



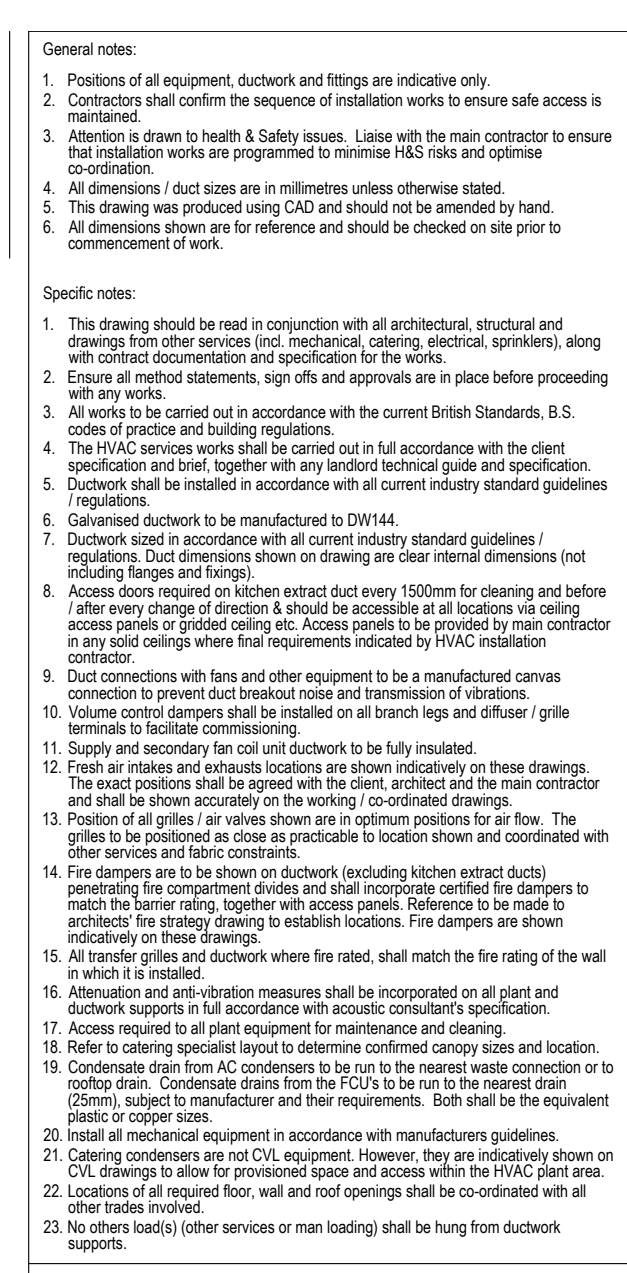

METERAGE	
SUPPLY DUCTWORK	0.0m
WC EXTRACT DUCTWORK	0.0m
AC PIPEWORK	0.0m
<i>Quantities are for this sheet only</i>	

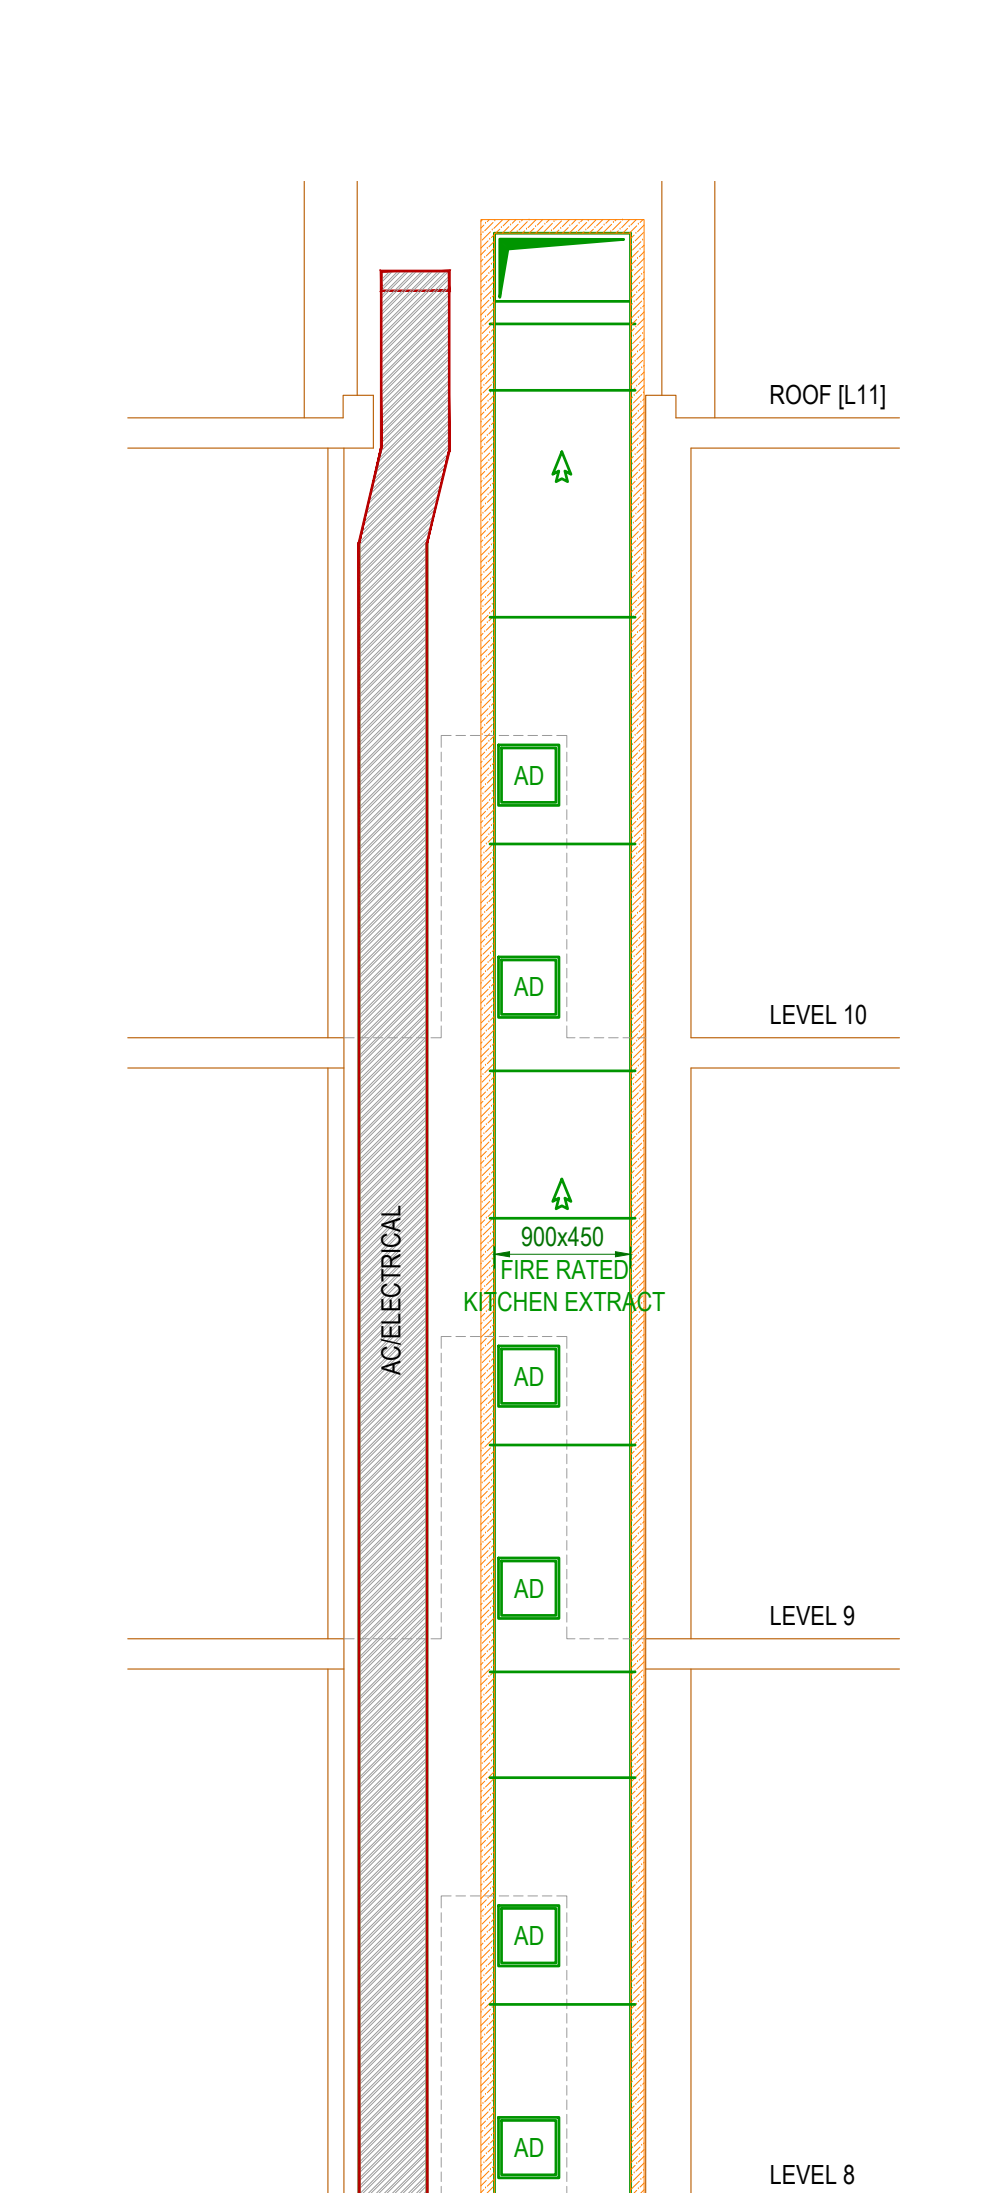

RISER ELEVATION LEVEL 8-R

H	5:28	NO	RECORD WORKING
G	4:30	NO	KITCHEN EXTRACT REVEALED A RISER SHIP TO SUIT EXISTING GROUND. TWO CANOPIES WAS REQUIRED TO EXTRACT AND SUIT TO SUIT
F	30:25	NO	KITCHEN TUBOY EXTRACT REVEALED MAIN KITCHEN TUBOY EXHAUST HAY RECOVERY UNIT REVEALED MAIN KITCHEN SUPPLY AIR TUBOY CANOPIES REVEALED. NEW SUPPLY AIR EXTRACT SYSTEMS ADDED TO KITCHEN AREA AND JORDAN WAS ROOF REMOVED.
E	19:24	NO	MSO ADDED TO TUBOY EXHAUST, WHICH WAS USED TO EXHAUST SMOKE FROM KITCHEN SUPPLY. ENHAY HEAT RECOVERY AND HEATING COILS ADDED
D	14:14	NO	TEST AREA ADDED TO LATEST ARCHITECTS LAYOUT. CANOPY REVEALED TO SUIT EXISTING GROUND
C	8:14	NO	CANOPY REMOVED. UO FILTERS REMOVED AND RELOCATED TO SUIT 2000L FPH BACKGROUND POLLUTION
B	26:24	NO	BACK OF HOUSE GRILL EXHAUST AND AC UNIT RELOCATED TO SUIT EXISTING GROUND. SUPPLY ADDED TO KITCHEN GRILL EXHAUST AND RELOCATED TO SUIT. UO FILTERS ADDED TO FUTURE UOY SPOON AND ALTERATIONS TO SPOON EXHAUST SYSTEMS
A	24:24	NO	SUPPLY AND EXTRACT TUBOYS TO CONNECT TO EXISTING LANDSCAPE WAS. TUBOY EXTRACT FAN FIBER RELOCATED TO SUIT EXISTING GROUND. UO FILTERS ADDED TO EXISTING DRAINING DRAINAGE AREA AS FAN COILS REVEALED TO SUIT THE LATEST RCP

No.	Date	By	Revision Description
Client:			

BIG MAMMA
STUDIO

Project :
2306 - MANCHESTER

Drawing Title :

FIRST FLOOR
AIR CONDITIONING AND
VENTILATION LAYOUT

Drawing No.:	Rev:
001-1204-02	RECORD

Scale: 1:50 @ A0 1:100 @ A2		
Drawn By: KDM	Checked By: -	Date: 04.04.24

chapman
ventilation

15-20 Woodfield Road, Welwyn Garden City
Hertfordshire AL7 1JQ
Tel: 01707 372888 Fax: 01707 325001
E-mail: info@subconcrete.co.uk

