



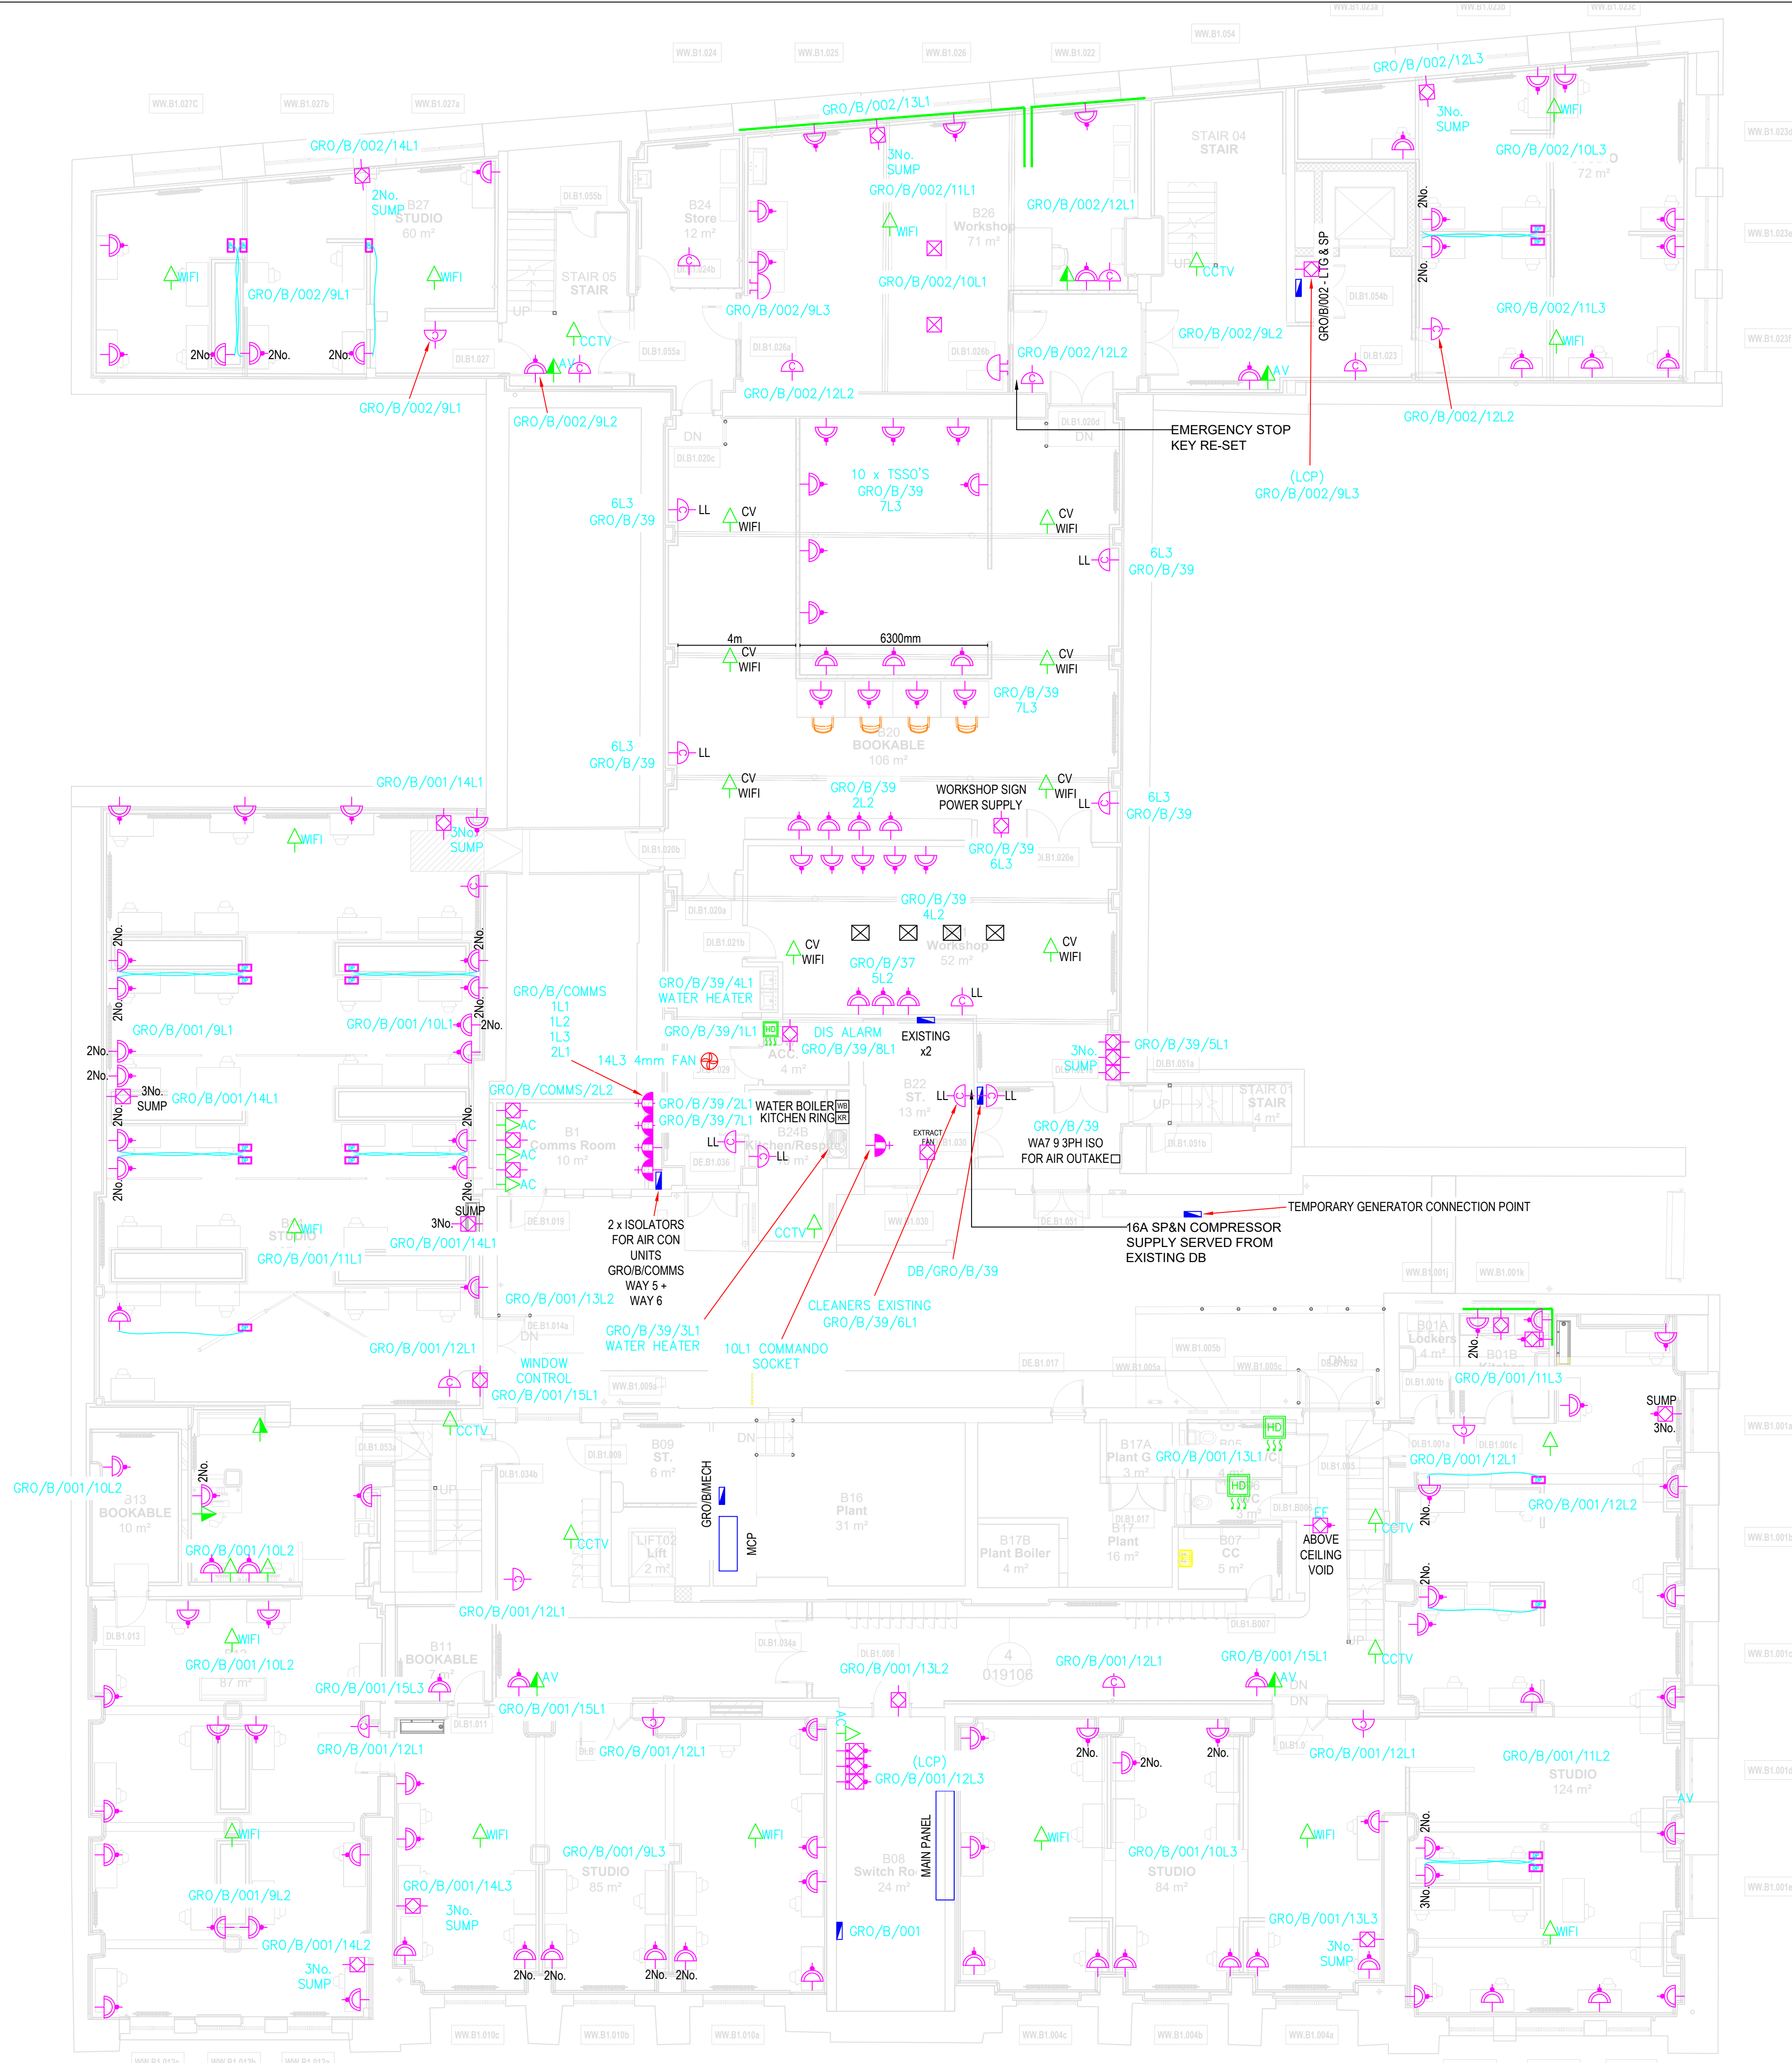

- LEGEND**
- 13A TWIN SWITCHED SOCKET OUTLET
 - 16A SWITCHED COMMANDO SOCKET
 - 13A CLEANERS SOCKET C/W RCD PROTECTION
 - FLOOR BOX - 3 No. TSSO AND 4 No. DATA
 - 13A SWITCHED FUSED CONNECTION UNIT C/W FLEX OUTLET + SINGLE SOCKET OUTLET
 - 13A SWITCHED FUSED CONNECTION UNIT
 - 13A SWITCHED FUSED CONNECTION UNIT
 - DESK POWER UNIT WITH 2No. OUTLETS
 - HDMI OUTLET
 - LIGHT SWITCH LOCATED ON SAME DROP AS SMALL POWER
 - DOUBLE DATA OUTLET
 - SINGLE DATA OUTLET
 - 3 COMPARTMENT DADO TRUNKING DROP
 - 3 COMPARTMENT DADO TRUNKING 100MM AFFL
 - 3 COMPARTMENT SKIRTING TRUNKING
 - HAND DRYER C/W HIGH LEVEL SWITCHED FUSED SPUR
 - SMALL POWER & DATA SYSTEMS
- OUTLET REFERENCE**
- AC OUTLET DEDICATED TO ACCESS CONTROL
 - AV OUTLET DEDICATED TO AV SYSTEM
 - IA OUTLET DEDICATED TO INTRUDER ALARM
 - EF OUTLET DEDICATED TO EXTRACT FAN
 - FAP OUTLET DEDICATED TO FIRE ALARM PANEL
 - DR OUTLET DEDICATED TO DISABLED REFUGE ALARM
 - WCA OUTLET DEDICATED TO WC ALARM
 - CCTV OUTLET DEDICATED TO CCTV CAMERA

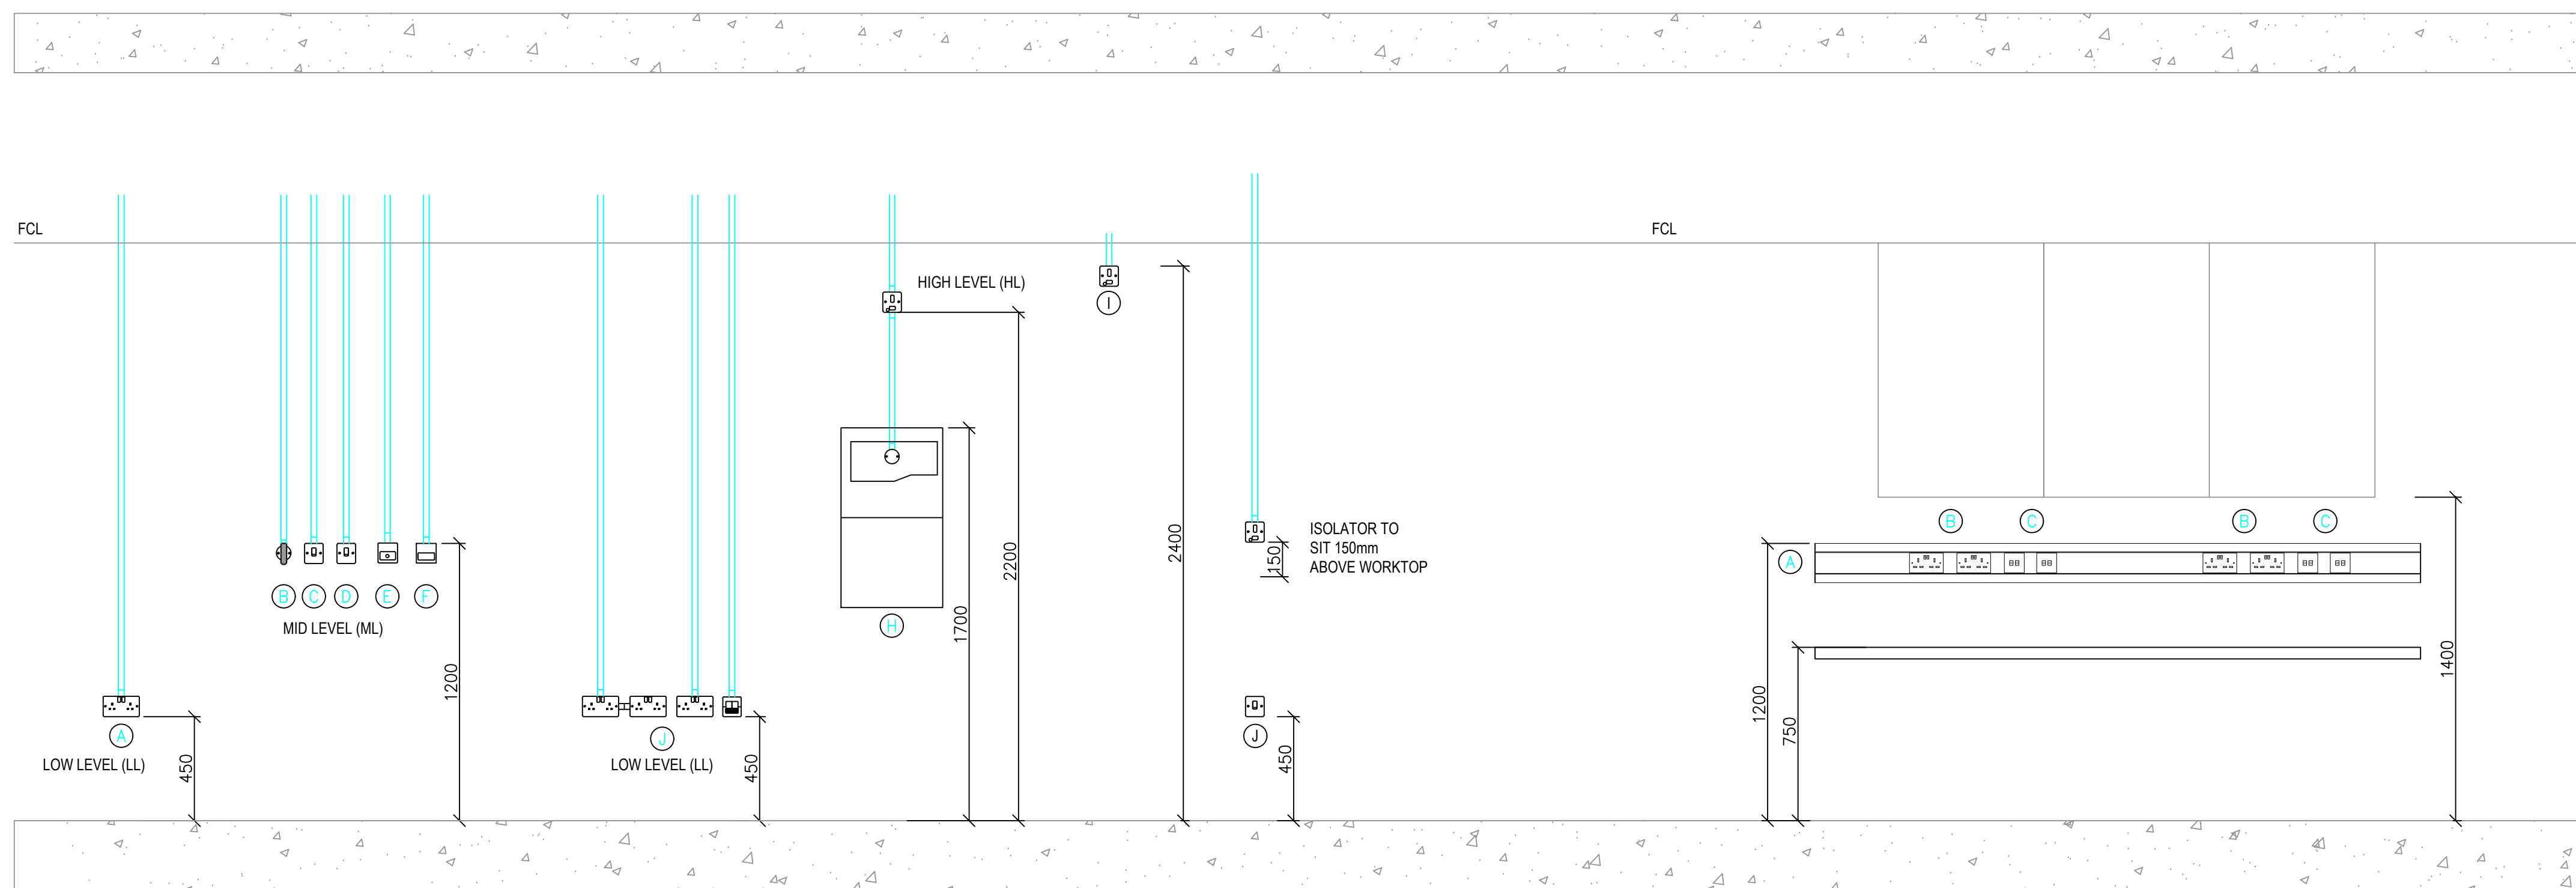

- CLEANERS/GENERAL PURPOSE SOCKET
- SWIPE CARD READER DOOR ACCESS CONTROL
- EGRESS BUTTON DOOR ACCESS CONTROL
- LIGHT SWITCH
- MANUAL CALL POINT AND STI STOPPER
- BREAK GLASS DOOR ACCESS CONTROL
- LOW LEVEL SOCKET OUTLETS
- FIRE ALARM/INTERCOM/SECURITY PANEL
- HIGH LEVEL FUSED SPUR
- SOCKET AT LOW LEVEL WITH ISOLATOR ABOVE WORKTOP

STANDARD DETAIL OF MOUNTING HEIGHTS
Scale 1:20

TYPICAL DADO MOUNTING HEIGHTS
Scale 1:20

- GENERAL DADO
- TWIN SOCKET OUTLET
- DOUBLE DATA OUTLET

- AS FITTED -



**GROSVENOR BUILDING
LIFESTYLE REFURBISHMENT**

**ELECTRICAL SERVICES SMALL POWER &
DATA LAYOUT BASEMENT**

SCALE: 1:100 @ A0 DATE: JUNE 2024 DRAWN BY: M WILSON
C10446-CBL-XX-B1-DT-E-030001 REV: AF