



BUILDING SERVICES ENGINEERS
LIVERPOOL

ALL RIGHTS RESERVED © COPYRIGHT A&B ENGINEERING (M.S.D) LTD
& A&B ENGINEERING (E.S.D) LTD.

REVISION	ITEM REVISED	DATE
P01	Preliminary Issue	03/09/2021
P02	Revised In line with comments	08/10/2021
P03	Revised In line with comments	31/05/2022
P04	Revised In line with comments	18/08/2022
C01	Construction Issue	23/06/2023
C02	Construction Record	16/09/2025

NOTES:

CONSTRUCTION RECORD

CLIENT

Manchester City Council

ARCHITECT

Fletcher Rae

PROJECT

Hammerstone Road Depot Refurbishment

TITLE

Electrical Service -
External
Lighting Plots Layout

STATUS

CR Construction Record

DRAWN BY

J.H

CHECKED

M.B

DATE

17/05/2021

SCALE @A1

1 : 500

A&B PROJECT No

8834

FILE DRAWING NUMBER


HRD-ABE-00-00-DR-E-7006

REV

C02



Holly Terrace • 9-17 Derby Lane
Old Swan • Liverpool • L13 6QA
tel: 0151 228 4661 • fax: 0151 220 4206
email: info@abeng.co.uk • website:
www.abeng.co.uk

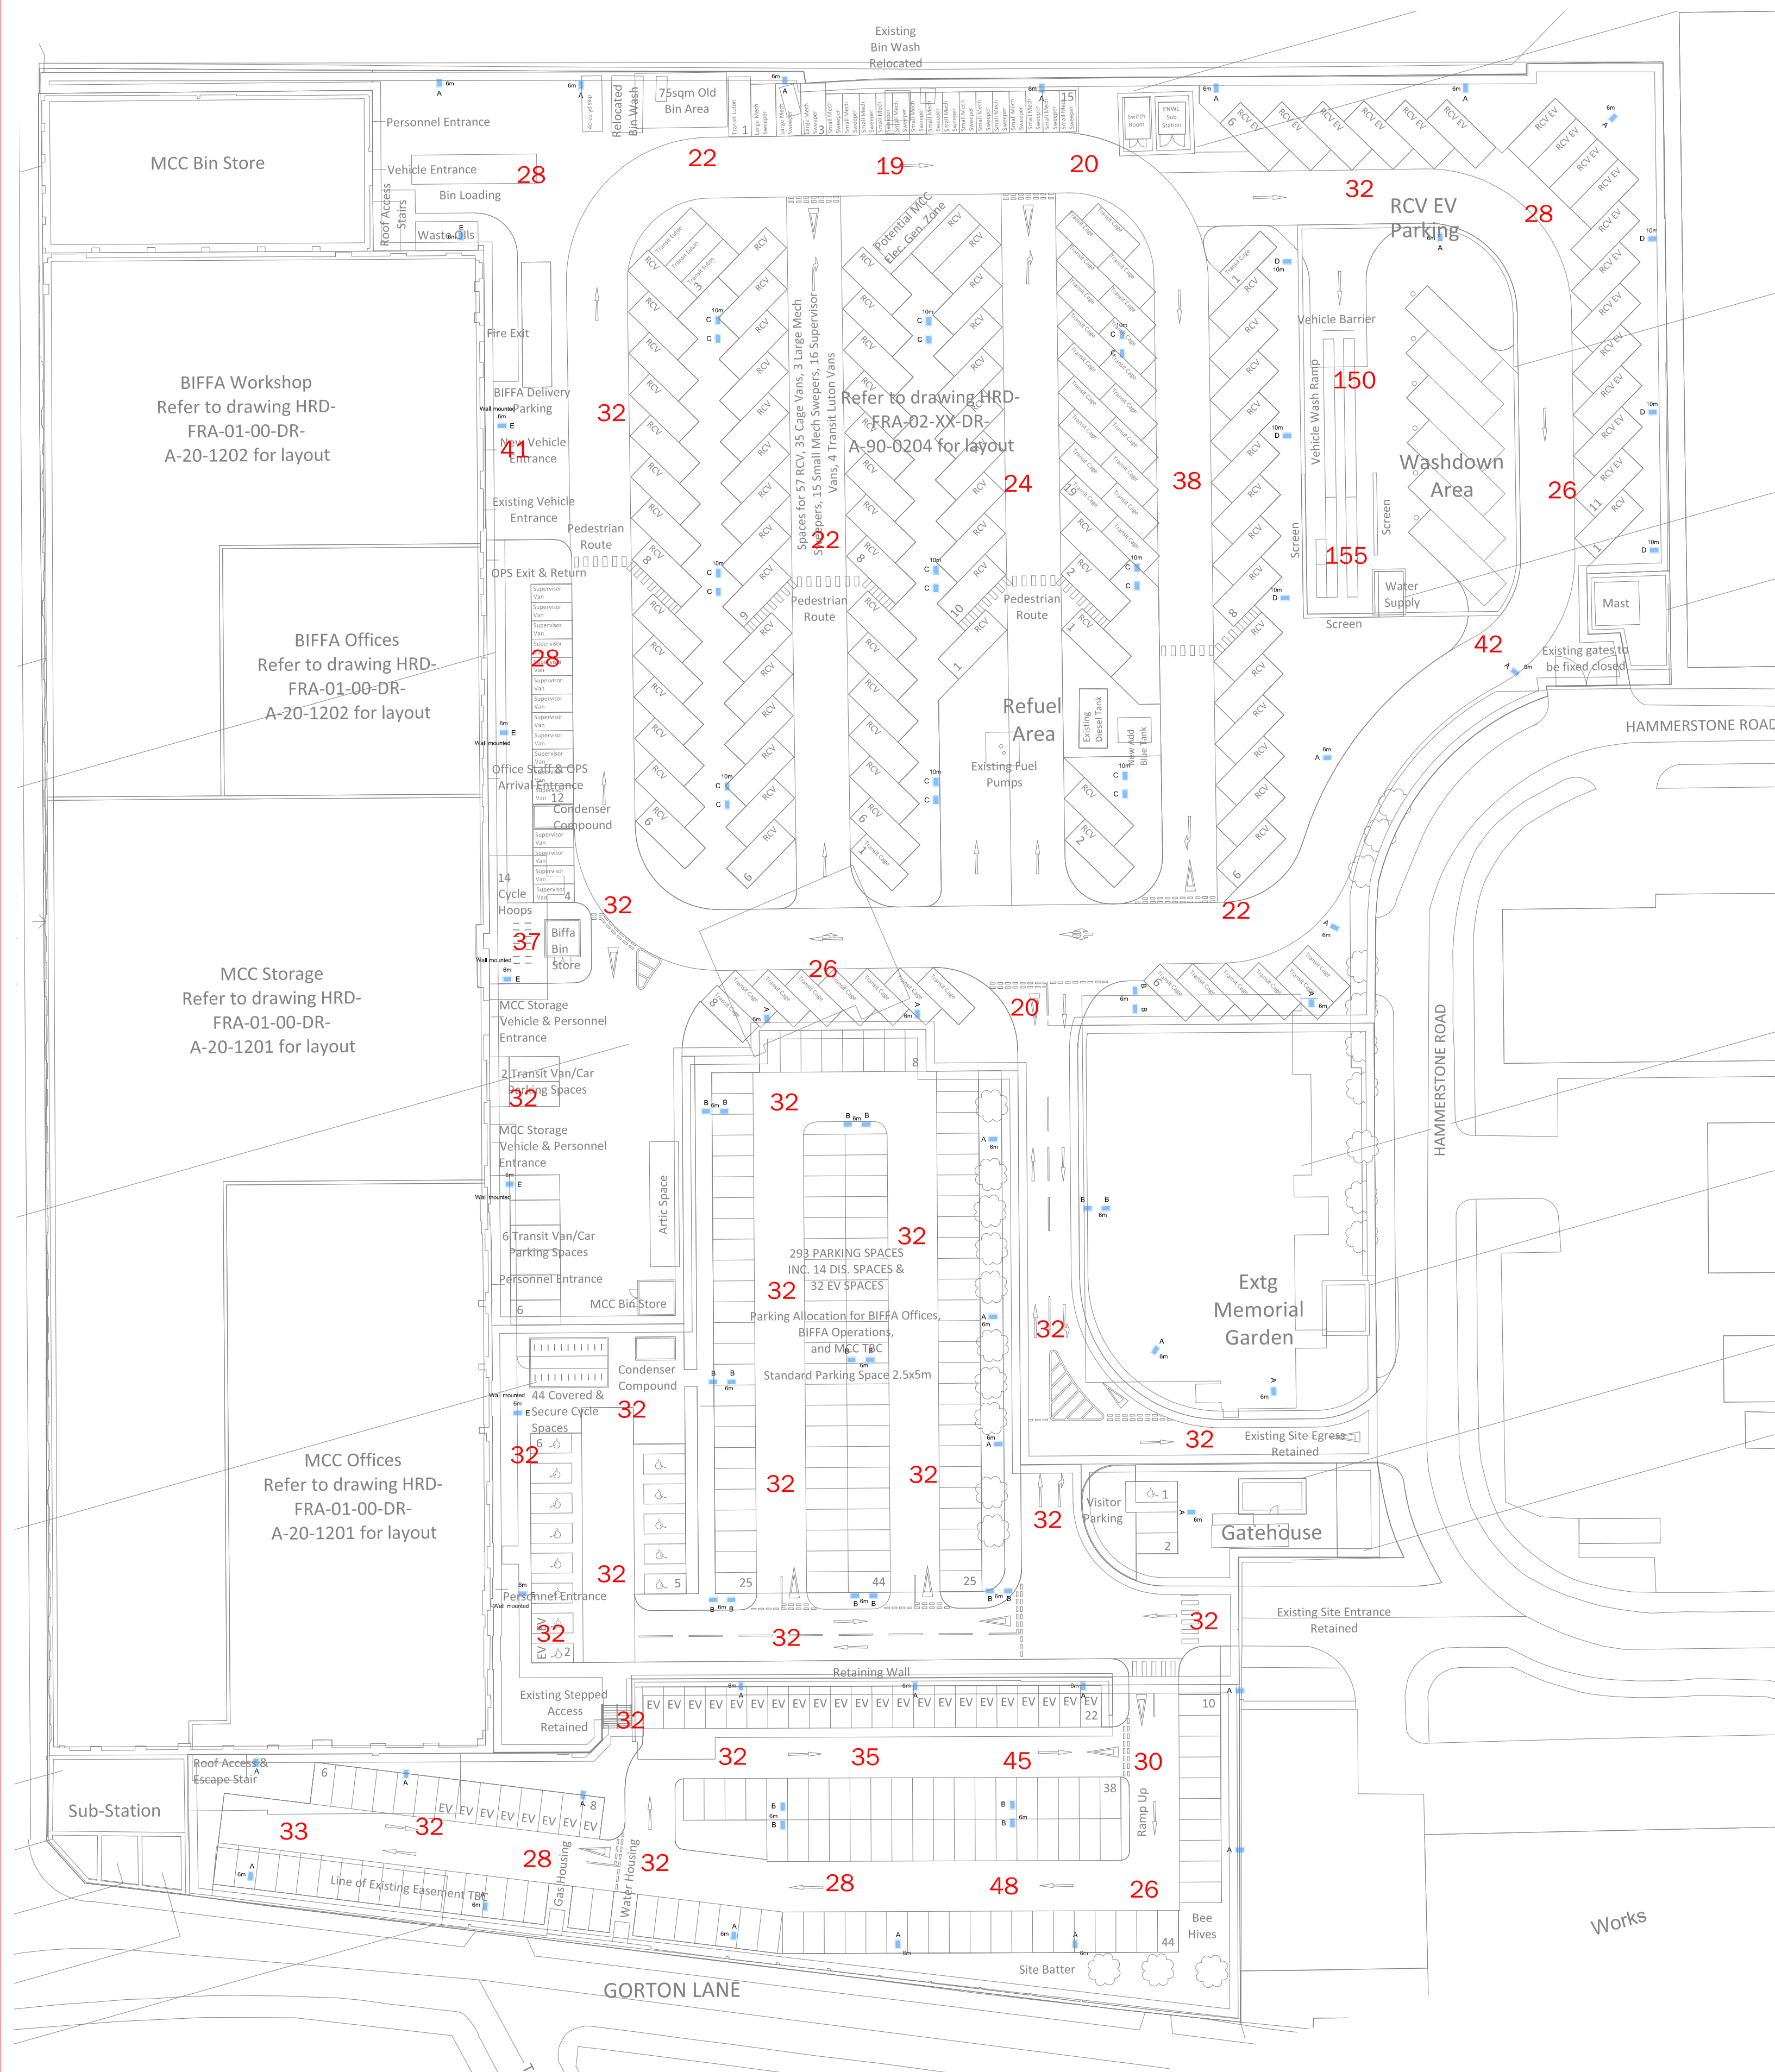

External Lighting Plot Layout
Scale 1:500

Luminaire Schedule							
Symbol	Qty	Label	Arrangement	Description	Tag	Luminaire Lumens	Luminaire Watts
	35	A	SINGLE	SIROCCO MIDI 100W LED 4k	A	4571	33
	12	B	BACK-BACK	SIROCCO MIDI 100W LED 4k	B	4571	33
	9	C	BACK-BACK	SIROCCO MIDI 100W LED 4k	C	9141	67
	6	D	SINGLE	SIROCCO MIDI 120W LED 4k	D	13712	100
	7	E	SINGLE	SIROCCO MIDI 100W LED 4k	E	9141	67