



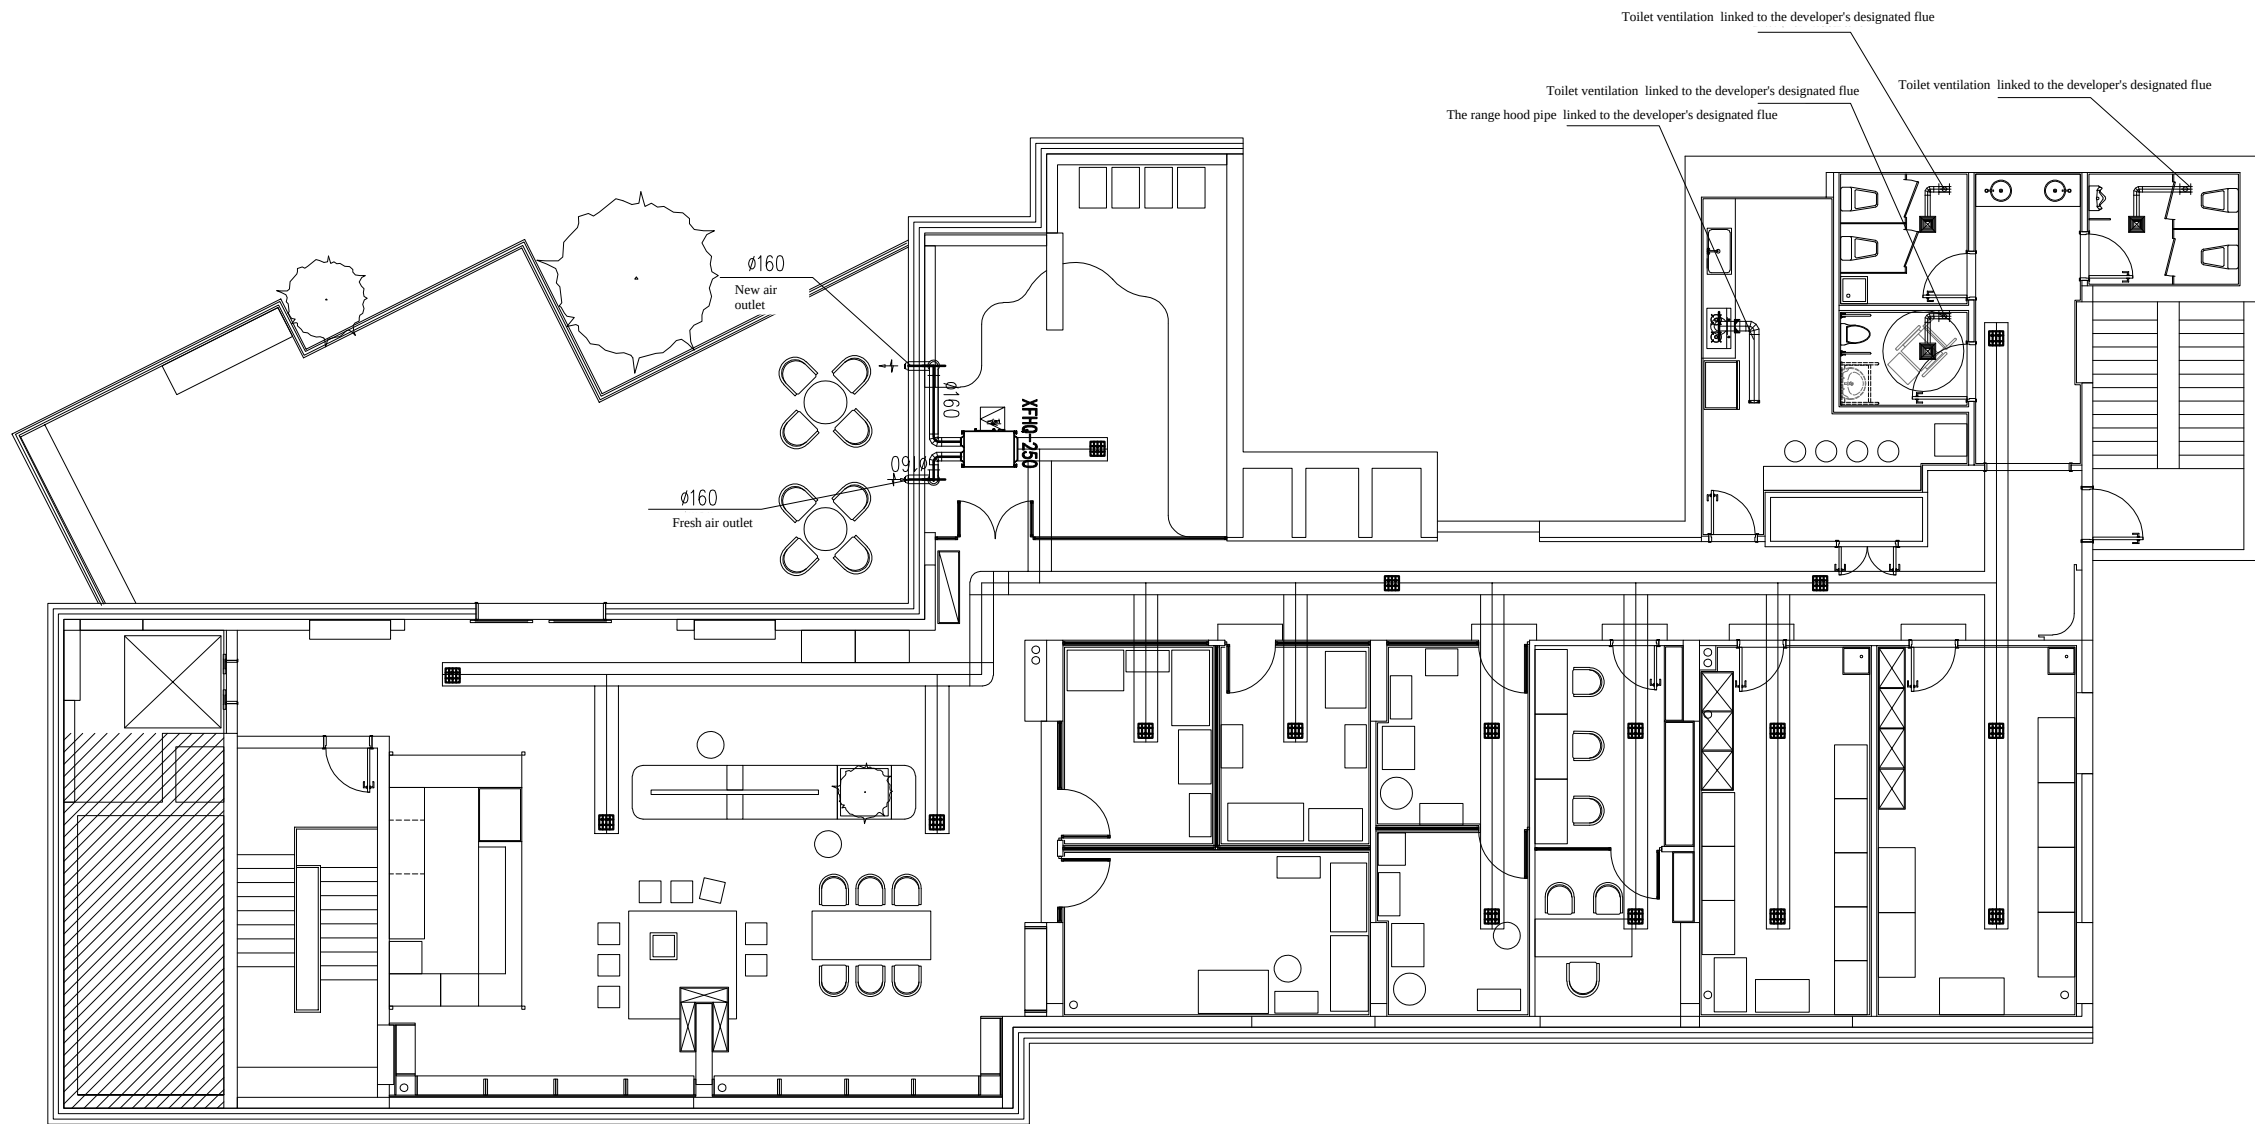

Lollipopaws club

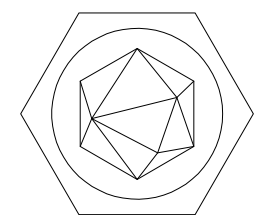

J I U J I Z H U A N G S H I

Freshair ventilation layout plan
on the second floor

SCALE:	1:140
DATE:	2025.3.23
SHEET NO.	
DESIGN BY:	
DRAWN BY:	
APPROVED BY:	

FIRST PARTY: