

Notes.

- 1 All dimensions are in millimetres unless noted otherwise.
- 2 All levels are in metres unless noted otherwise.
- 3 This drawing is to be read in conjunction with all relevant Architects and Service Engineers drawings.
- 4 Manholes to be precast concrete rings to BS 5911 min 1200 dia u.n.o.
- 5 All Manhole covers to be Grade B125 in footpaths/ soft landscaping or D400 in trafficked areas to BS EN 124. All manhole covers to be recessed type.
- 6 Invert levels quoted are exit inverts.
- 7 PVC pipes with cover of less than 900mm under road/cowslad and 600mm under landscaped areas to be encased in concrete bedding class S
- 8 All RWP's & SVP's to have roddable access covers.
- 9 Installation of manholes, road gullies, pipes, channels etc to be as per the manufacturer's instructions and recommendations.
- 10 Proposed SW pipes to be 1000dia u.n.o.
- 11 Proposed FW pipes to be 100dia u.n.o.
- 12 All drainage to comply with the requirements of BS8301 & Building Regulations part H.
- 13 Drainage channels to be Aco Multidrain MD100, or similar approved design/ spec/ installation to be in accordance with manufacturer's details. Gating to be D400, final type TBC.

Rev	Drawn	Date	Description
T4	RH	05/20	Minor amendments
T3	RH	05/20	Revised scheme
T2	SB	12/19	Updated to latest information

TENDER

Contract
UNITY COMMUNITY SCHOOL
EXTENSION

Drawing Title

**BELOW GROUND DRAINAGE
LAYOUT**

integra
consulting

Office 4
11-32 Merrit Street
Macclesfield
M13 4BS

Civil & Structural Engineers

Tel : 0161 237 3400
Fax : 0161 237 3635
Email : manchester@integraconsulting.co.uk


Web : www.integraconsulting.co.uk

All floor gullies to be trapped, double
seals & odour trapped

For typical drainage details refer to Integra drawings 3205–1.06.

Location / Number of SVP's & RWP's
indicative only, tbc by Architect / M&E
Engineer.

All new manhole & inspection chambers to have recessed covers to accommodate external finishes.

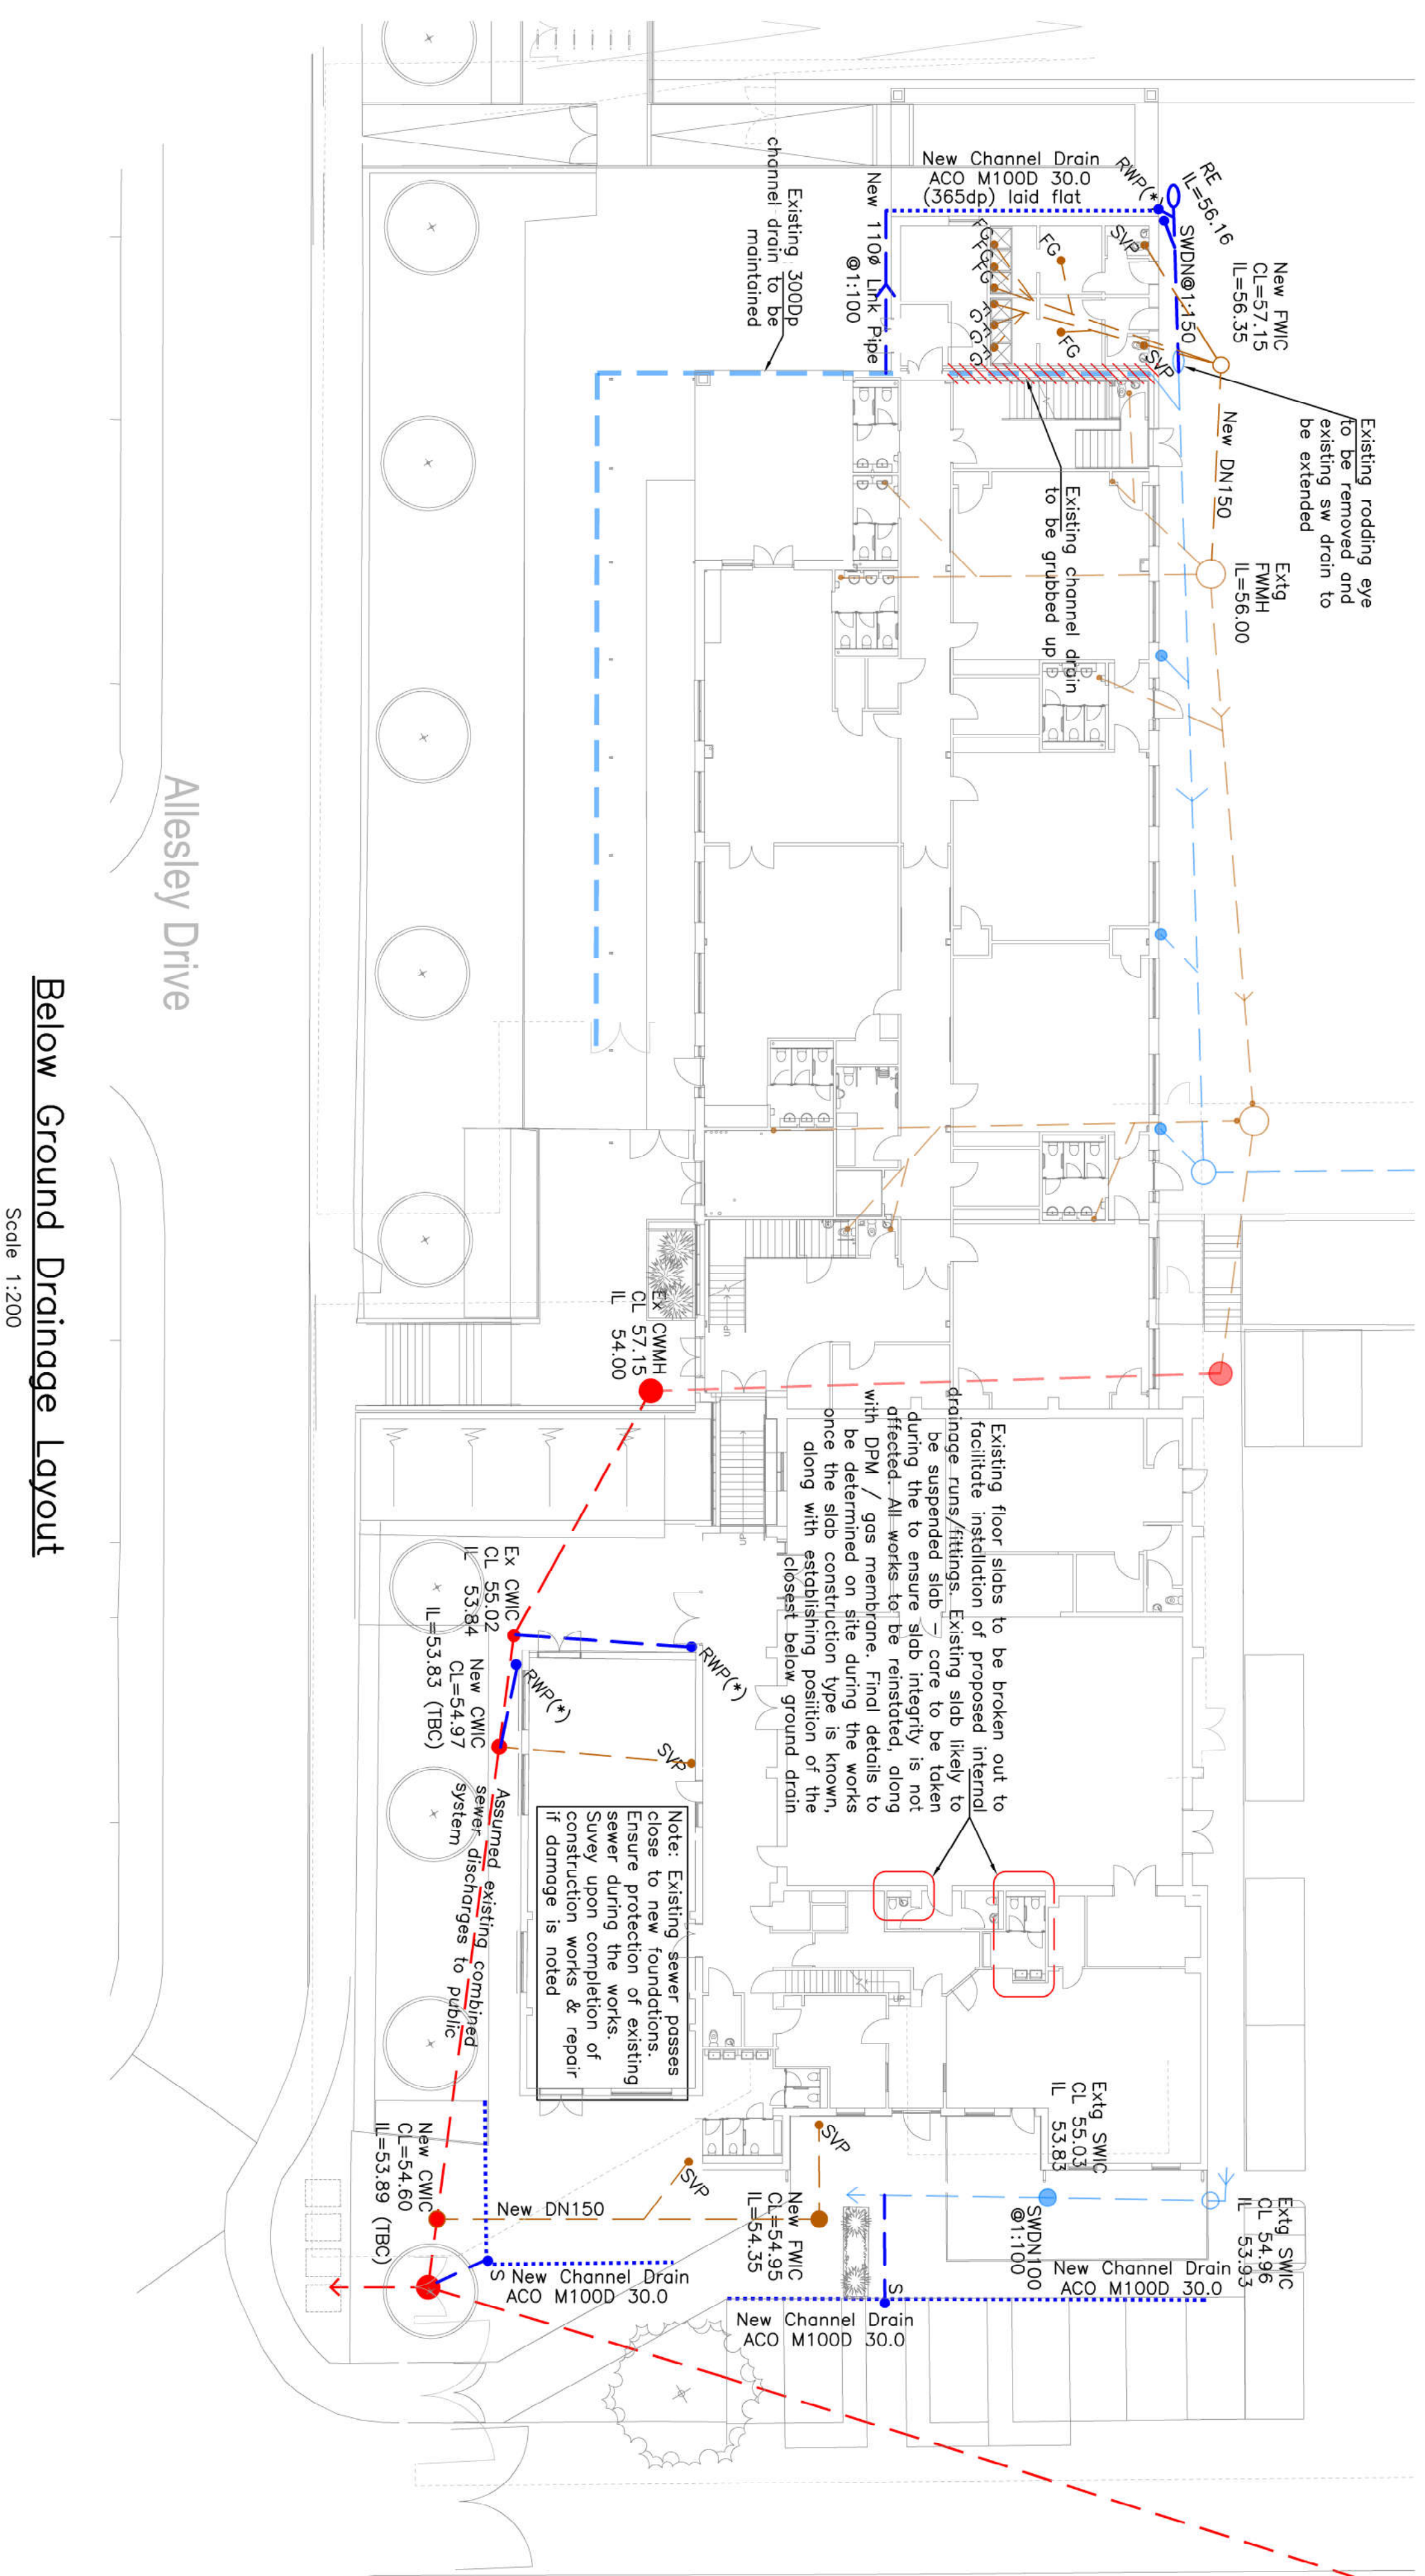

Below Ground Drainage Layout

Scale 1:200

Drainage Legend

- | | |
|---|---|
|  | SMWH – New Surface Water Manhole |
|  | RE – New Rodding Eye |
|  | RWP(*) – New Rain Water Pipe (Assumed located |
|  | BD – New Backdrop into Existing Manhole |
|  | FMMH – New Foul Water Manhole |
|  | FWIC – New Foul Water Inspection Chamber |
|  | SVP – New Soil Pipe (final positions TBC) |
|  | FG – New Foul Gully (final positions TBC) |
|  | New Aco Channel (or similar approved) |
|  | New Surface Water Drain |
|  | New Surface Water Drain |
|  | CMMH – Existing Combined Water Manhole |
|  | RE – Existing Rodding Eye |
|  | RWP – Existing Rain Water Pipe |
|  | FMMH – Existing Foul Water Manhole |
|  | Existing Combined Drain |
|  | Existing Channel Drain |
|  | Existing Surface Water Drain |
|  | Existing Foul Water Drain |