


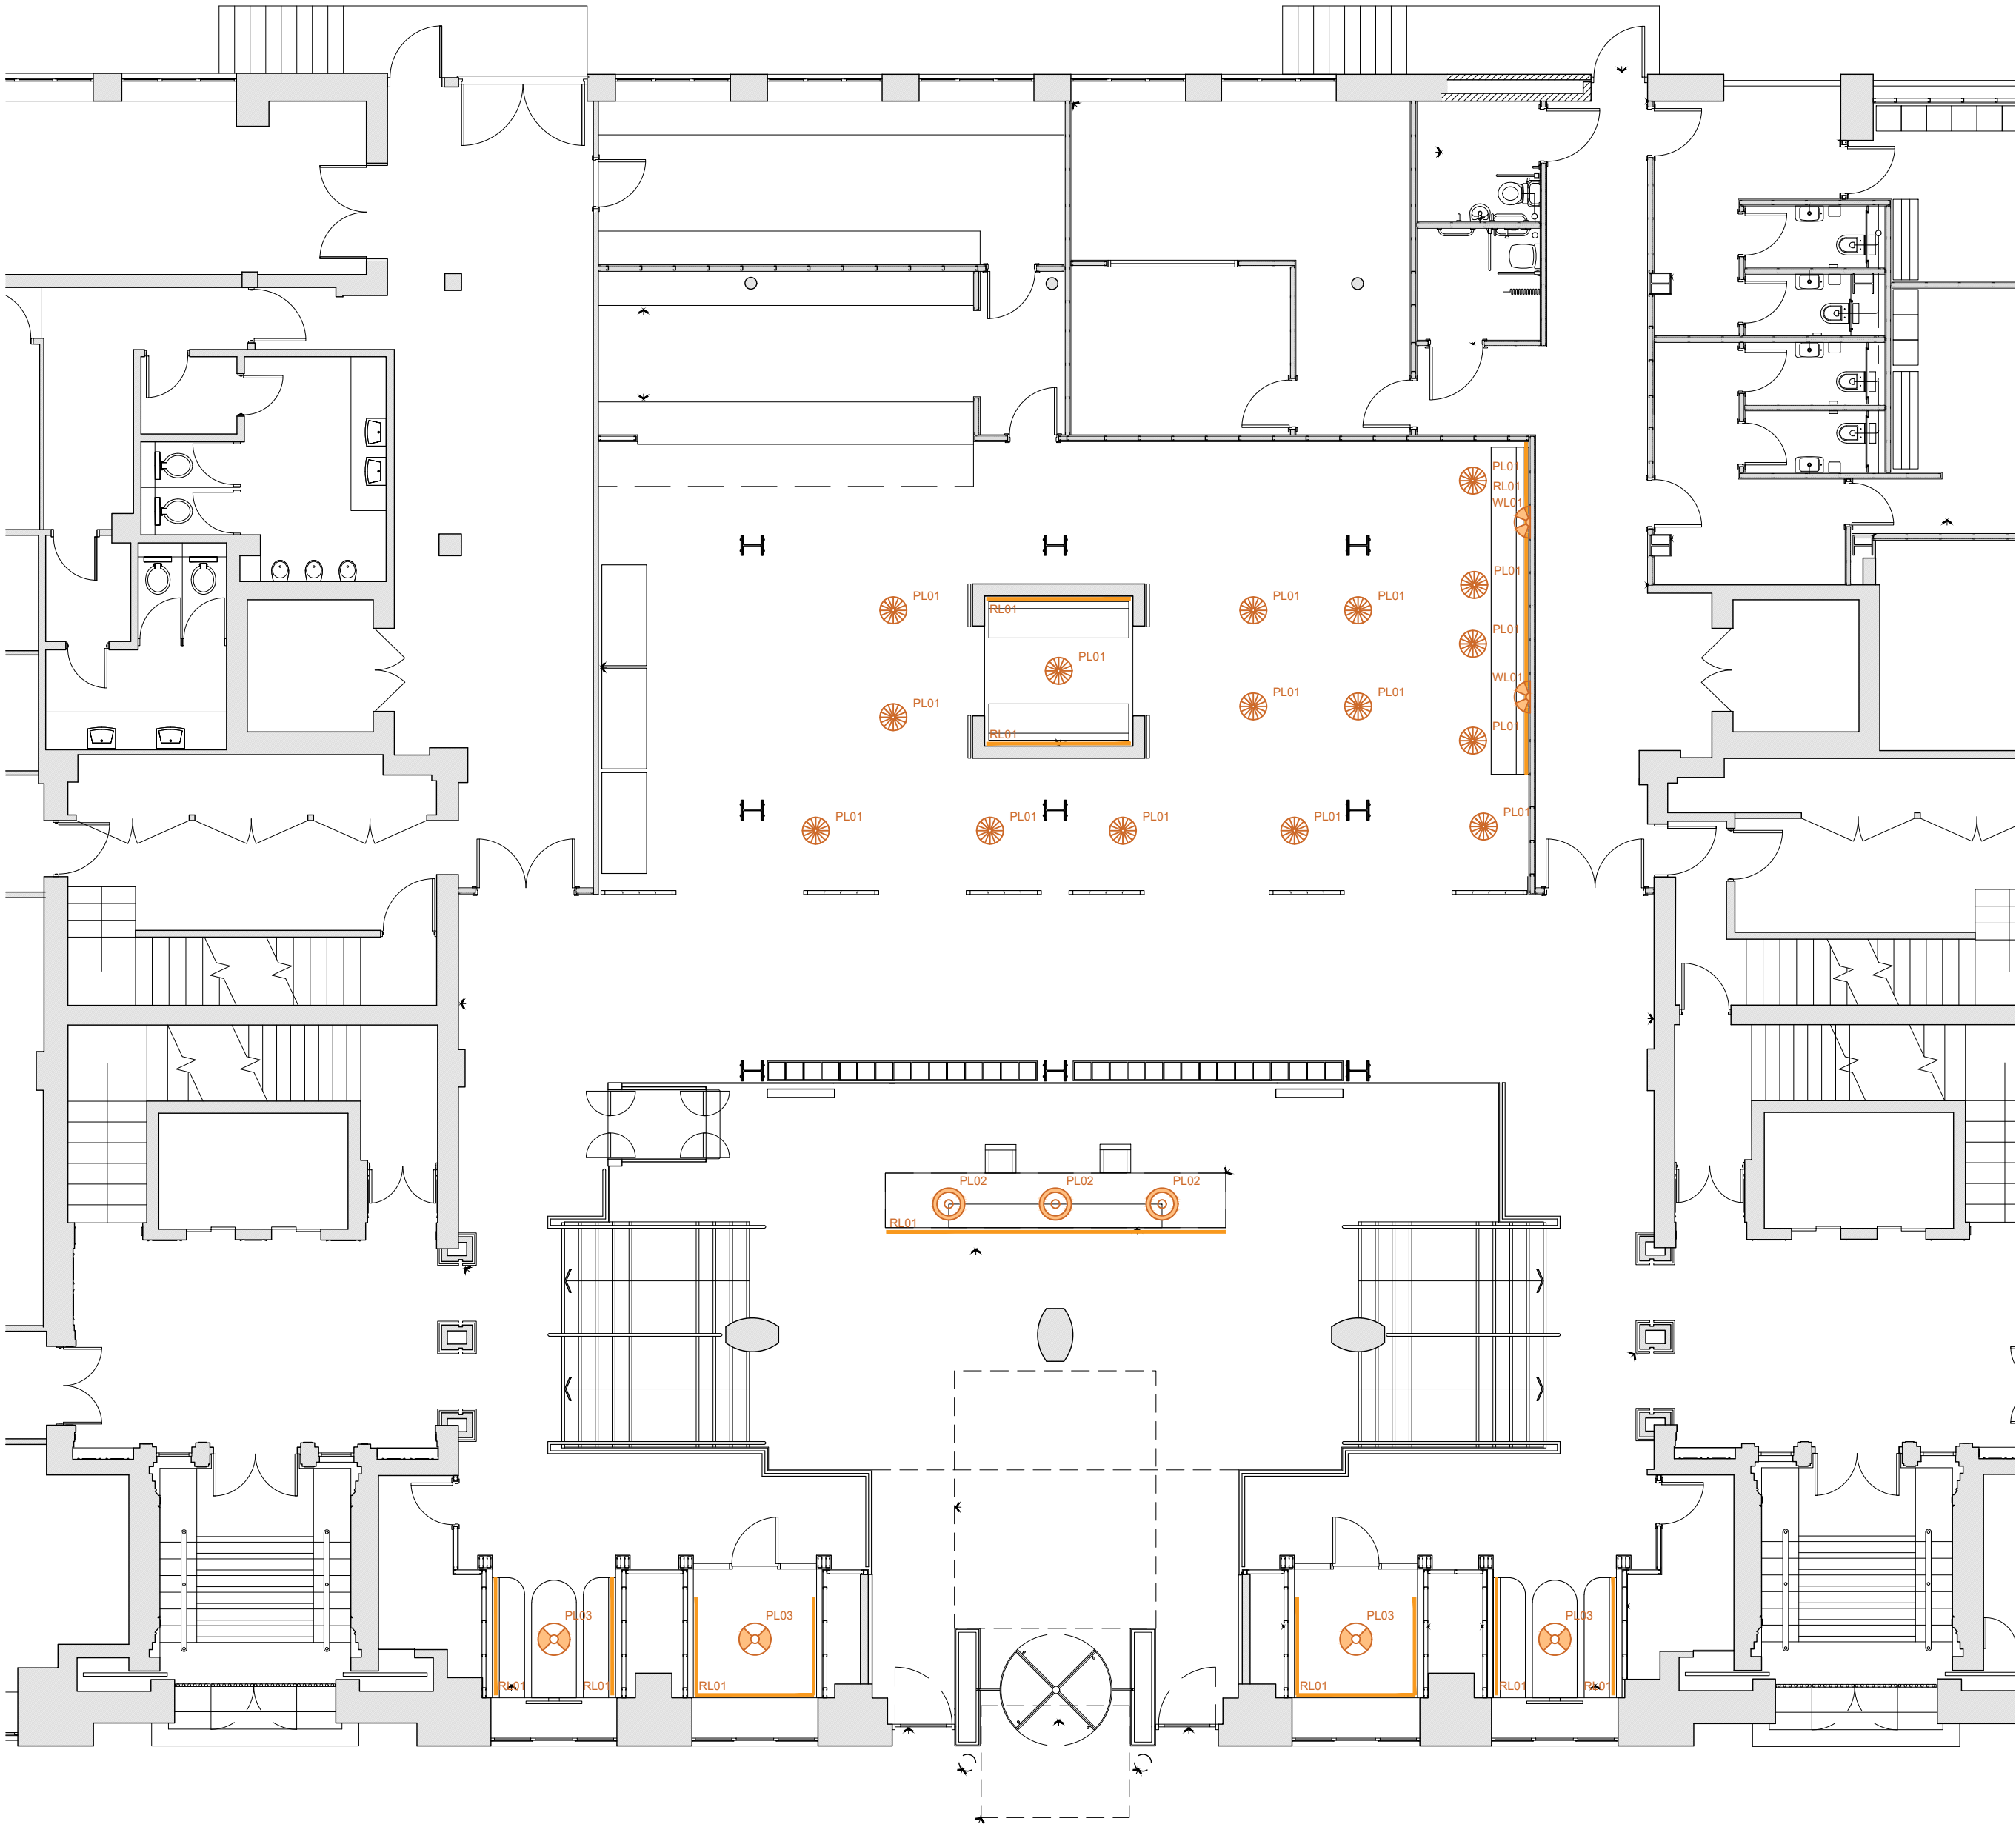

Do not scale off this drawing. All dimensions to be checked on site prior to manufacture and construction. This drawing is the property of The Friday Project and should not be reproduced without permission. All discrepancies to be brought to the attention of the architect immediately. This drawing to be read in conjunction with the specification / bill of quantities and related drawings.

REVISION			
-	FIRST ISSUE	13.07.25	LA
A	LIGHTING SPECIFICATION ADDED TO DRAWINGS	14.07.25	LA
B	DROPPED CEILING ADDED TO CAFE LIFT SHAFT BOOTH	15.07.25	LA
C	DROPPED CEILING IN LIFT SHAFT REMOVED AS ONE EXISTS ALREADY. BOOTH PENDANT REFERENCE UPDATED	17.07.25	LA
D	PLAN UPDATED	14.08.25	LA

LIGHTING KEY	
Pendant Symbol	Specification
 PL01	CAFE PENDANTS: Burford PL 300mm Ø with black mount and gold twisted flex. Globe to have applied banding. Lamps to be LED and warm white. Supplied by Optime Lighting T: 01462 441 920
 PL02	RECEPTION PENDANTS: Burford Bespoke 600mm Ø with black mount and gold twisted flex. Globe to have applied and layered banding and lettering. Lamps to be LED and warm white. Supplied by Optime Lighting T: 01462 441 920 Pendants to be centred over reception desk.
 PL03	BOOTH PENDANT: Beaumont pendant with black exterior and brushed brass interior with black twisted flex. Lamps to be LED and warm white. Supplied by Optime Lighting T: 01462 441 920 Pendant to be centered over booths.
 WL01	WALL LIGHT: Burford W2 150mm Ø with black mount. Globe to have applied banding. Lamps to be LED and warm white. Supplied by Optime Lighting T: 01462 441 920
 RL01	BOOTH & BANQUETTE SEAT: LED tape / rope light fitted to the capping at the back of the booth and banquette seating, to be concealed from view. LED to be warm white. Supplied by Electrical Contractor.
NOTES: - Mechanical ductwork to adjusted and adapted to suit new layout. - New lighting to be ordered and installed by electrical contractor in line with lighting manufacturers recommendations. - Pendants to be installed to 1800mm to underside. - Existing bulkhead to meeting booths to be retained and decorated. - Allow for alterations to the existing smoke detection and fire alarm system accordingly to suit alterations to the layout.	

APAM	client
BRIDGEWATER HOUSE 58-60 WHITWORTH STREET, M1 6LT	project
PROPOSED NEW DECORATIVE LIGHTING PLAN	title
VBC03	job No.
AL05 / D	dwg No.
1:100 @ A2	scale
LA	drawn

