




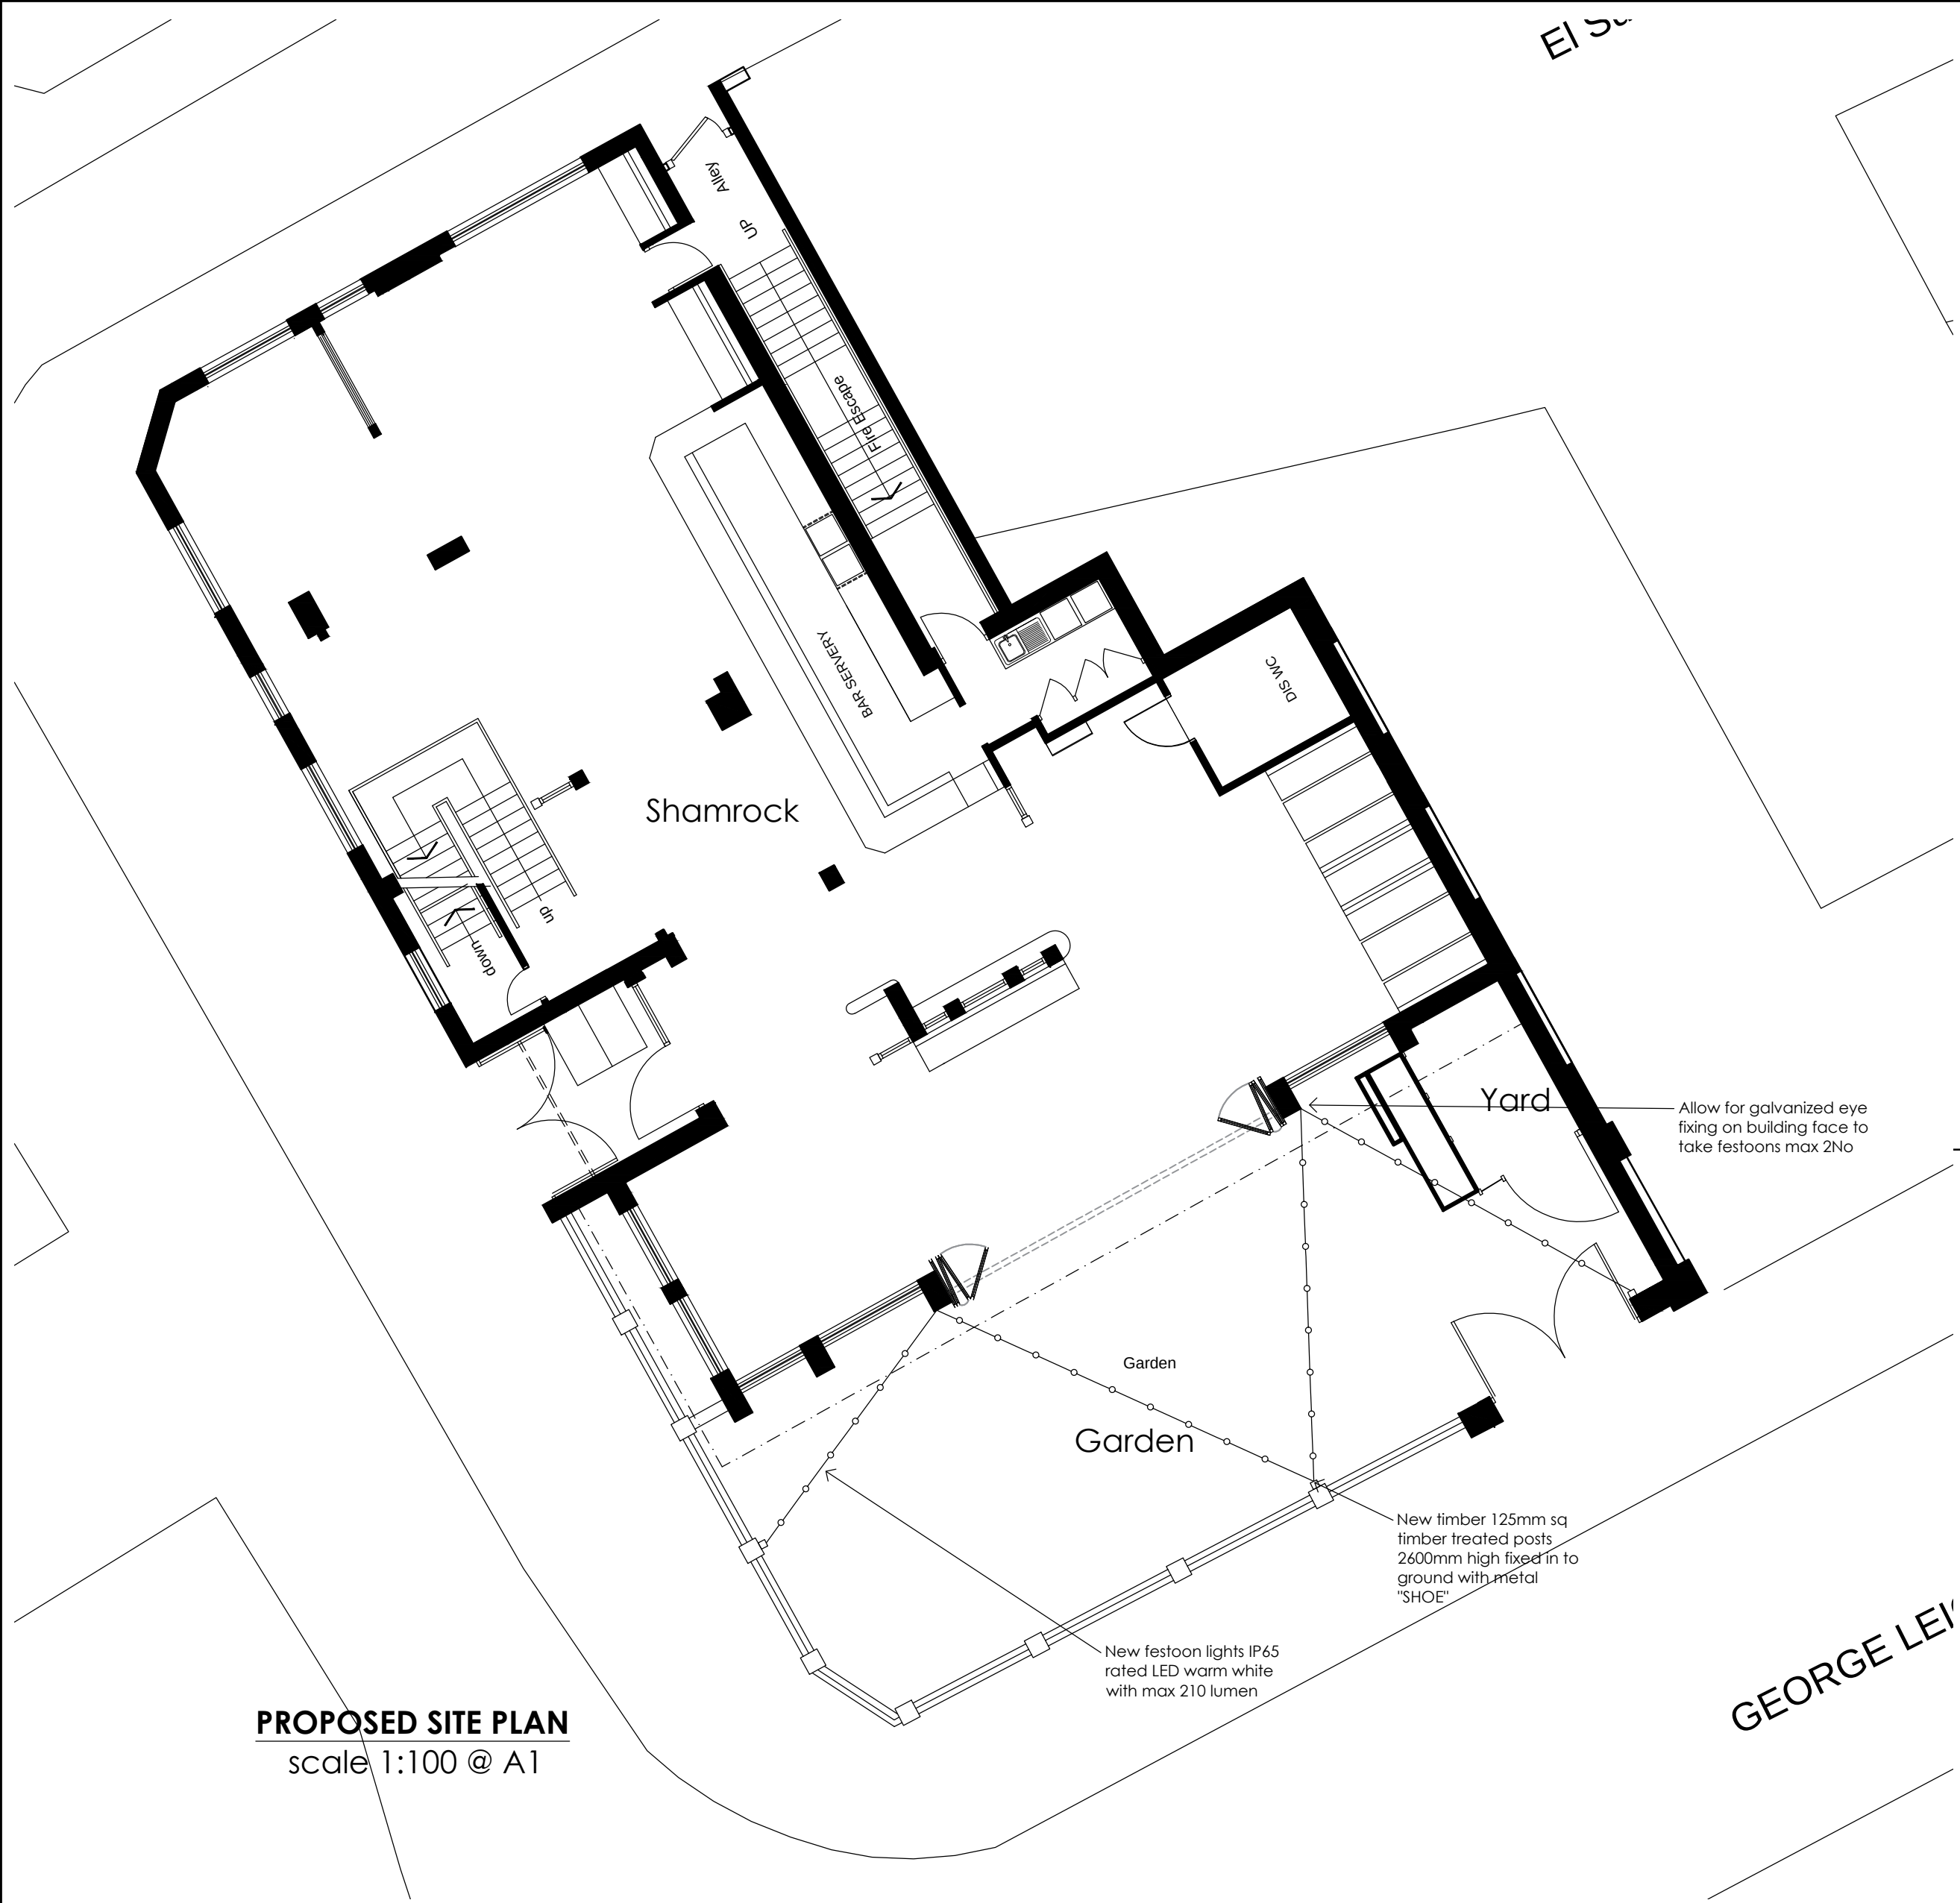

PROPOSED SITE PLAN
scale 1:100 @ A1

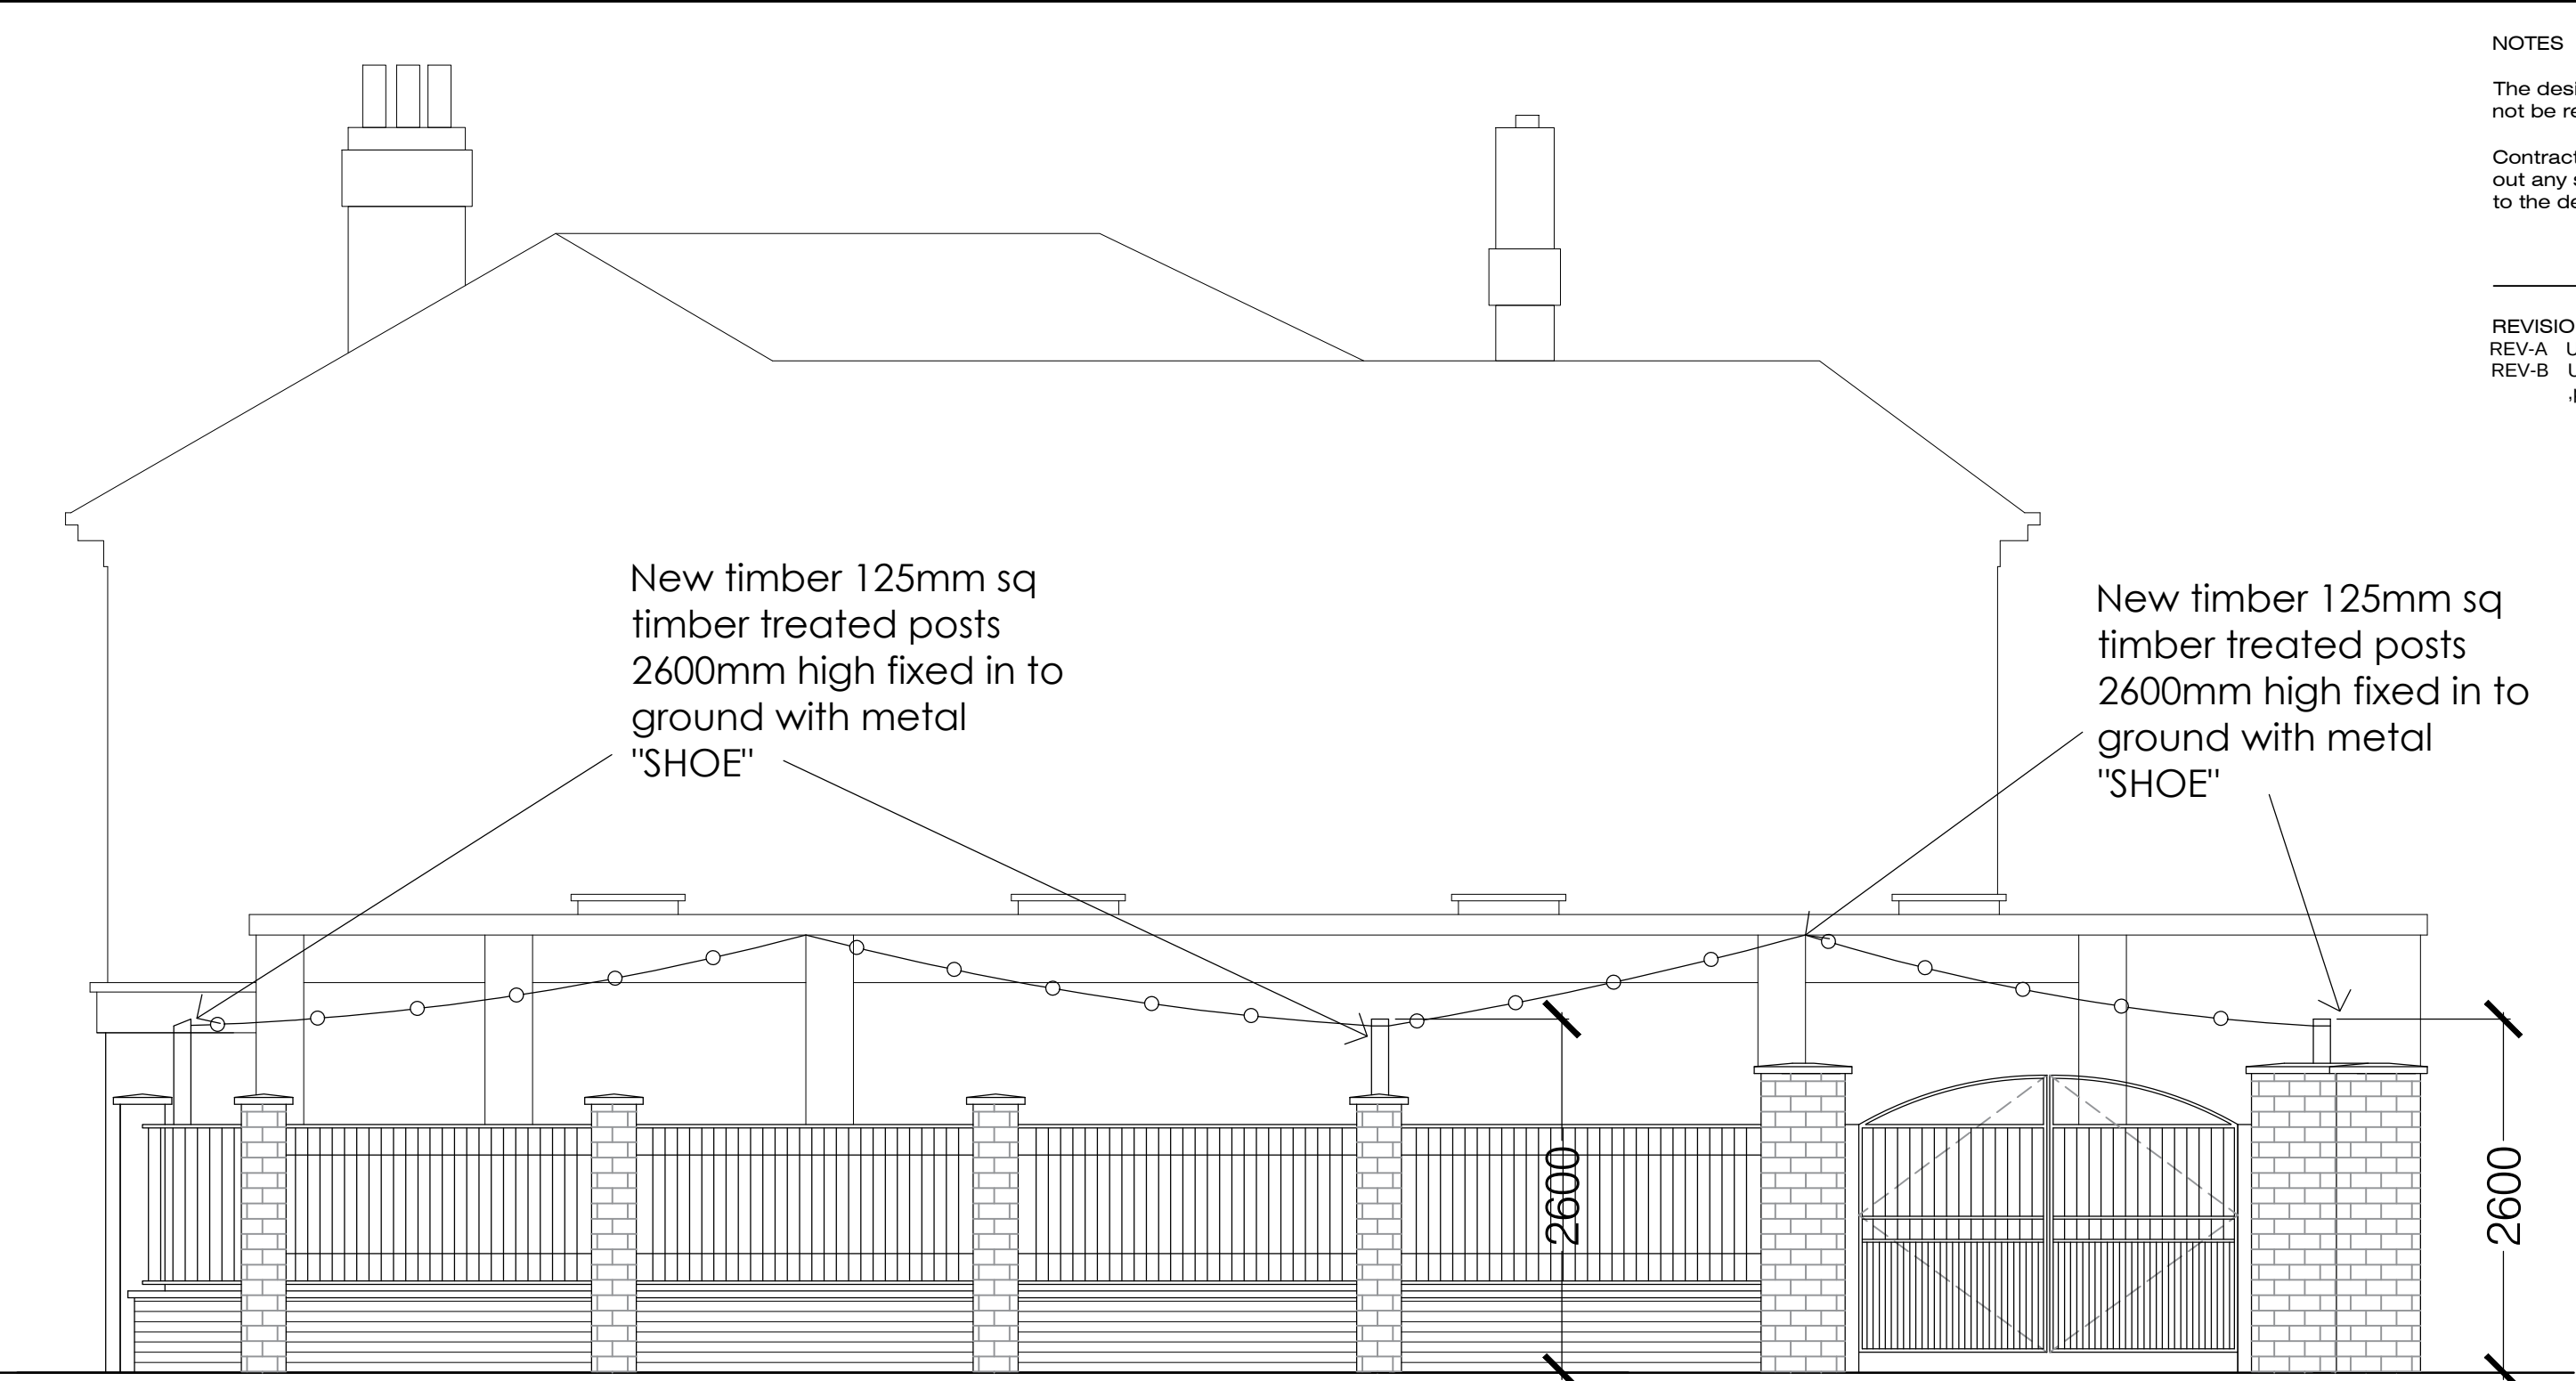

PROPOSED ELEVATION D - (George Leigh Street) Scale 1:100 @ A1

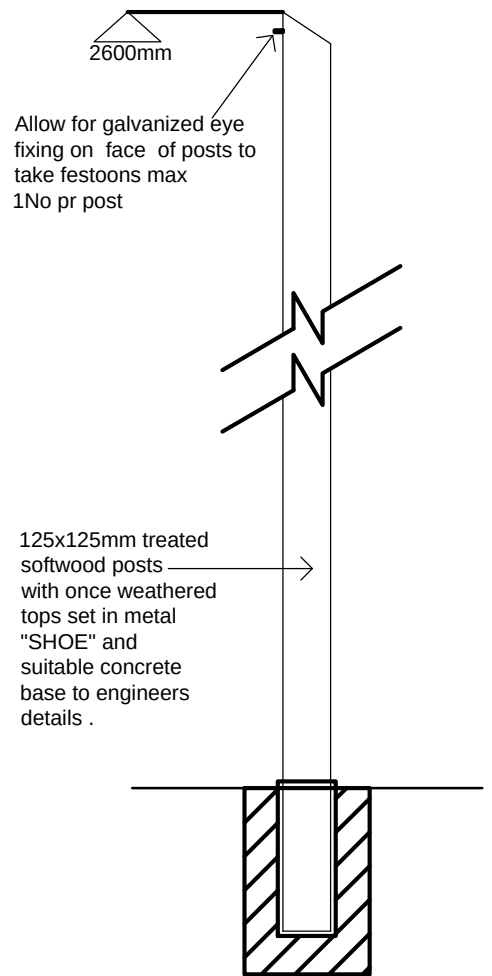

FESTOON POST - SECTION
SCALE 1:20@A1





New festoon lights IP65
rated LED warm white
with max 210 lumen



PROPOSED ELEVATION C - (BENGAL ST) Scale 1:100 @ A1



NOTES	
The designs and details on this drawing are copyright and must not be reproduced without the written permission of the designer.	
Contractors are to check all sizes and dimensions before setting out any site or shop work. Any errors or discrepancy to be reported to the designer.	
REVISIONS	
REV-A	Updated site plan
REV-B	Updated yard gates now open into yard planter added cycle stand added
DATE	
07/02/25	JAA
07/04/25	JAA

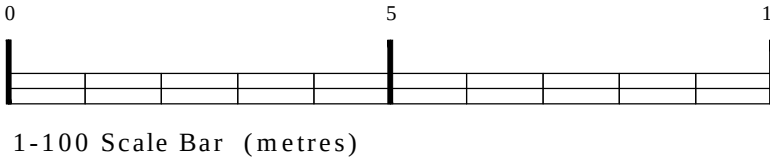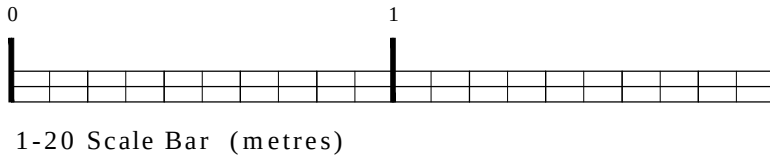

PLANNING

DRAWING DESCRIPTION
PROPOSED FESTONN LAYOUT PLAN
SITE PLAN

JOB TITLE
THE SHAMROCK,
17 BENGAL STREET,
MANCHESTER. M4 6AQ.
CLIENT
JOSEPH HOLT BREWERY

DRAWN BY	JAA	SCALE	1:20 and 1:100 @ A1
DATE	FEB 2025	DRAWING NO.	2021 - 228
CHECKED		REVISION	B

John Dixon & Associates Ltd,
Unit 211
Chambers Business Centre,
Chapel Road,
Oldham,
OL8 4QQ.
TEL : 0161 682 0964
FAX : 0161 683 4106
E-MAIL : info@johndixon.co.uk
WEB : www.johndixon.co.uk

jda
architecture
interior design
project management