


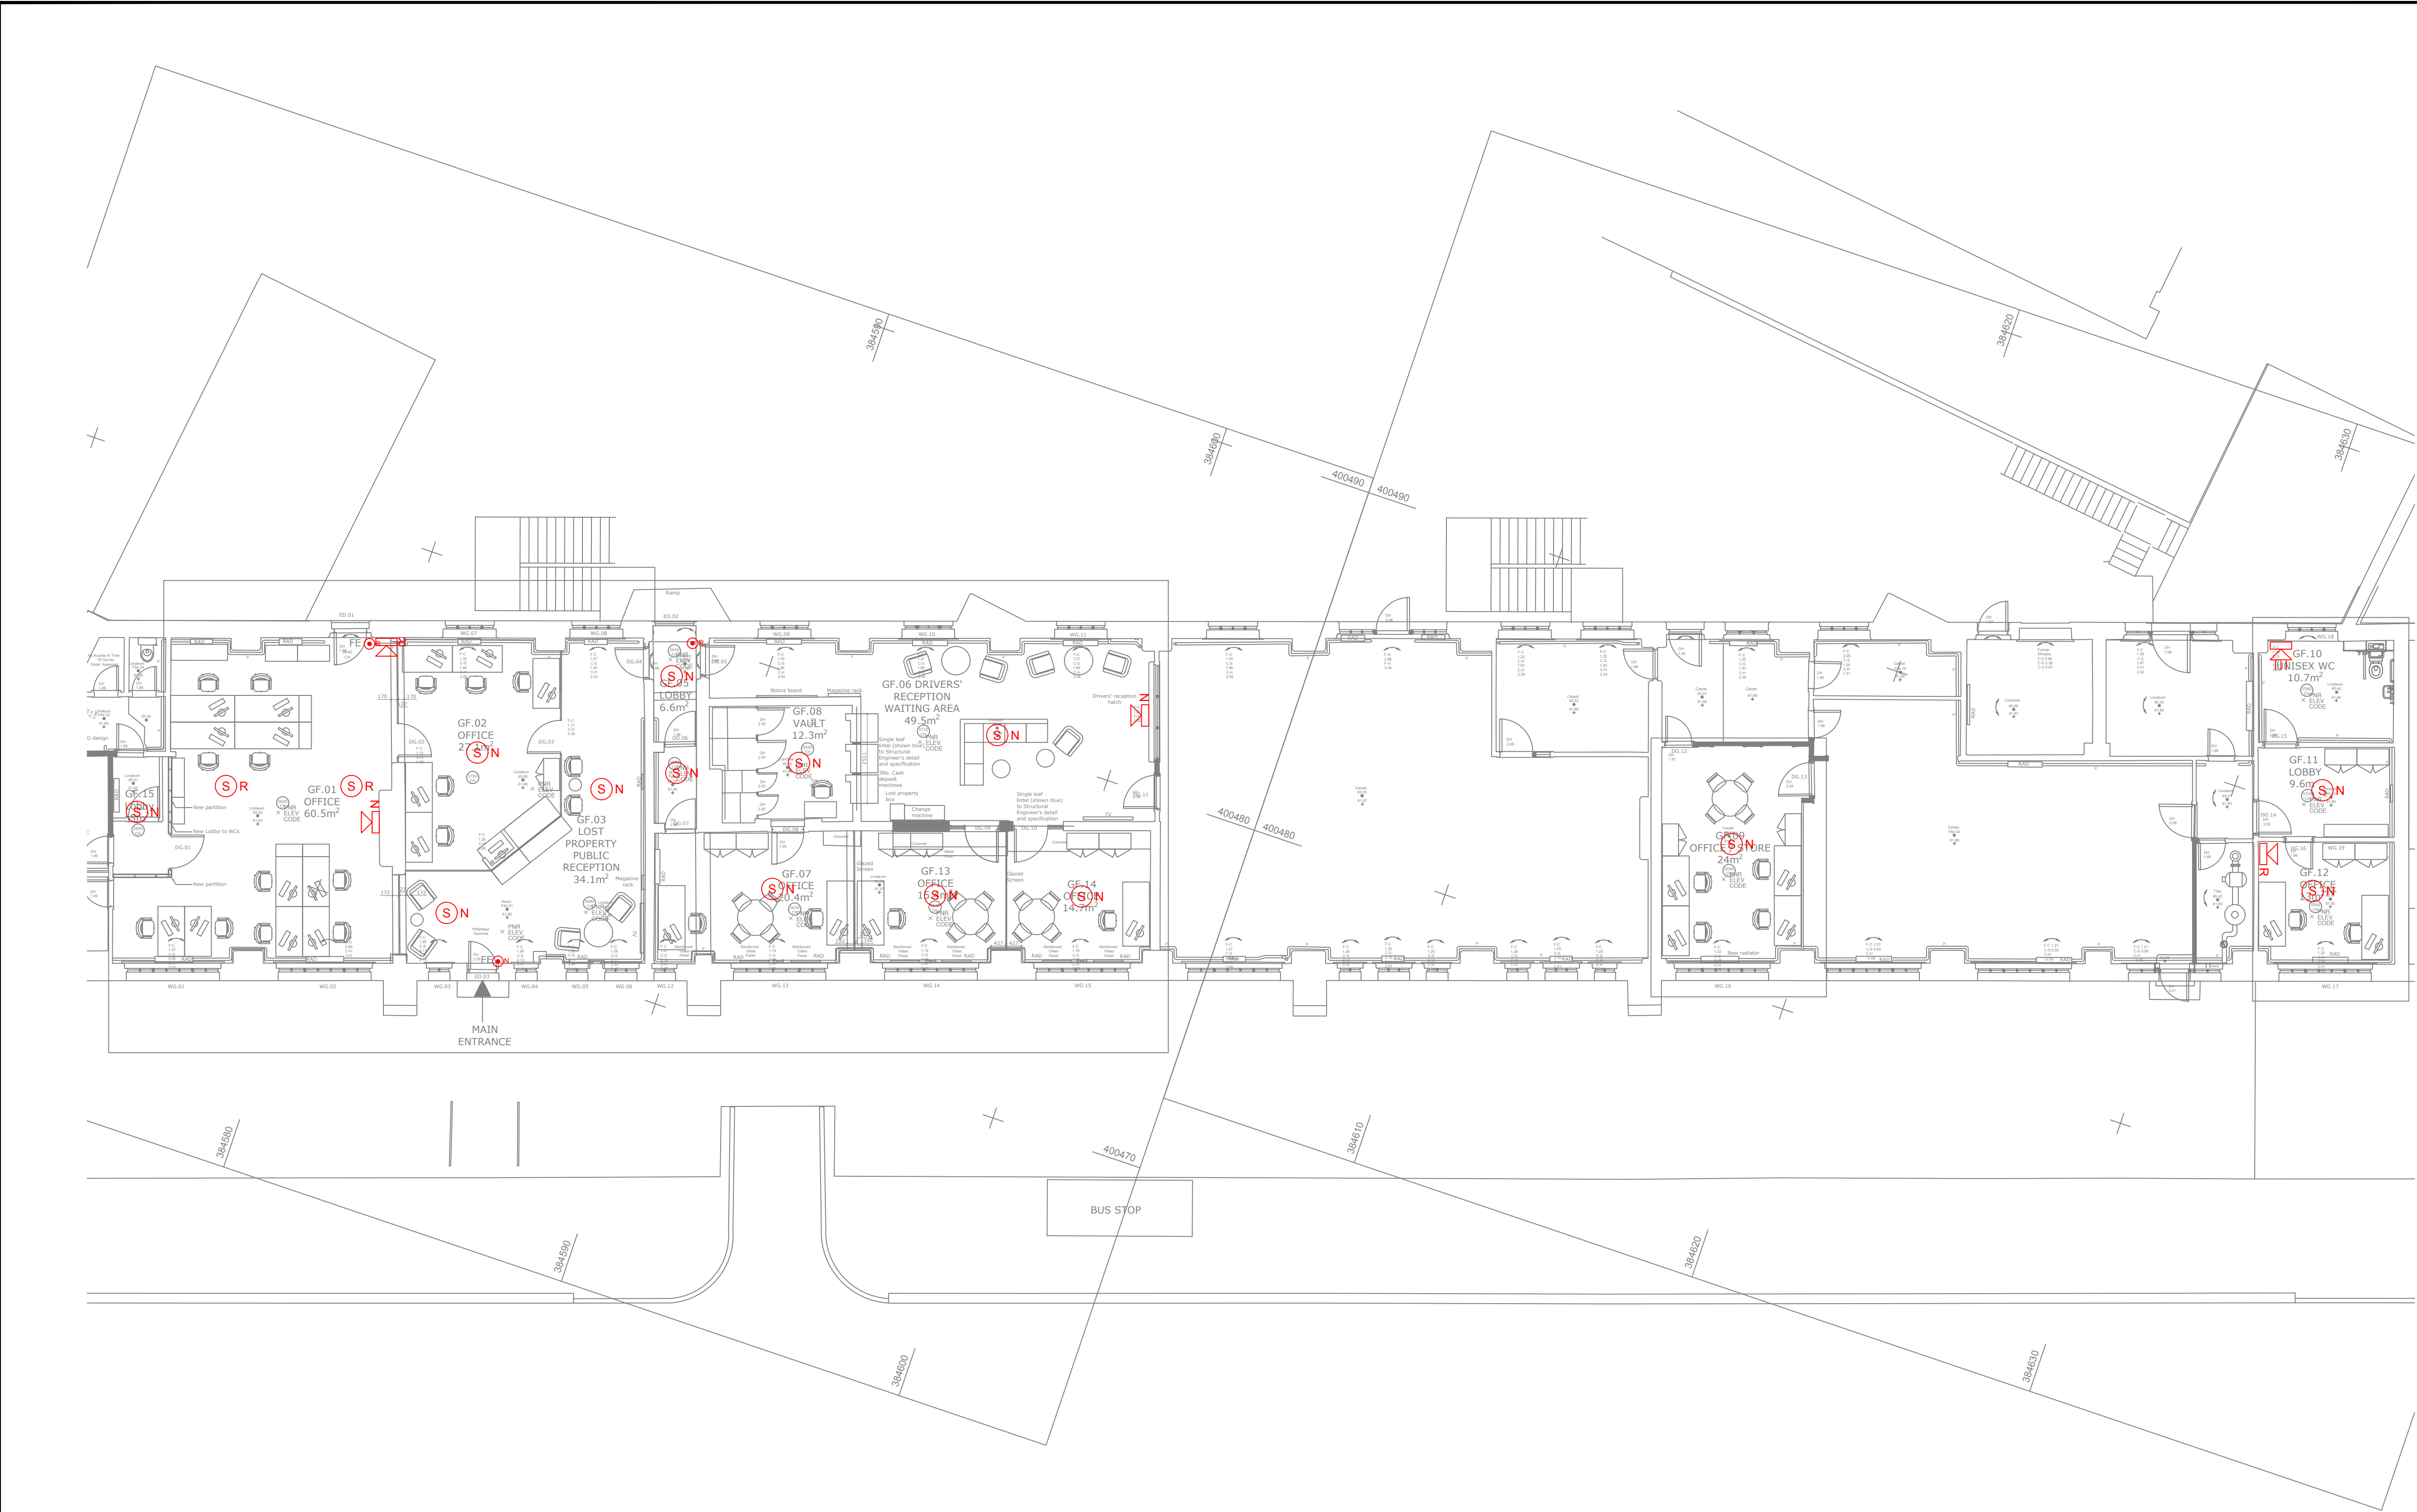

LEGEND	
	SMOKE DETECTOR - NEW
	SMOKE DETECTOR - REPLACEMENT
	MANUAL CALL POINT - NEW
	MANUAL CALL POINT - REPLACEMENT
	SOUNDER - REPLACEMENT
	SOUNDER - NEW
	VISUAL ALARM DEVICE

P2 Alterations	01.07.25	APM	AF	AF
P1 Preliminary Issue	14.04.25	APM	AF	AF
Rev. Revision note	Date	Rev.	Sgn.	Chg.

TFGM - QUEENS ROAD BUS DEPOT -
CHEETHAM HILL

PROPOSED FIRE ALARM LAYOUT

SCALE 1:100 @ A1	DATE 14.04.25	DRAWING NUMBER TFGM 03	REV. P2
DRW. APM	DESIGN AF		