


This document and its contents are the property of the Purchaser/Employee and Crookes Walker Consulting. They may not be copied or reproduced in any way, in part or whole, without prior written approval of both parties. Violations will result in legal action. This drawing shall be used in conjunction with the CWC Mechanical and Electrical Specifications. DO NOT SCALE FROM THIS DRAWING


DESIGNERS RISK ASSESSMENT
REFER TO APPENDIX 1 OF M&E SPECIFICATION FOR DESIGNERS RISK ASSESSMENT SCHEDULE

DRAWING BACKGROUNDS:
ARCHITECTS: CWB-JR-003-P

- NOTES:**
1. FINAL FIX AND CONNECTION OF KITCHEN EQUIPMENT BY KITCHEN SPECIALIST
 2. THIS DRAWING SHALL BE READ IN CONJUNCTION WITH THE PROJECT SPECIFICATION AND EQUIPMENT SCHEDULES.
 3. FINAL POSITIONING OF ALL EQUIPMENT SHALL BE PROVIDED BY THE CONTRACTOR AS PART OF THE INSTALLATION DRAWINGS SUBMISSION.

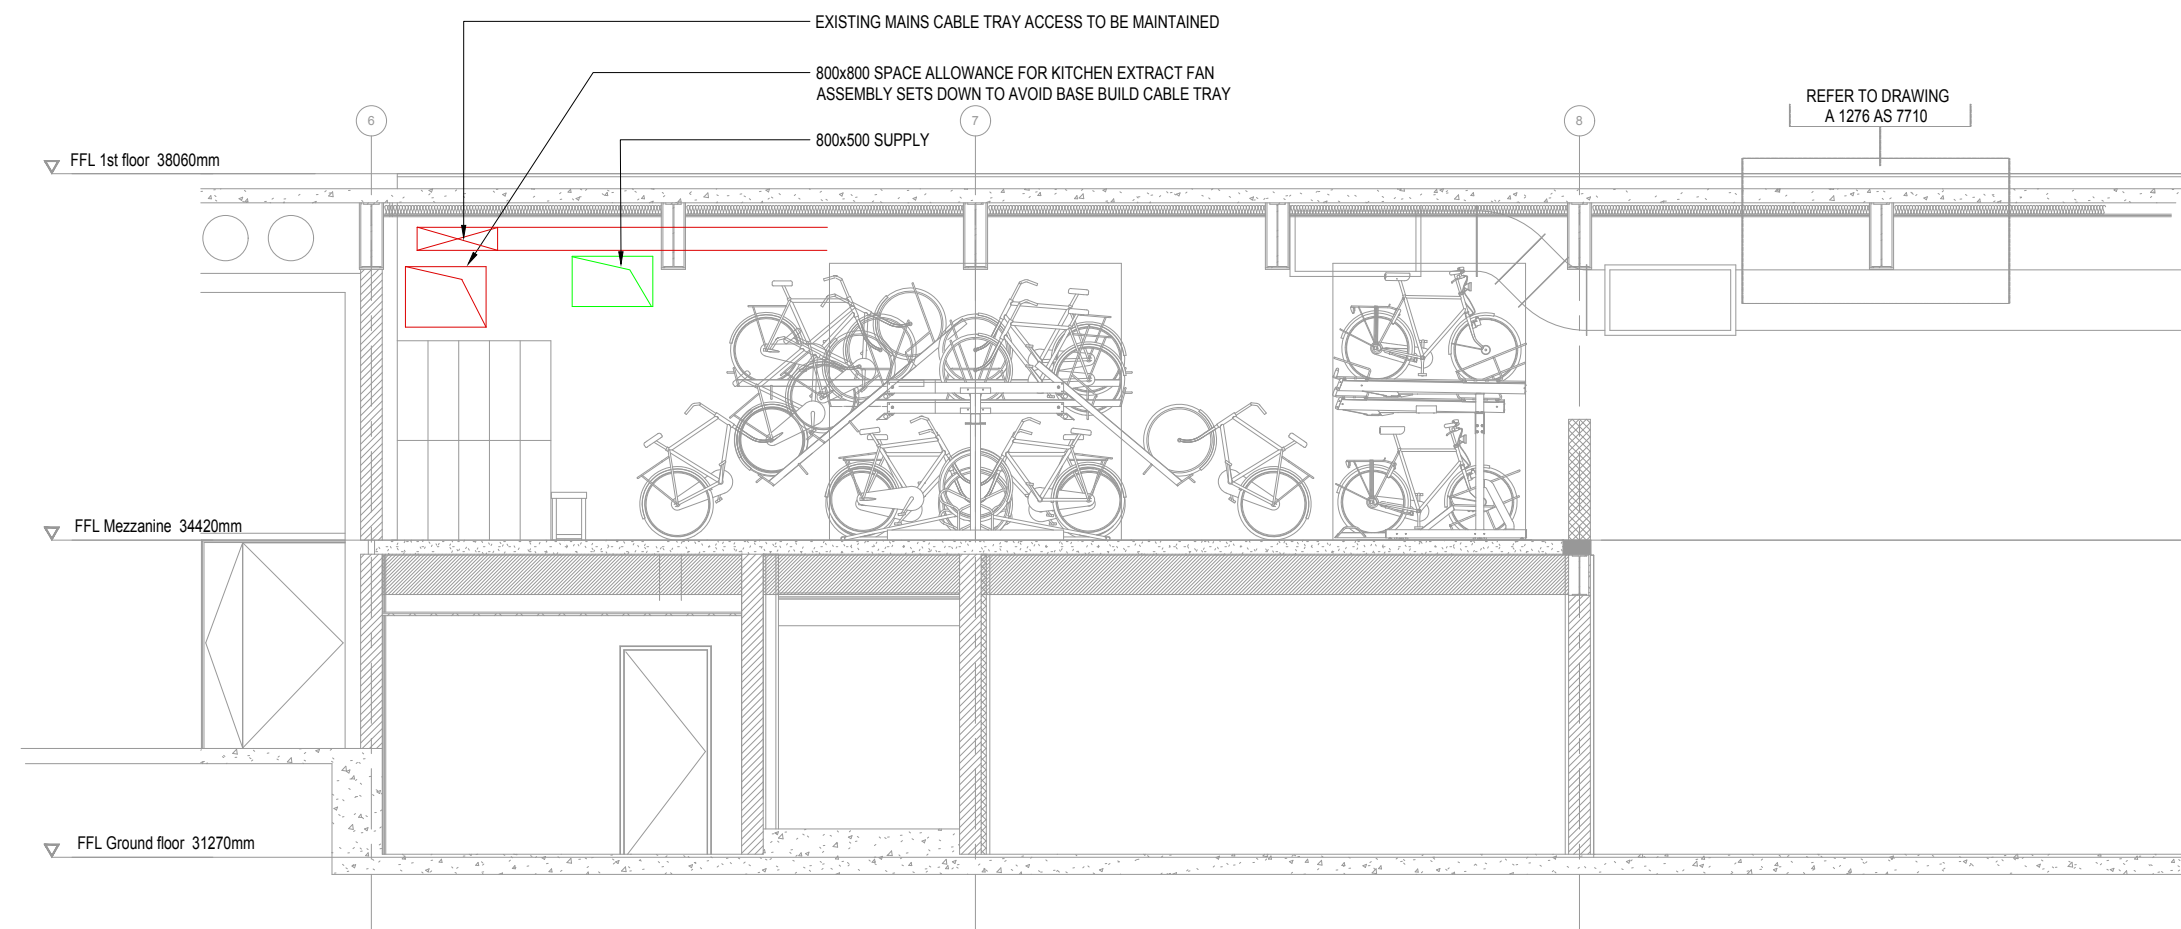

SECTION A-A

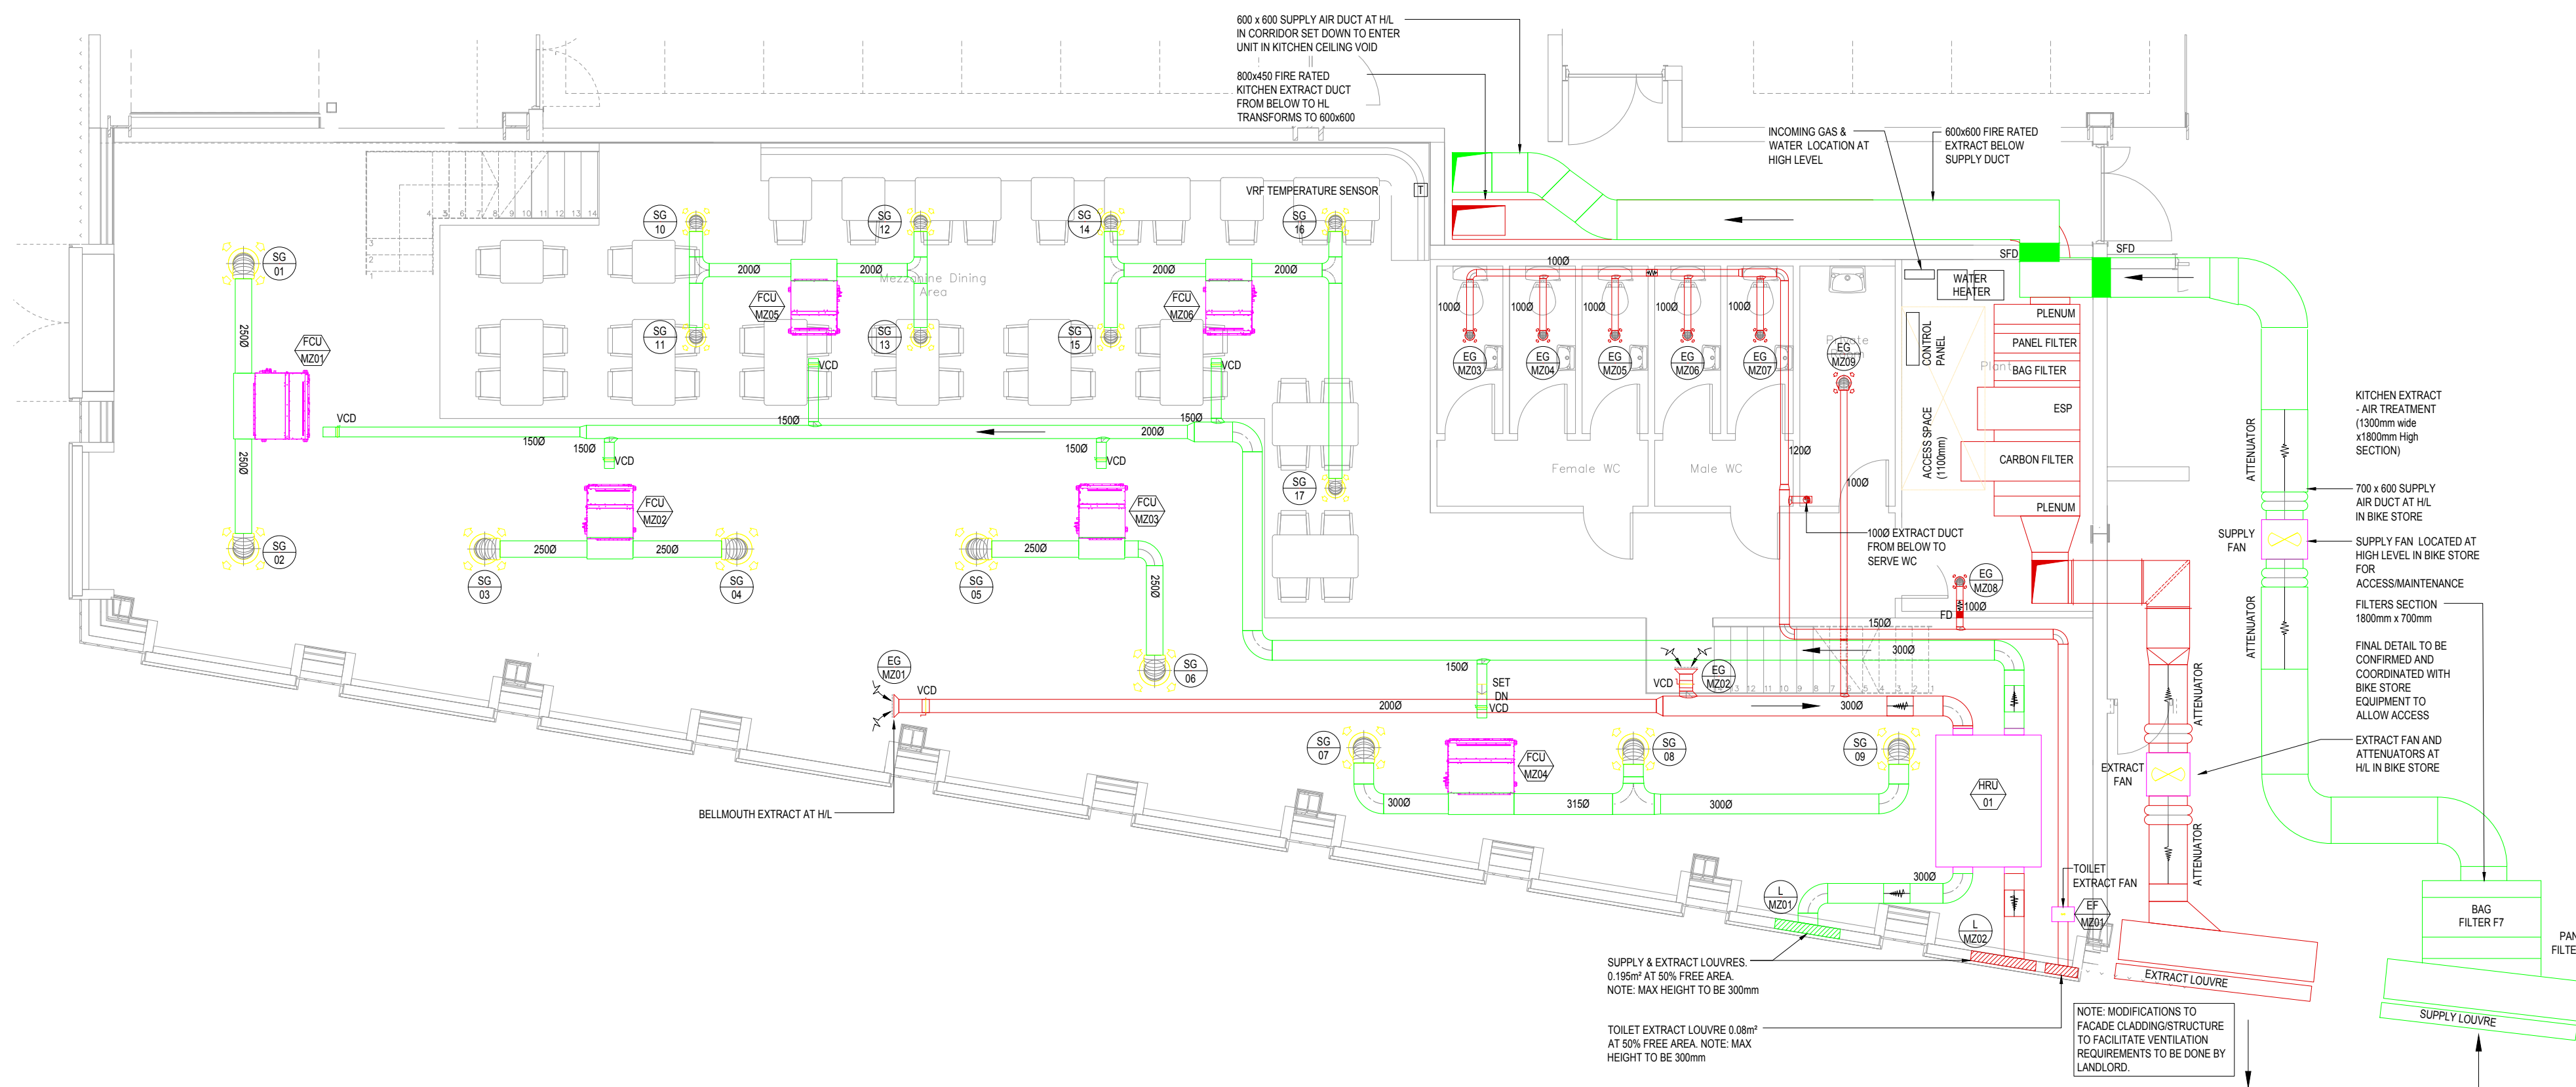

T4	08.10.18	UPDATED TO REFLECT NEW LAYOUT & KITCHEN VENT. REQUIREMENTS	SM	SW
T3	06.08.18	ALTERNATIVE DUCT ROUTE SHOWN	SM	SW
T2	06.08.18	DUCTWORK LAYOUT UPDATED. MEZZ PLANT SECTION ADDED	SM	SW
T1	24.04.18	TENDER ISSUE	SM	SW
P1	12.04.18	PRELIMINARY ISSUE	TH	SW
Rev	Date	Description	Eng	CW

CWC
crookes walker consulting
Albion House, 30 St Mary's Parsonage
Manchester M3 2WJ
Tel: 0161 854 9999
The Plaza, Old Hall Street,
Liverpool L3 9QJ
Tel: 0151 600 9449
E-mail: sales@cwcon.co.uk
Website: www.cwcon.co.uk

Client
RIBEYE STEAKHOUSE

Project
FIRST STREET BUILDING 8 UNIT 1A

Drawing Title
MEZZANINE VENTILATION & AC

Status	TENDER
Project No.	1663
Drawing	TH
Scale / Paper Size	1:50 @ A0
Drawing No.	1663-MX-5701
Rev	T4