



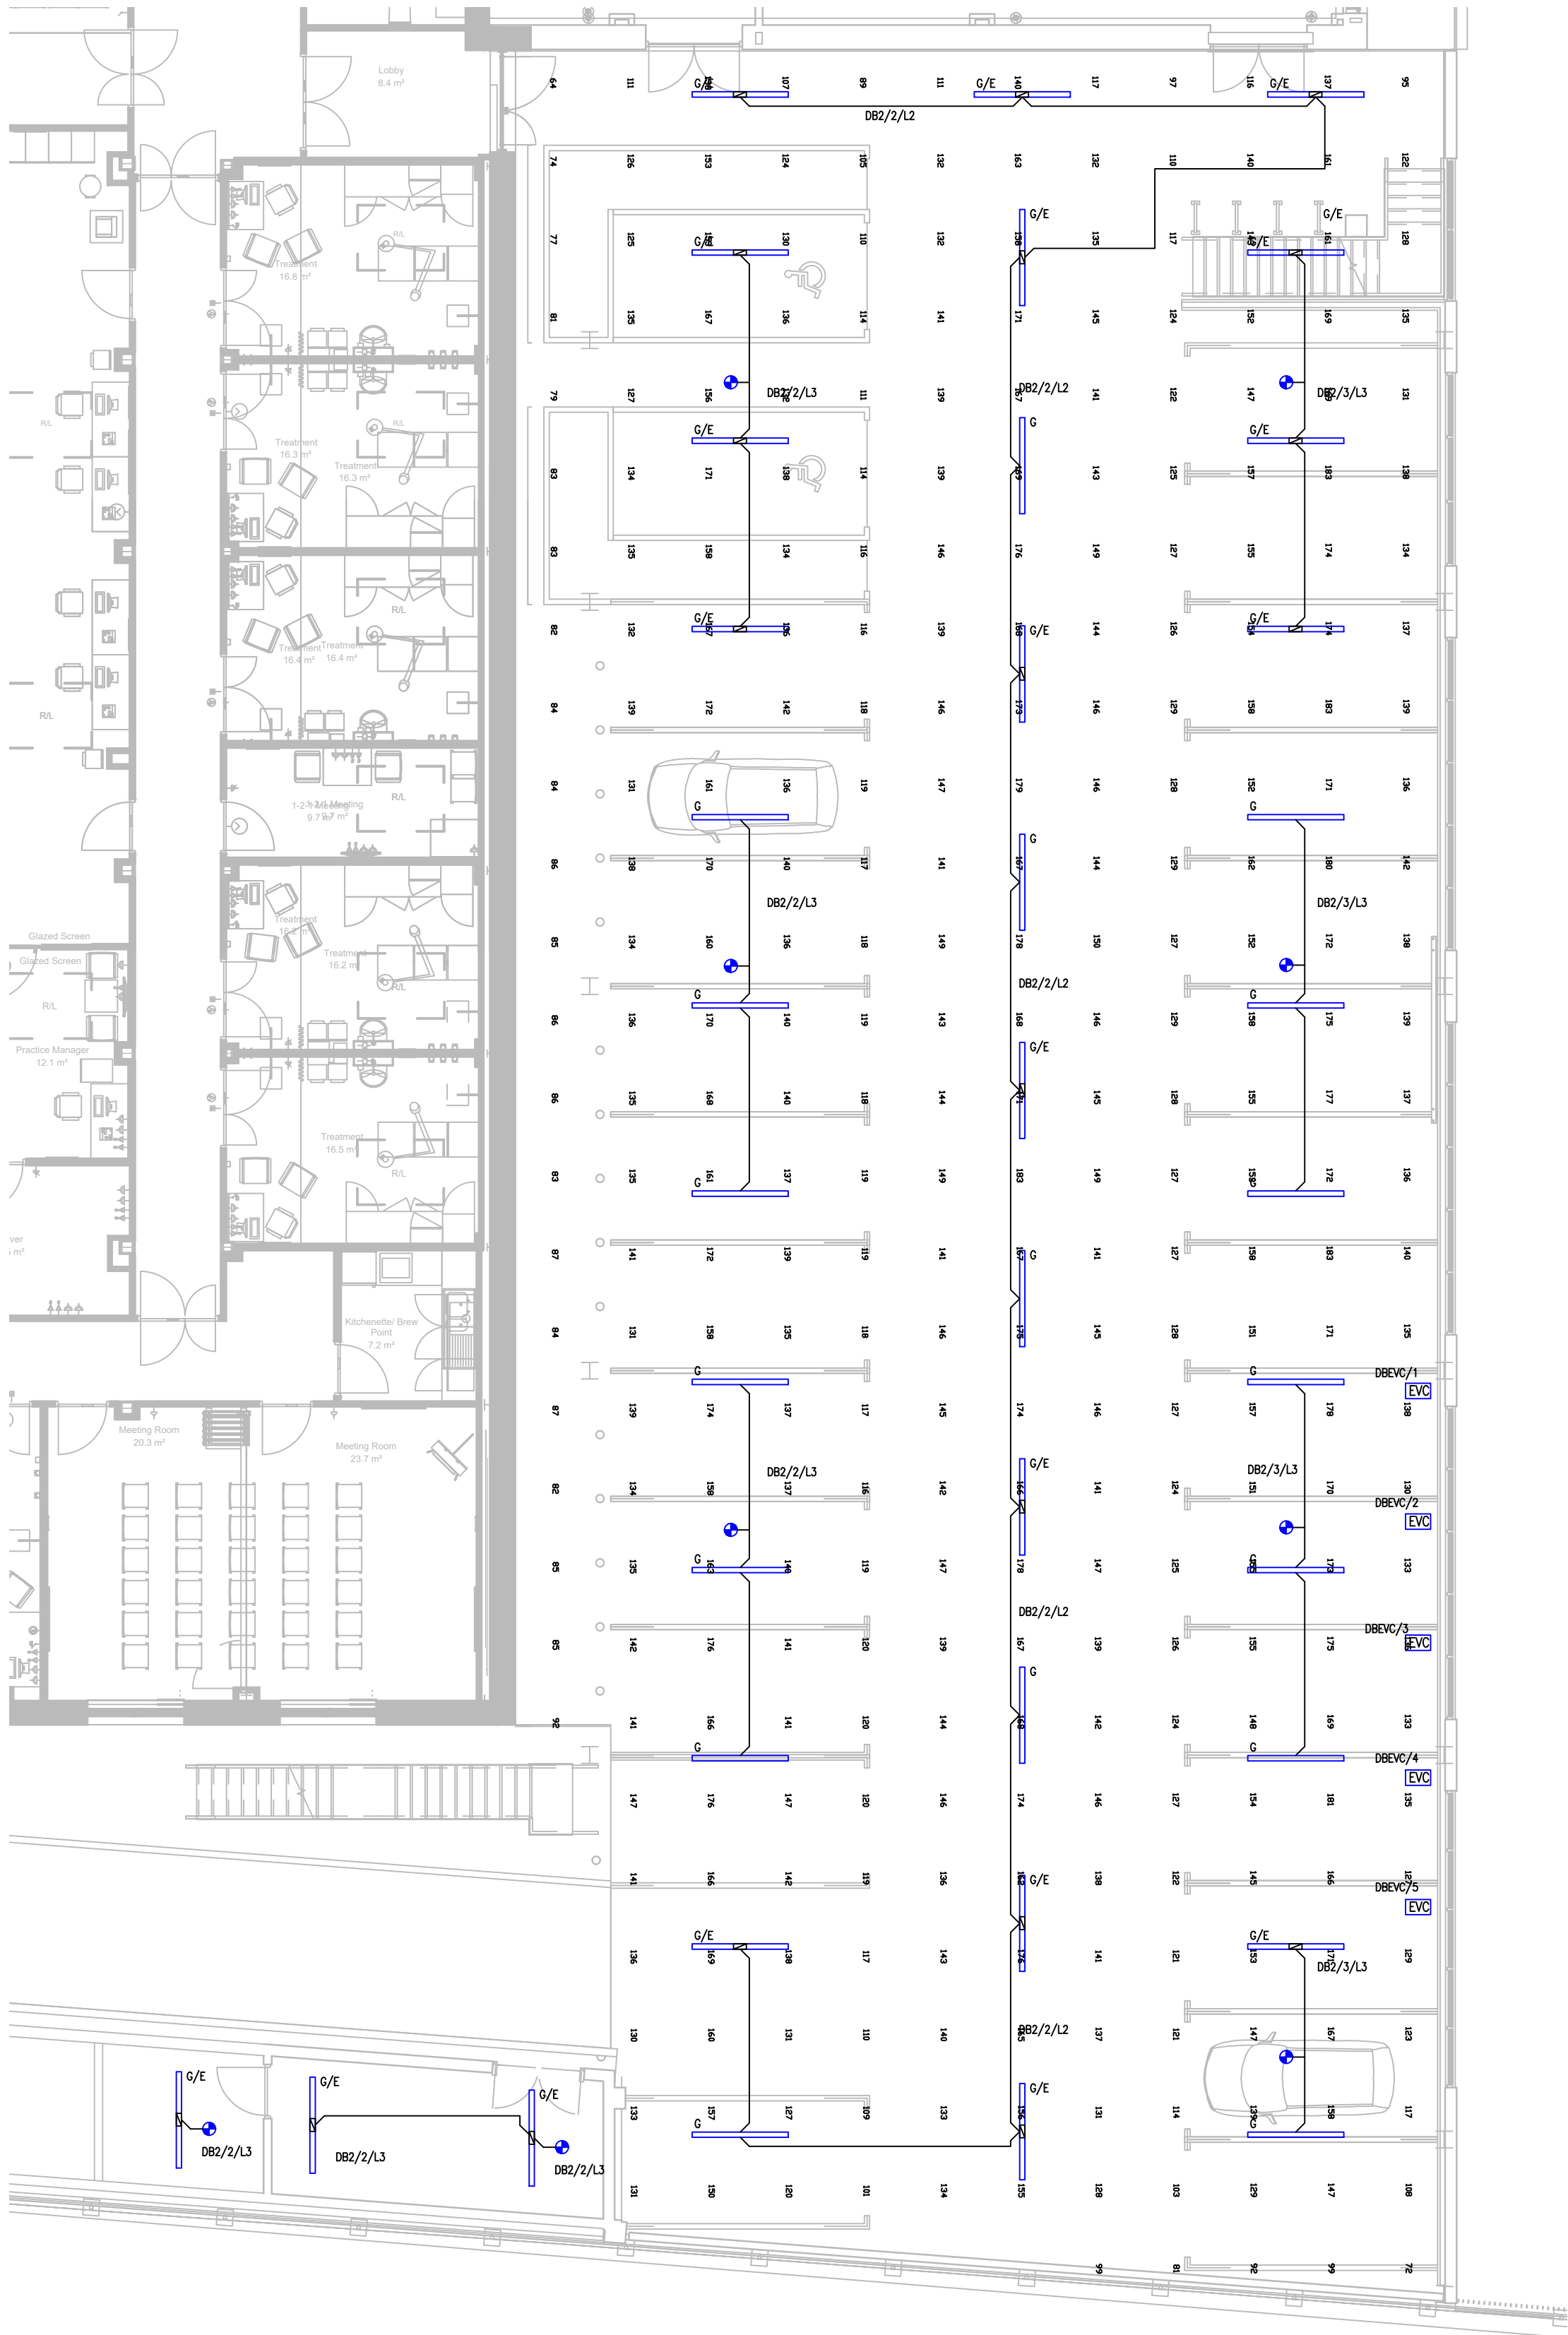

GROUND FLOOR CARPARK LIGHTING & EVC LAYOUT

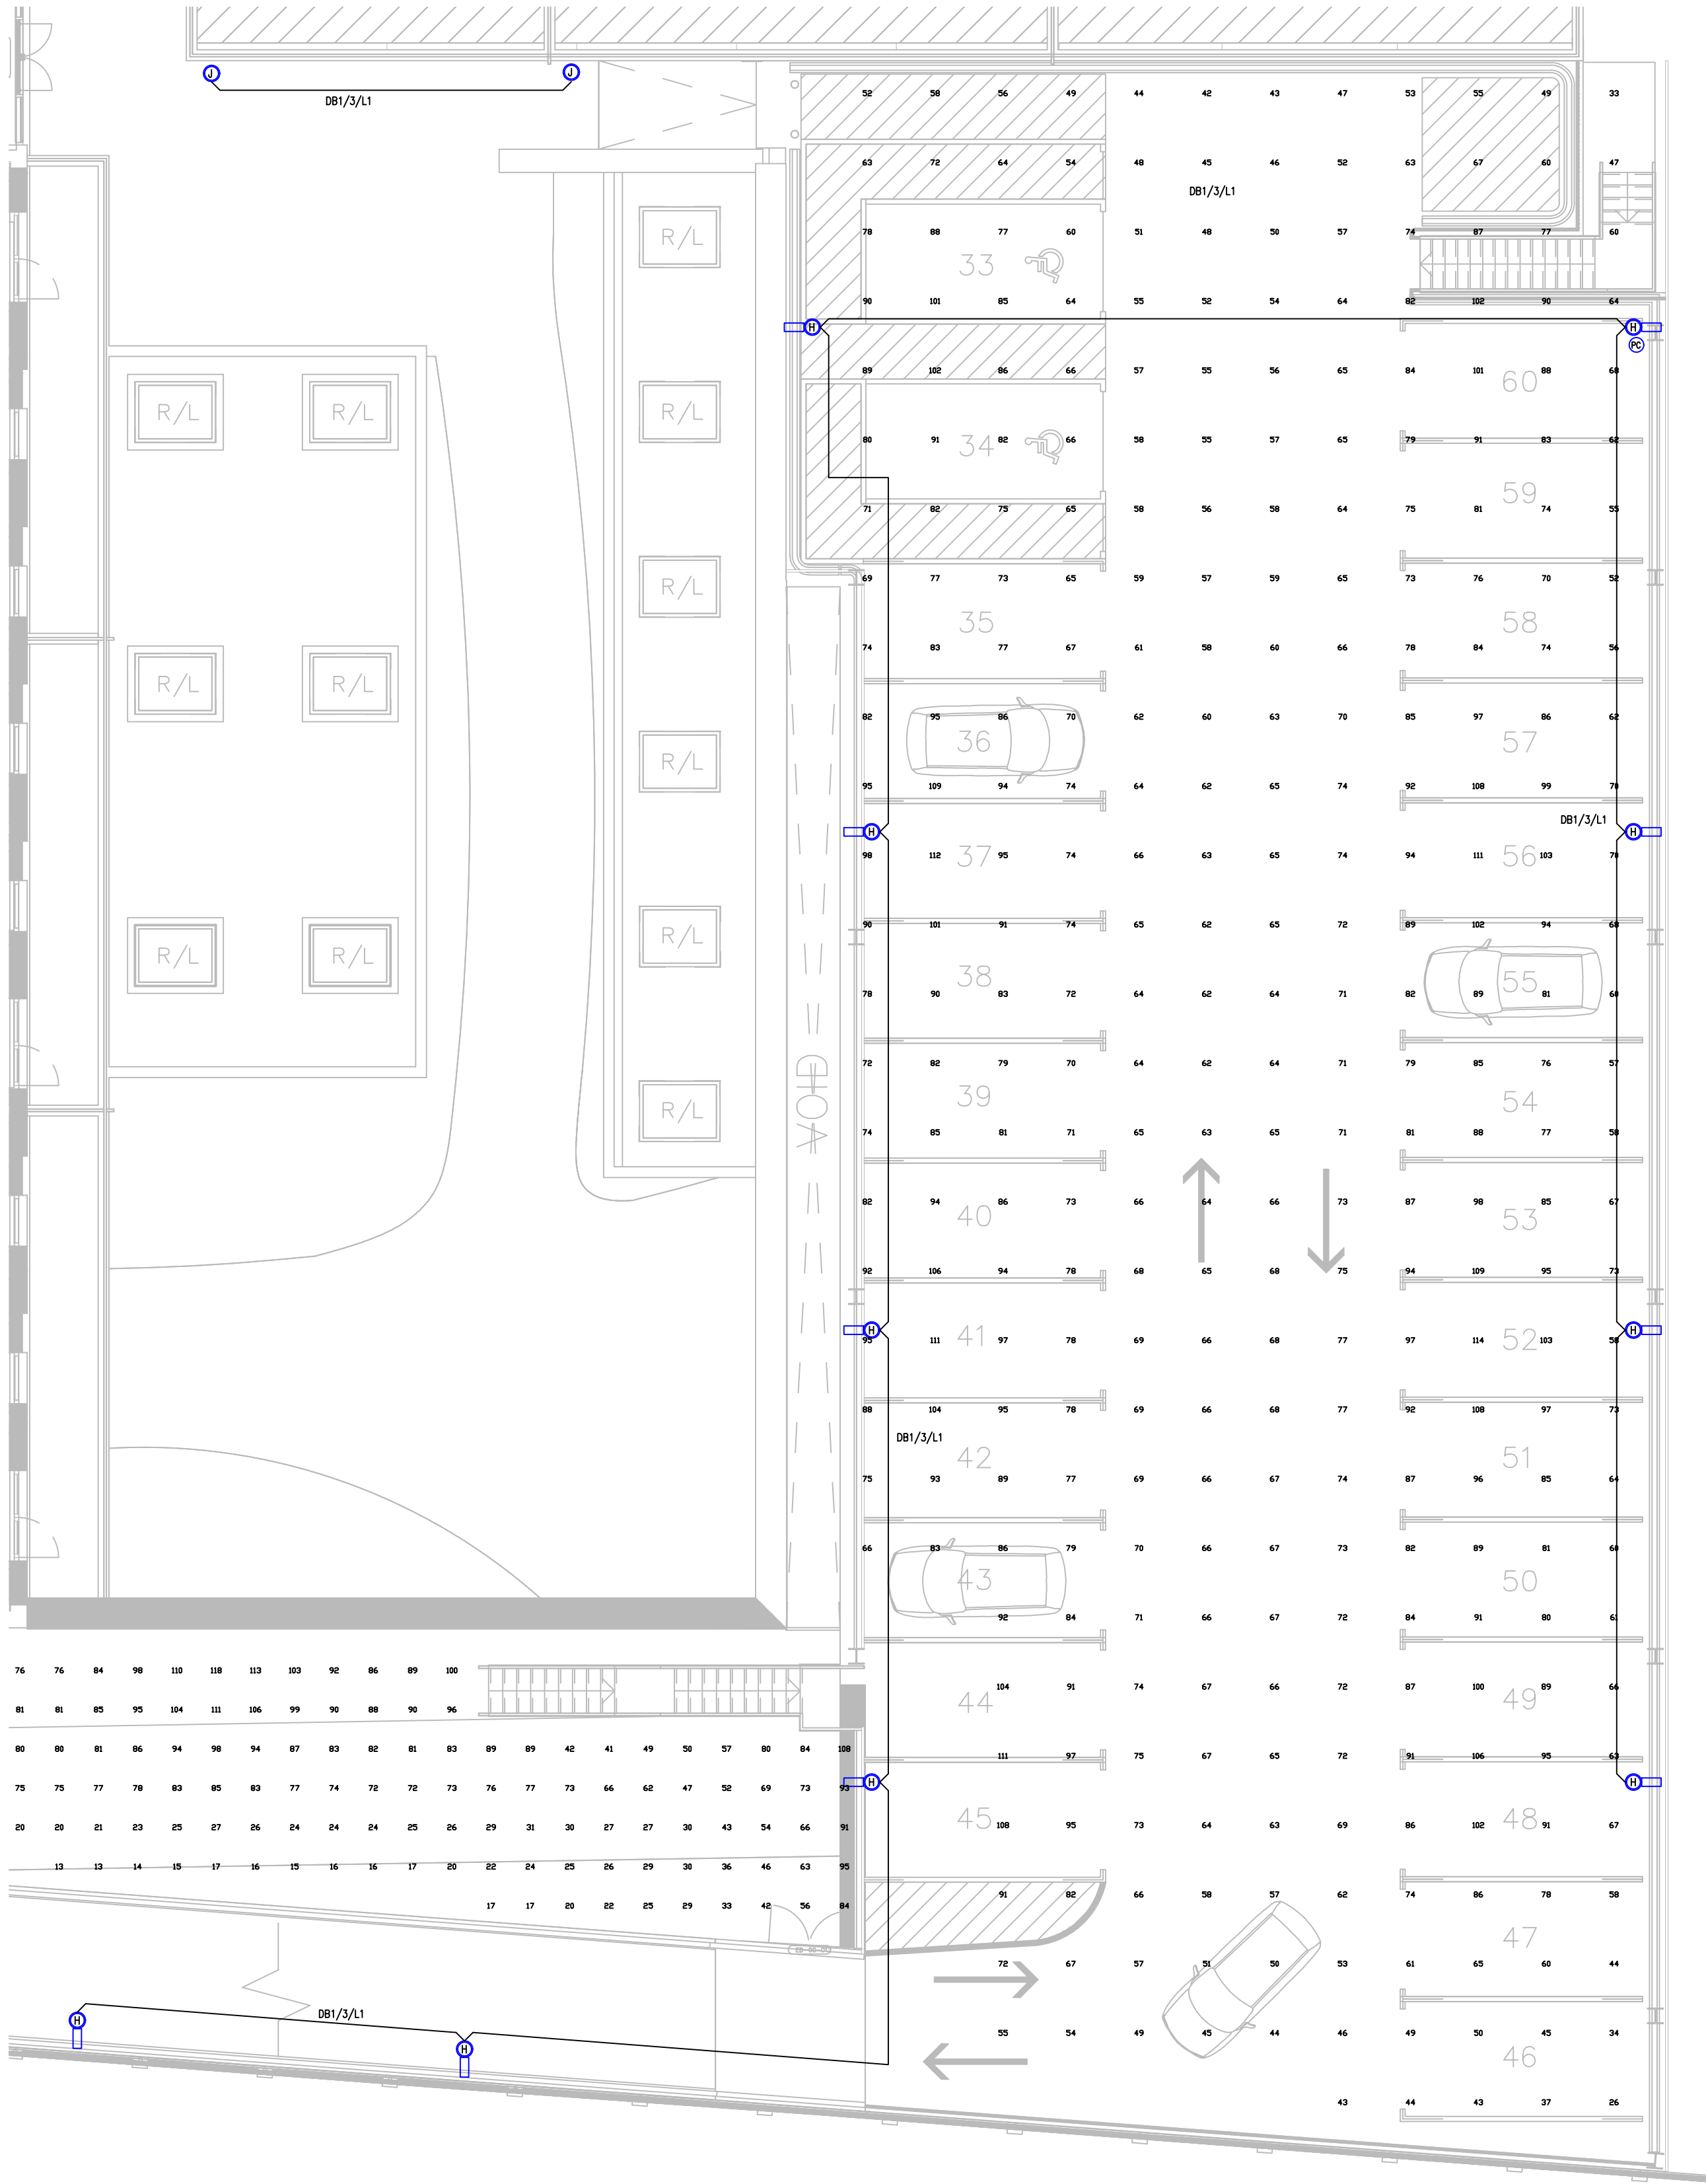

FIRST FLOOR CARPARK LIGHTING & EVC LAYOUT

© Copyright in the drawing is the property of Prana Engineering Ltd.
It must not be reproduced, amended, used in any way without the express written consent of a Director of Prana Engineering Ltd.

This drawing is for information only and shall not be used for construction purposes.

Any drawing issued as "Construction Issue" is done so to confirm the basis on which the contractor shall provide their own working drawings.

All dimensions are in mm unless stated otherwise.

The information on this drawing shall be read in conjunction with any relevant associated specifications.

- NOTES:**
- LOWER LEVEL CARPARK THROUGH FARE LIGHTING TO BE 24 HOUR ILLUMINATED WITH TIMECLOCK OVERRIDE LOCATED ADJACENT TO SUPPLYING DISTRIBUTION BOARD.
 - CAR PARK BAY LIGHTING TO BE CONTROLLED VIA LOCAL PIR SENSORS.
 - UPPER CARPARK LIGHTING AND RAMP LIGHTING TO BE CONTROLLED VIA PHOTOCELL AND TIMECLOCK OVERRIDE LOCATED ADJACENT TO SUPPLYING DISTRIBUTION BOARD.

- LUMINAIRE SCHEDULE**
- 'A' ROBUS SPACE UGR-19 30W LED PANEL 600X600 4000K
 - 'B' ROBUS ATMOS 60W LED PANEL 1200X600 4000K
 - 'C' ROBUS VIRTUE 24W LED DOWNLIGHT 4000K
 - 'D' ROBUS ULTIMUM 6W LED SPOTLIGHT 4000K
 - 'F' ROBUS FALCON 30W WALL LIGHT IP65
 - 'G' ROBUS HARBOUR 40W LED CORROSION PROOF IP65 6FT BATTEN
 - 'H' ROBUS URB-XS75-T3N-365 COLUMN MOUNTED LED FLOODLIGHT
 - 'J' ROBUS WHITESTAR BULKHEAD FITTING IP65
- /E DENOTES C/W 3 HOUR EMERGENCY BATTERY BACK UP PACK & LED INDICATOR.

- LIGHTING LEGEND**
- SINGLE WAY LIGHT SWITCH.
*'g' - DENOTES NO. OF GANGS.
'N' DENOTES C/W NEON INDICATOR
 - TWO WAY LIGHT SWITCH.
*'g' - DENOTES NO. OF GANGS.
 - EMERGENCY LIGHTING KEY TEST SWITCH.
LABELLED FOR EACH SWITCH WITH DESCRIPTION OF CIRCUIT. LOCATED ADJACENT TO THE DISTRIBUTION BOARD.
 - PIR SENSOR
 - HIGH LEVEL MICROWAVE SENSOR
 - PHOTO ELECTRIC CELL WITH TIMECLOCK OVERRIDE

C3	UPDATED CONTRACT ISSUE	J.H.	M.R.	07.10.25
C2	UPDATED CONTRACT ISSUE	J.H.	M.R.	05.09.25
C1	UPDATED CONTRACT ISSUE	J.H.	M.R.	08.08.25
C	CONTRACT ISSUE	J.H.	M.R.	06.06.25
REV	DESCRIPTION	DESN	CHKD	DATE



PROJECT
DIDSBURY POINT CARPARK

TITLE
ELECTRICAL SERVICES
GROUND & FIRST FLOOR
LIGHTING & EMERGENCY LIGHTING & EVC LAYOUT

SCALE	1:100	ORIGINAL SIZE	A1	DATE	SEP 2024
DRAWN	J.H.	DESIGNED	J.H.	CHECKED	M.R.
DRAWING NUMBER				REVISION	
J23009-PRA-00-E-6302				C3	