



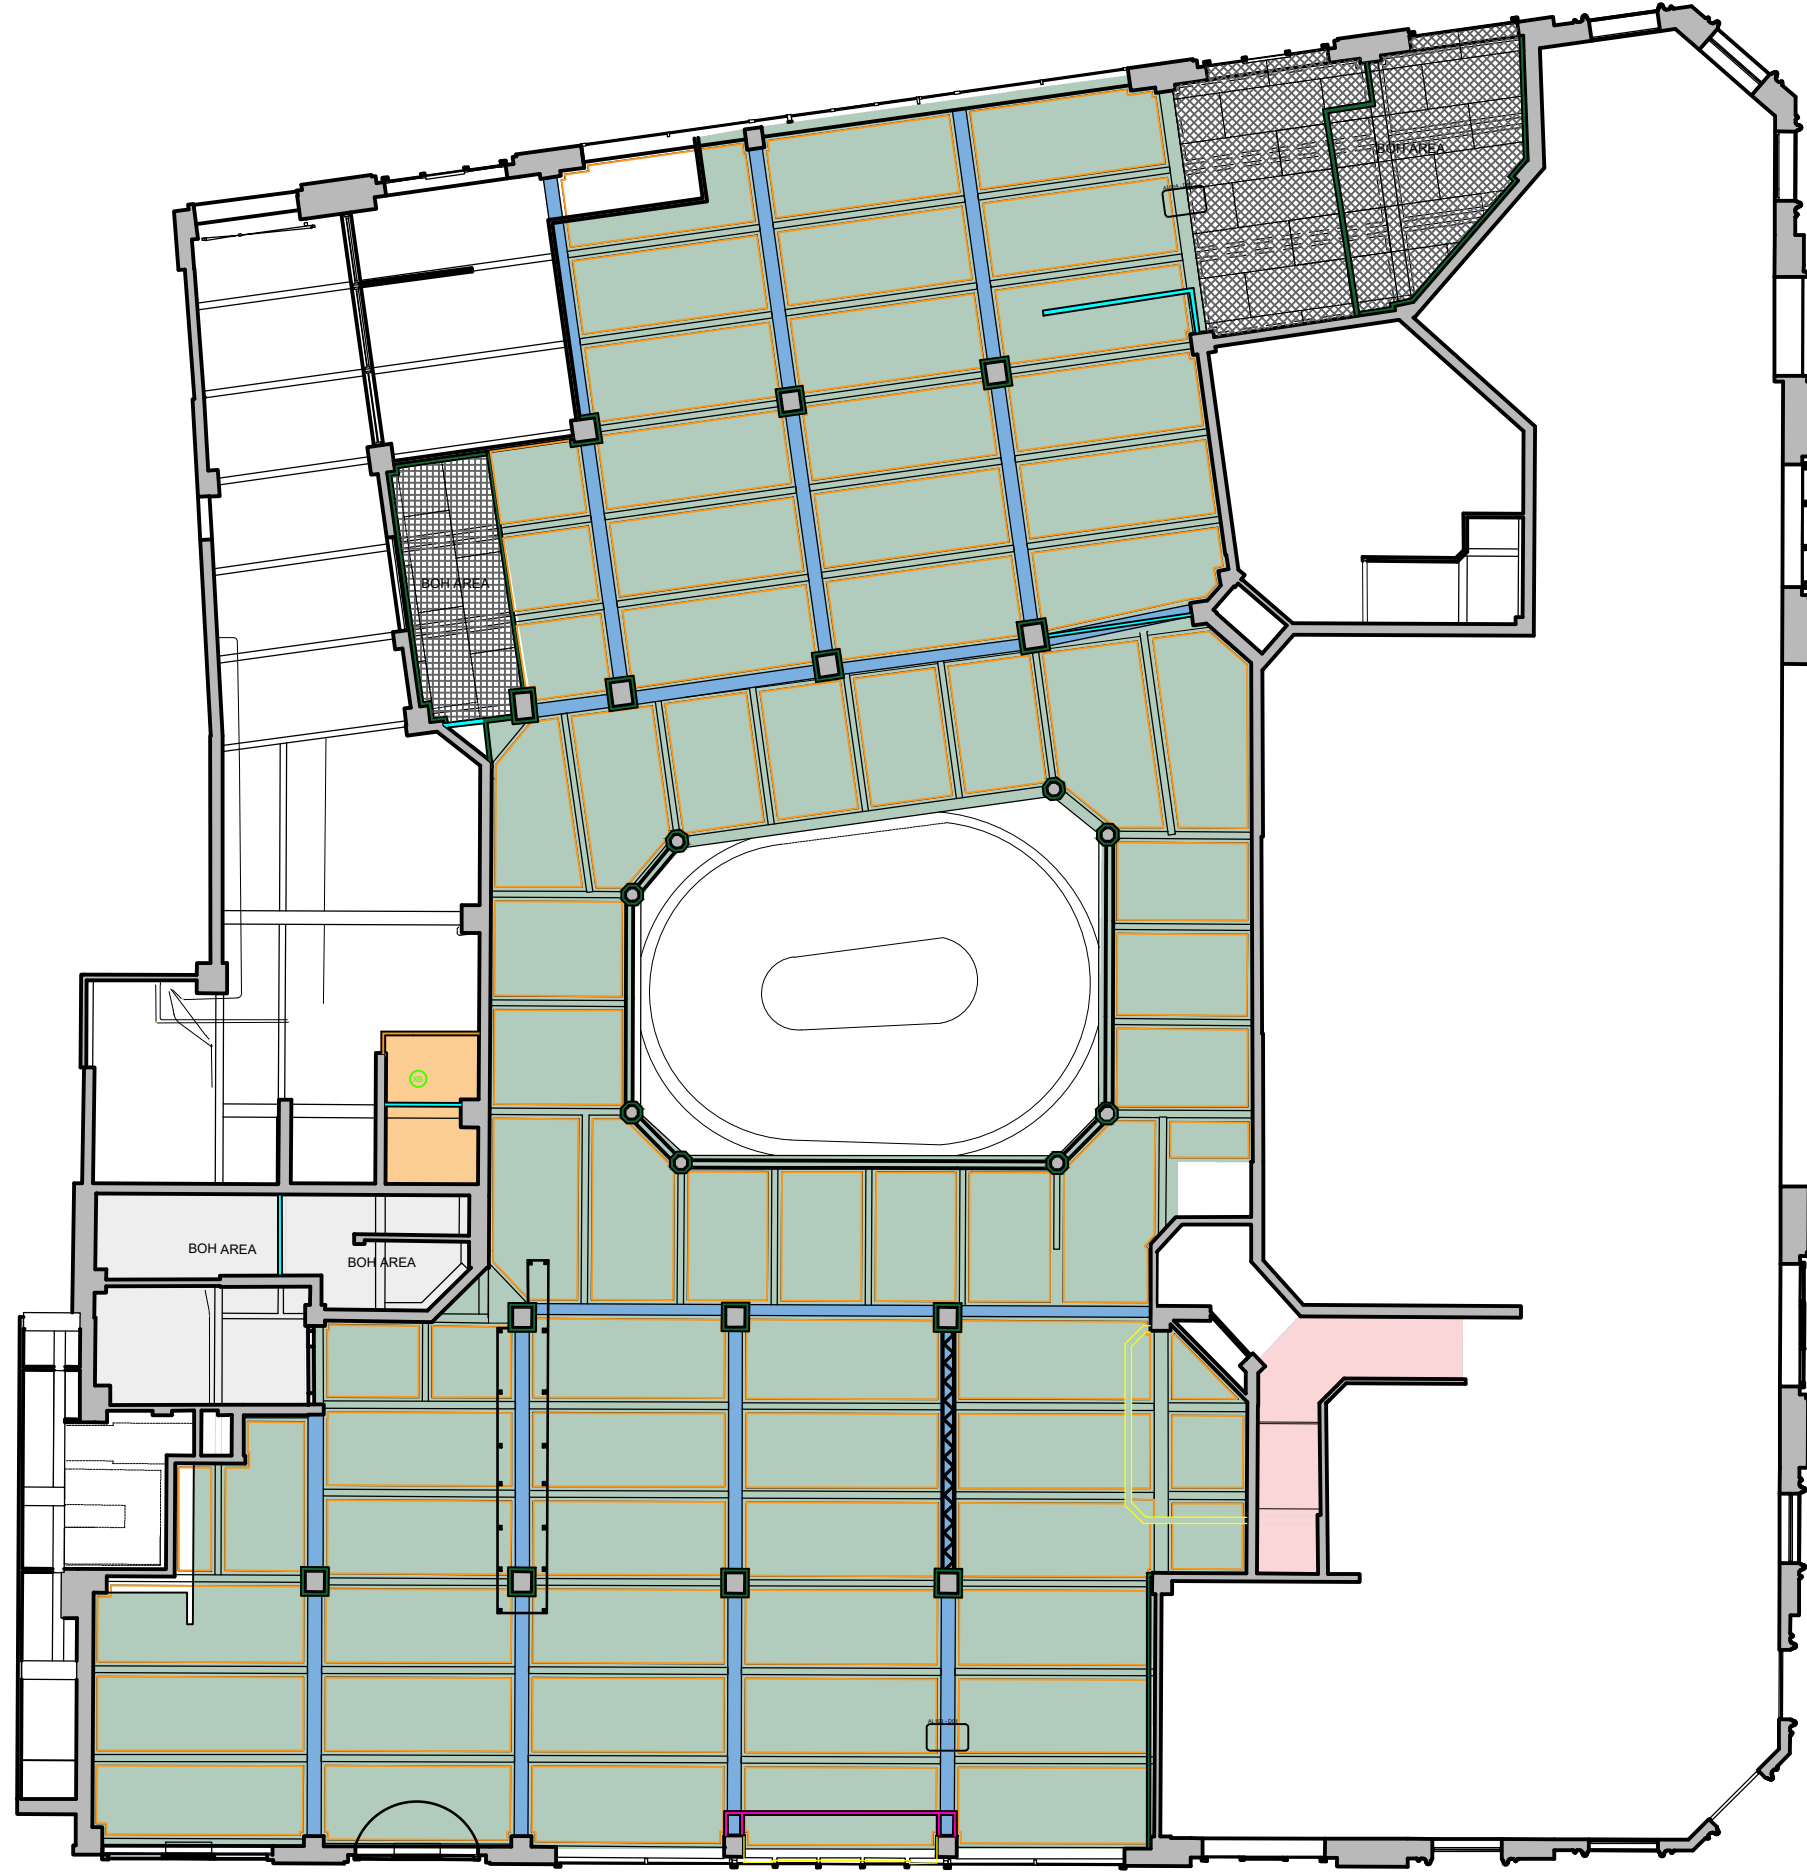


PROPOSED RCP GROUND

1:500

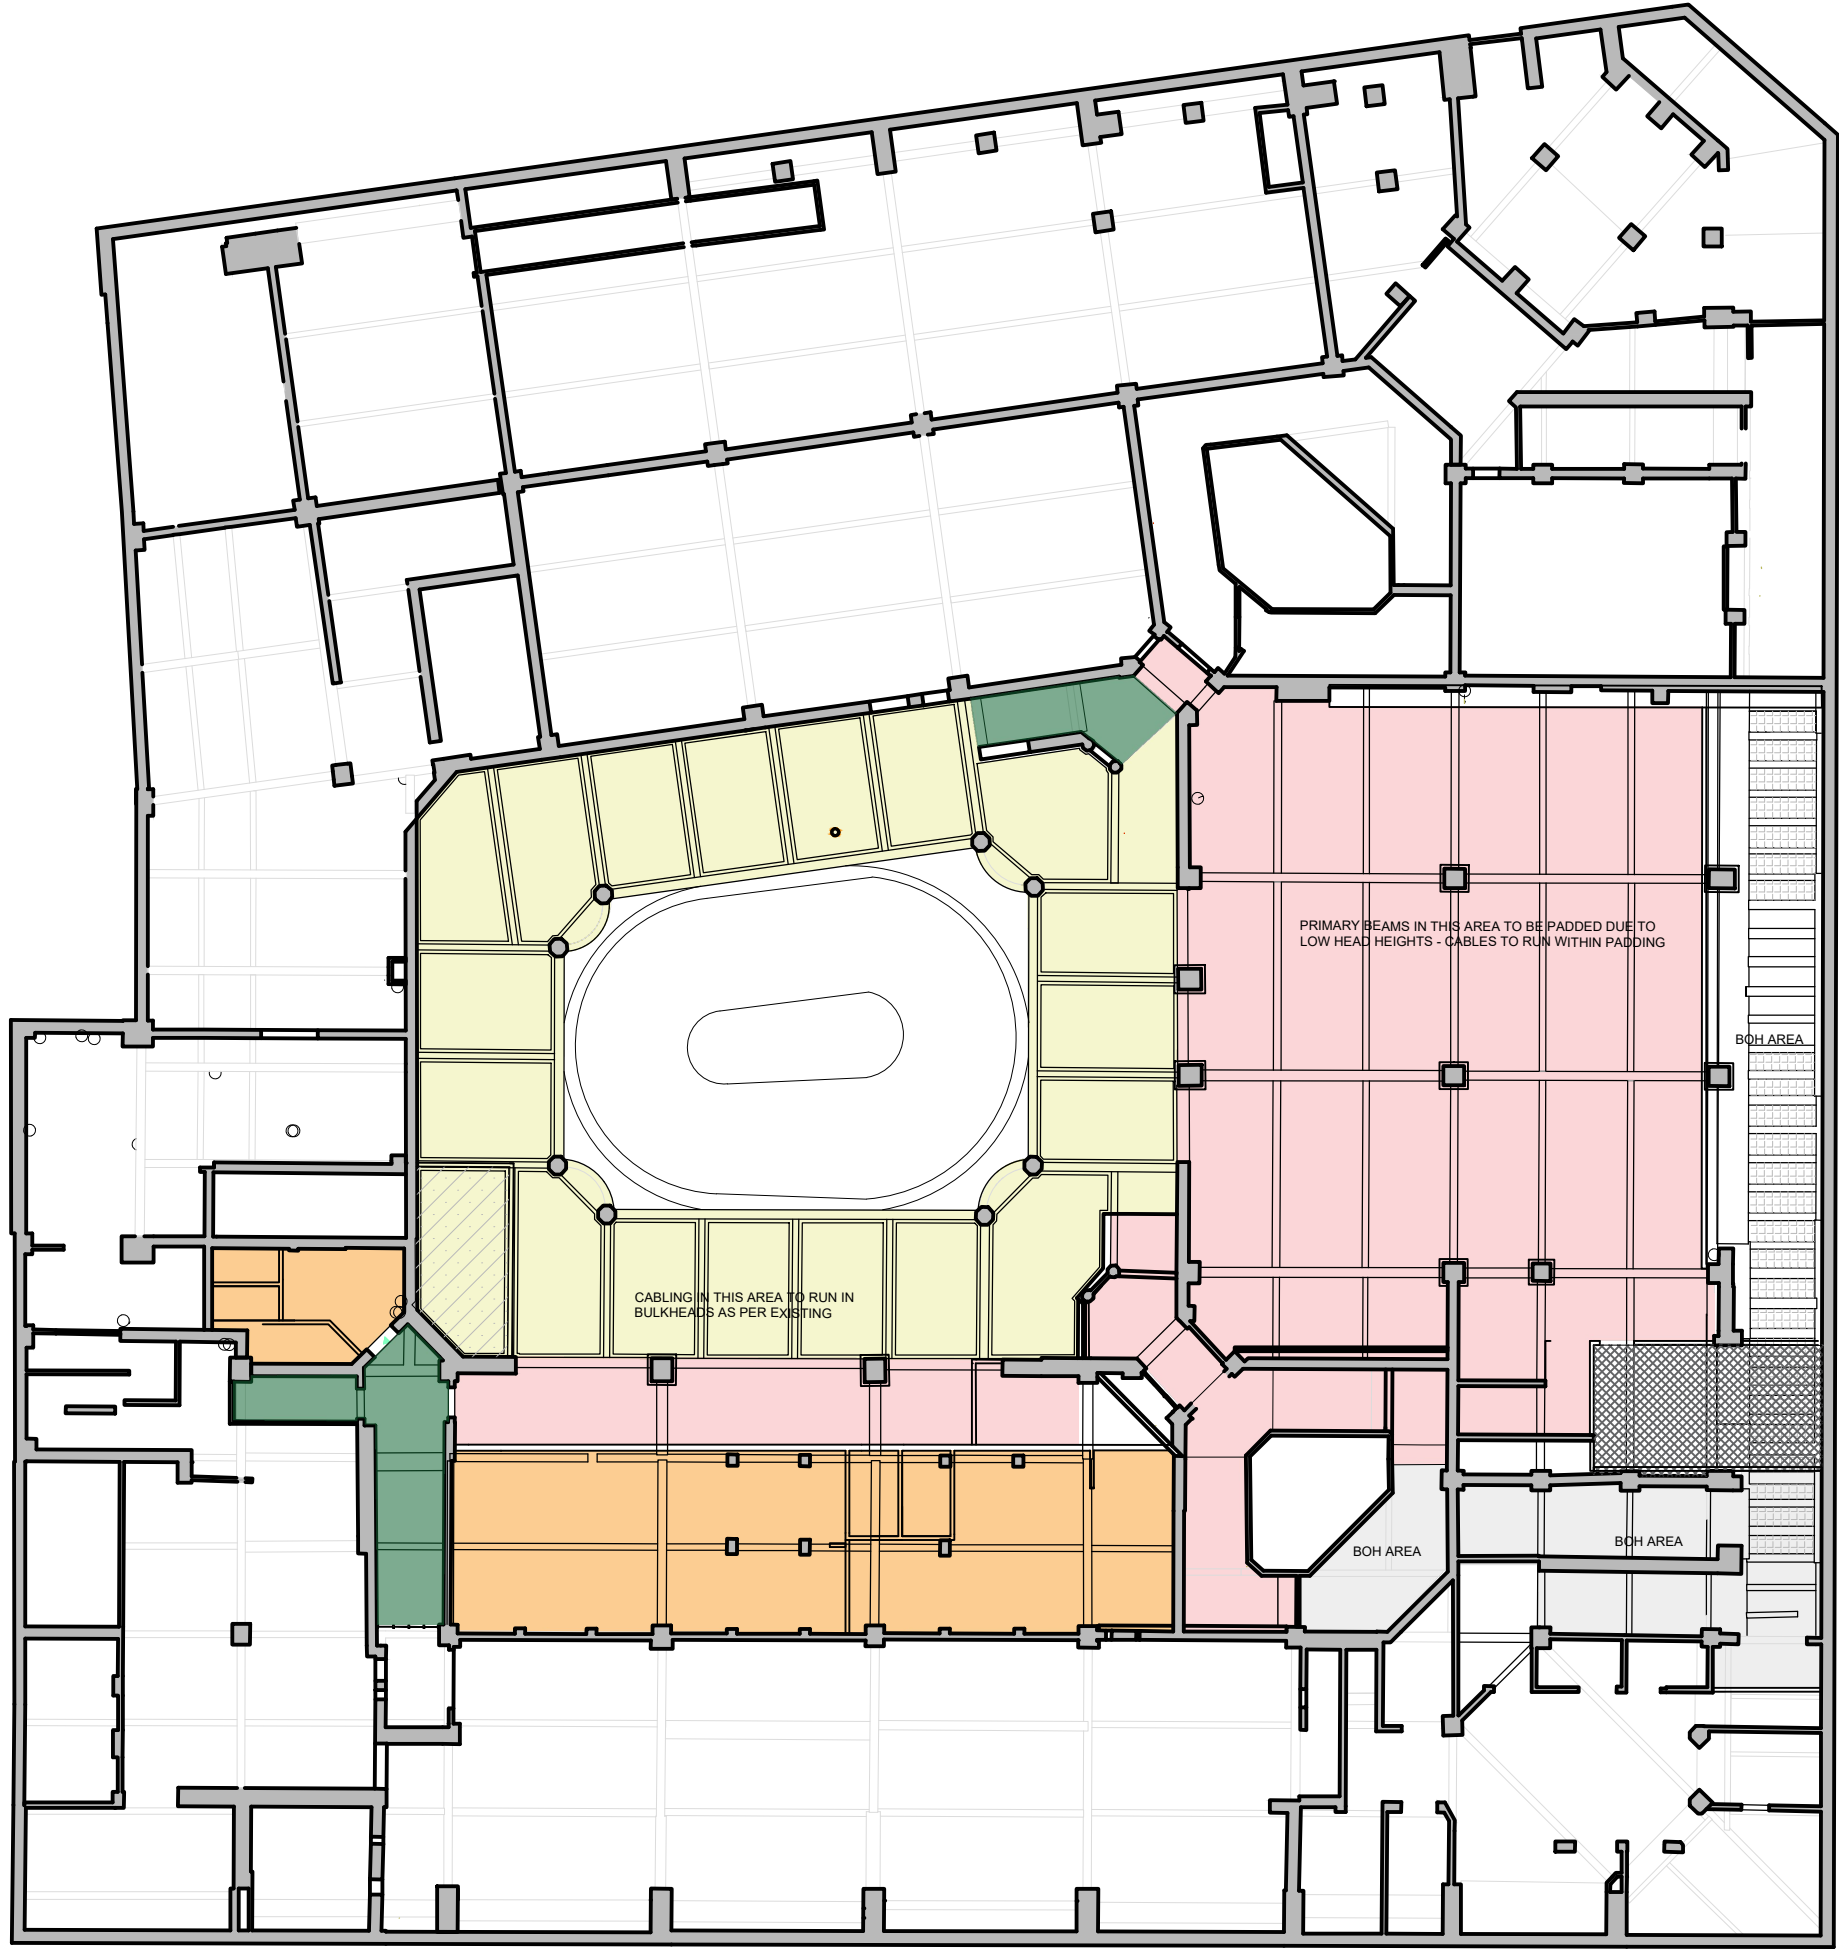


PROPOSED RCP MEZZANINE

1:500

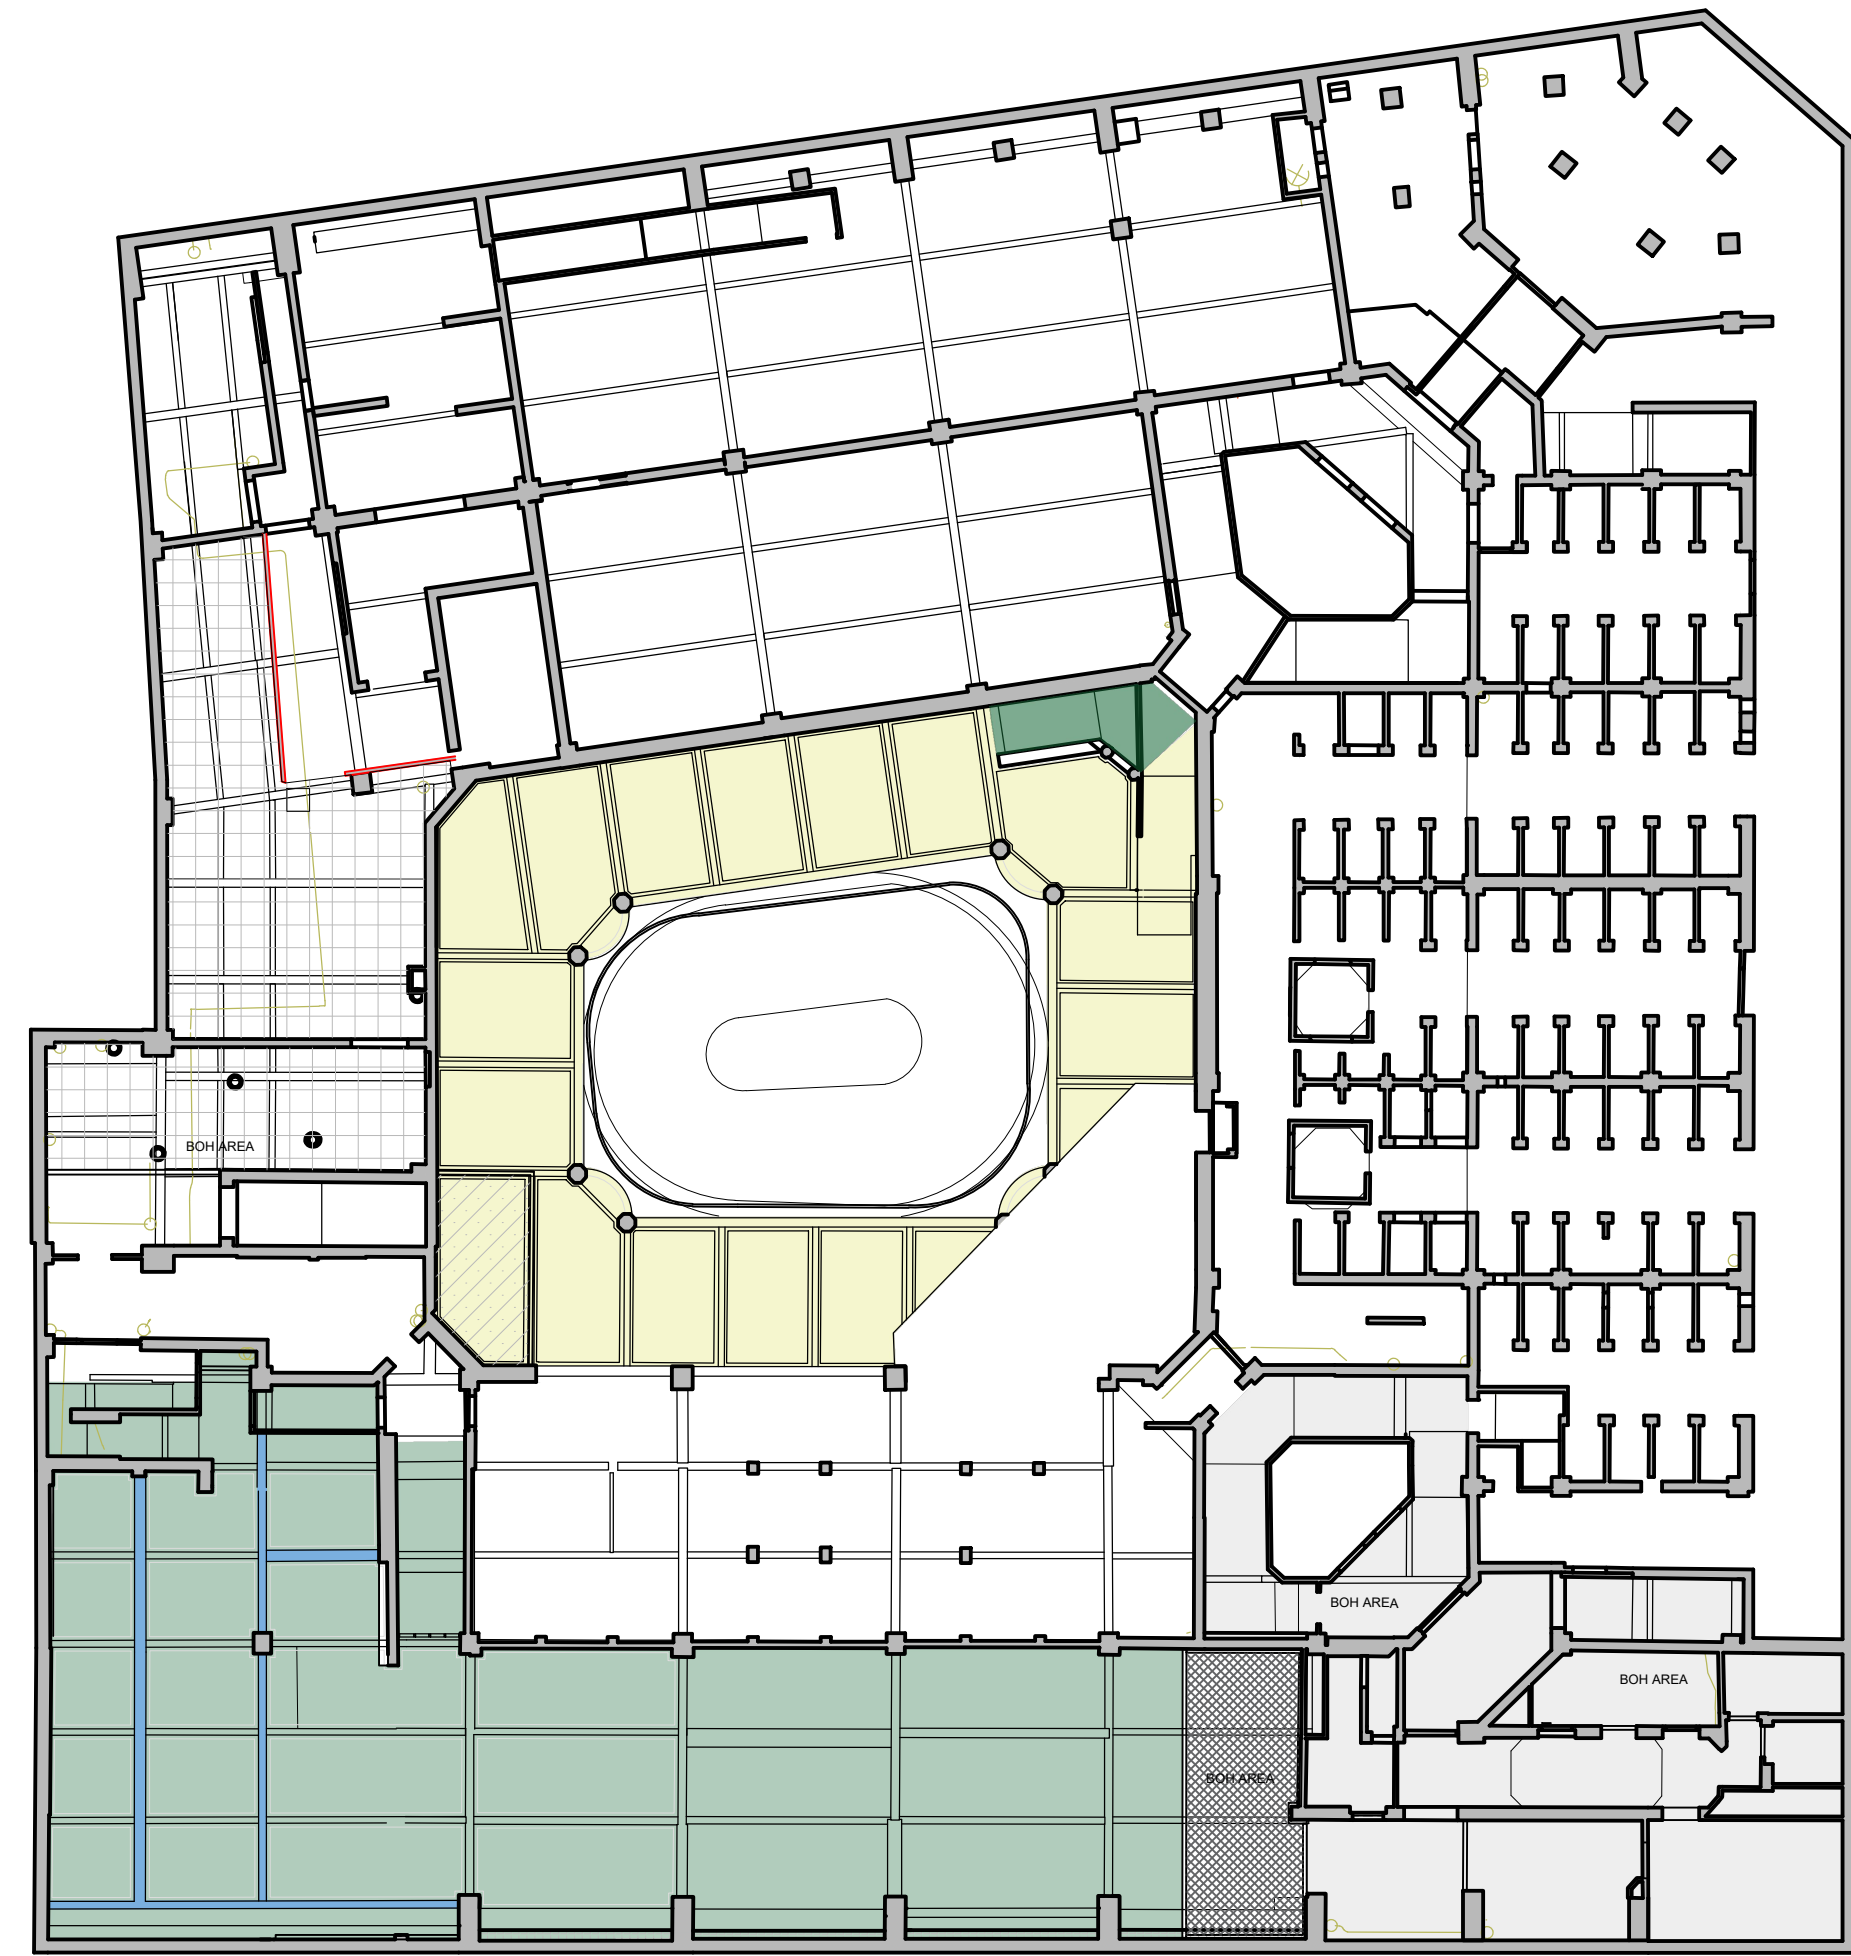


PROPOSED RCP BASEMENT

1:500

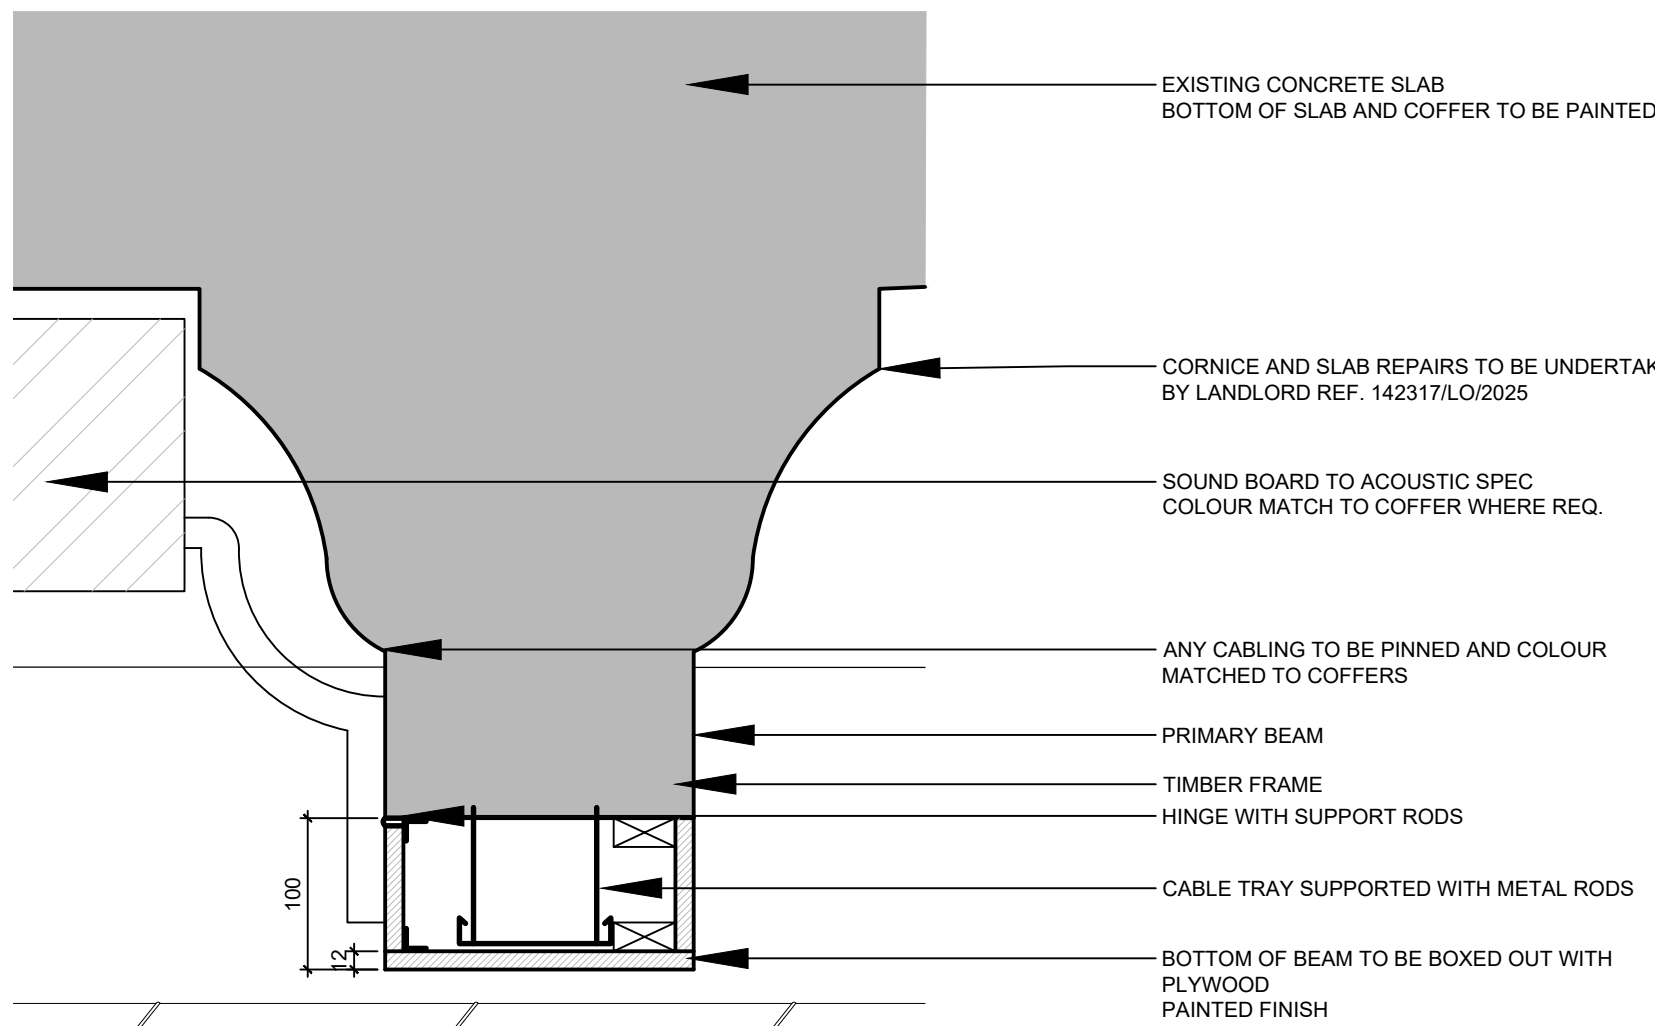

D01 - BEAM DETAIL

1:5

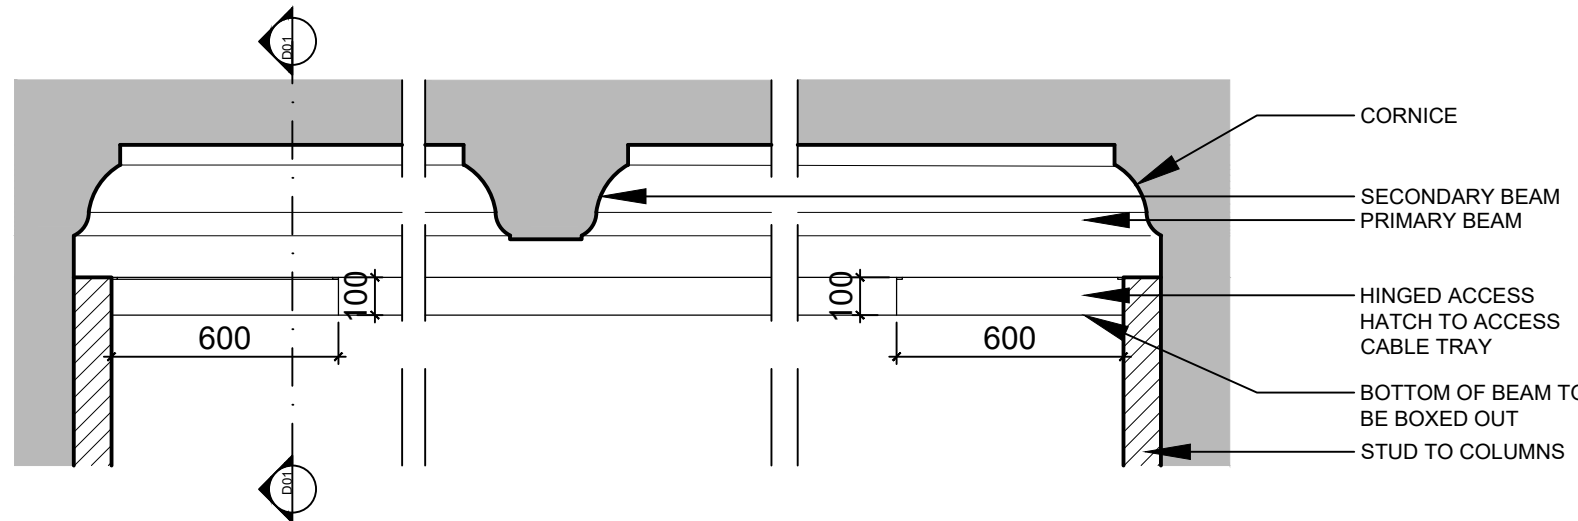

D02 - ACCESS HATCH TO BOTTOM OF BEAM

1:20



EXAMPLE CEILING TREATMENTS

Do not scale from this drawing. All dimensions to be checked on site prior to manufacture and construction. This drawing is the property of Harrison Ince Holdings Limited and should not be reproduced without permission. All discrepancies to be brought to the attention of the architect immediately. This drawing is to be read in conjunction with the specification / bill of quantities and related drawings.

REVISIONS

-	FIRST ISSUE	03.07.25	GW
A	REVISED PLANNING ISSUE	05.08.25	GW

- ACOUSTIC SOUND BOARD
NOTE: PLEASE REFER TO MECHANICAL DRAWING SET FOR HVAC SCHEME
- PROPOSED BEAMS FOR BOXING OUT REFER TO AL D01 AND D02
- AREA WITH EXPOSED M&E
REF: BRANDING GREEN TO MATCH CEILING PAINT
- AREA WITH EXPOSED MECHANICAL DUCTING ELECTRICAL TO RUN IN CEILING VOID
REF: WHITE TO MATCH CEILING PAINT
- AREA WITH EXPOSED M&E
REF: WHITE TO MATCH CEILING PAINT
- AREA WITH EXPOSED M&E
REF: GALVANISED
- BACK OF HOUSE AREAS WITH EXPOSED M&E
REF: WHITE PVC TRUNKING AND GALV MECH
- SUSPENDED CEILING

NOTES:

ALL FIRE SAFETY EQUIPMENT LOCATIONS TO BE CHECKED BY FIRE ENGINEER. PLEASE REFER TO MECHANICAL PACKAGE FOR DETAILS ON MECHANICAL SCHEME.

ALL CABLING IN CUSTOMER AREAS WILL BE HOUSED WITHIN CONDUITS. TO BE COLOUR MATCHED.

ALL DUCTWORK WILL BE EXPOSED. TO BE COLOUR MATCHED TO CEILING IN CUSTOMER AREAS.


NO FIXINGS WILL BE MADE TO CORNICE DETAILING.

REFER TO LIGHTING PLAN FOR LIGHT FITTING DETAILS.

FOR PLANNING

ALL DIMENSIONS TO BE CHECKED ON SITE BEFORE CONSTRUCTION

@1:500 scale

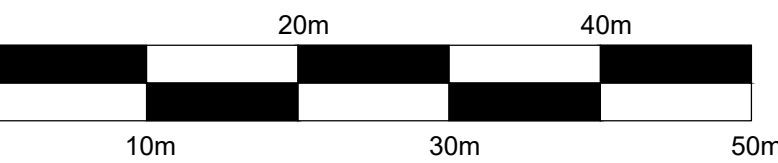

HARRISON INCE

ARCHITECTS INTERIOR DESIGNERS

PINS SOCIAL CLUB

CLIENT

SUNLIGHT HOUSE
LITTLE QUAY ST, MANCHESTER M3 3HP

PROPOSED CEILING DETAILS

TITLE

DATE AUGUST 2025

JOB NO. 01

DRAWN CAD/GW

SCALE 1:100 @ A1

DWG. NO. AL100 A

CHECKED

SECOND FLOOR
EASTGATE
2 CASTLE STREET
MANCHESTER
M3 4LZ
TEL: 0161 236 3650
EMAIL: admin@harrison-ince.co.uk