
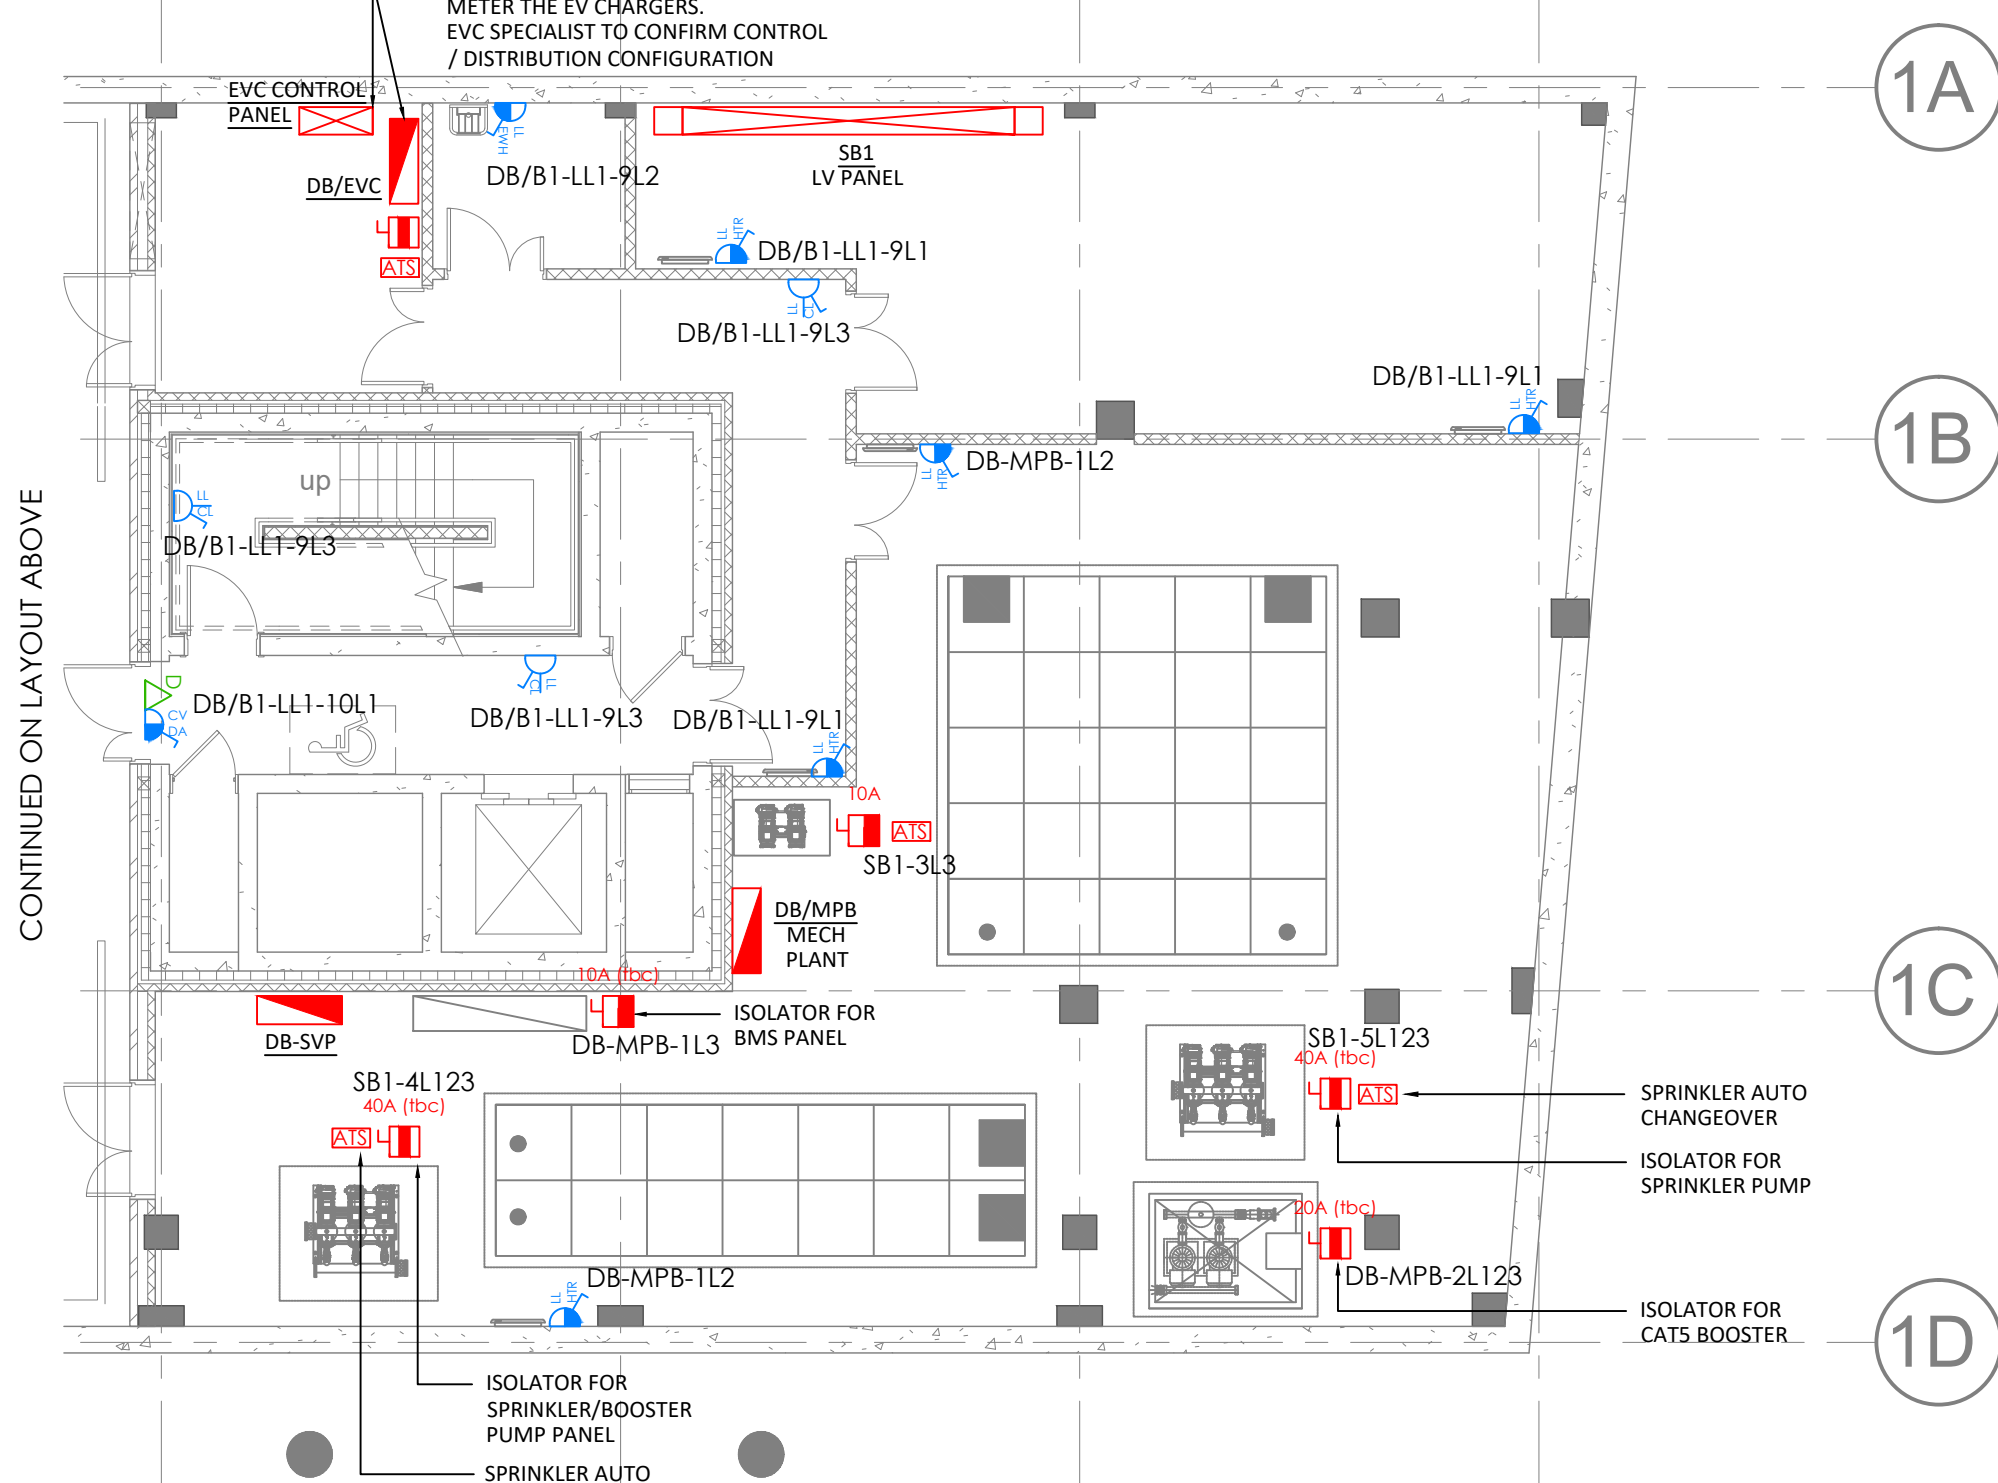


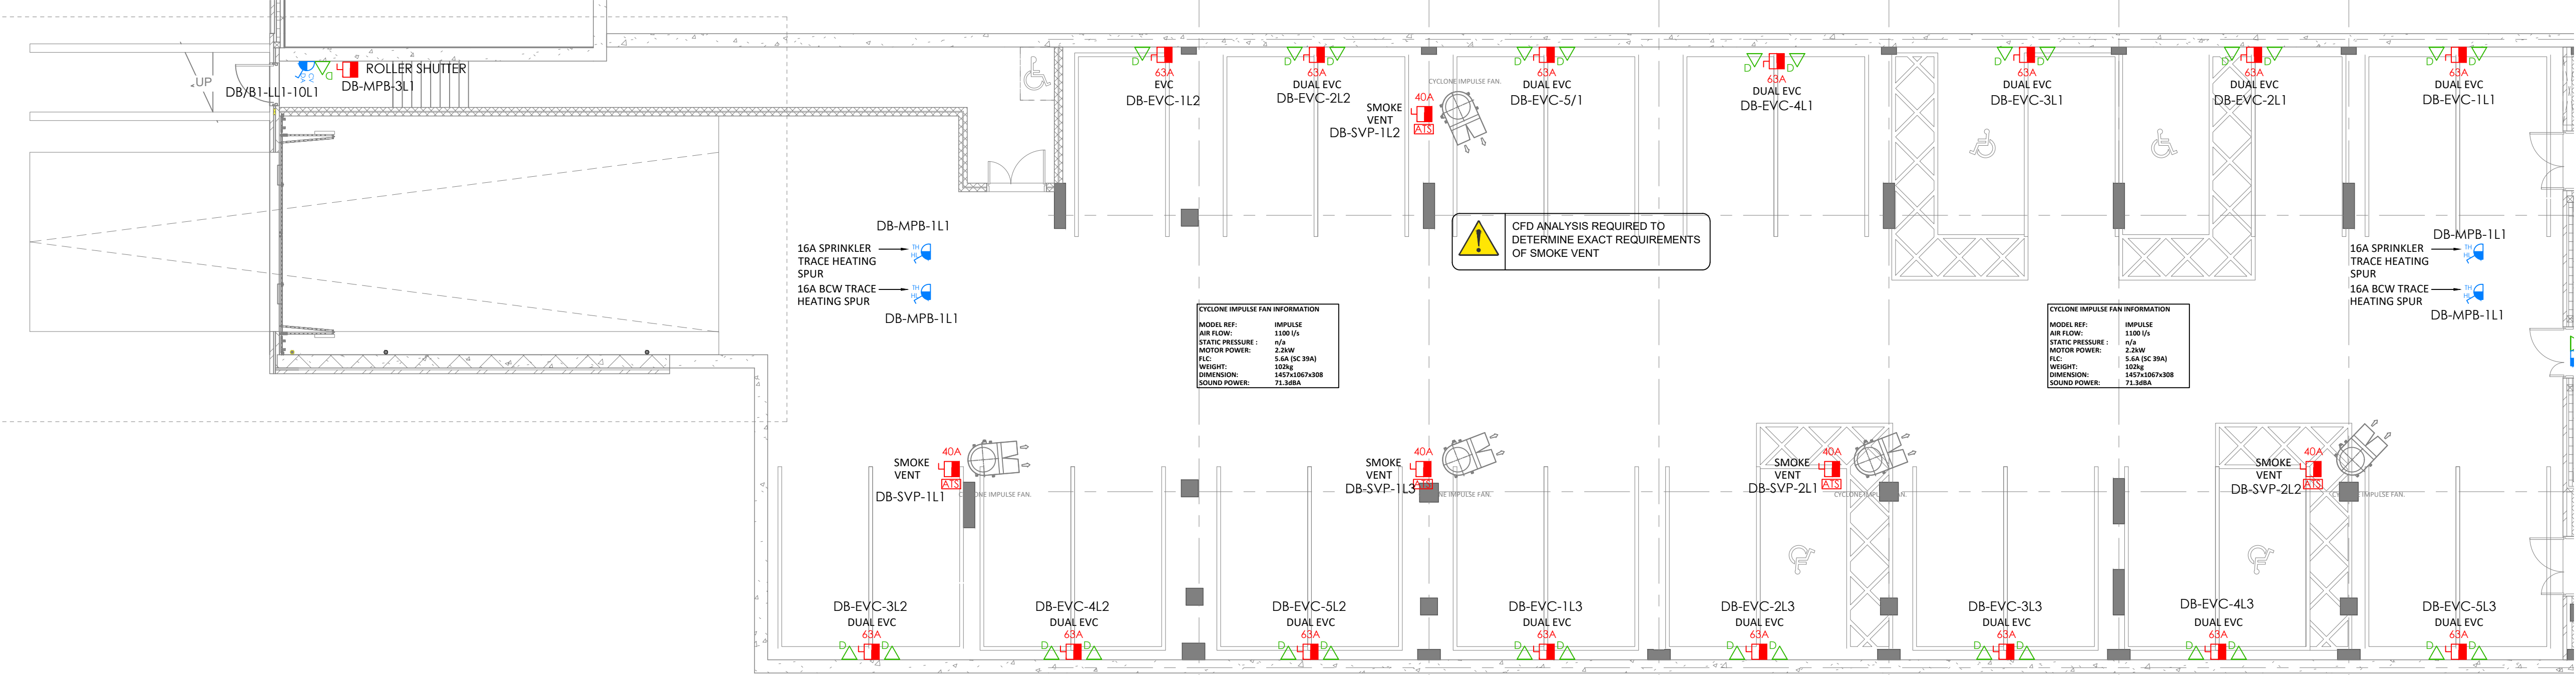

62. SMALL POWER & DATA ABBREVIATIONS	
CL	CLEANERS SOCKET
LL	LOW LEVEL
ML	MID LEVEL
HL	HIGH LEVEL
CV	CEILING VOID
DB	DISTRIBUTION BOARD
HTR	ELECTRIC PANEL HEATER
HURU	HEAT RECOVERY UNIT
SAP	SECURITY ALARM PANEL
FAP	FIRE ALARM PANEL
DP	DRAINAGE PUMP
WH	WATER HEATER
EX	EXTRACT FAN
FCU	FAN COIL UNIT
EVC	ELECTRIC VEHICLE CHARGING

62 SMALL POWER & DATA NOTES

1. THIS DRAWING IS TO BE READ IN CONJUNCTION WITH ALL OTHER DRAWINGS AND DOCUMENTS RELATING TO THE MECHANICAL AND ELECTRICAL INSTALLATIONS.
2. ALL DIMENSIONS WHERE SHOWN ARE IN MILLIMETERS / METERS. THIS DRAWING SHALL NOT BE SCALED. THE CONTRACTOR SHALL BE RESPONSIBLE FOR CHECKING ALL DIMENSIONS THROUGH SITE MEASUREMENTS PRIOR TO COMMENCEMENT OF THE WORKS.
3. ALL OTHER DISCIPLINES' SPECIFICATIONS SHALL BE READ IN CONJUNCTION WITH THE HURSTWOOD ENVIRONMENTAL BUILDING SERVICES SPECIFICATION AND DRAWINGS AS WELL AS ARCHITECT'S, STRUCTURAL ENGINEER'S, ACOUSTIC ENGINEER'S AND FIRE CONSULTANTS. ANY DISCREPANCIES BETWEEN ANY DOCUMENT, DRAWING OR SCHEDULE SHOULD BE CLARIFIED AT TENDER OR THE MOST COST ONEROUS OPTION SHALL BE DEEMED TO HAVE BEEN ALLOWED FOR.
4. ANY CONNECTION PLATE TO CONSIST OF HDMI, VGA & AUDIO. TO BE PROVIDED AS PART OF THE ELECTRICAL INSTALLATION BY THE ELECTRICAL CONTRACTOR COMPLETE WITH INTEGRAL CABLING BETWEEN PLATES

62. SMALL POWER LEGEND	
	SP&N ISOLATOR
	TP&N ISOLATOR
	DISTRIBUTION BOARD
	LV PANEL
	AUTO CHANGEOVER SWITCH
	13A SINGLE SWITCHED SOCKET OUTLET
	SWITCHED FUSED SPUR
	13A TWIN SWITCHED SOCKET OUTLET
	FUSED SPUR
	BS EN 60309 SWITCHED SOCKET OUTLET
	DATA OUTLET 1 GANG
	CCTV OUTLET
	WIFI BOOSTER

C01	CE	04/09/24	SS ISSUE - CONSTRUCTION
P05	CE	20.02.24	STAGE 4 - EVC POWER SUPPLIES AMENDED
P04	CE	19.10.23	STAGE 4 ISSUE
P03	CE	31.07.23	STAGE 4 ISSUE
P02	CE	01.03.23	EVC CHARGERS AMENDED
P01	CE	03.02.23	PRELIMINARY REVIEW
REV	CHK	DATE	Description

Architectural X-Ref Drawings:
FF&E X-Ref Drawings:

Drawing Status: **S5 CONSTRUCTION**

McGOFF
CONSTRUCTION

 **hurstwood environmental**
Consulting Engineers
www.hurstwood-eng.co.uk

Bolton Office	Liverpool Office	London Office
Atria	23 Goodlass Road	344 Gray's Inn Road
Spa Road	Speke	Bloomsbury
Bolton	Liverpool	London
BL1 4AG	L24 9HJ	WC1X 8BP
T: 01204 770 041	T: 0151 728 3360	T: 0203 755 3711
E: bolton@burthwood.ang.co.uk	E: liverpool@burthwood.ang.co.uk	E: london@burthwood.ang.co.uk

Drawn: J KUERSCHNER	Chkd: C EBBS	App: P CHAMBERS	A1
Date: JAN 2023	Scale: 1:100		

Project: ROCHDALE ROAD APARTMENTS

Drawing Title:
BLOCK 1 & 2 - SMALL POWER & DATA LAYOUT - BASEMENT
LEVEL

Project No:	Rev:
23C002-HEC-ZZ-B1-DR-E-6200	C01