



| LIGHTING LEGEND |        |                               |
|-----------------|--------|-------------------------------|
| REF             | SYMBOL | DESCRIPTION                   |
| EX1             |        | Surface mounted LED spotlight |



PROPOSED LIGHTING ELEVATION - YORK STREET  
SCALE 1:100

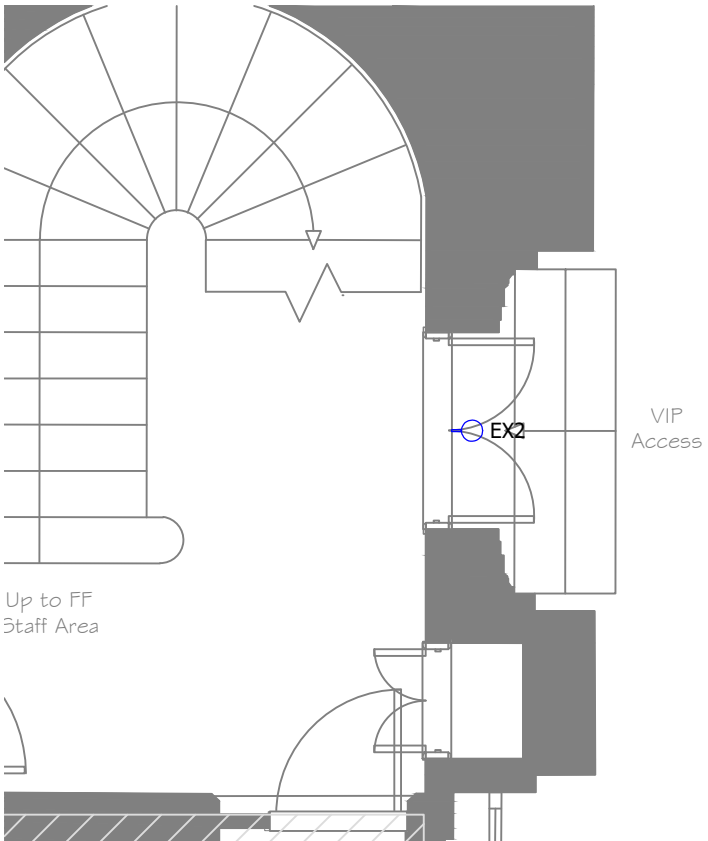

PLAN VIEW OF YORK STREET ENTRANCE  
SCALE 1:50

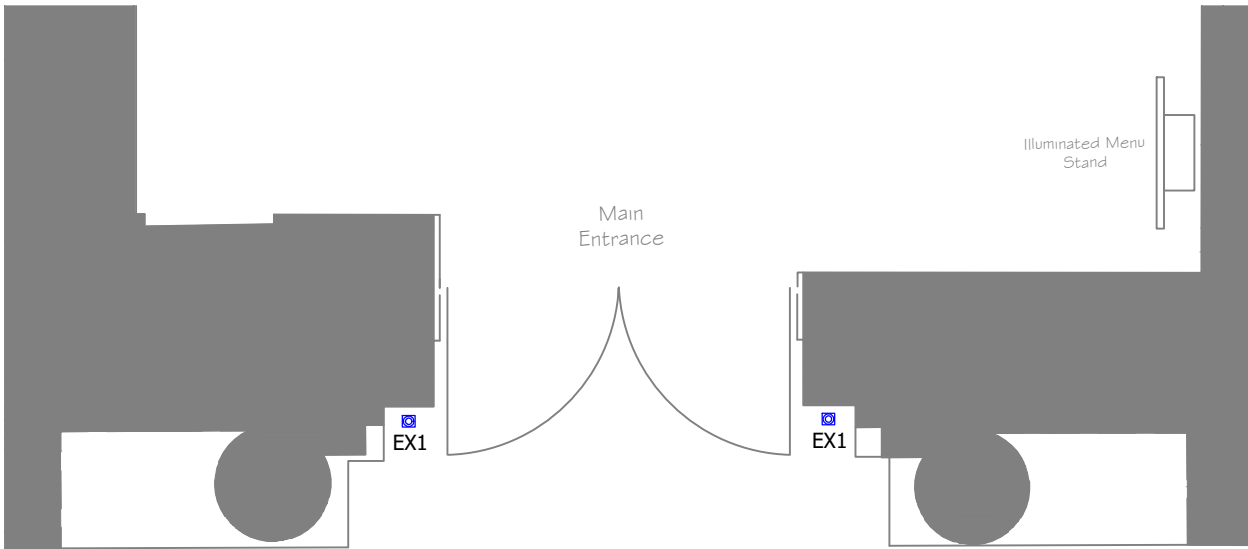

PLAN VIEW OF MAIN ENTRANCE  
SCALE 1:50



PROPOSED LIGHTING ELEVATION - MOSLEY STREET  
SCALE 1:100

EXISTING SURFACE MOUNTED  
WALL LIGHT TO BE RETAINED.

EX1 - INGROUND UPLIGHT RECESSED  
WITHIN A GRANITE STONE BLOCK.  
NARROW BEAM ANGLE. CABLE ENTRY  
BEHIND THE FITTING. BLOCK FINISHED  
TO MATCH ENTRANCE PAVING STONE.

© Mistry Lighting LTD  
All Rights Reserved. Mistry Lighting (unless otherwise agreed in writing) their rights under s.77 to 89  
of the Copyright, Designs and Patents Act 1988.

DO NOT SCALE THIS DRAWING.

Notes

DRAWING TO BE PRINTED IN COLOUR

- THIS DRAWING MUST BE READ IN CONJUNCTION WITH ALL OTHER RELEVANT PROJECT DRAWINGS AND SPECIFICATIONS
- DO NOT SCALE FROM THIS DRAWING. IF IN DOUBT PLEASE REQUEST FURTHER INFORMATION.
- ALL DIMENSIONS ARE SHOWN IN MILLIMETERS UNLESS NOTES STATE OTHERWISE.
- SYMBOLS INDICATE PROPOSED LOCATIONS OF LIGHTING EQUIPMENT. FOR FURTHER INFORMATION PLEASE REFER TO THE LUMINAIRE SCHEDULES AND DETAILS SHOWN.
- THE LIGHTING INSTALLATION REQUIRES A VARIETY OF LUMINAIRE TYPES TO ACHIEVE THE DESIRED AFFECTS. INFORMATION HAS BEEN PROVIDED ON THIS DRAWING AS GENERAL GUIDANCE AND OUTLINE OF GOOD PRACTICE. FOR MORE SPECIFIC RECOMMENDATIONS PLEASE REFER TO MANUFACTURERS DETAILS FOR APPLICATION, OPERATION, HANDLING, CLEANING AND DISPOSAL INSTRUCTIONS.
- INSTALLATION AND MAINTENANCE OF LIGHTING EQUIPMENT INSTALLED AT ANY HEIGHT ABOVE GROUND REQUIRES PRECAUTIONS TO BE TAKEN. ACCESS ARRANGEMENT SHOULD BE IN STRICT ACCORDANCE WITH THE PROJECTS ACCESS REPORT, METHOD STATEMENT AND HEALTH AND SAFETY GUIDELINES.

|     |                        |          |    |
|-----|------------------------|----------|----|
| 06  | FACADE LIGHTING LAYOUT | 02/06/25 | KM |
| 05  | FACADE LIGHTING LAYOUT | 26/03/25 | KM |
| 04  | FACADE LIGHTING LAYOUT | 25/02/25 | KM |
| 03  | FACADE LIGHTING LAYOUT | 17/02/25 | KM |
| 02  | FACADE LIGHTING LAYOUT | 30/01/25 | KM |
| 01  | FACADE LIGHTING LAYOUT | 15/01/25 | KM |
| Rev | Description            | Date     | Dm |

SCHEME DESIGN

Status of drawing

**MISTRY  
LIGHTING**



0774715 3333  
WWW.MISTRYLIGHTING.COM  
KRISHNA@MISTRYLIGHTING.COM

Project CUT & CRAFT, MANCHESTER

Drawing Title LIGHTING LAYOUT - FACADE

|          |            |        |             |
|----------|------------|--------|-------------|
| Drawn By | Date       | Scale  | Drawing No. |
| KM       | 02/06/2025 | VARIES | ML_CCM_F00  |

|                |          |           |               |
|----------------|----------|-----------|---------------|
| Drawing Order: | Revision | Client    | Stage         |
| 01 of 03       | REV 06   | CUT&CRAFT | SCHEME DESIGN |