


View of existing condensers in locations proposed for new

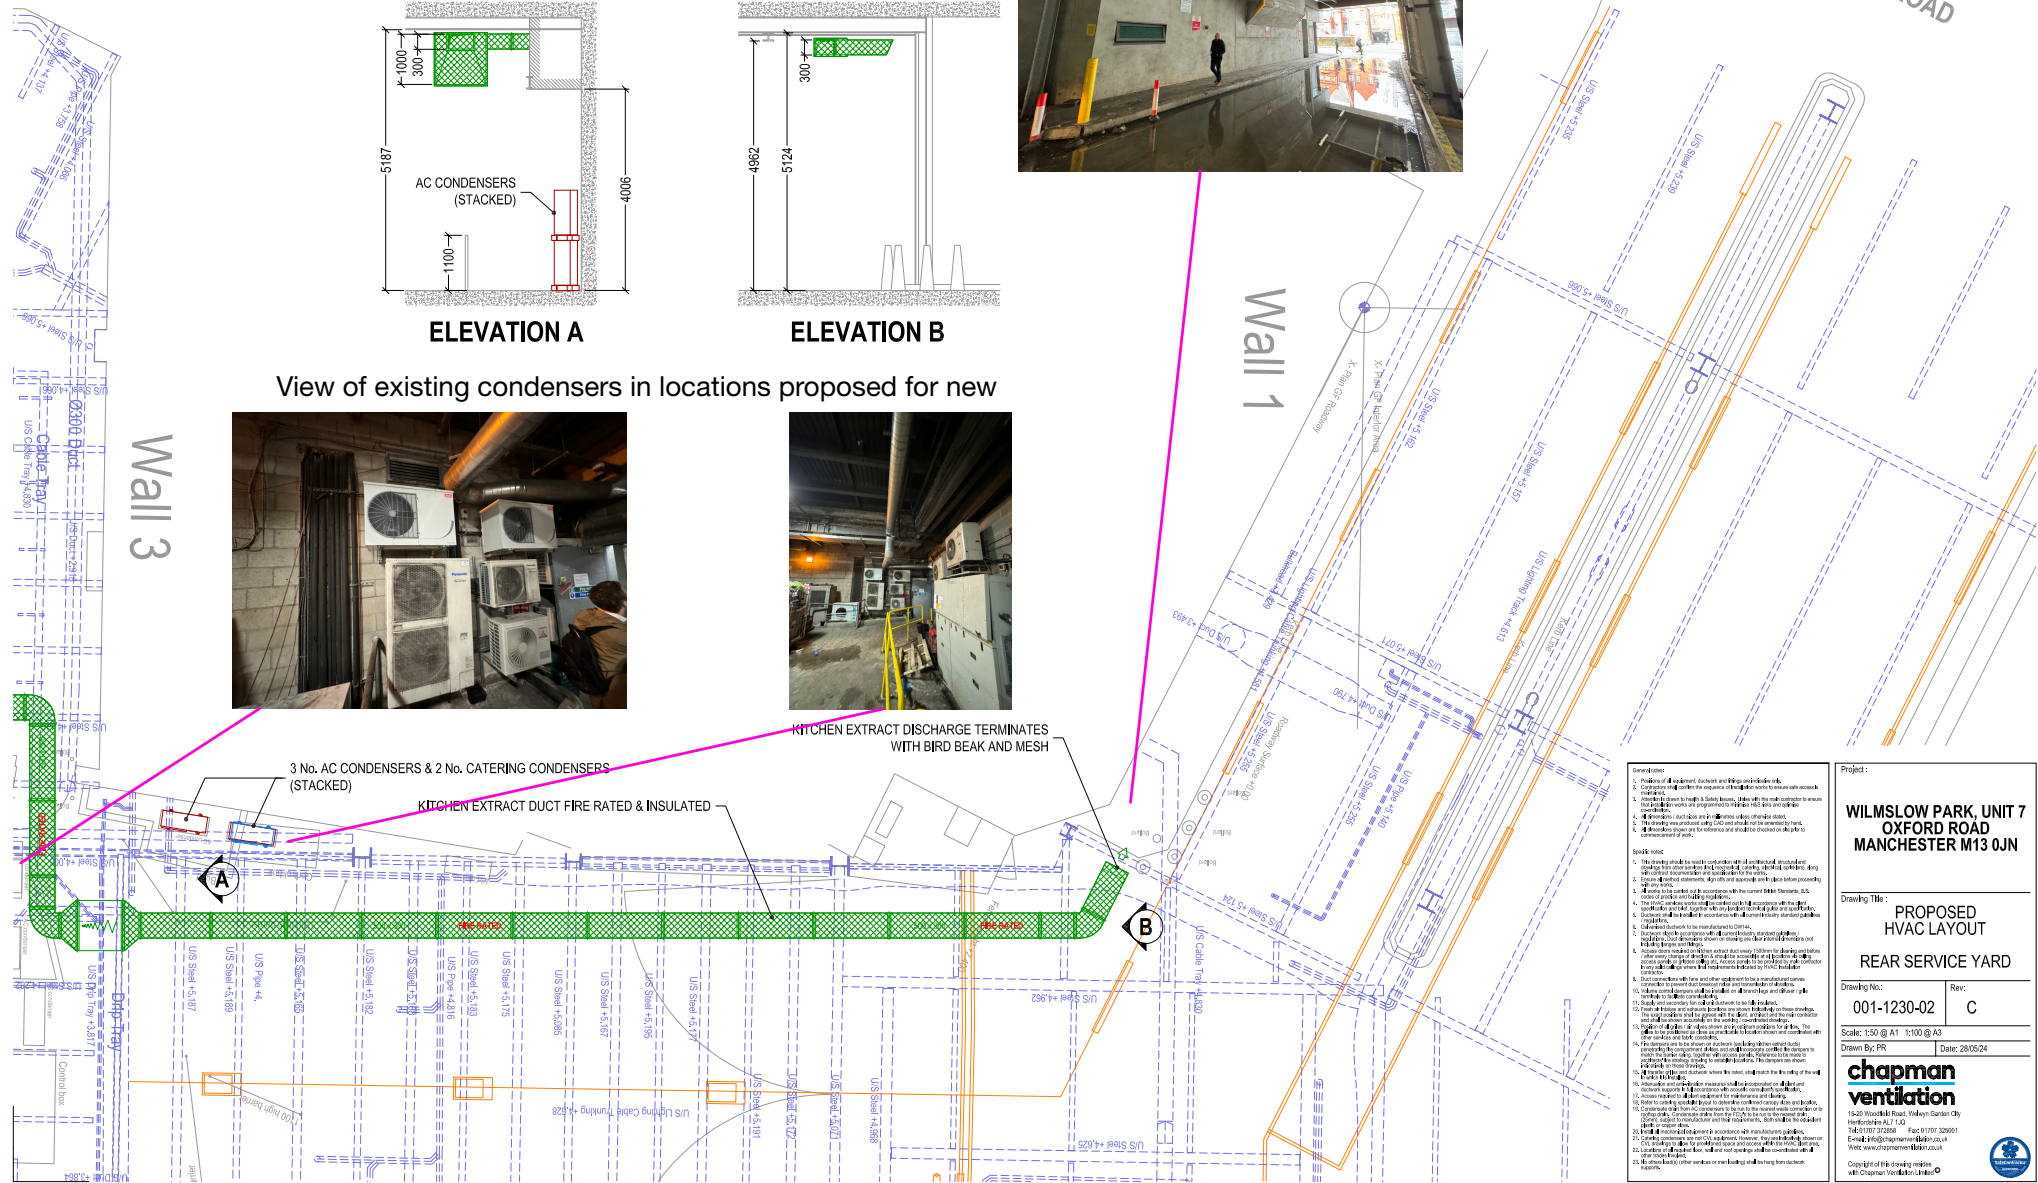

SERVICE YARD ENTRANCE
VIA
HATHERSAGE ROAD

Wall 1

[illegible]

Project :	
WILMSLOW PARK, UNIT 7 OXFORD ROAD MANCHESTER M13 0JN	
Drawing Title : PROPOSED HVAC LAYOUT	
REAR SERVICE YARD	
Drawing No.:	Rev:
001-1230-02	C
Scale: 1:50 @ A1 1:100 @ A0	
Drawn By RY	Date: 28/06/24
chapman ventilation 1250 Kingsway Road, Huddersfield, West Yorkshire HU8 7LJ, UK Tel: 01484 222188 Fax: 01484 222001 Email: info@chapmanvent.co.uk www.chapmanvent.co.uk	
Copyright © this drawing remains all-Chapman Ventilation Ltd. ®	
	