



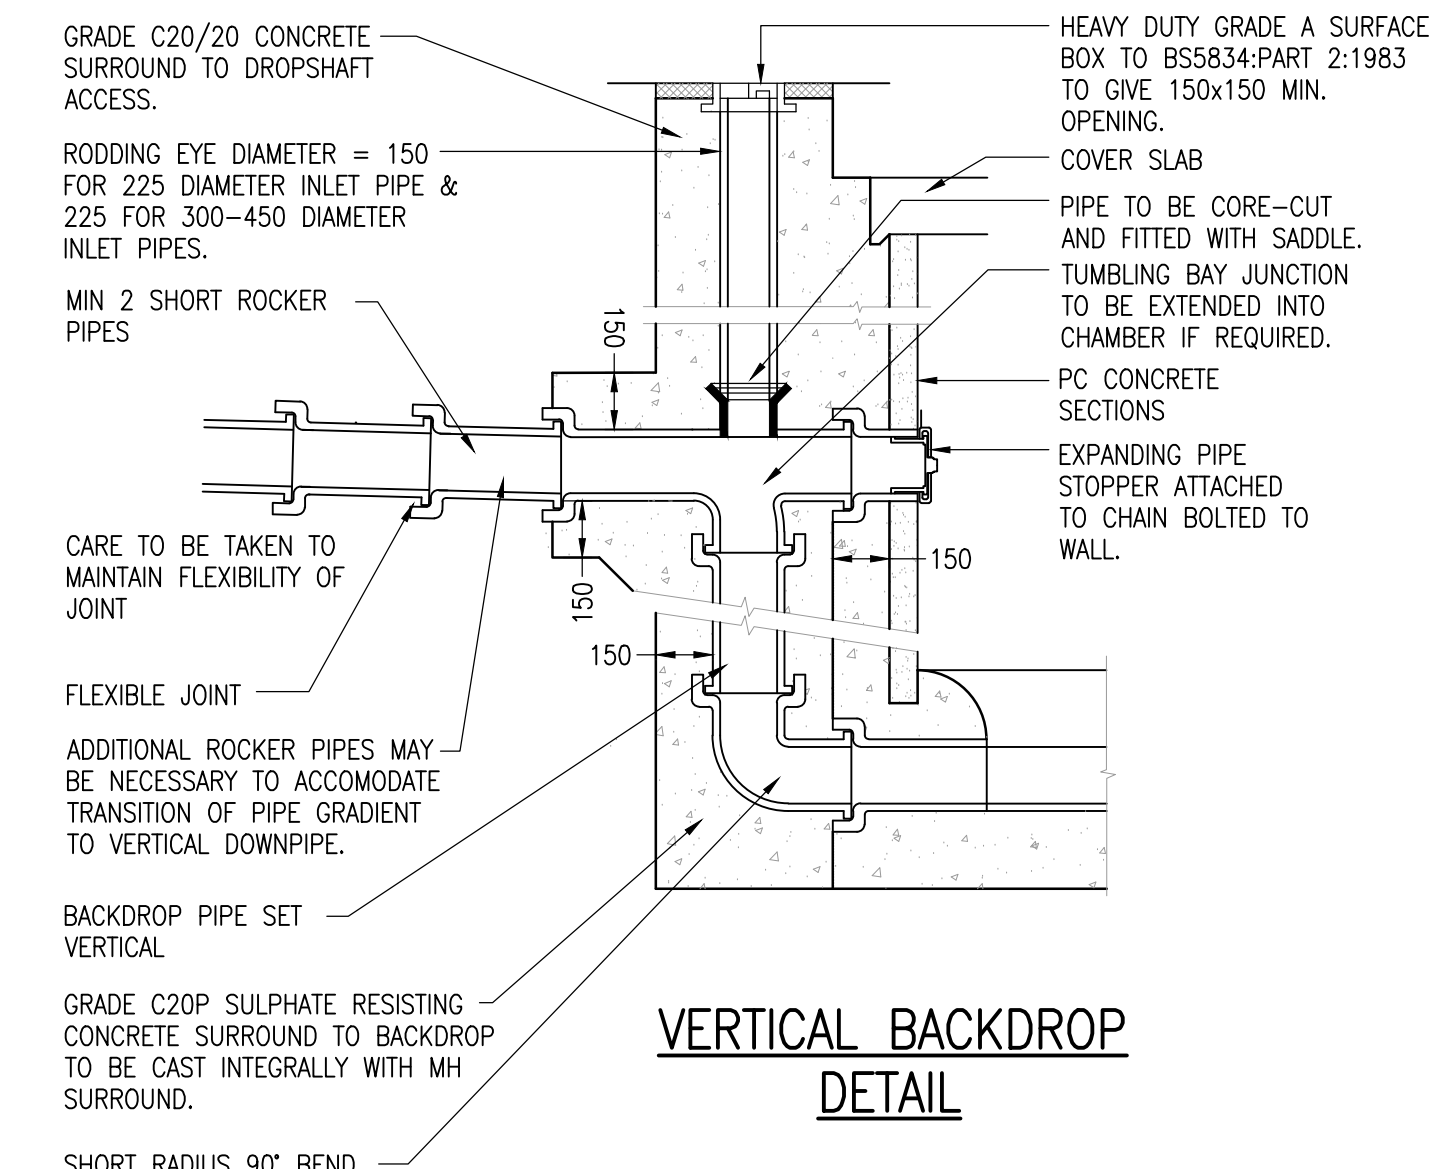


VERTICAL BACKDROP
DETAIL

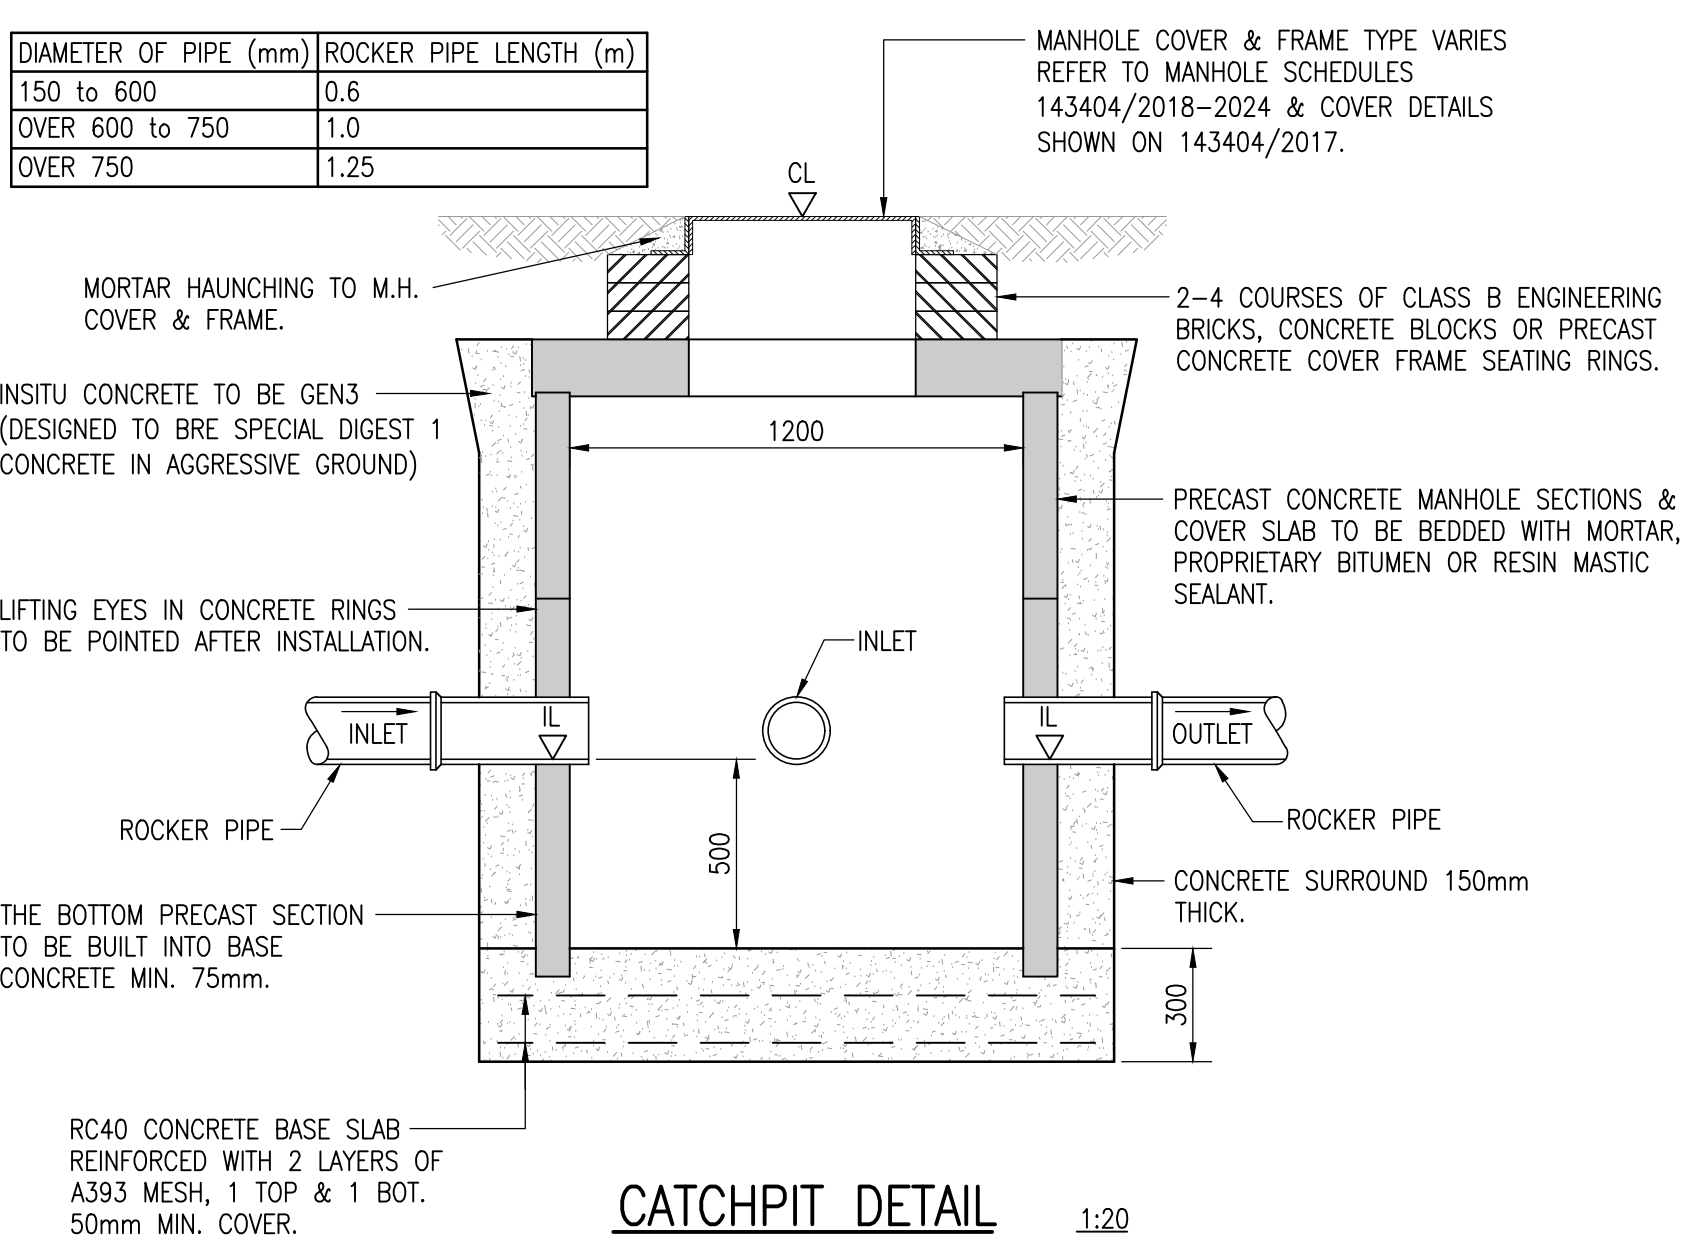


CATCHPIT DETAIL


NOTE:-
REFER TO DRAINAGE LAYOUT & MANHOLE SCHEDULES FOR COVER LEVELS, INVERT LEVELS, INLET & OUTLET LOCATIONS. WHERE THERE IS INSUFFICIENT SPACE TO INSTALL REQUIRED ROCKER PIPES, CONNECTIONS MUST BE FULLY ENCASED IN CONCRETE TO ENSURE THAT THEY CANNOT MOVE.

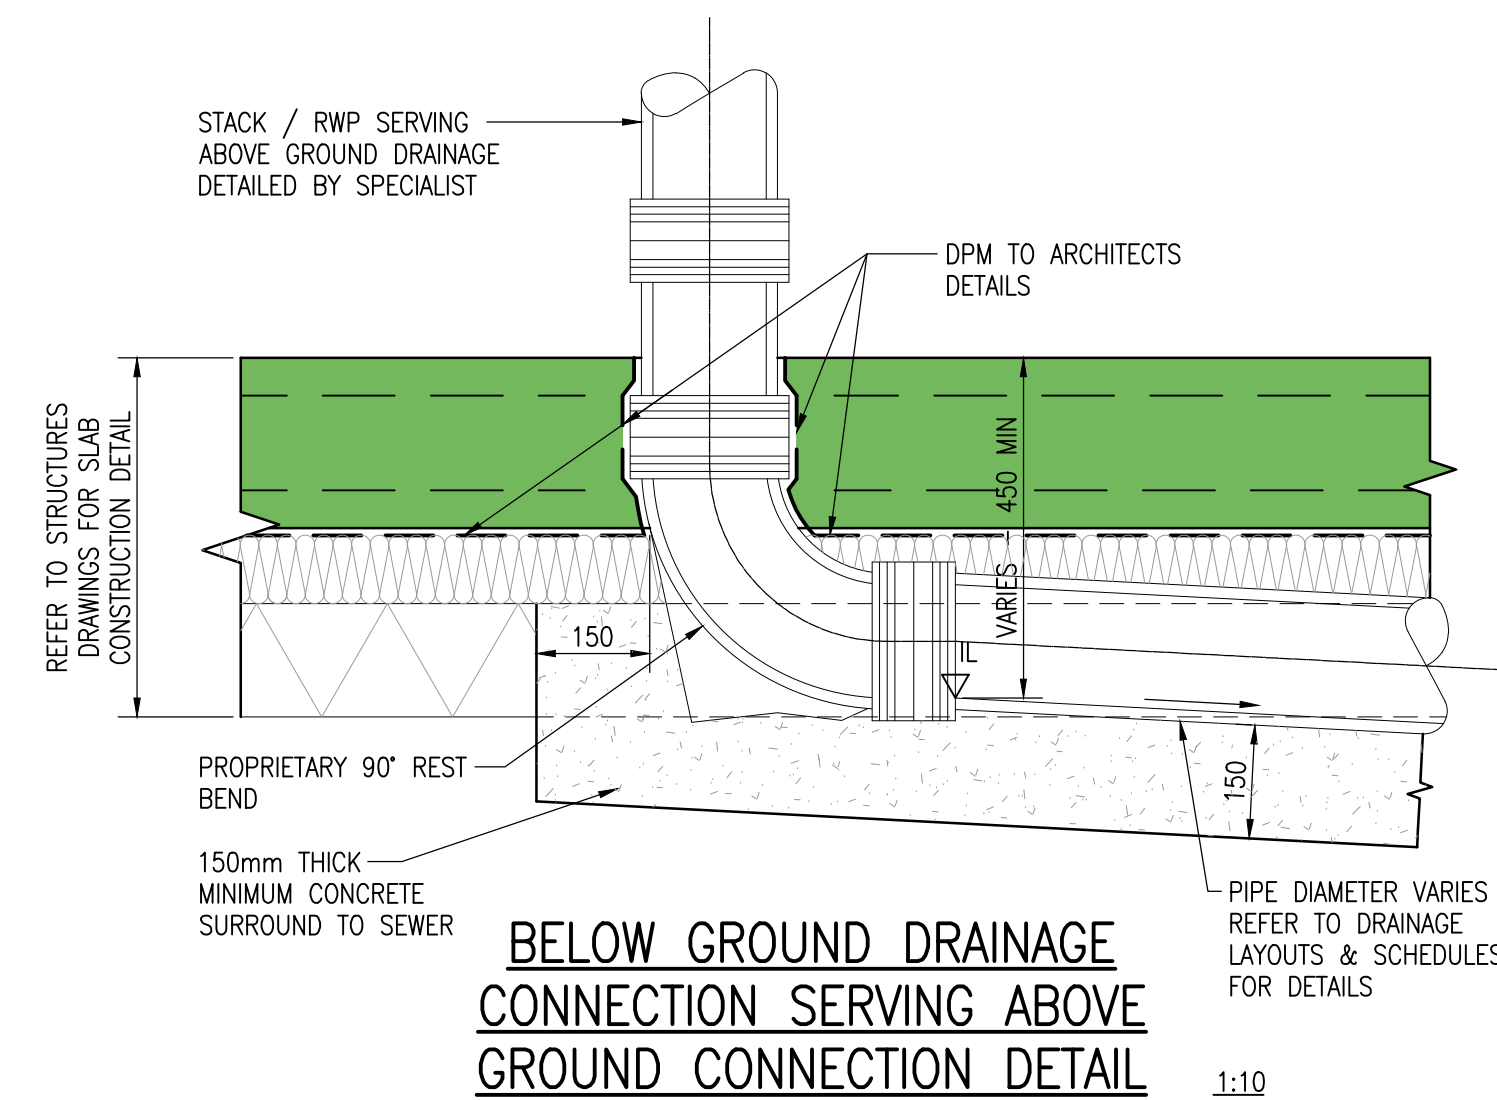


BELOW GROUND DRAINAGE
CONNECTION SERVING ABOVE
GROUND CONNECTION DETAIL

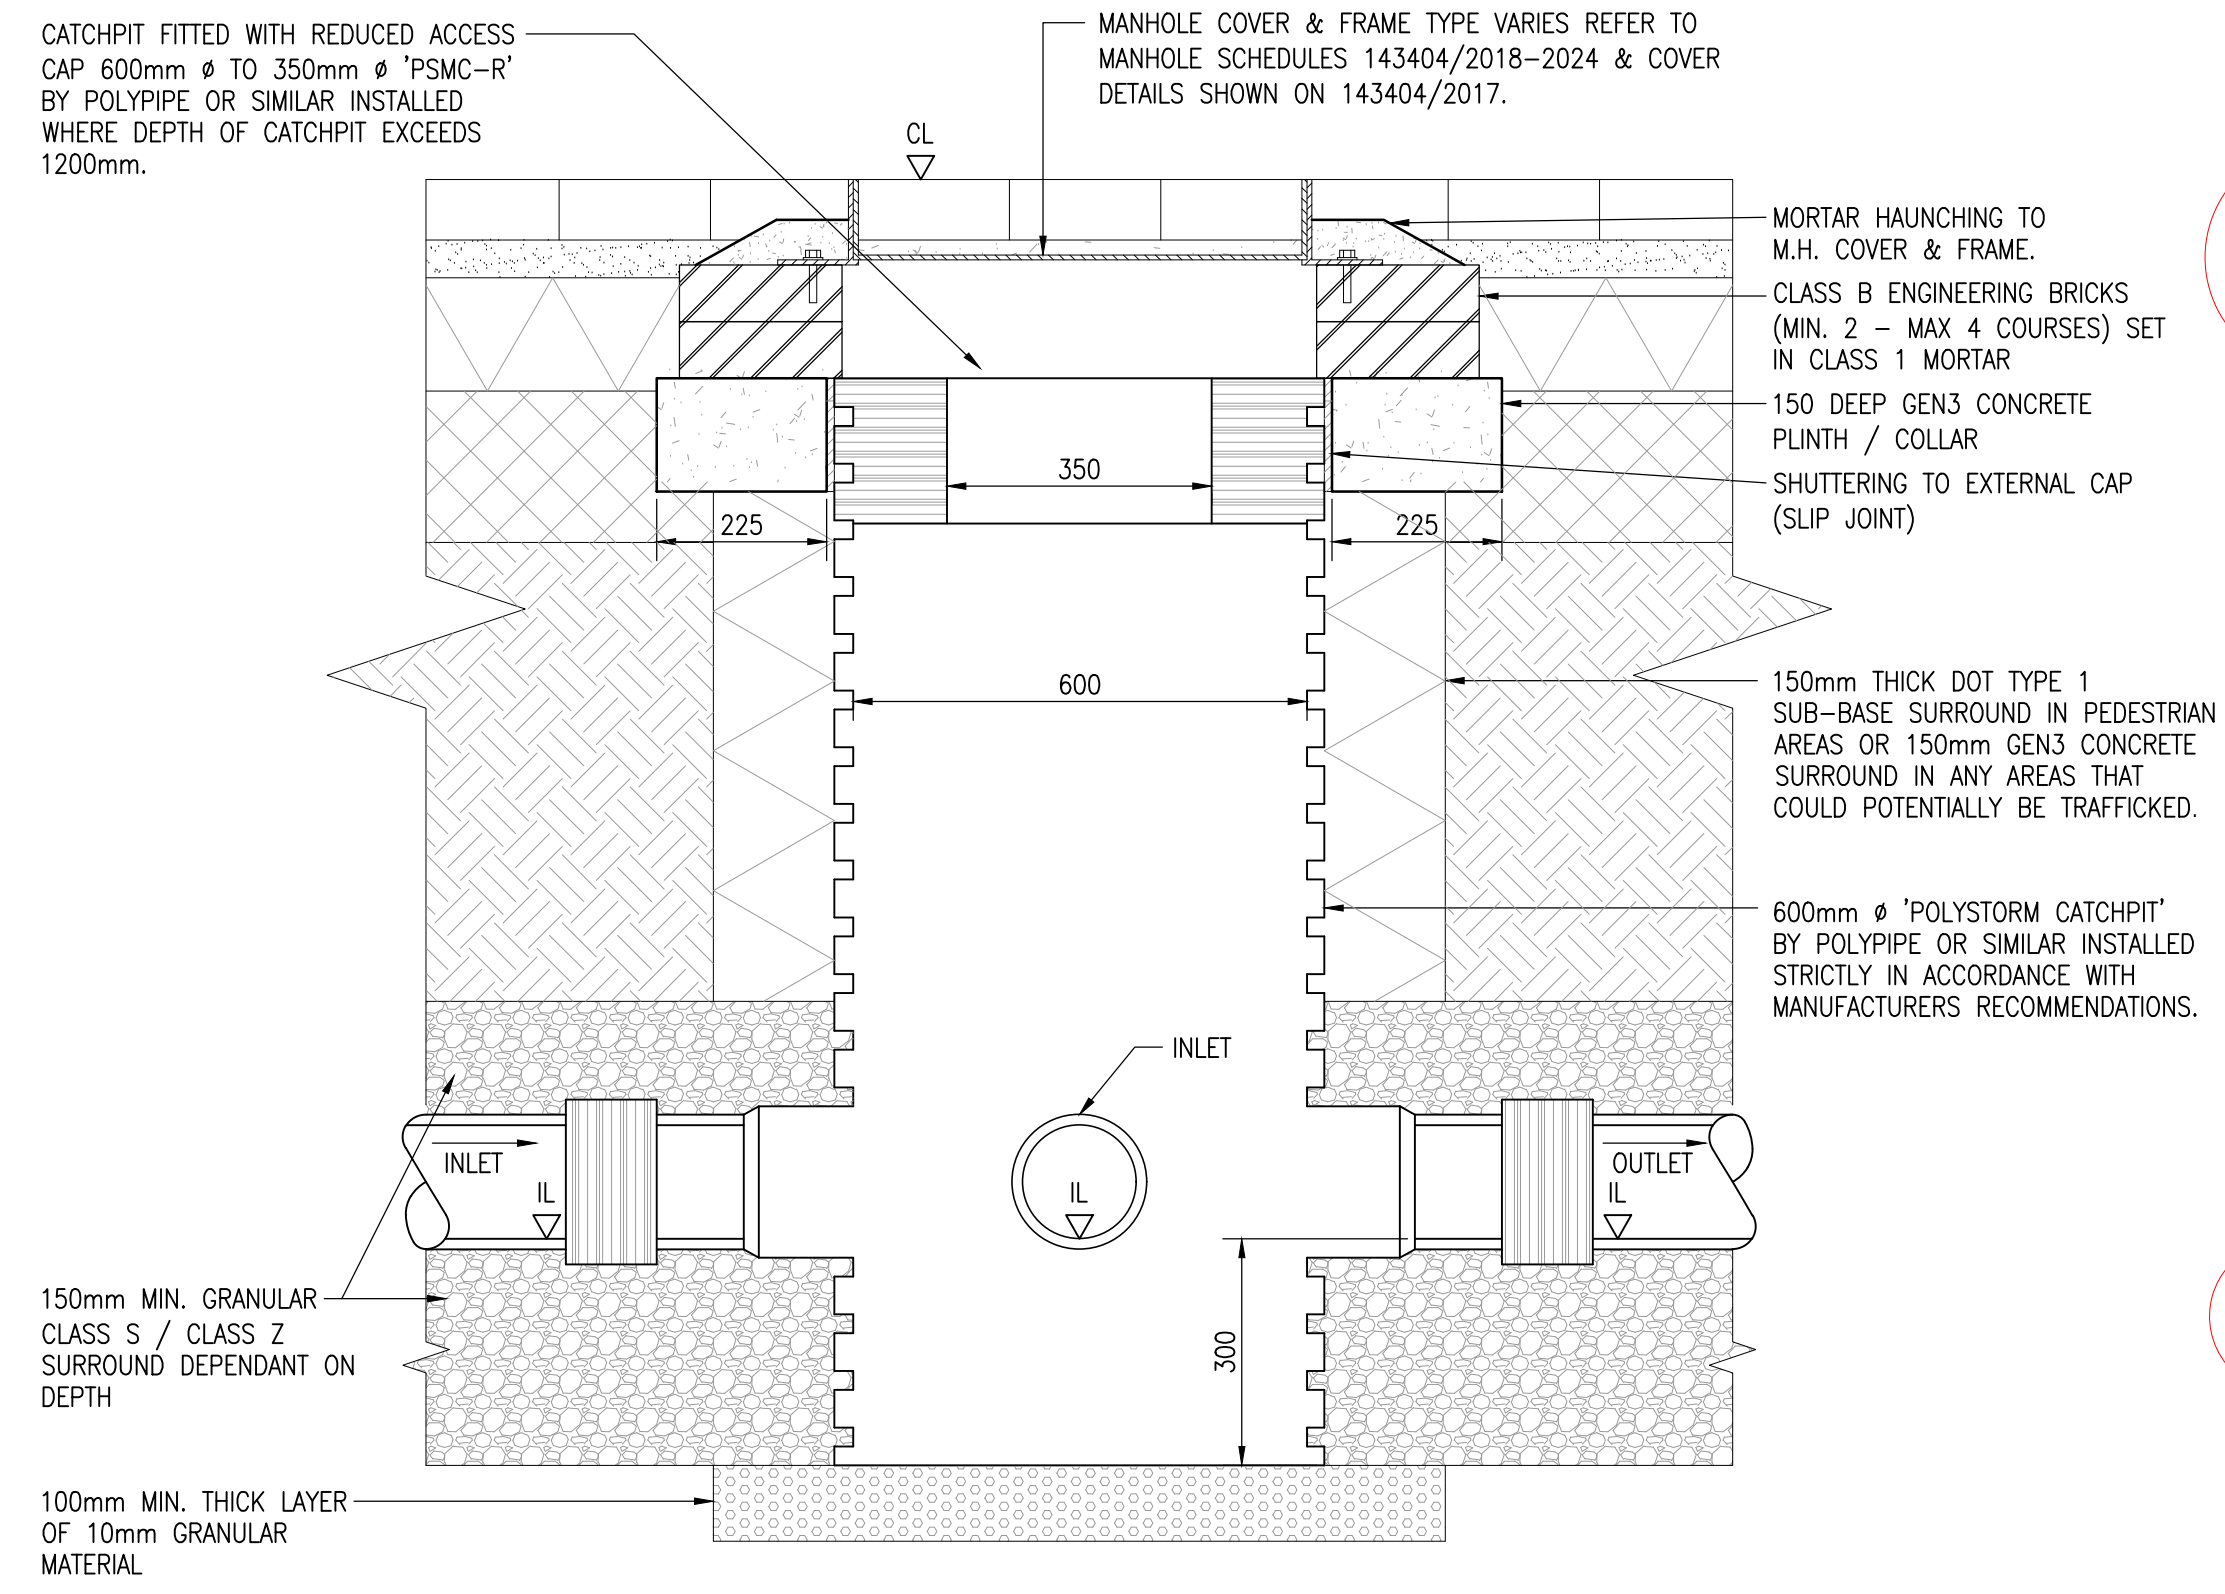

'POLYSTORM CATCHPIT' DETAIL

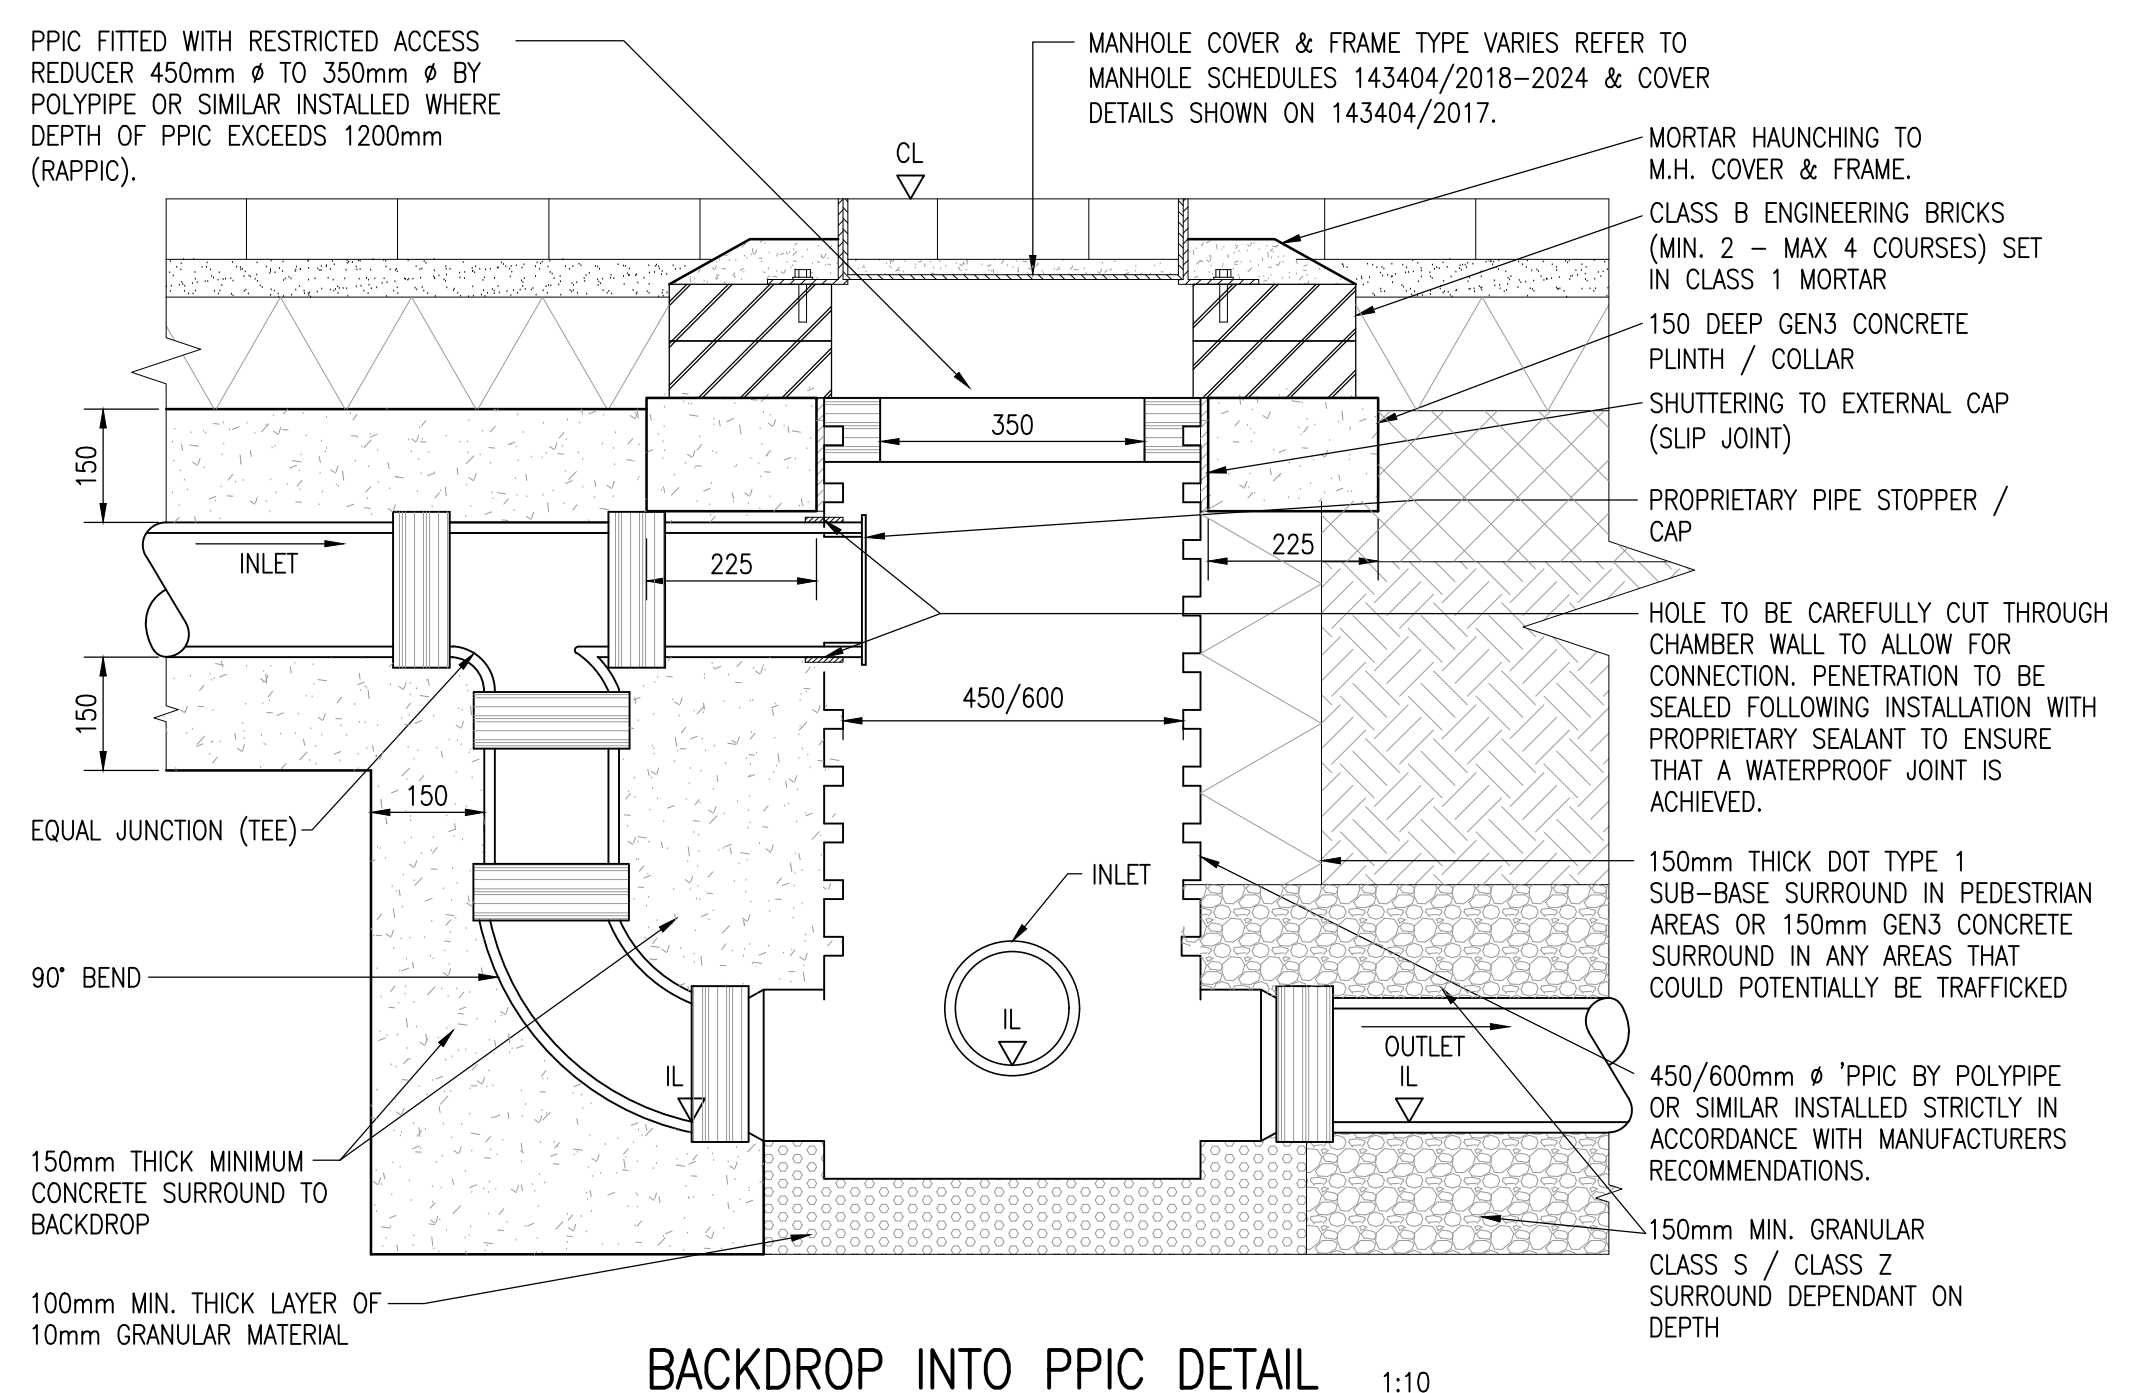

BACKDROP INTO PPIC DETAIL

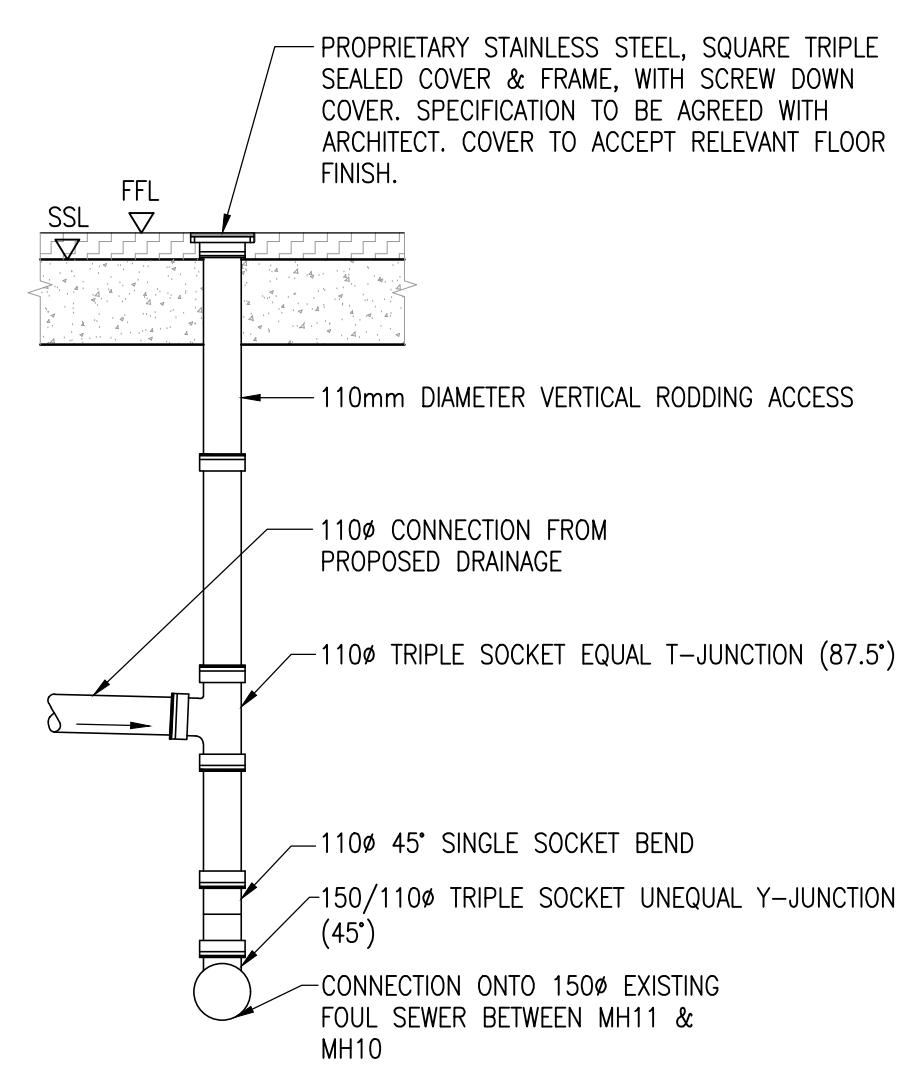

VERTICAL RODDING ACCESS/EYE
DETAIL

Do not scale from this drawing.

SAFETY HEALTH AND ENVIRONMENTAL INFORMATION

IN ADDITION TO THE HAZARD/RISKS NORMALLY ASSOCIATED WITH THE TYPES OF WORK DETAILED ON THIS DRAWING, NOTE THE FOLLOWING RISKS AND INFORMATION.

RISKS LISTED HERE ARE NOT EXHAUSTIVE. REFER TO DESIGN ASSESSMENT FORM NO.

CONSTRUCTION

- RESTRICTED SITE/CONFINED SPACES
- GROUND WATER/INUNDATION

DEMOLITION

FOR INFORMATION RELATING TO USE, CLEANING AND MAINTENANCE SEE THE HEALTH AND SAFETY FILE

IT IS ASSUMED THAT ALL WORKS WILL BE CARRIED OUT BY A COMPETENT CONTRACTOR WORKING, WHERE APPROPRIATE, TO AN APPROVED METHOD STATEMENT.

C02	07/08/24	VERTICAL RODDING ACCESS/EYE DETAIL ADDED.	DAS	JRT	JRT
Rev.	Date	Description	Drwn.	Chkd.	Appd.

FAIRHURST

51a St. Pauls Street
LEEDS
LS1 2TE
Tel: 0113 243 4671
Fax: 0844 361 4412

Client:

united living

new homes

Project Title:

1 NQ & CLEMENTS BUILDING
TARIFF STREET
MANCHESTER

Drawing Title:

DRAINAGE DETAILS
SHEET 2

Scale of A1:	Status:
AS SHOWN	Construction
Drawn:	Checked:
DS	JRT
Date:	Date:
27/02/24	27/08/24
Drawing No.:	
143404-FAI-EX-EX-DR-D-02016-C02	

united living

Document Number
143404-FAI-EX-EX-DR-D-02016

Revision
C02

Issued for Construction

Ms Fatima Asim - United Living

Aug 28, 2024, 11:22 AM GMT+1:00