


ALL DIMENSIONS IN MM

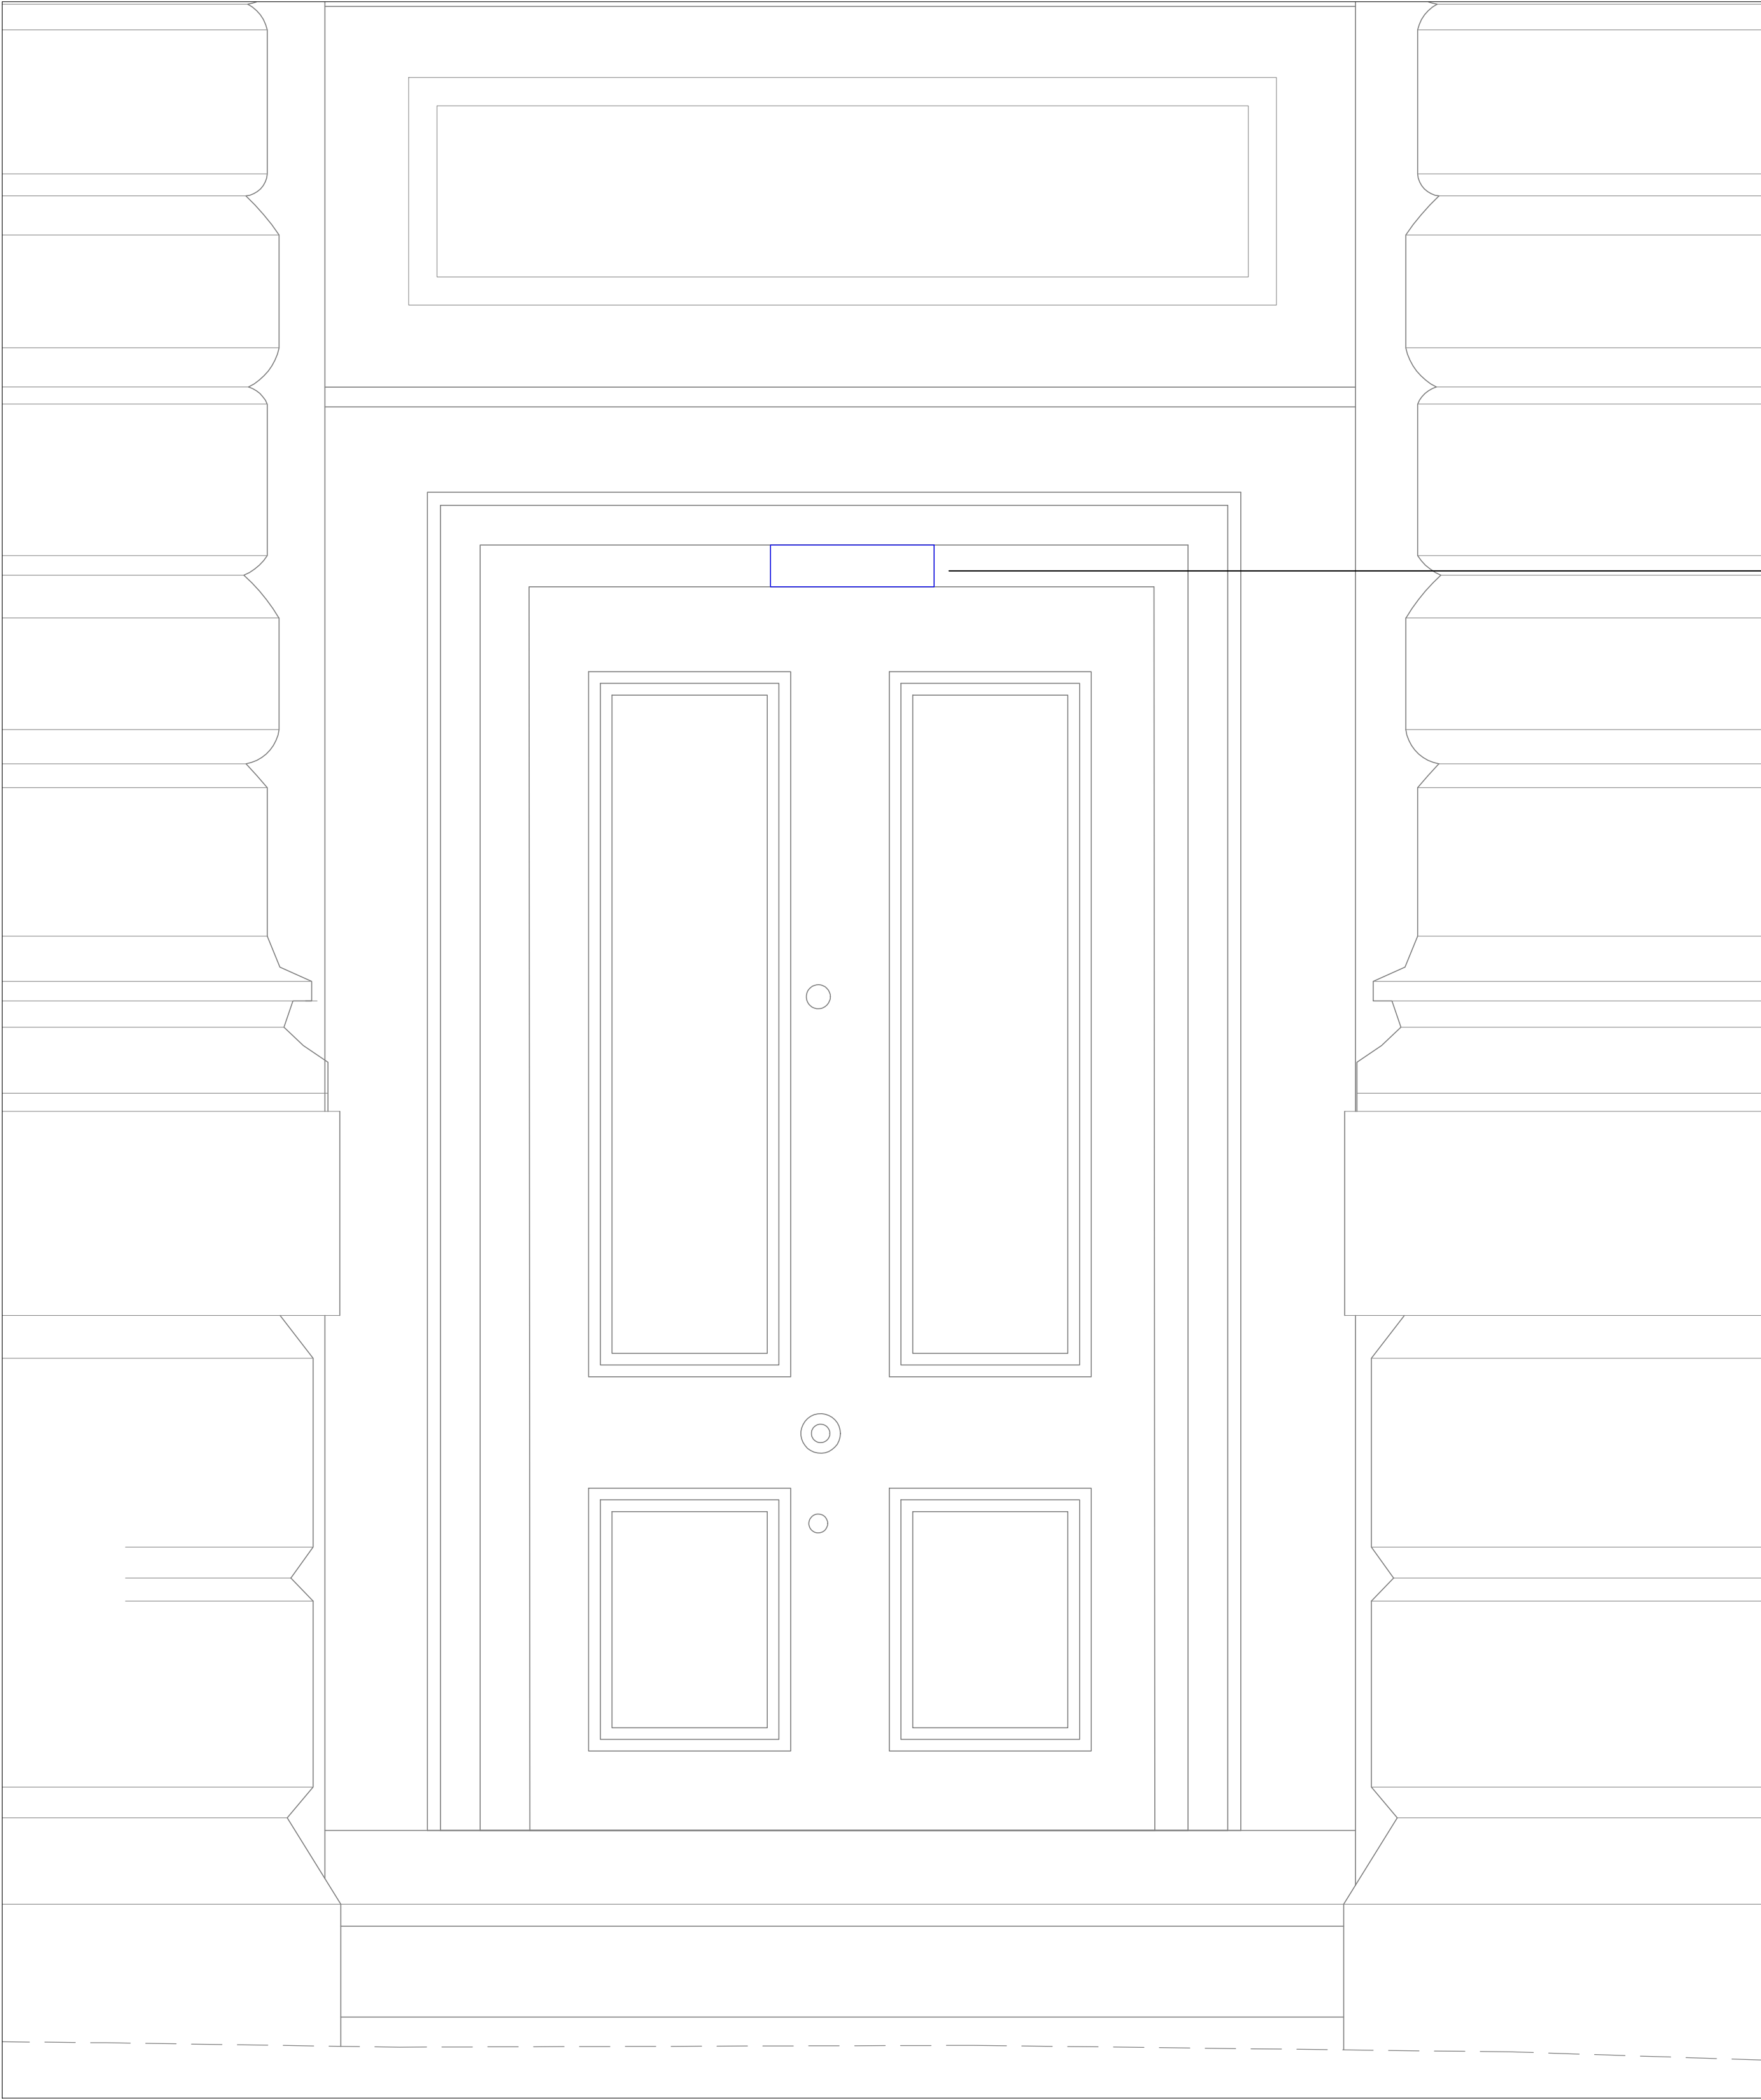

PROPOSED LIGHTING ELEVATION - YORK STREET ENTRANCE
SCALE 1:10

EXISTING SURFACE MOUNTED
WALL LIGHT TO BE RETAINED .

© Mistry Lighting LTD
All Rights Reserved. Mistry Lighting (unless otherwise agreed in writing) their rights under s.77 to 89
of the Copyright, Designs and Patents Act 1988.
DO NOT SCALE THIS DRAWING.

Notes

DRAWING TO BE PRINTED IN COLOUR

1. THIS DRAWING MUST BE READ IN CONJUNCTION WITH ALL OTHER RELEVANT PROJECT DRAWINGS AND SPECIFICATIONS
2. DO NOT SCALE FROM THIS DRAWING. IF IN DOUBT PLEASE REQUEST FURTHER INFORMATION.
3. ALL DIMENSIONS ARE SHOWN IN MILLIMETERS UNLESS NOTES STATE OTHERWISE.
4. SYMBOLS INDICATE PROPOSED LOCATIONS OF LIGHTING EQUIPMENT. FOR FURTHER INFORMATION PLEASE REFER TO THE LUMINAIRE SCHEDULES AND DETAILS SHOWN.
5. THE LIGHTING INSTALLATION REQUIRES A VARIETY OF LUMINAIRE TYPES TO ACHIEVE THE DESIRED AFFECTS. INFORMATION HAS BEEN PROVIDED ON THIS DRAWING AS GENERAL GUIDANCE AND OUTLINE OF GOOD PRACTICE. FOR MORE SPECIFIC RECOMMENDATIONS PLEASE REFER TO MANUFACTURERS DETAILS FOR APPLICATION, OPERATION, HANDLING, CLEANING AND DISPOSAL INSTRUCTIONS.
6. INSTALLATION AND MAINTENANCE OF LIGHTING EQUIPMENT INSTALLED AT ANY HEIGHT ABOVE GROUND REQUIRES PRECAUTIONS TO BE TAKEN. ACCESS ARRANGEMENT SHOULD BE IN STRICT ACCORDANCE WITH THE PROJECTS ACCESS REPORT, METHOD STATEMENT AND HEALTH AND SAFETY GUIDELINES.

02	YORK STREET ENTRANCE DETAIL	02/06/25	KM
01	YORK STREET ENTRANCE DETAIL	26/03/25	KM
00	YORK STREET ENTRANCE DETAIL	25/02/25	KM
Rev	Description	Date	Drm

SCHEME DESIGN

Status of drawing

**MISTRY
LIGHTING**



0774715 3333
WWW.MISTRYLIGHTING.COM
KRISHNA@MISTRYLIGHTING.COM

Project CUT & CRAFT, MANCHESTER

Drawing Title FACADE LIGHTING - YORK ST ENTRANCE

Drawn By	Date	Scale	Drawing No.
KM	02/06/2025	VARIES	ML_CCM_F02

Drawing Order:	Revision	Client	Stage
02 of 03	REV 02	CUT&CRAFT	SCHEME DESIGN