




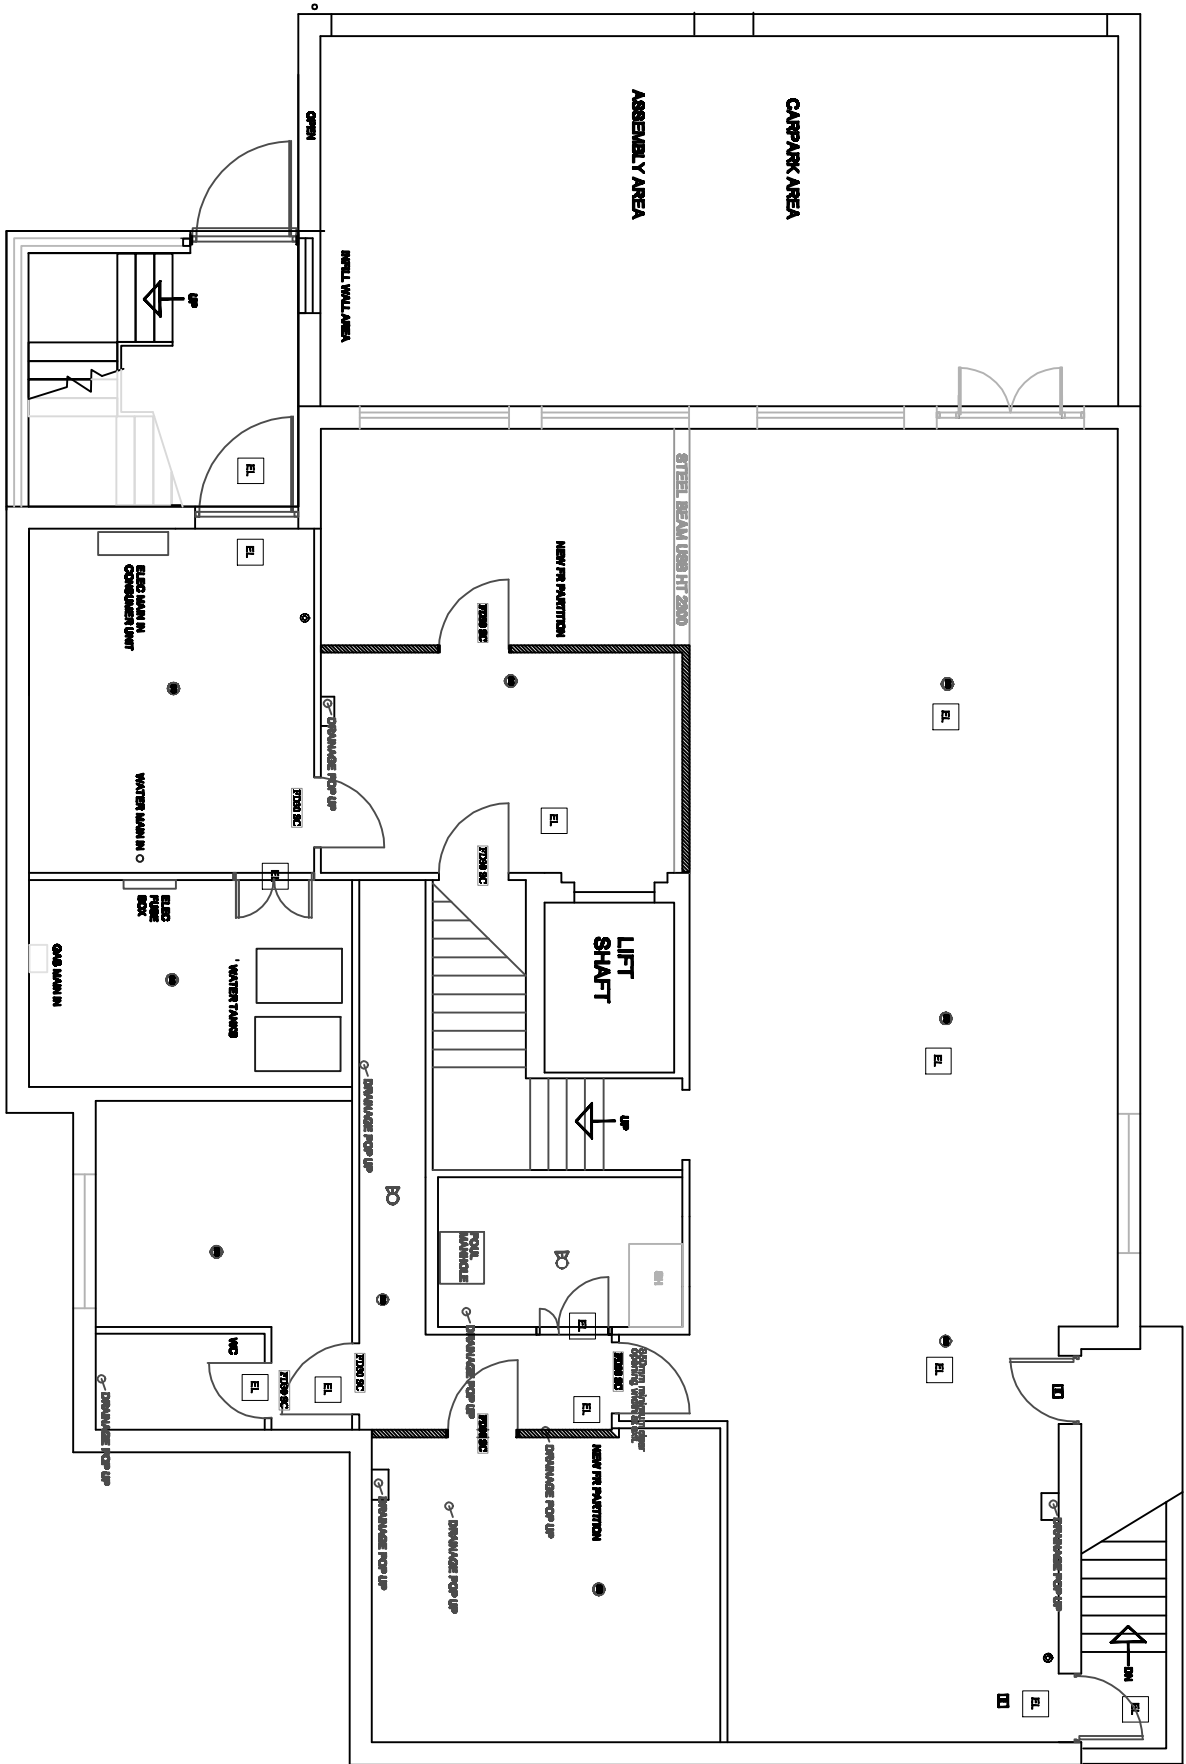

GROUND FLOOR

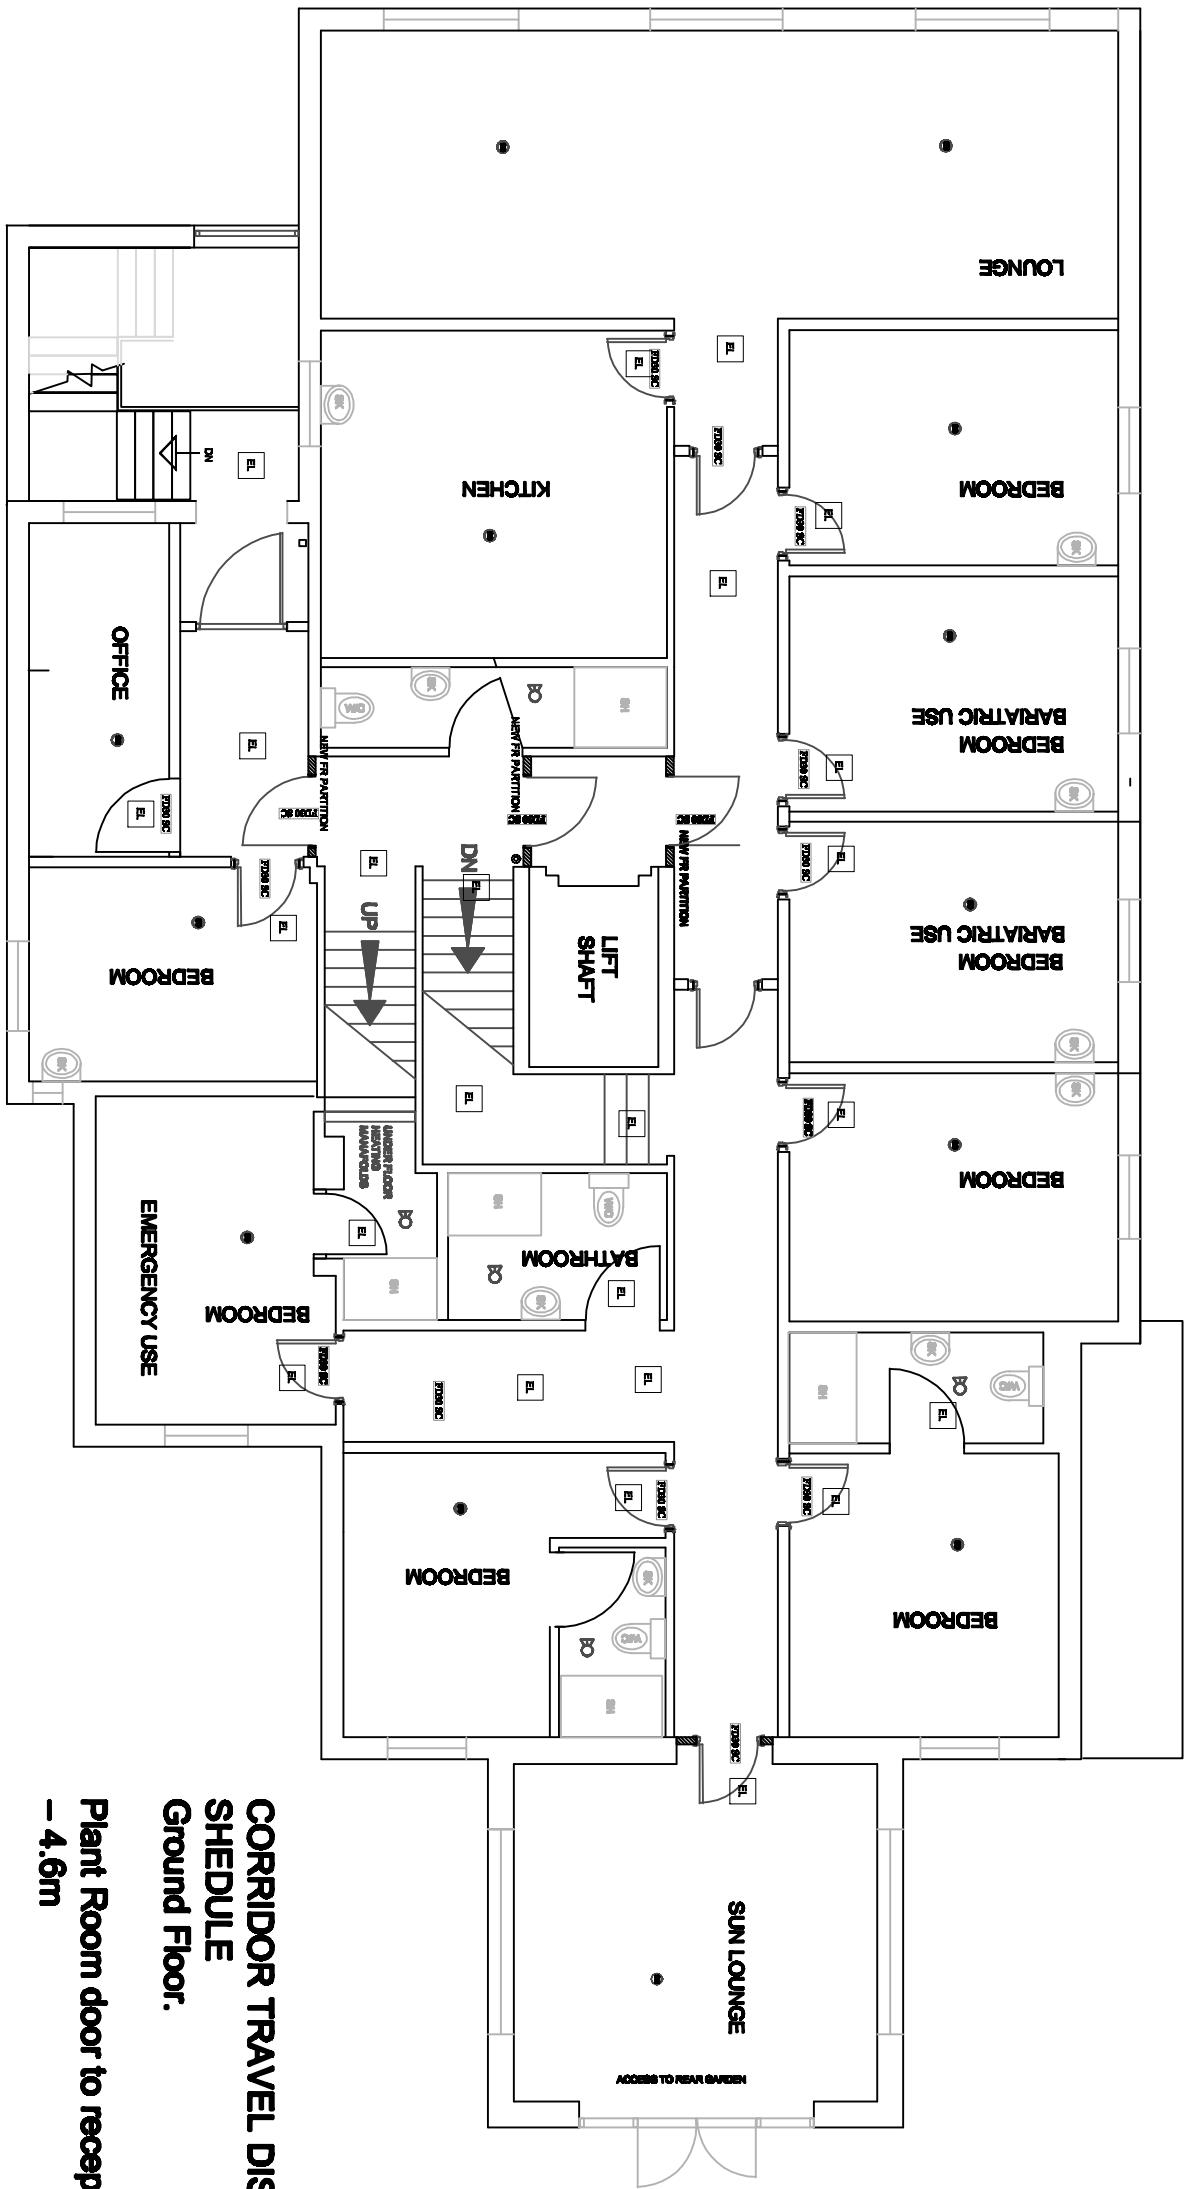

FIRST FLOOR PLAN

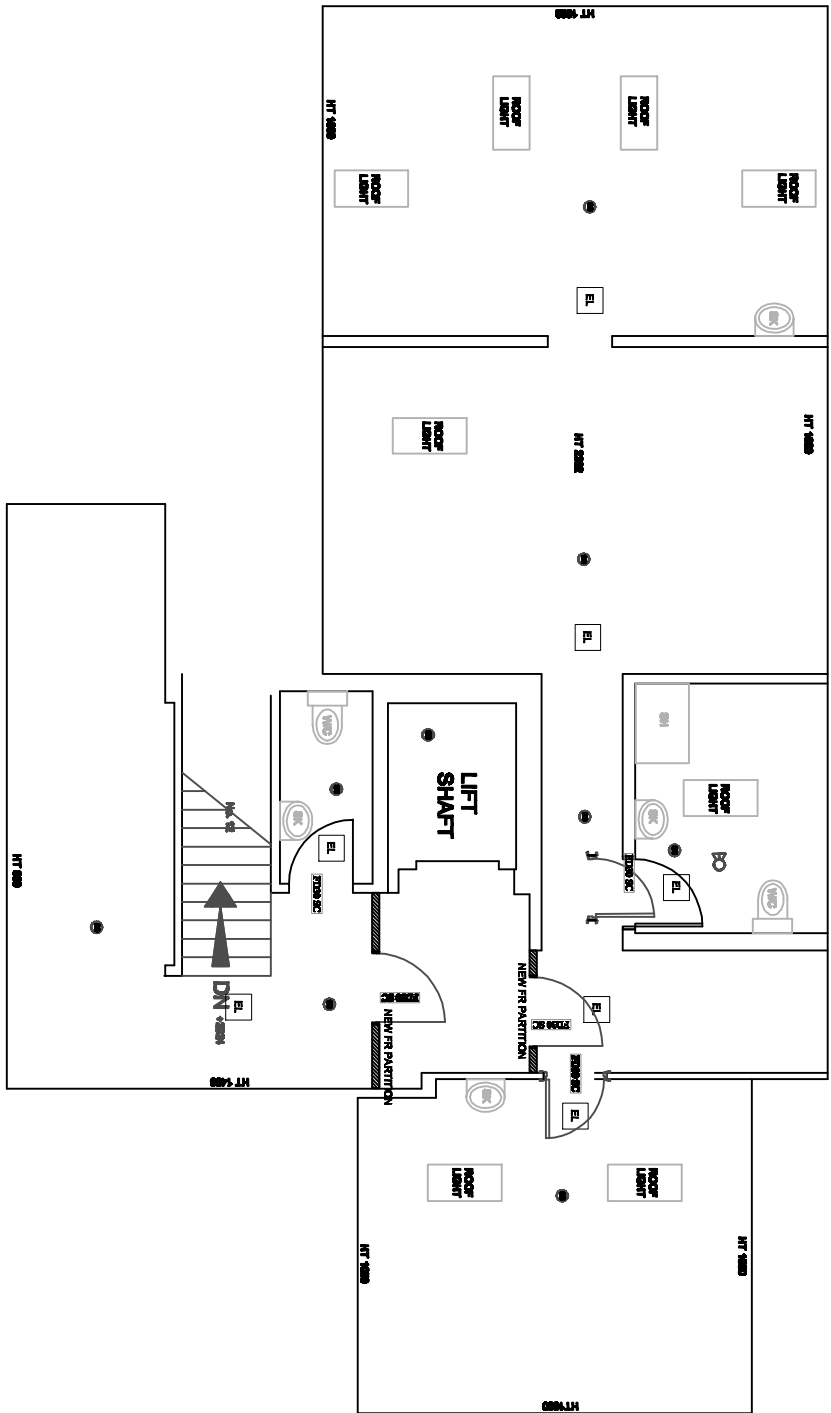

SECOND FLOOR

## Key to Fire Symbols

|  |                                                                                  |
|--|----------------------------------------------------------------------------------|
|  | general fire action notice                                                       |
|  | sign to access side "Fire Door Keep Locked Shut"                                 |
|  | sign to access side "Fire Door - Keep Shut"                                      |
|  | Fire Exit Sign                                                                   |
|  | 30 minute fire resistant door and frame                                          |
|  | 60 minute fire resistant door and frame                                          |
|  | Smoke seal                                                                       |
|  | Self Closing Device                                                              |
|  | Vision Panel                                                                     |
|  | Panic Bar                                                                        |
|  | Fire Blanket                                                                     |
|  | Fire Extinguisher Dry Powder                                                     |
|  | Fire Alarm Panel                                                                 |
|  | Call Point                                                                       |
|  | Emergency lighting                                                               |
|  | Smoke Detector                                                                   |
|  | Heat Detector                                                                    |
|  | Fire alarm sounder                                                               |
|  | existing emergency lighting extended to these areas in accordance with BS 5226-1 |

All new internal soil and vent pipes to be fitted with minimum 60 min. fire rated Quafire or equivalent approved intumescent pipe collar where they penetrate all floor levels.  
Fire Alarm System to be extended to cover all new areas and designed in accordance with BS. 5839.

All Fire Safety and Exit Signs to be in accordance with B.S. 5499.  
Portable fire extinguishers and blankets to be in accordance with B.S. 5306-3 : 2009

- Utility Room to Car Port final exit – 19m
- First Floor.
- Lounge to lift – 5.8m
- Lounge to bed 4 – 7.2m
- Sun Lounge to lift – 12.2m
- Bed 4 to Sun Lounge – 8.4m
- Bed 4 to lift – 5.6m
- Bed 8 to lift – 4m
- Bed 8 to new external staircase – 5m
- Bed 8 to Bed 3 – 6.6m
- Bed 7 to lift – 13m
- Bed 7 to Sun Lounge – 11.2m
- Second Floor.
- Bed 10 to lift – 9.9m
- Bed 9 to lift – 2.8m
- Lift to stairs – 1.5m

| REVISIONS |          |       |         |
|-----------|----------|-------|---------|
| SCALE     | DATE     | DRAWN | CHECKED |
| 1/100     | NOV 2024 |       |         |

CLIENT

VESTACARE Ltd

TITLE

PROPOSED RESTBITE / DAYCARE FACILITY  
AS BUILT FLOORPLAN SURVEY  
60 VICTORIA AVENUE EAST  
BLACKLEY, MANCHESTER M9 6HB

FIRE RISK ASSESSMENT