


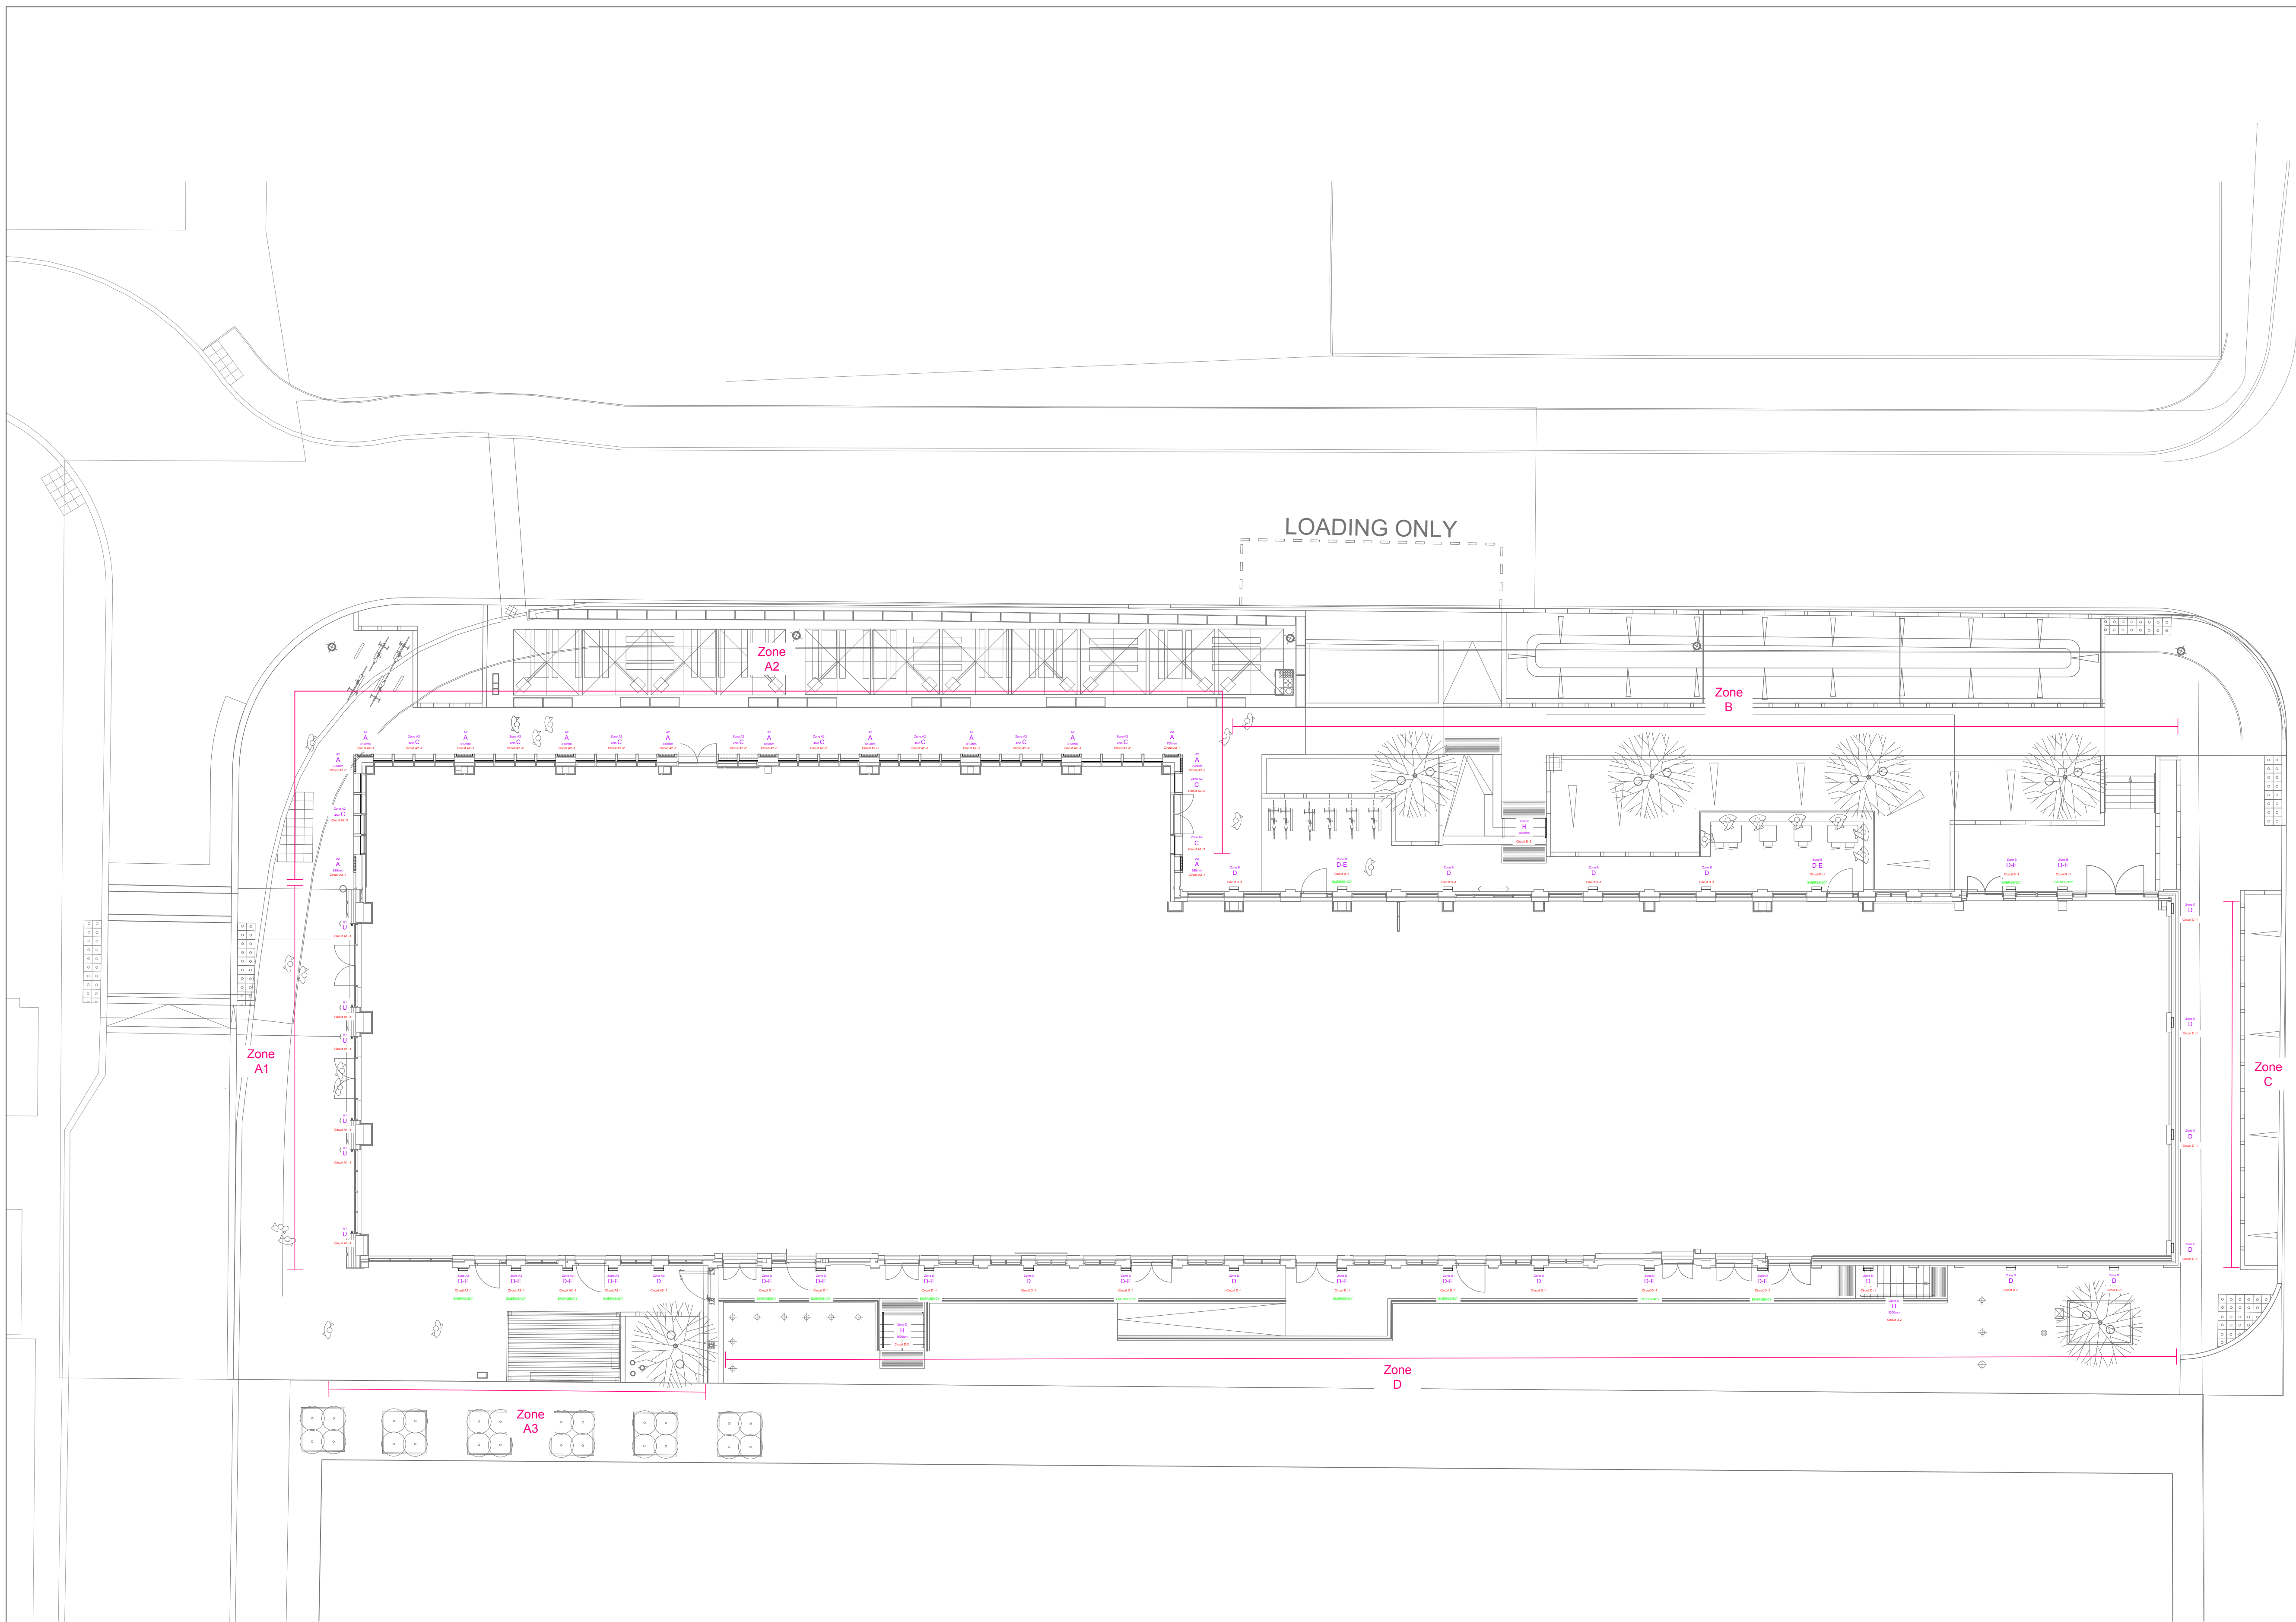

- NOTES
1. DO NOT SCALE FROM THIS DRAWING
 2. ALL DIMENSIONS ARE STATED IN MILLIMETERS
 3. THIS DRAWING IS DESIGN INTENT ONLY, AND SHALL NOT BE USED FOR CONSTRUCTION PURPOSES
 4. THIS DRAWING SHALL BE READ IN COORDINATION WITH THE LUMINAIRE SCHEDULE
 5. THIS DRAWING SHALL BE READ IN CONJUNCTION WITH THE LIGHTING SPECIFICATION DOCUMENT
 6. CONSTRUCTION DRAWINGS SHALL BE PROVIDED BY OTHERS
 7. COORDINATION OF THE M&E SERVICES ONSITE SHALL BE UNDERTAKEN BY THE MAIN CONTRACTOR
 8. THE MAIN CONTRACTOR SHALL ENSURE THE LIGHTING GUIDANCE AND BRITISH STANDARDS
 9. THE MAIN CONTRACTOR SHALL DESIGN AND INSTALL EMERGENCY LIGHTING AND EXIT SIGNAGE IN LINE WITH BS EN 5286 + BS EN 1838
 10. THE MAIN CONTRACTOR SHALL UNDERTAKE A FEASIBILITY STUDY TO ASSESS THE PROPOSED FITTING LOCATIONS, LUMINAIRE SIZES, FIXING DETAILS AND CABLING ROUTES PRIOR TO ORDERING THE LIGHTING EQUIPMENT. A REPORT SHALL BE ISSUED FROM THE MAIN CONTRACTOR CONFIRMING THE STUDY RESULTS AND RAISING ANY ISSUES THAT MIGHT ARISE FROM THE STUDY
 11. FINAL LUMINAIRE HEIGHTS FOR WALL MOUNTED FITTINGS AND PENDANTS FITTINGS SHALL BE AGREED BY THE ARCHITECT AND INTERIOR DESIGNER PRIOR TO INSTALLATION

AREA HIGHLIGHTED - LIGHTING DESIGN BY OTHERS

HIGH LEVEL LIGHTING

LOW / MID LEVEL LIGHTING

5 AMP 5 AMP SOCKET FOR LIGHTING CONTROL SYSTEM - POSITIONS TO BE COORDINATED WITH THE INTERIOR DESIGNER AND JOINERY PACKAGE

REMOTE LED DRIVERS

THE MAIN CONTRACTOR SHALL ENSURE ALL REMOTE LED DRIVERS ARE CONCEALED FROM DIRECT VIEW IN ACCESSIBLE POSITIONS FOR MAINTENANCE PURPOSES.

LINEAR LED LIGHTING

LED POSITION WITHIN COFFERS TO BE AGREED ONSITE PRIOR TO FINAL INSTALLATION

THE MAIN CONTRACTOR SHALL CONFIRM FINAL LED LENGTHS FOR ALL LINEAR LED PRODUCTS WHICH SHALL COORDINATED WITH ARCHITECTURAL DETAILS AND JOINERY ELEMENTS

D	16.01.25	WALL LIGHTS TO EMERGENCY	SA
C	22.02.24	REVISION FOR STAGE 4	SA
B	28.11.23	PROJECT MEETING REVISION	SA
A	28.11.23	PROJECT MEETING REVISION	SA
-	13.11.23	DRAFT INITIAL ISSUE	SA

REV	DATE	ISSUE	
Project		HOUSE OF SOCIAL, MANCHESTER	
Client		VITA	
Designer		TIM GROOM / PLANET.IE	
Drawing		EXTERIOR LIGHTING LAYOUT	
Drawing No.	201922-HOS-EXT LIGHTING-1001	Scale:1:150 @ A1	