


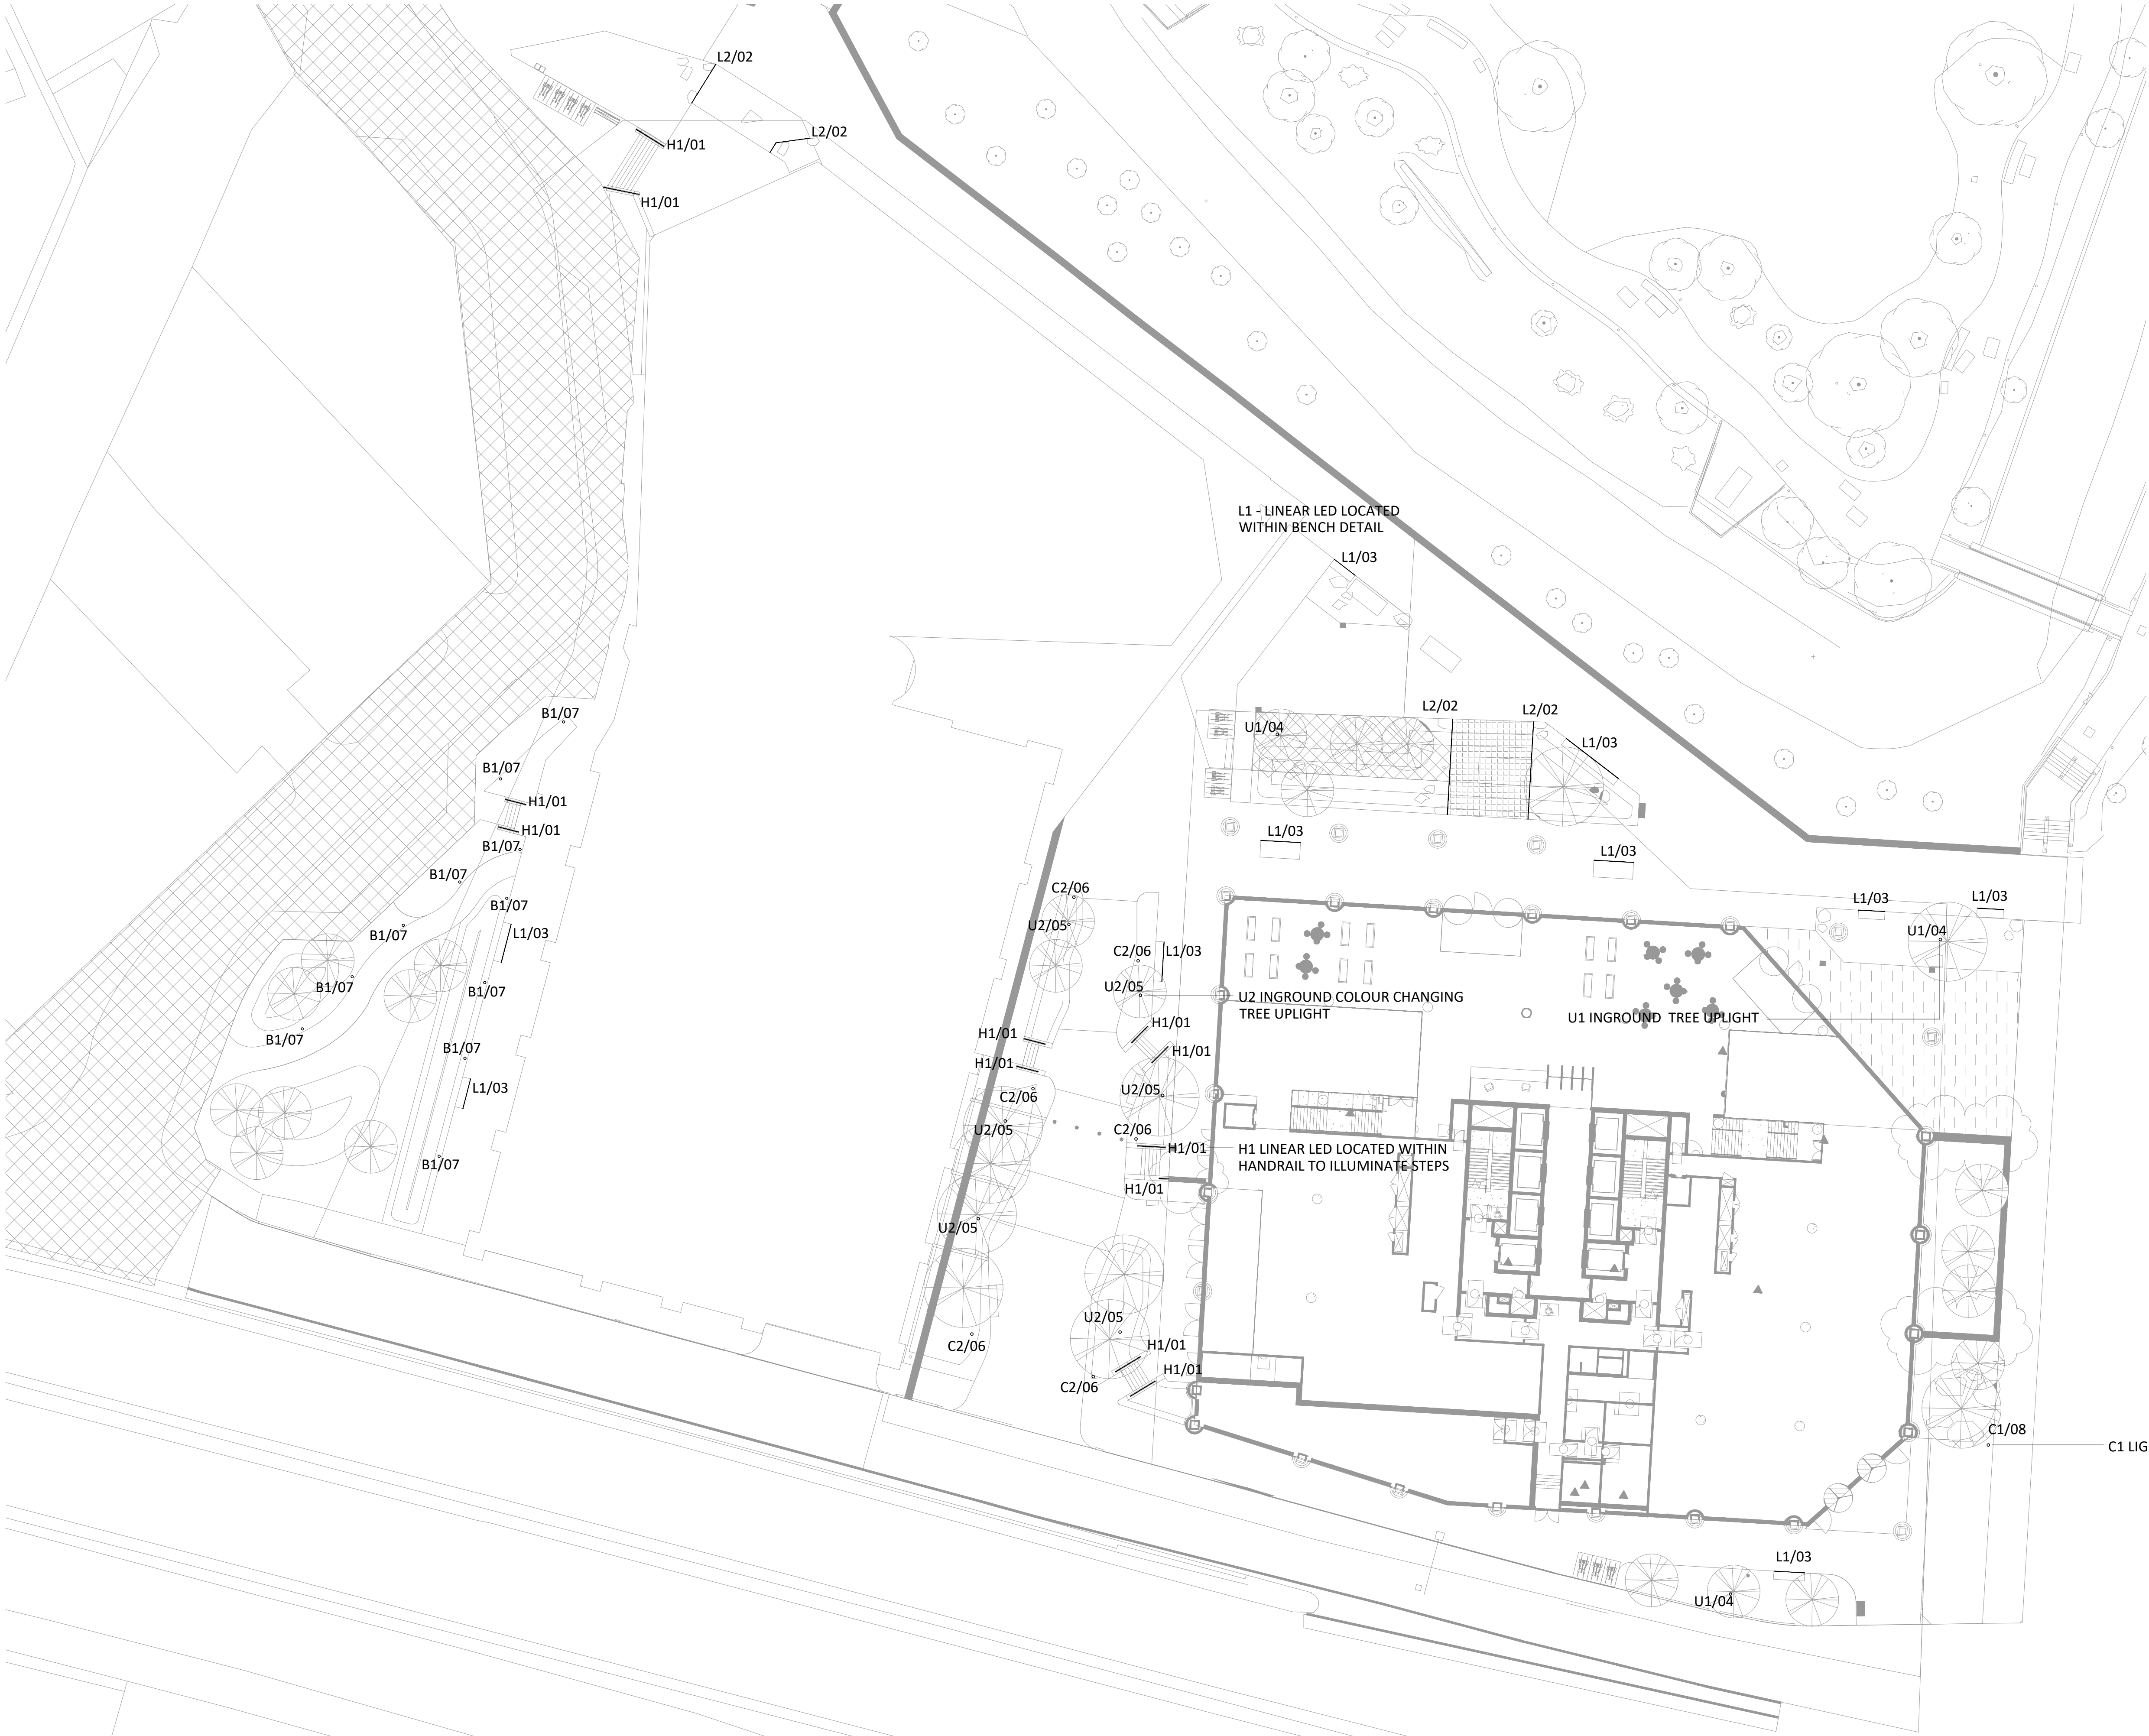

C1 LIGHTING COLUMN

Note
All final dimensions, fixings and details should be taken from architects co-ordinated drawings or where applicable fabricators / manufacturers drawings.

Luminaire Key
B1 - 12.3W LED LIGHTING BOLLARD
C1 - IP66 28W 5M LIGHTING COLUMN
C2 - IP66 2x35W 5M LIGHTING COLUMN
U1 - IP67 18W LED INGROUND UPLIGHTER
U2 - IP67 23W LED INGROUND UPLIGHTER
H1 - IP66 1.5W HANDRAIL LIGHTING
L1 - IP67 7W/M LED LINEAR
L2 - IP67 15W/M LED LINEAR

ADDITIONAL NOTES.
FOR FULL DETAILED SPECIFICATION REFER TO Studio FRACTAL DOCUMENT
Luminaire references refer to luminaire type and control channel (not electrical circuits)

D10 / 01
LUMINAIRE REF CONTROL CHANNEL

02	STAGE 4 ISSUE	02-08-24
01	ORIGINAL ISSUE	23-11-23
Rev	Description	Date

All dimensions are in millimetres unless otherwise stated. This drawing is not to be scaled. Use figured dimensions only.

Drawing Status
STAGE 4 / ER ISSUE

STUDIOFRACTAL
Tel. +44 (0)1293 730121. Email: info@studiofractal.co.uk

Project
MAYFIELD MEDLOCK LIMITED

Drawing Title
PUBLIC REALM PHASE 1A
LIGHTING LAYOUT

© All rights reserved. No part of this design may be reproduced without the prior agreement of StudioFractal Ltd.

Drawn By	Drawn Date	Checked By	Checked Date
EF	02/08/24	CS	02/08/24

Approved By	Approved Date	Scale
CS	02/08/24	1/250@A1

Drawing No.	Rev
0198_MAY-SFL-SWI-ZZZZ-DR-Y-000001	02

NOT FOR CONSTRUCTION