


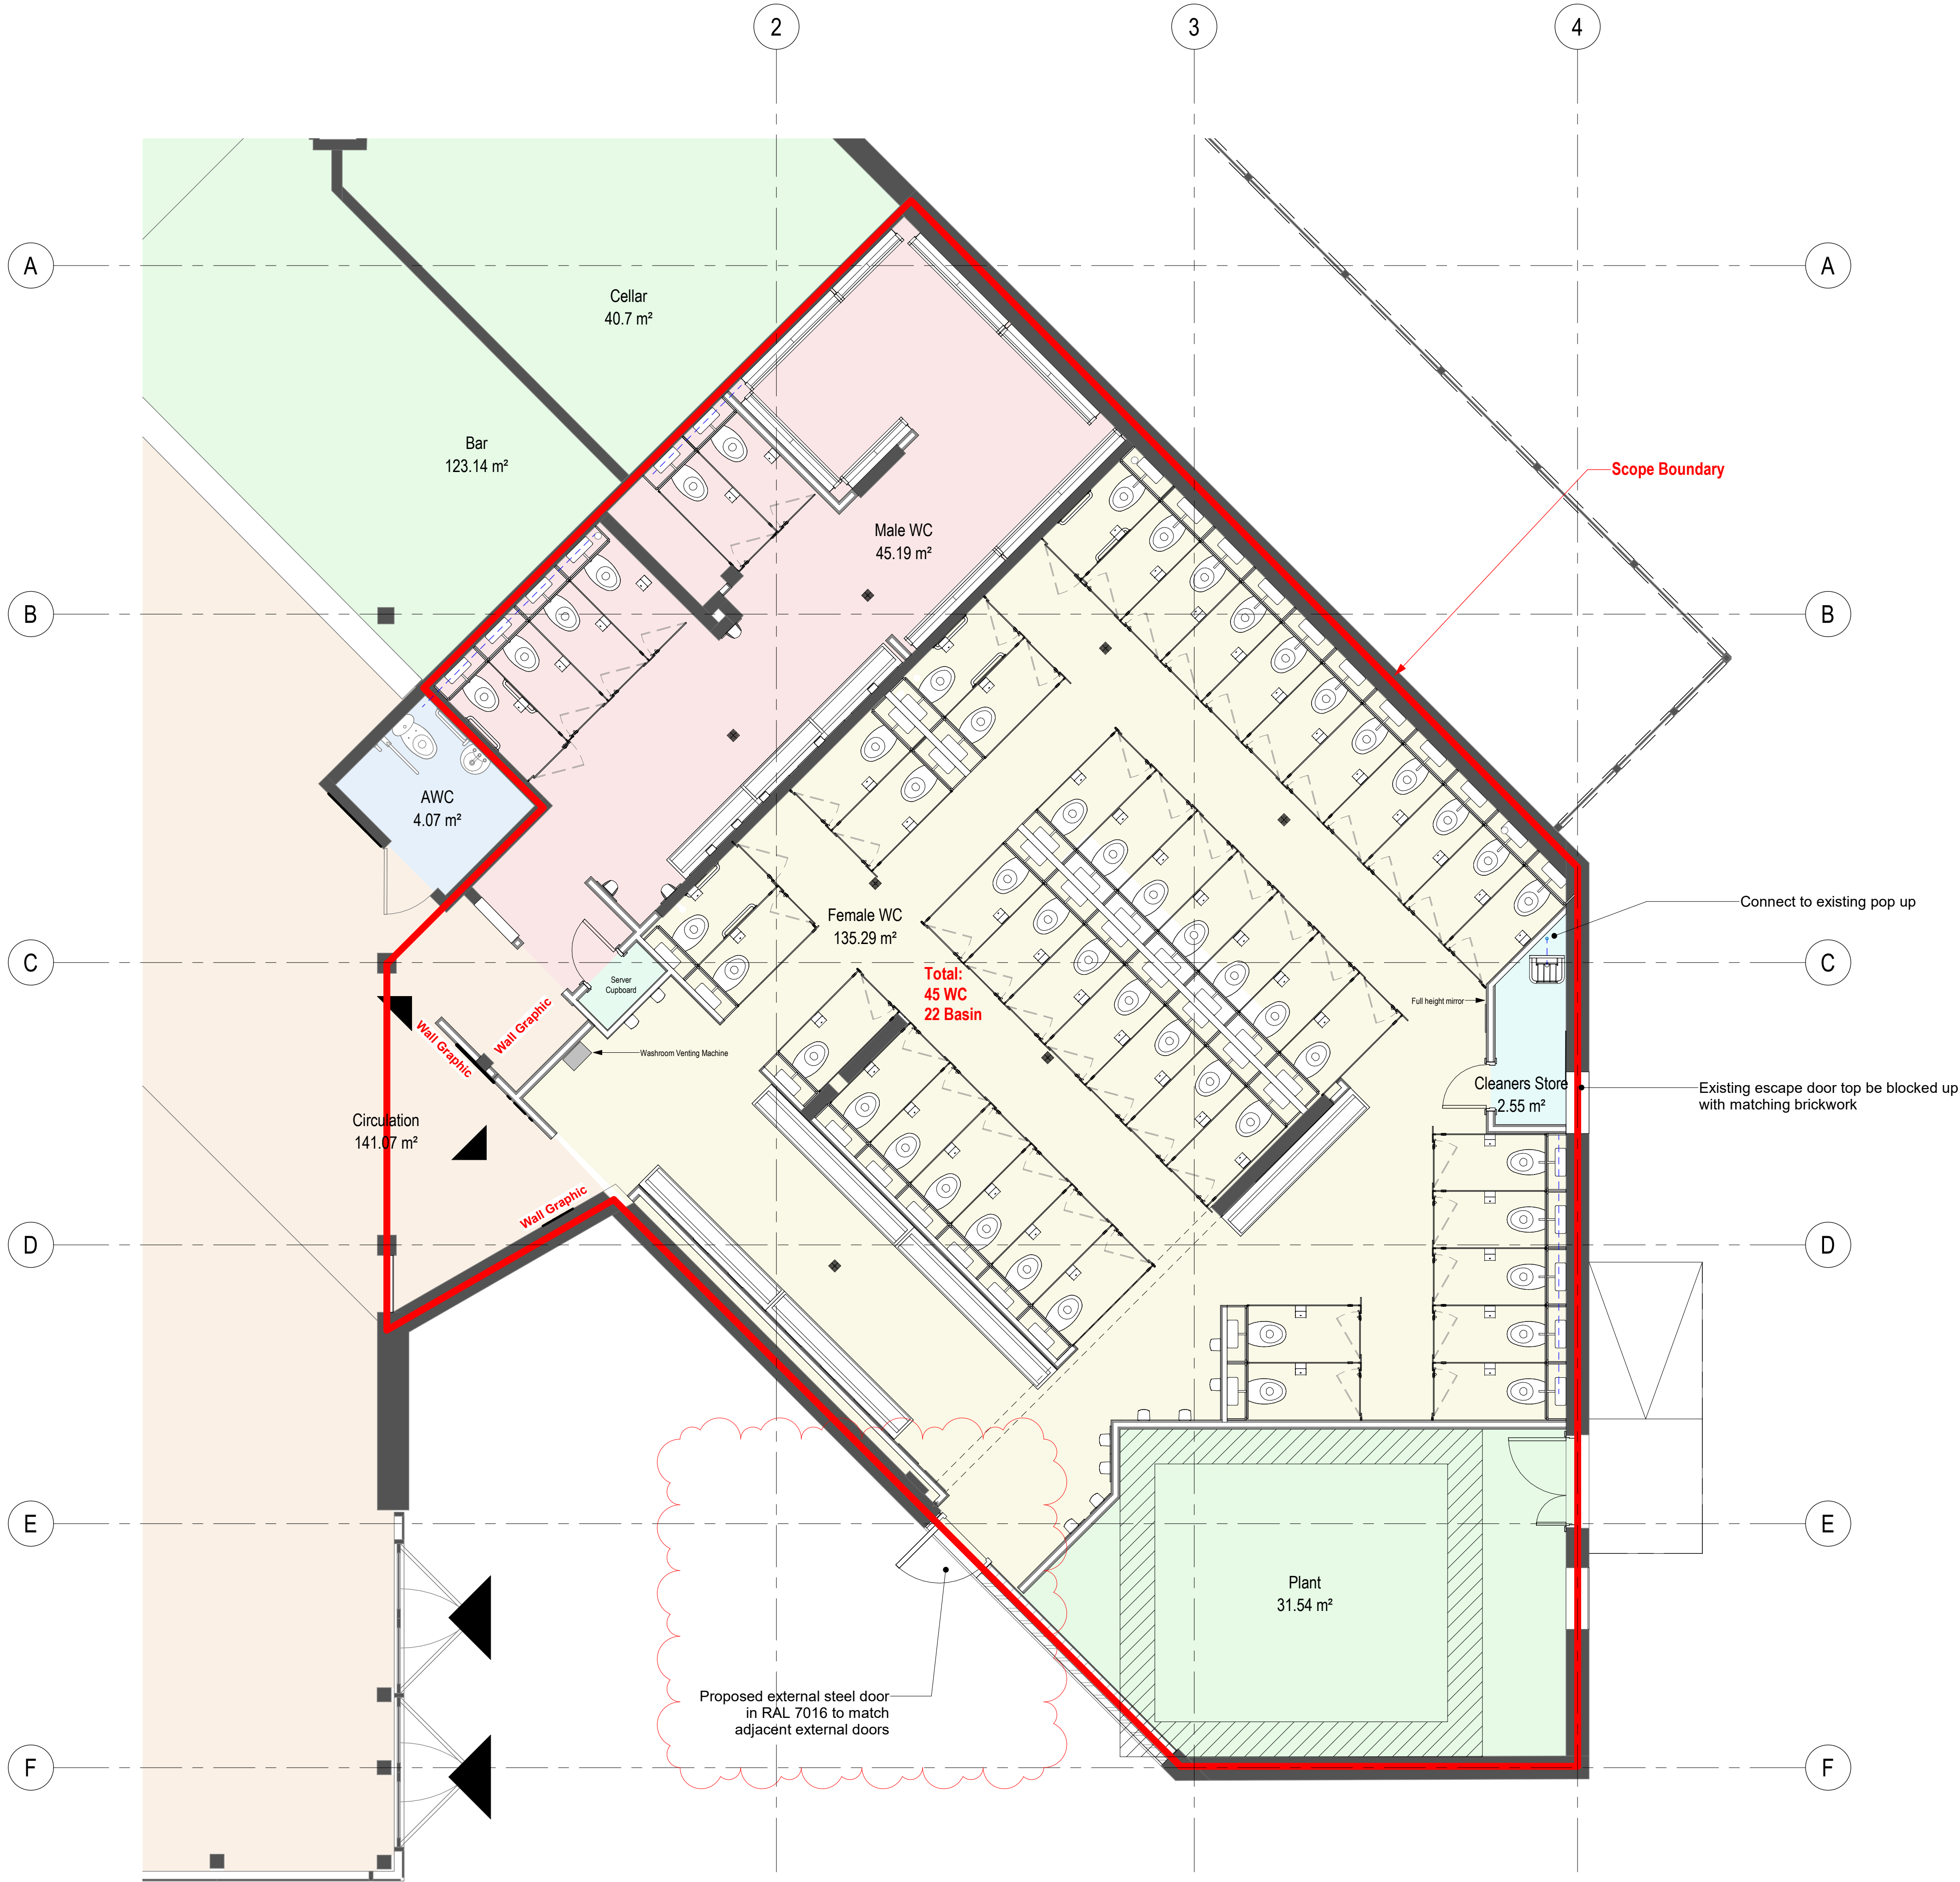

Level GF Proposed

1 : 50 @ A1

P15	Annotation added for NMA	30/06/25	JP	OC
P14	Issue for Non Material Amendment	06/06/25	JP	OC
P13	Handdryers relocated following client feedback	15/01/25	JP	OC
P12	Cleaners store made larger	20/12/24	JP	OC
P11	External ramp shown for planning	25/10/24	JP	OC
P10	Issue for Construction	26/07/24	JP	OC
P09	Server Cupboard location altered for phasing	18/07/24	JP	OC
P08	Server Cupboard Relocation	02/07/24	JP	OC
P07	Issued for tender	19/06/24	JP	OC
P06	Issue for initial tender	17/06/24	JP	OC
P05	Layout Updated to align with structural walls	12/06/24	JP	-
P04	Scope Boundary Added	24/05/24	JP	OC
P03	WC layout altered	13/05/24	JP	OC
P02	Plant Room Added	03/05/24	JP	OC
P01	Updated Layout Issue	02/08/2023	JP	OC

Revision	Description	Date	Drawn	Checked
----------	-------------	------	-------	---------

Halliday Meecham Architects Limited

111 Piccadilly Manchester M1 2HY
+44 (0)161 661 5566

4 Devonshire Street London W1W 5DT
+44 (0)203 440 5175

hma@hallidaymeecham.com
www.hallidaymeecham.com



Client:	University of Manchester
Project:	The Academy WC Refurb
Phase/ Location:	The University of Manchester, Oxford Rd, Manchester, M13 9PL
Drawing:	Proposed Ground Floor Plan

Scale @ A1	Scale @ A3	Date:	Drawn:	Checked:	Job No.	Drawing No.
1:50	1:100	08/03/23	JP	OC	5630	00201

 Drawing Ref.	Scale  1:50	Stage / Suitability: Information	Status:
			Revision

5630-HMA-MA-00-DR-A-00201

P15