


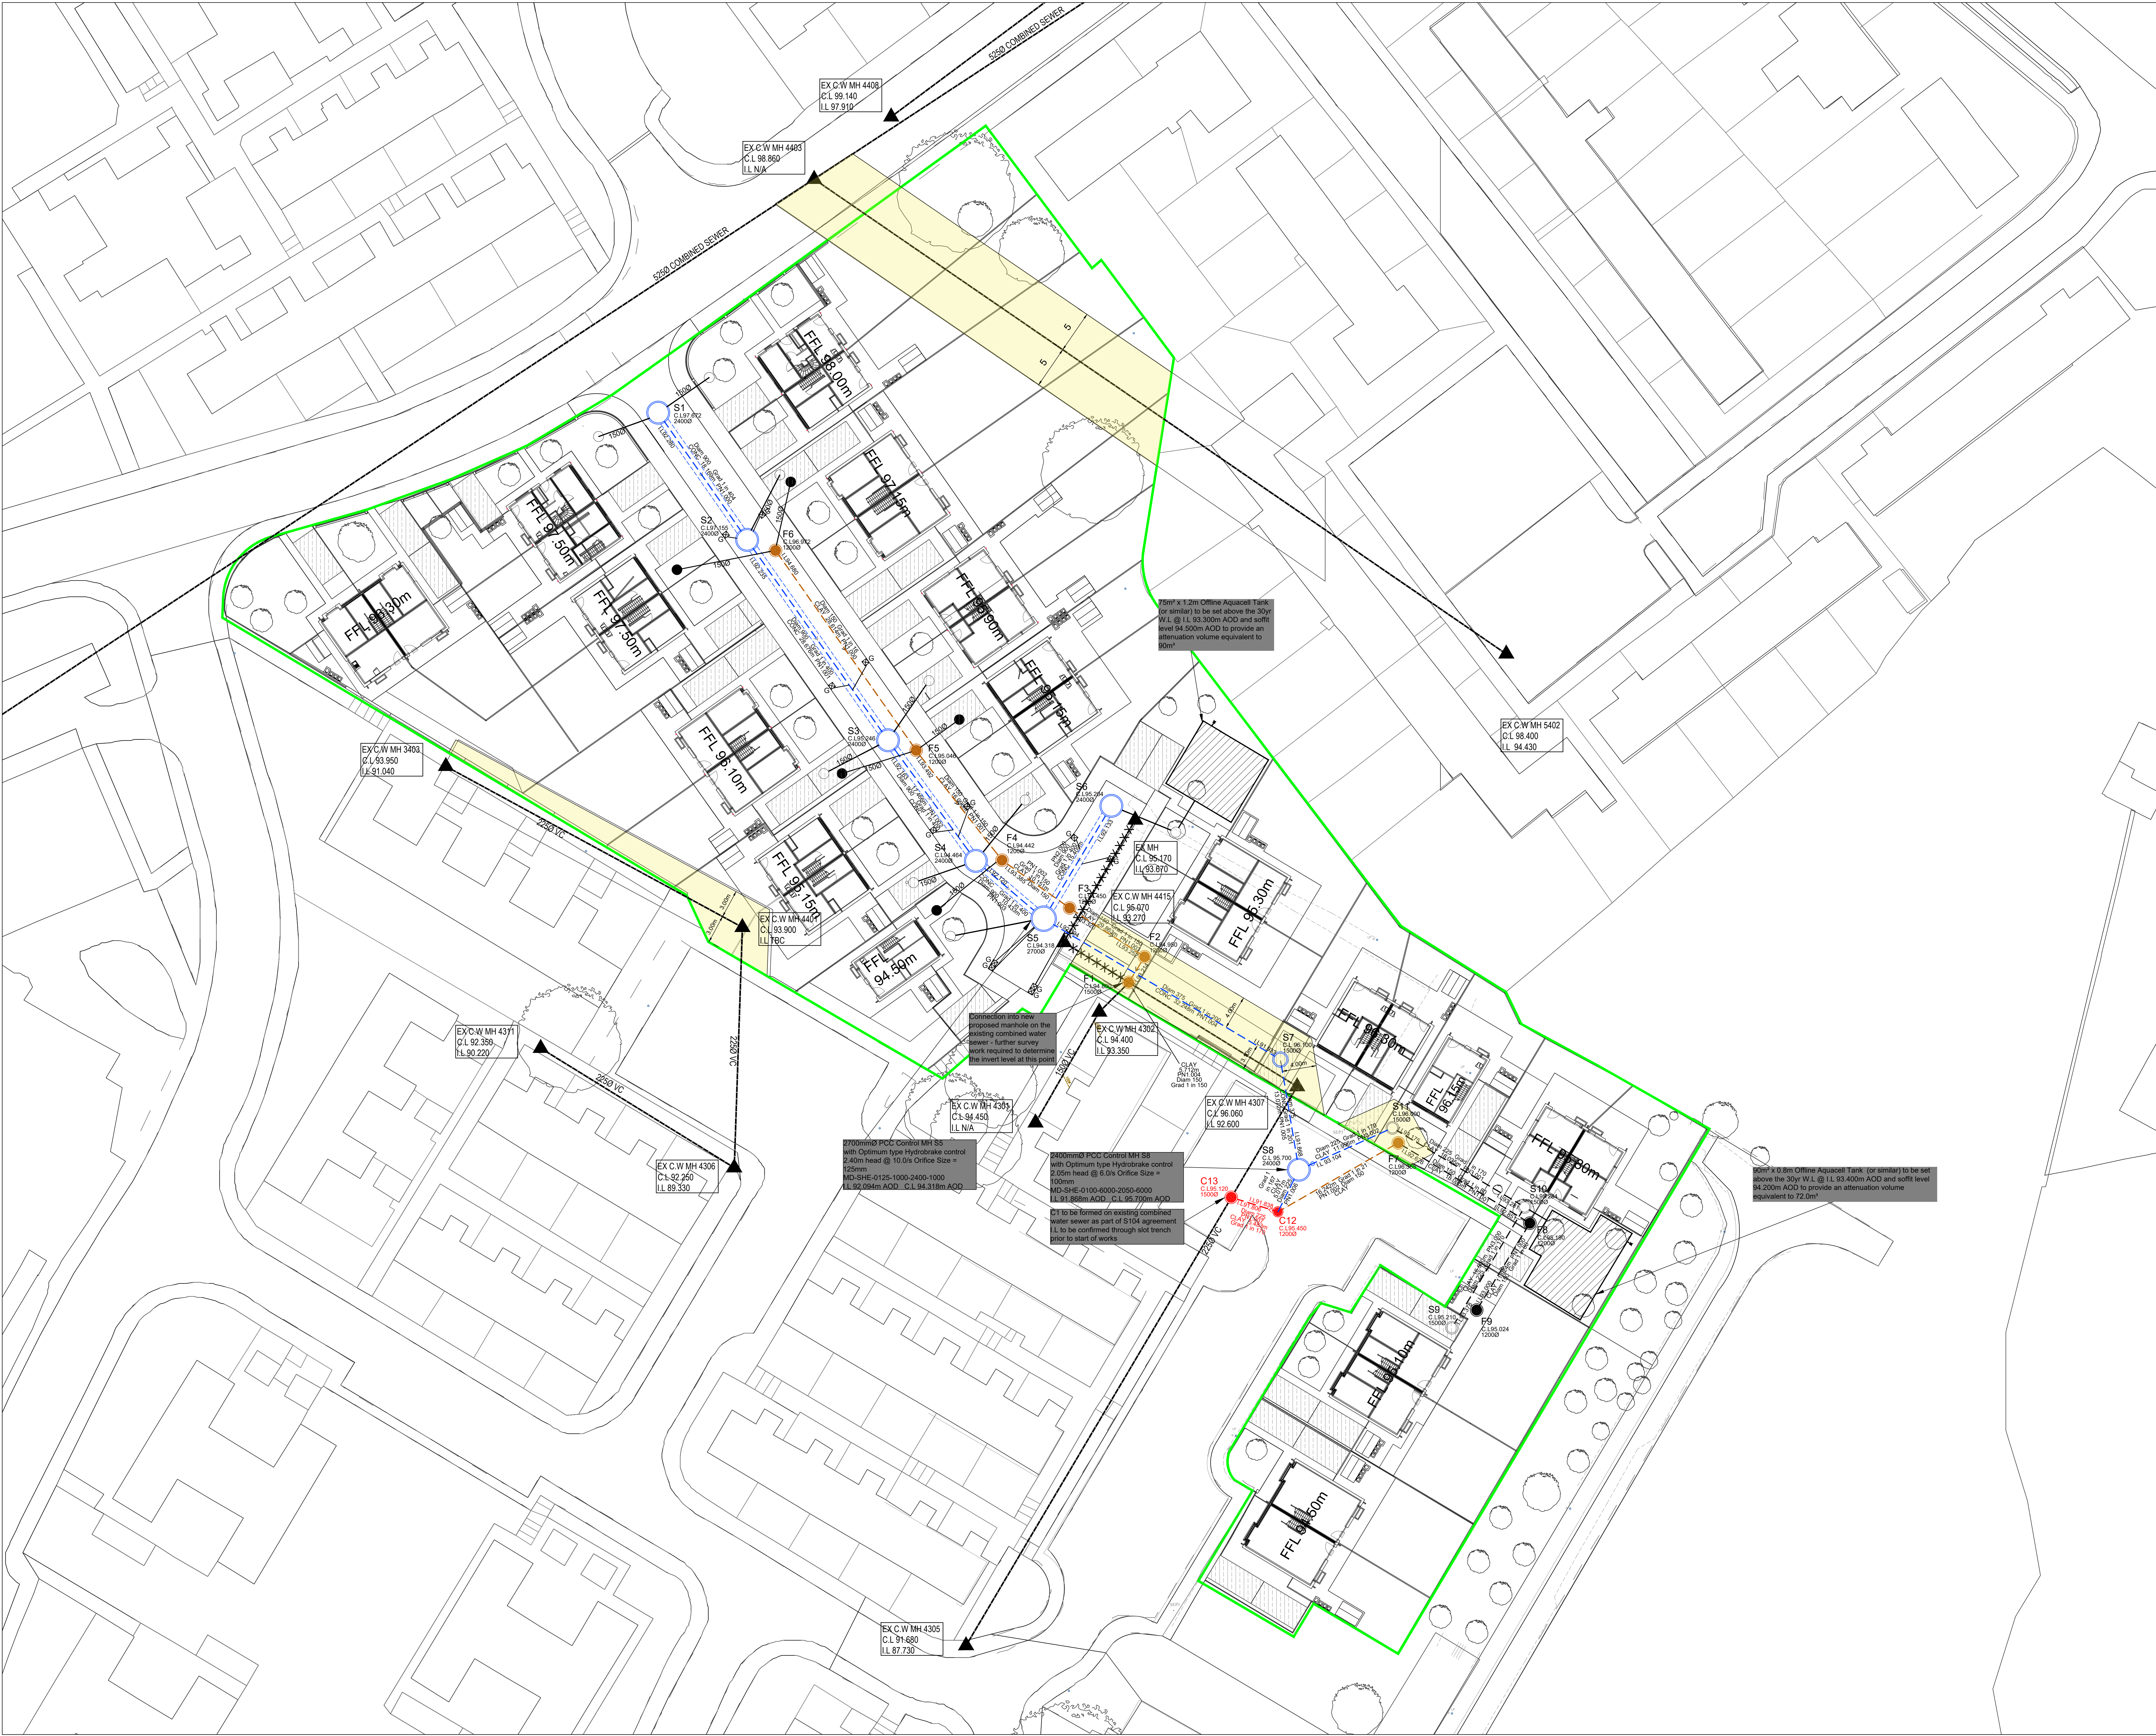

- GENERAL NOTES**
- SETTING OUT SHALL BE UNDERTAKEN USING ONLY THE INFORMATION GIVEN. DISTANCES SHOULD NOT BE SCALED FROM THIS DRAWING.
 - ALL SEWERS SHALL BE CONSTRUCTED IN ACCORDANCE WITH DCS AND UNITED UTILITIES DETAILS & GUIDELINES.
 - THE MINIMUM GRAVITY PIPE DIAMETER UNDER ACCEPTABLE HIGHWAYS SHALL BE 150mm.
 - IT IS THE RESPONSIBILITY OF THE CONTRACTOR TO VERIFY ALL INFORMATION GIVEN WITH REGARDS TO EXISTING SERVICES AND DRAINAGE CONNECTIONS ETC. PRIOR TO COMMENCING THE WORKS. THE NOTES SHALL INCLUDE FOR HAND DIG AROUND SERVICES WHERE NECESSARY. THE CONTRACTOR SHALL ADHERE TO THE DCS REGULATIONS AT ALL TIMES.
 - THE OUTSIDES OF ALL SEWERS SHALL BE A MINIMUM OF 1m FROM WHERE LINES AND THE OUTSIDE OF MANHOLES SHALL BE A MINIMUM OF 1.5m FROM ADRY LINES.
 - EXISTING FLOWS IN WATERCOURSES, SEWERS AND LAND DRAINS SHALL BE MAINTAINED AT ALL TIMES. ONLY TRAINED PERSONNEL SHALL BE PERMITTED TO ENTER CONFINED SPACES.
 - ALL MATERIALS TO BEAR THE RELEVANT B.E. KITEMARK AND COMPLY FULLY WITH THE SPECIFICATIONS. ALL CONCRETE & CONCRETE PRODUCTS MUST USE SULPHATE RESISTANT CEMENT UNLESS THE SITE INVESTIGATION REPORT PROVIDES THAT SULPHATE ATTACK FROM SOILS AND GROUNDWATER WILL NOT OCCUR TO WITHSTAND A CLASS.
 - ALL OPENING NOTICES ETC. AS REQUIRED UNDER HIGHWAYS ACTS ETC. ARE TO BE OBTAINED PRIOR TO COMMENCEMENT OF WORKS. ALL WORKS ARE TO BE INSPECTED BY I.A. WARD OR THE NETWORK OPERATOR AS APPLICABLE.
 - WHERE 'ULTRA RIF' UPVC PIPES OR SIMILAR APPROVED ARE USED IN ADAPTABLE DRAINAGE THEY SHALL STILL BE HANDLED AND LAD IN ACCORDANCE WITH THE SPECIFICATION AND GUIDANCE ISSUED BY THE HIGH PERFORMANCE PIPE ASSOCIATION.
 - A CLASS 5 SDO AND SURROUND MUST BE USED FOR SUCH PIPES. TRENCH BACKFILL IN HIGHWAYS TO WITHIN 50m OF HIGHWAY SHALL AS DIRECTED BY THE HIGHWAY AUTHORITY BE A SUITABLE GRANULAR MATERIAL. ALL IN ACCORDANCE WITH SEWERS FOR ADOPTION. CL 4.4 TO 4.6. ALL LEVELS SHALL NOT BE INFERRED WITHOUT REFERENCE TO THE DRAWING FOR GUIDANCE.
 - DOMESTIC DRAINAGE SHALL BE TO BUILDING REGULATIONS APPROVED DOCUMENT H 10MM UP V.C. PIPES LAID TO THE FOLLOWING MINIMUM FALLS UNLESS OTHERWISE SHOWN:
POUL 1 IN 80
HEAD RUN 1 IN 80
ELSEWHERE 1 IN 100
 - FOR PROPOSED INSPECTION CHAMBERS TO BE PROVIDED TO ALL PRIVATE DRAINAGE LINES. 1.1m DEEP. WHERE PRIVATE DRAINAGE LINES ARE DEEPER THAN 1.1m, REDUCED ACCESS CHAMBERS TO BE PROVIDED.
 - WHENEVER PLASTIC PIPES ARE TO BE USED FOR THE CONSTRUCTION OF ADAPTABLE DRAINAGE, STRUCTURED WALL PLASTIC PIPES MUST BE USED WHICH MUST COMPLY WITH BS EN 12201 AND BS 4570.

- LEGEND**
- PROPOSED SURFACE WATER SEWER MANHOLE - TO BE ADOPTED UNDER A S104 AGREEMENT SUBJECT TO TECHNICAL APPROVAL
 - PROPOSED FOUW WATER SEWER MANHOLE - TO BE ADOPTED UNDER A S104 AGREEMENT SUBJECT TO TECHNICAL APPROVAL
 - PROPOSED COMBINED WATER SEWER MANHOLE - TO BE ADOPTED UNDER A S104 AGREEMENT SUBJECT TO TECHNICAL APPROVAL
 - EXISTING COMBINED WATER MANHOLE
 - PROPOSED FOUW 1200mm PCC DRAG OUT MH (TO BE AGREED WITH LU FIELD INSPECTOR)
 - PROPOSED SURFACE WATER 1200mm PCC DRAG OUT MH (TO BE AGREED WITH LU FIELD INSPECTOR)
 - PROPOSED FOUW WATER SEWER
 - PROPOSED SURFACE WATER SEWER
 - HIGHWAY GULLY
 - FINISHED FLOOR LEVEL
 - ADO CHANNEL (OR SIMILAR)
 - POROUS PAVING - FOR WATER QUALITY ONLY
 - EXISTING SEWER EASEMENT
 - RED LINE BOUNDARY

NO	06.03.2025	AMENDED TO SUIT LU COMMENTS	JPR	JCM	JCM
REV	14.02.2025	AMENDED FOLLOWING MEETING WITH LU	JPR	JCM	JCM
REV	17.01.2025	PRELIMINARY ISSUE	JPR	JCM	JCM
REV	DATE	DESCRIPTION	BY	CHK	APP

DRAWING STATUS:		PRELIMINARY							
CLIENT:		GUINNESS PARTNERSHIPS							
ARCHITECT:		JOHN MCCALL ARCHITECTS							
PROJECT:		WHITEMOSS ROAD MANCHESTER							
TITLE:		OUTLINE DRAINAGE LAYOUT MASTERPLAN							
STATUS:	PROJECT No	PROJECT	ORIGINATOR	VOLU	LEVEL	TYPE	ROLE	DRAWING No	REV
S2	223-009	WMR - AJP - ZZ - 00 - DR - C - 1002	P03						
SCALE @ A1	DESIGNED	DRAWN	CHECKED	APPROVED			DATE		
1:250	JPR	JPR	JCM	JCM			JAN 2025		