


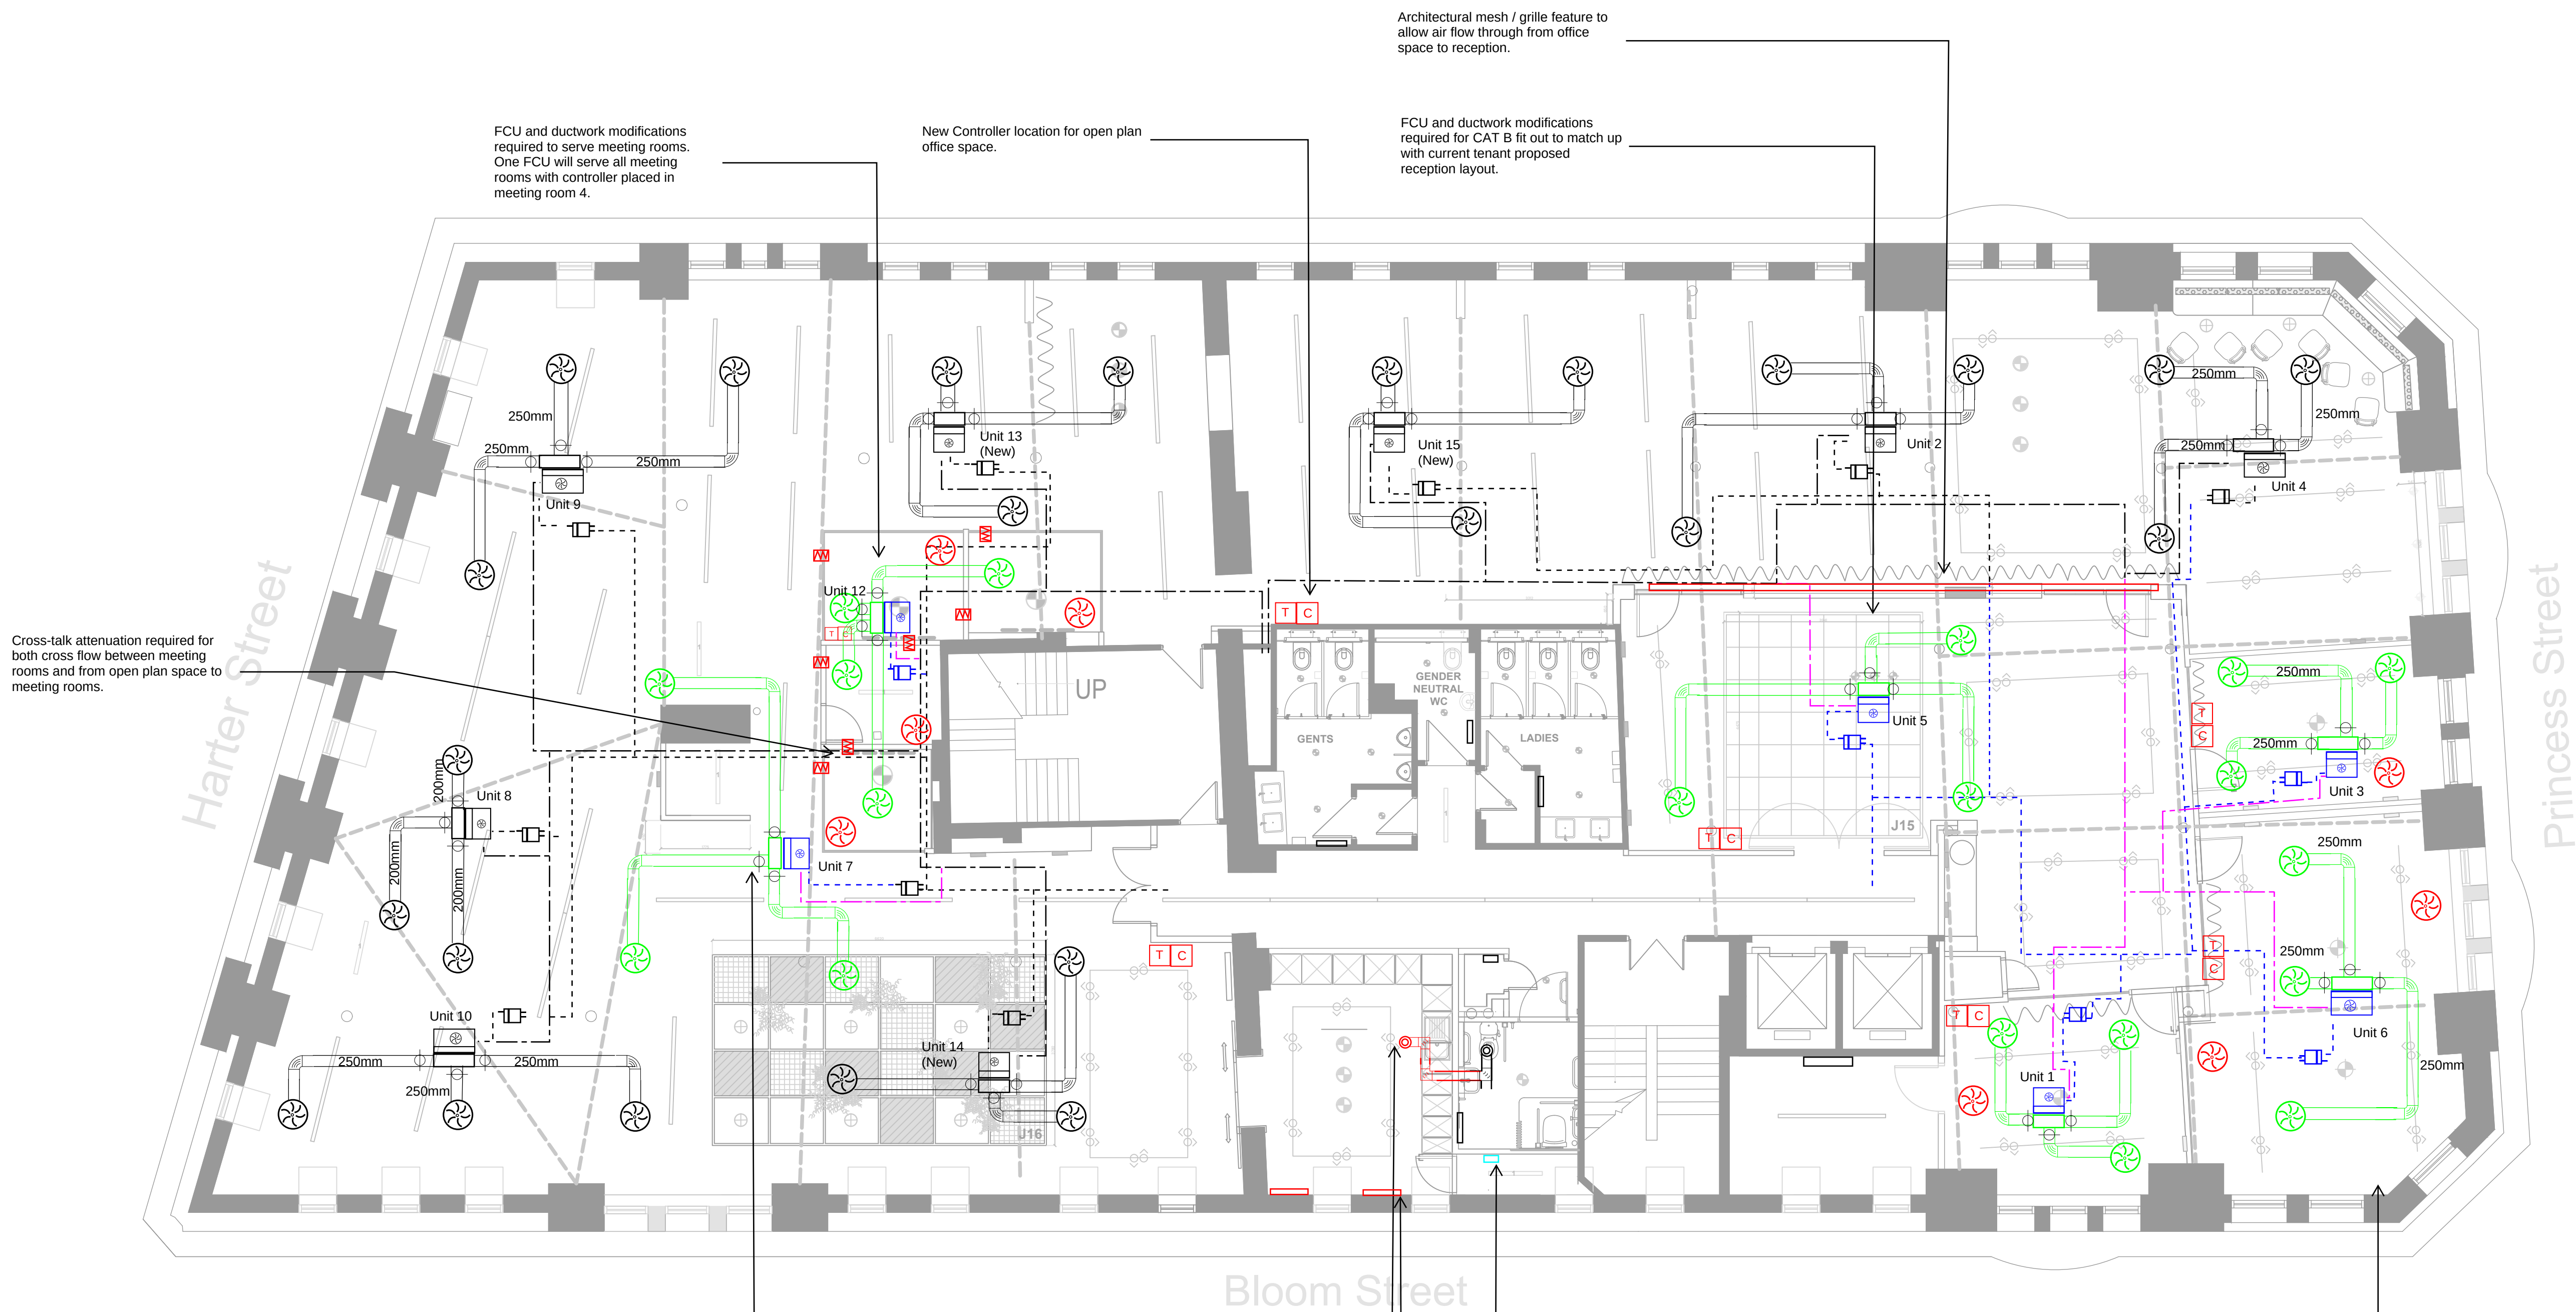

Notes:

1. This is not an installation drawing. All information and servicing philosophies shown are relevant to the current stage of the project (Stage 3), and subject to detailed calculations, co-ordination.
2. This drawing shall be read in conjunction with all other Stage 3 information, outline specification documents and all relevant Contract Documents.
3. This Stage 3 MEP issue pack is for information only.
4. It is the responsibility of the contractor to fully survey the existing utilities connection points to determine exact positions of supply and connection points, available routes and condition of existing services.

Drawing Notes

5. Circular Swirl Diffusers to be co-ordinated with proposed lighting scheme.
6. Contractor must ensure all ductwork and diffusers are co-ordinated with the structural beams within the space.
6. The contractor must ensure access for all fan coil units is as per manufacturers guidance and no light shall block the maintenance of the FCU.
7. Drawings must be read in line with CAT B specification and original CAT A drawings.

T1	CAT B ISSUE	18/03/25
Rev.	Description	Date



Matthew Murray House
97 Water Lane
LS11 5QN
info@joneshargreaves.co.uk
Tel: +44 (0)113 322 1590
www.joneshargreaves.co.uk

Client: UKRO/ADAPT

Project Address: 52 PRINCESS STREET

Drawing Title: 4TH FLOOR MECHANICAL LAYOUT - CAT B

Project Number: 23.179
Drawing Number: PS-JH-04-DR-M-5700
Revision: T01

Drawing Status: CAT B ISSUE

Scale: 1:75@A1
Date: 18/03/2025

Drawn By: BD
Checked By: KK

All dimensions are in millimetres unless otherwise stated.
Dimensions to be verified on site.
Do not scale.
Copyright of Jones Hargreaves. All rights reserved.
Drawing not to be reproduced without permission.

