


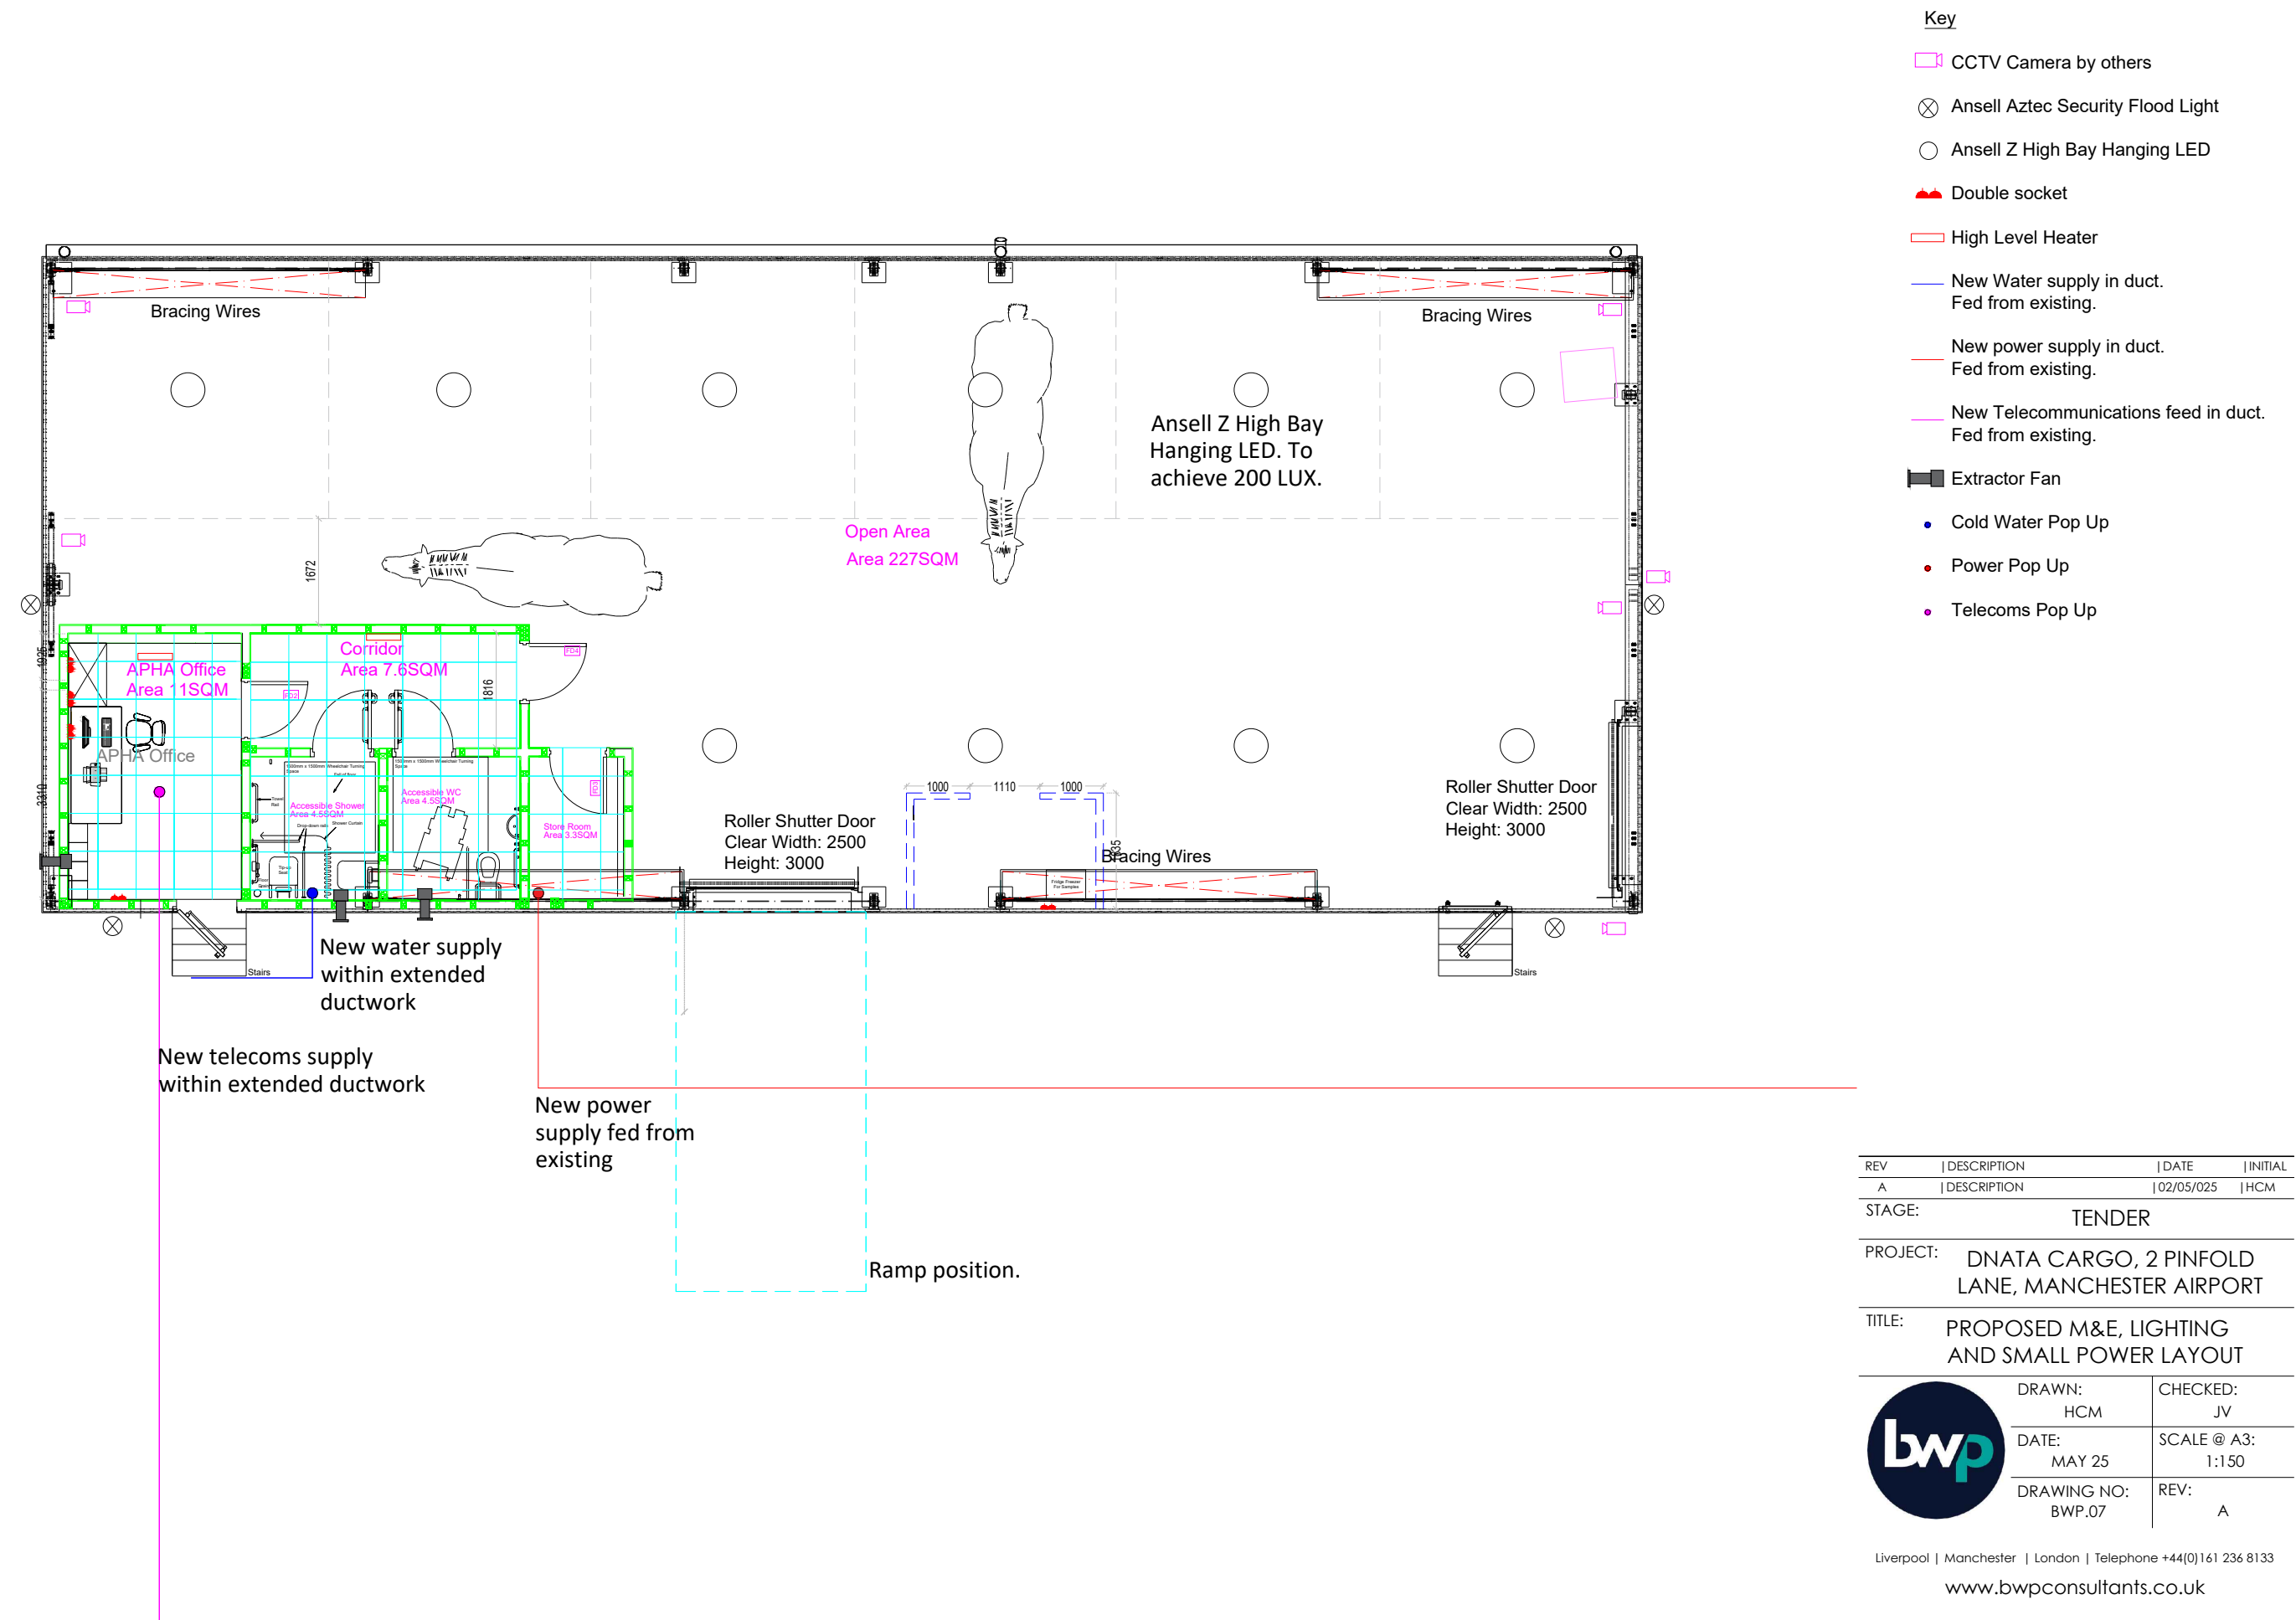

REV	DESCRIPTION	DATE	INITIAL
A	DESCRIPTION	02/05/25	HCM

STAGE: TENDER

PROJECT: DNATA CARGO, 2 PINFOLD
LANE, MANCHESTER AIRPORT

TITLE: PROPOSED M&E, LIGHTING
AND SMALL POWER LAYOUT

	DRAWN: HCM	CHECKED: JV
	DATE: MAY 25	SCALE @ A3: 1:150
	DRAWING NO: BWP.07	REV: A