


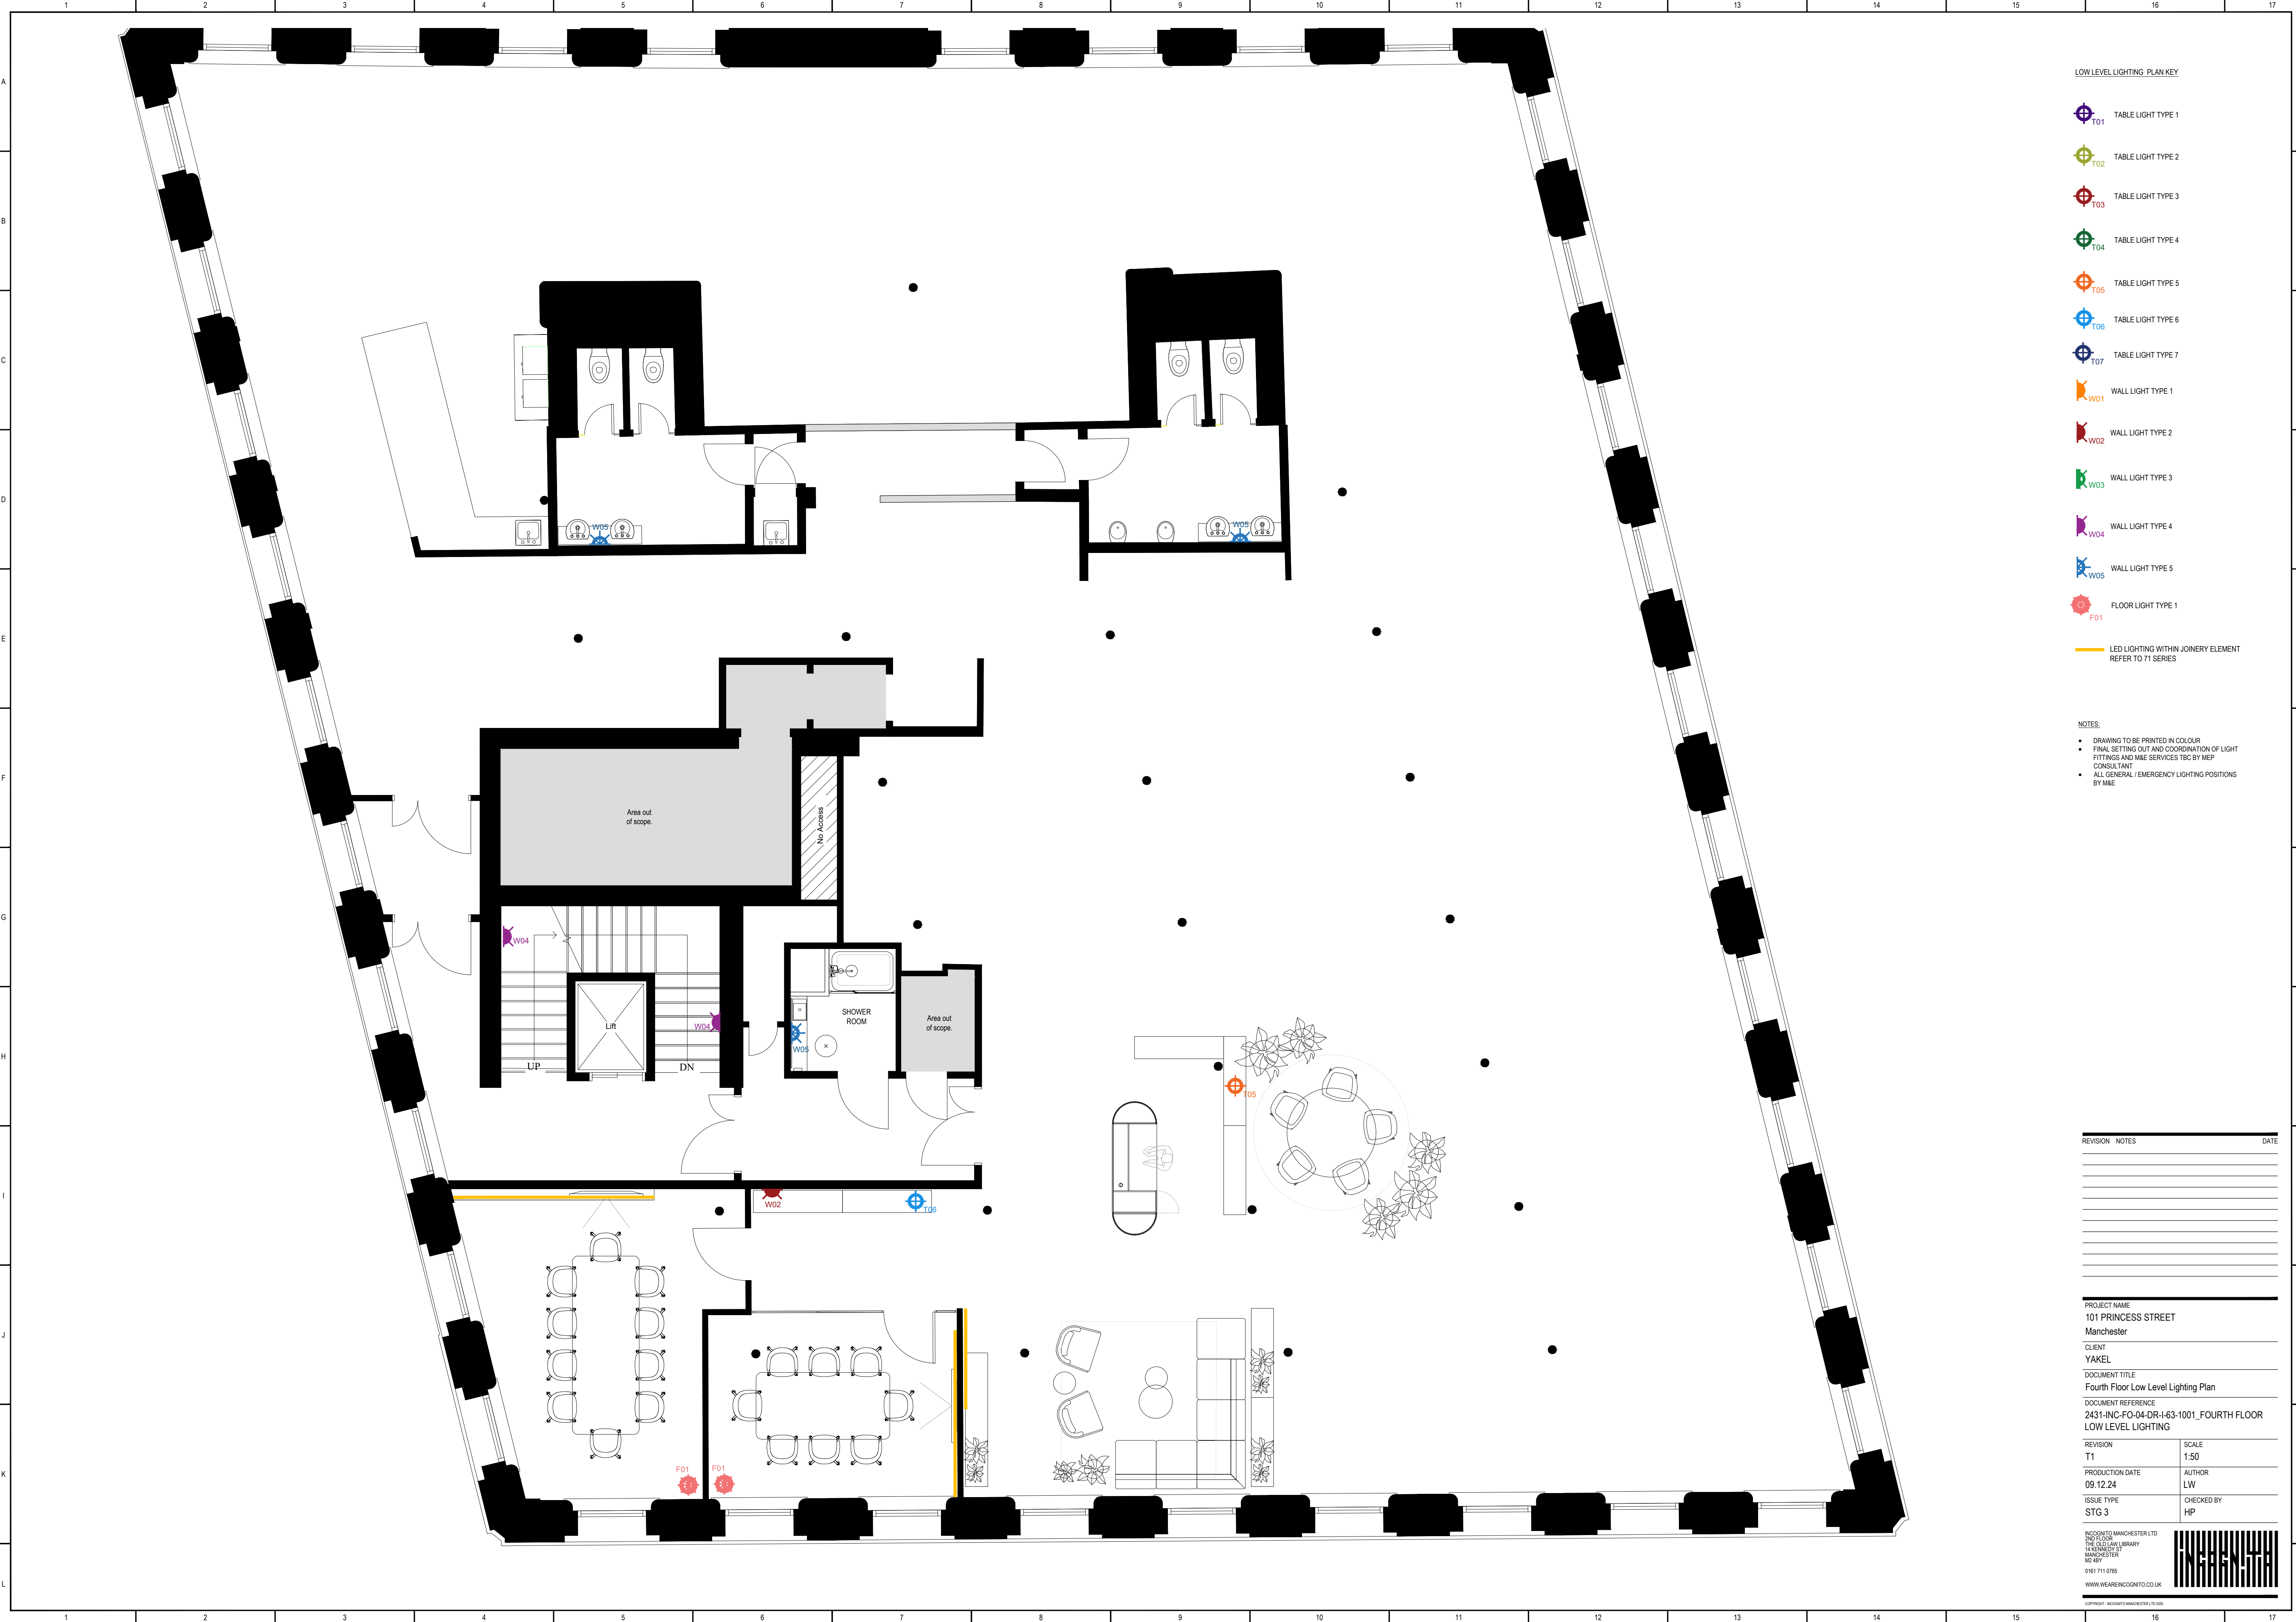

LOW LEVEL LIGHTING PLAN KEY

- T01 TABLE LIGHT TYPE 1
- T02 TABLE LIGHT TYPE 2
- T03 TABLE LIGHT TYPE 3
- T04 TABLE LIGHT TYPE 4
- T05 TABLE LIGHT TYPE 5
- T06 TABLE LIGHT TYPE 6
- T07 TABLE LIGHT TYPE 7
- W01 WALL LIGHT TYPE 1
- W02 WALL LIGHT TYPE 2
- W03 WALL LIGHT TYPE 3
- W04 WALL LIGHT TYPE 4
- W05 WALL LIGHT TYPE 5
- F01 FLOOR LIGHT TYPE 1
- LED LIGHTING WITHIN JOINERY ELEMENT REFER TO 71 SERIES

NOTES:

- DRAWING TO BE PRINTED IN COLOUR
- FINAL SETTING OUT AND COORDINATION OF LIGHT FITTINGS AND MAE SERVICES TBC BY MEP CONSULTANT
- ALL GENERAL / EMERGENCY LIGHTING POSITIONS BY MAE

REVISION	NOTES	DATE

PROJECT NAME 101 PRINCESS STREET Manchester	
CLIENT YAKEL	
DOCUMENT TITLE Fourth Floor Low Level Lighting Plan	
DOCUMENT REFERENCE 2431-INC-FO-04-DR-I-63-1001_FOURTH FLOOR LOW LEVEL LIGHTING	
REVISION T1	SCALE 1:50
PRODUCTION DATE 09.12.24	AUTHOR LW
ISSUE TYPE STG 3	CHECKED BY HP
INCQINTO MANCHESTER LTD 2ND FLOOR THE OLD LAW LIBRARY 14 ROXBURY ST MANCHESTER M2 8BY 0161 711 0785 WWW.WEAREINCQINTO.CO.UK	

