



ALL DIMENSIONS IN MM

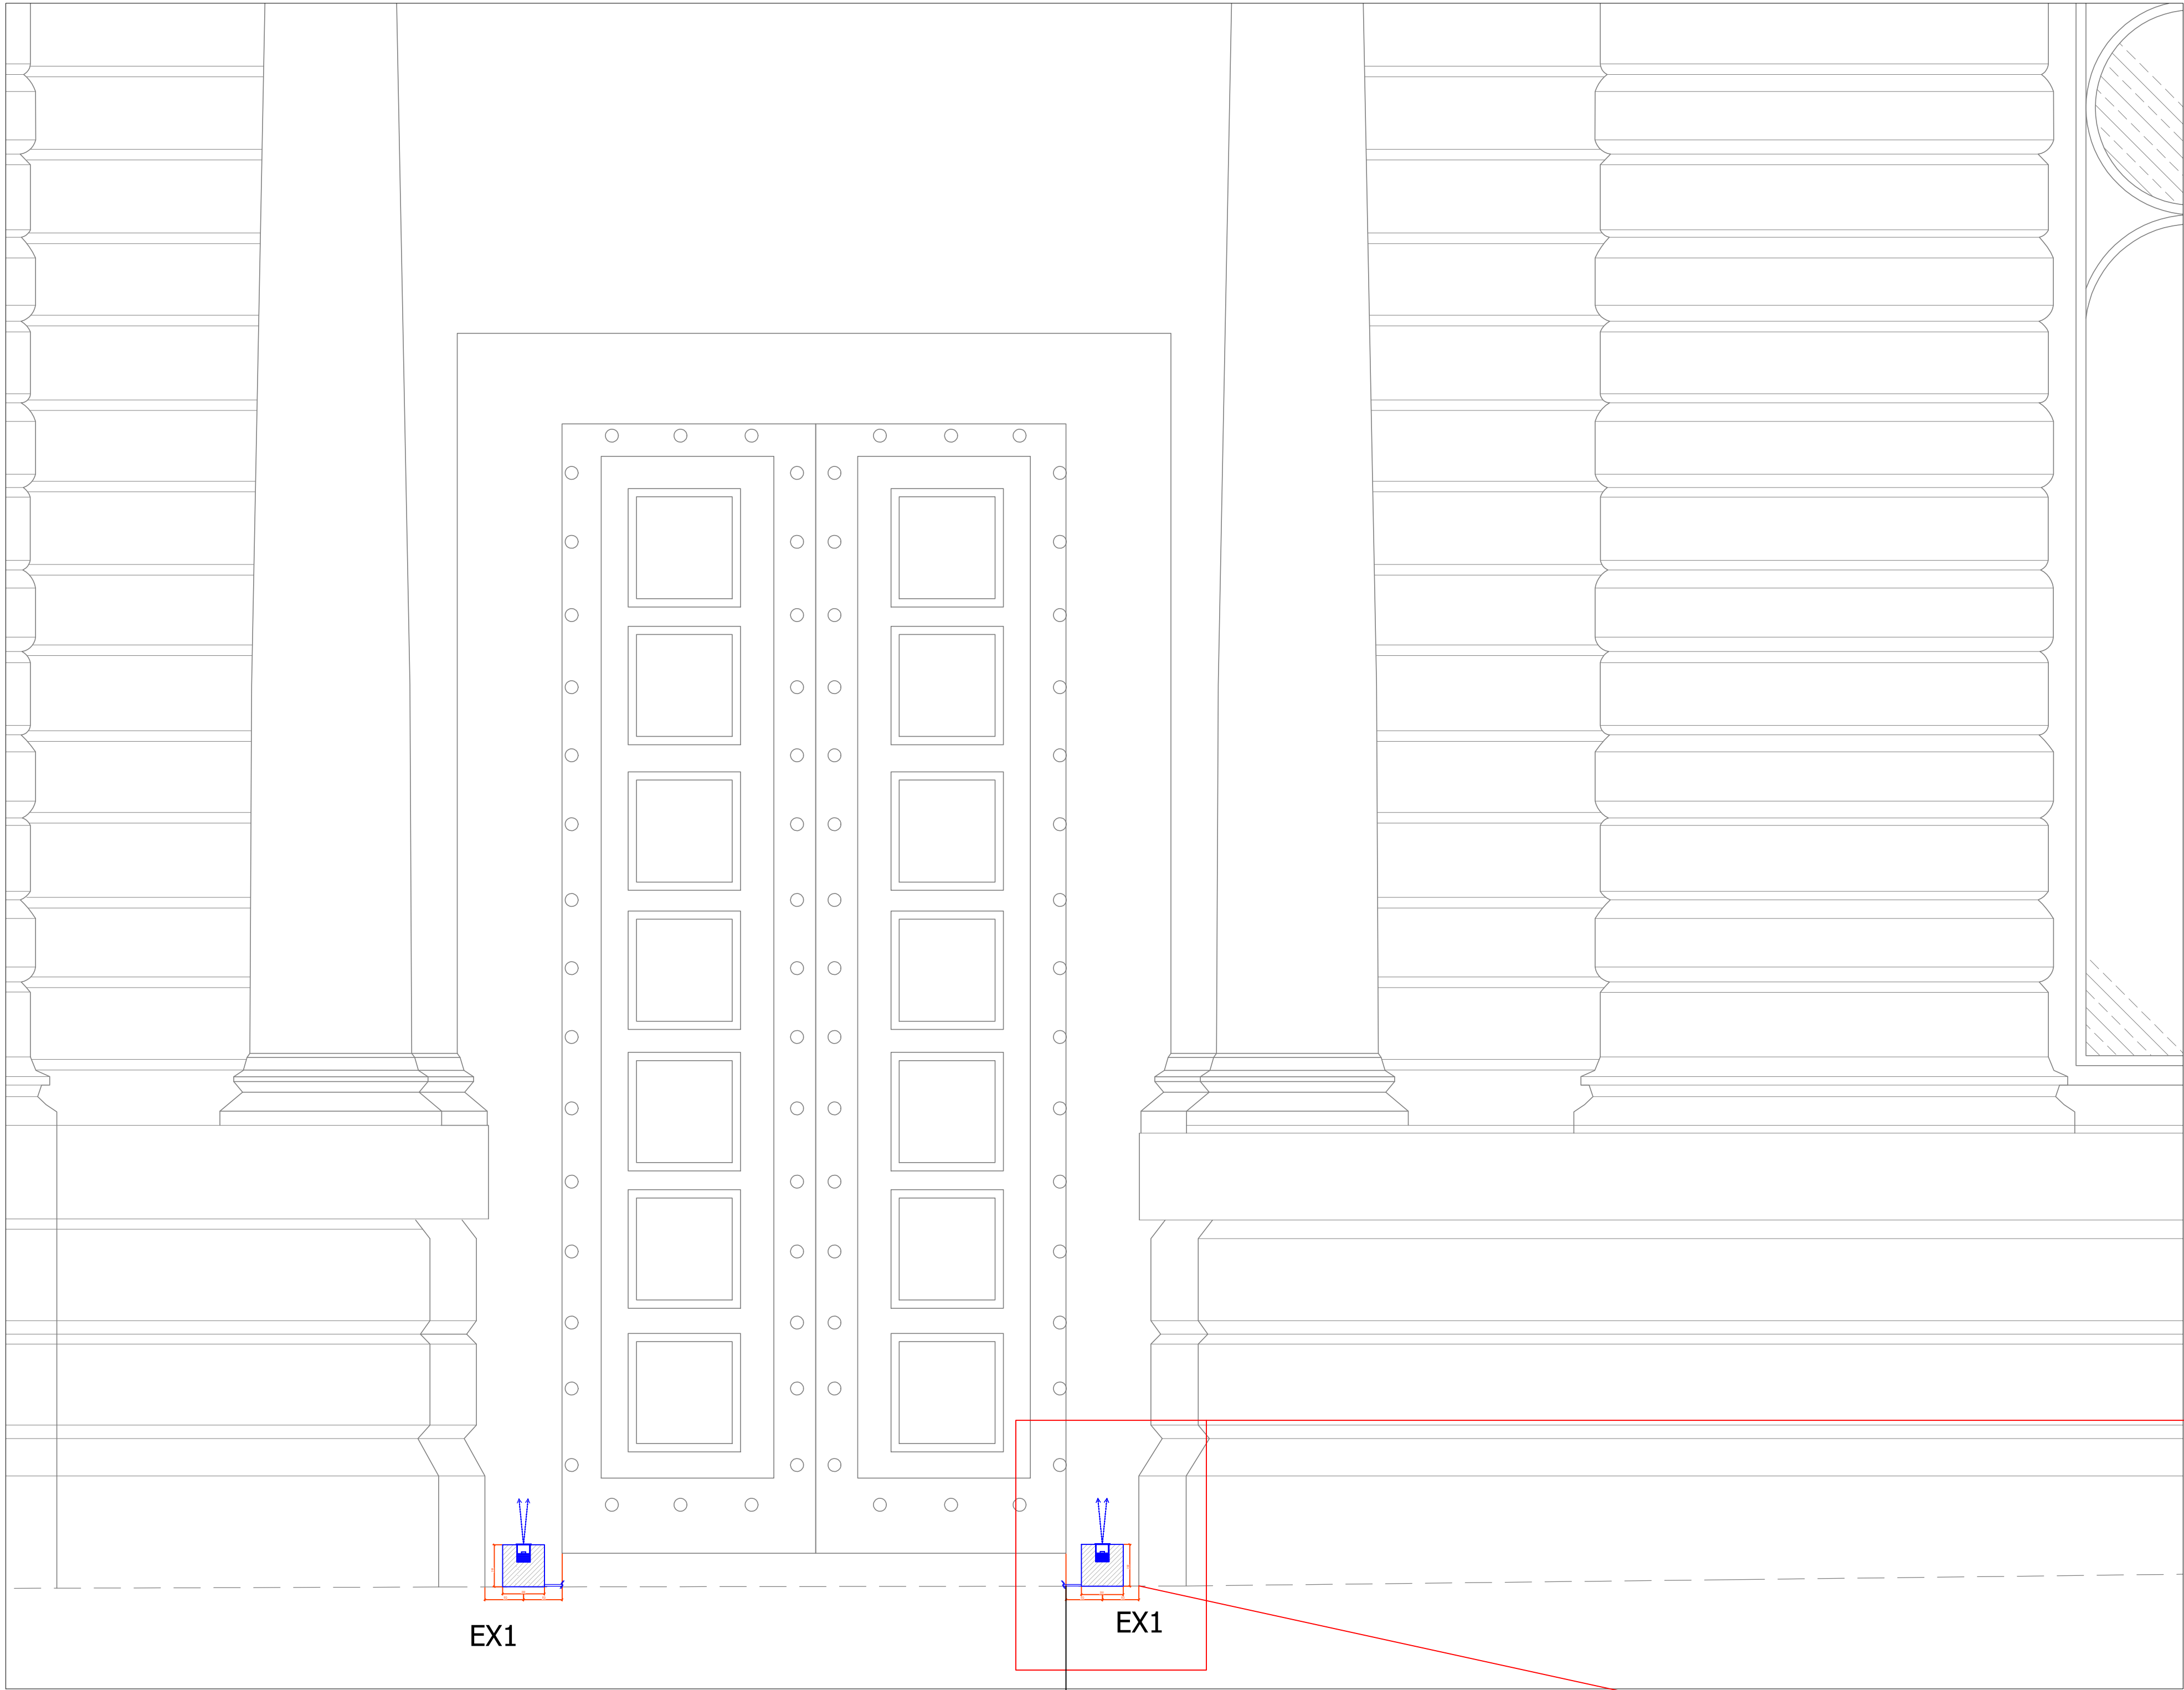


PROPOSED LIGHTING ELEVATION - MOSLEY STREET MAIN ENTRANCE
SCALE 1:20

LV CABLE TO PASS THROUGH
SEALED 8MM HOLE IN CORNER
OF DOOR FRAME TO REMOTE
DRIVER.

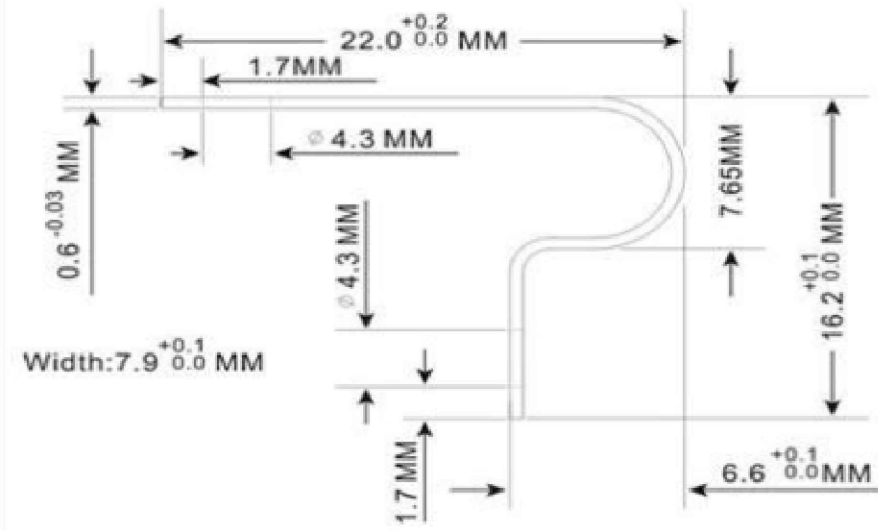

CABLE CLIP TO SECURE CABLE LINE AND
FIXTURES. 6MM GREY CABLING. FIXED IN
PLACE USING CLIPS REQUIRED EVERY 200MM
(MIN) IN GREY FINISH.

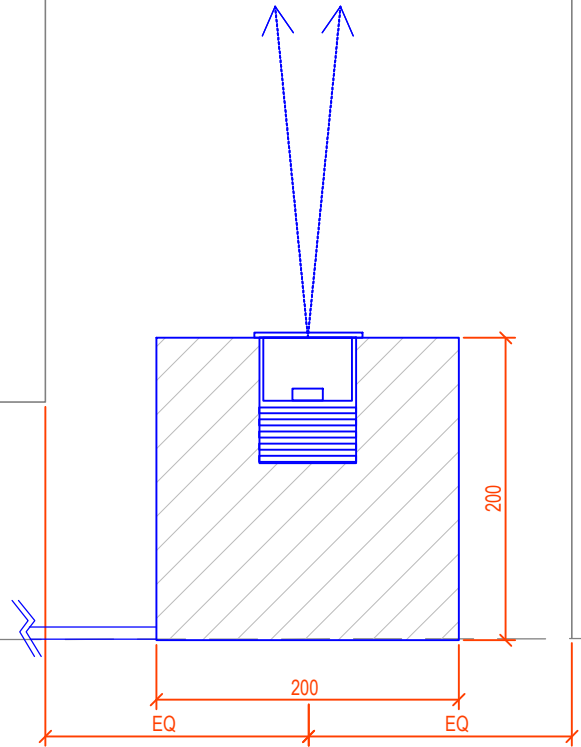

EX1

EX1 - INGROUND UPLIGHT RECESSED
WITHIN A GRANITE STONE BLOCK.
NARROW BEAM ANGLE. CABLE ENTRY
BEHIND THE FITTING. BLOCK FINISHED
TO MATCH ENTRANCE PAVING STONE.

LIGHTING REFERENCE 'EX1' DETAIL
SCALE 1:5

© Mistry Lighting LTD
All Rights Reserved. Mistry Lighting (unless otherwise agreed in writing) their rights under s.77 to 89
of the Copyright, Designs and Patents Act 1988.
DO NOT SCALE THIS DRAWING.

Notes

DRAWING TO BE PRINTED IN COLOUR

- THIS DRAWING MUST BE READ IN CONJUNCTION
WITH ALL OTHER RELEVANT PROJECT
DRAWINGS AND SPECIFICATIONS
- DO NOT SCALE FROM THIS DRAWING. IF IN
DOUBT PLEASE REQUEST FURTHER
INFORMATION.
- ALL DIMENSIONS ARE SHOWN IN MILLIMETERS
UNLESS NOTES STATE OTHERWISE.
- SYMBOLS INDICATE PROPOSED LOCATIONS OF
LIGHTING EQUIPMENT. FOR FURTHER
INFORMATION PLEASE REFER TO THE
LUMINAIRE SCHEDULES AND DETAILS SHOWN.
- THE LIGHTING INSTALLATION REQUIRES A
VARIETY OF LUMINAIRE TYPES TO ACHIEVE THE
DESIRED AFFECTS. INFORMATION HAS BEEN
PROVIDED ON THIS DRAWING AS GENERAL
GUIDANCE AND OUTLINE OF GOOD PRACTICE.
FOR MORE SPECIFIC RECOMMENDATIONS
PLEASE REFER TO MANUFACTURERS DETAILS
FOR APPLICATION, OPERATION, HANDLING,
CLEANING AND DISPOSAL INSTRUCTIONS.
- INSTALLATION AND MAINTENANCE OF LIGHTING
EQUIPMENT INSTALLED AT ANY HEIGHT ABOVE
GROUND REQUIRES PRECAUTIONS TO BE
TAKEN. ACCESS ARRANGEMENT SHOULD BE IN
STRICT ACCORDANCE WITH THE PROJECTS
ACCESS REPORT, METHOD STATEMENT AND
HEALTH AND SAFETY GUIDELINES.

04	MAIN ENTRANCE LIGHTING DETAIL	02/06/25	KM
03	MAIN ENTRANCE LIGHTING DETAIL	26/03/25	KM
02	MAIN ENTRANCE LIGHTING DETAIL	25/02/25	KM
01	FACADE LIGHTING DETAIL	30/01/25	KM
Rev	Description	Date	Dwn

SCHEME DESIGN

Status of drawing

**MISTRY
LIGHTING**



0774715 3333
WWW.MISTRYLIGHTING.COM
KRISHNA@MISTRYLIGHTING.COM

Project CUT & CRAFT, MANCHESTER

Drawing Title FACADE LIGHTING - MAIN ENTRANCE

Drawn By Date Scale Drawing No.
KM 02/06/2025 VARIES ML_CCM_F01

Drawing Order: Revision Client Stage
02 of 03 REV 04 CUT&CRAFT SCHEME DESIGN