


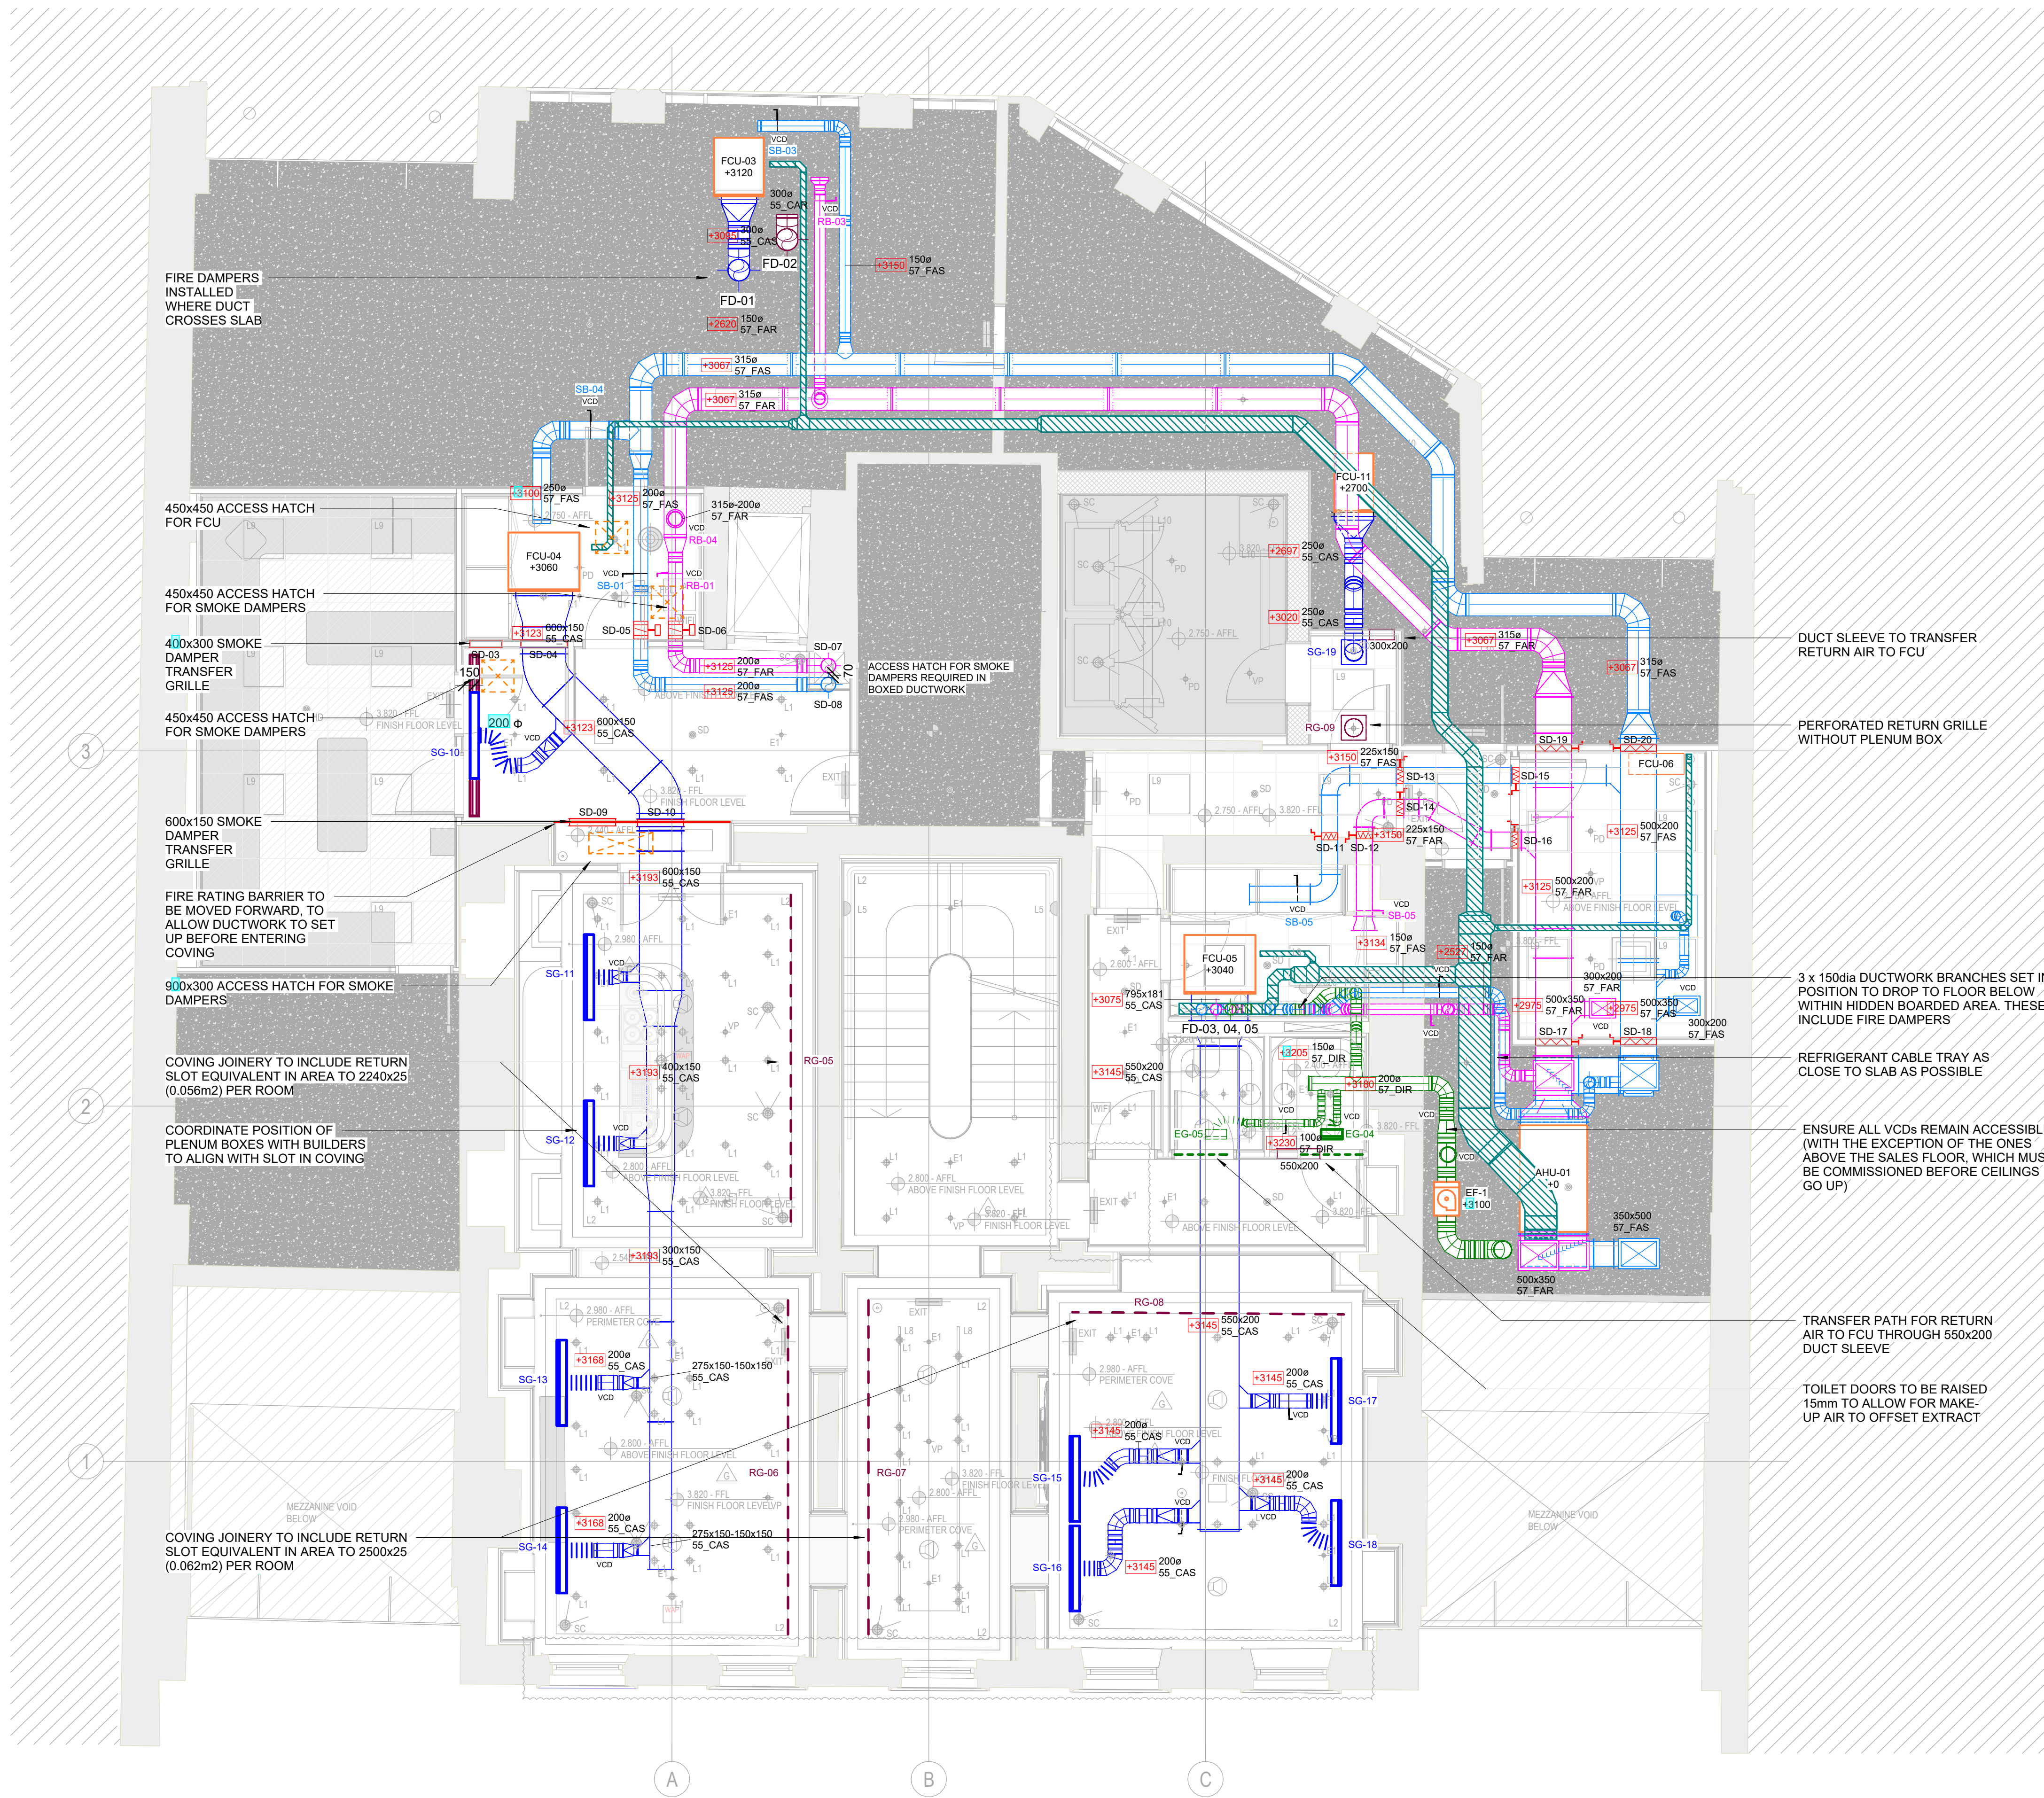

- STANDARD NOTES
- DO NOT SCALE FROM THIS DRAWING. CONFIRM ALL DIMENSIONS AND STRUCTURAL INFORMATION ON SITE, IF IN DOUBT ASK BEFORE ACTING.

REV	DATE	BY	DESCRIPTION	CHK	APP
F	26/11/2024	BP	GRILLE SCHEDULE + CHANGES	JO	JO
E	19/11/2024	BP	IMPLEMENTING JPA + PHP COMMENTS	JO	JO
D	12/11/2024	BP	COORDINATION WITH NEW HEIGHTS	JO	JO
C	28/10/2024	NS	ADDED HEIGHTS	BP	JO
B	18/10/2024	NS	PROPOSED PRELIMINARY LAYOUT	BP	JO
A	17/09/2024	NS	PROPOSED PRELIMINARY LAYOUT	BP	JO

DRAWING STATUS | PROPOSAL

TaylorGrace
air conditioning ltd

UNIT 2B PARK FARM BARN, CV7 7TL
TEL: +44 (0)1676 522901
WWW.TAYLORGRACE.CO.UK

PROJECT | AP TOWNHOUSE, MANCHESTER

DRAWING TITLE | First Floor HVAC Layout

DESIGNER | BP
SCALE | 1:50 @ A1
CHECKED | JO
DRAWN | BP

DRAWING No | TGAC-5245-M-57-01
REV - F