
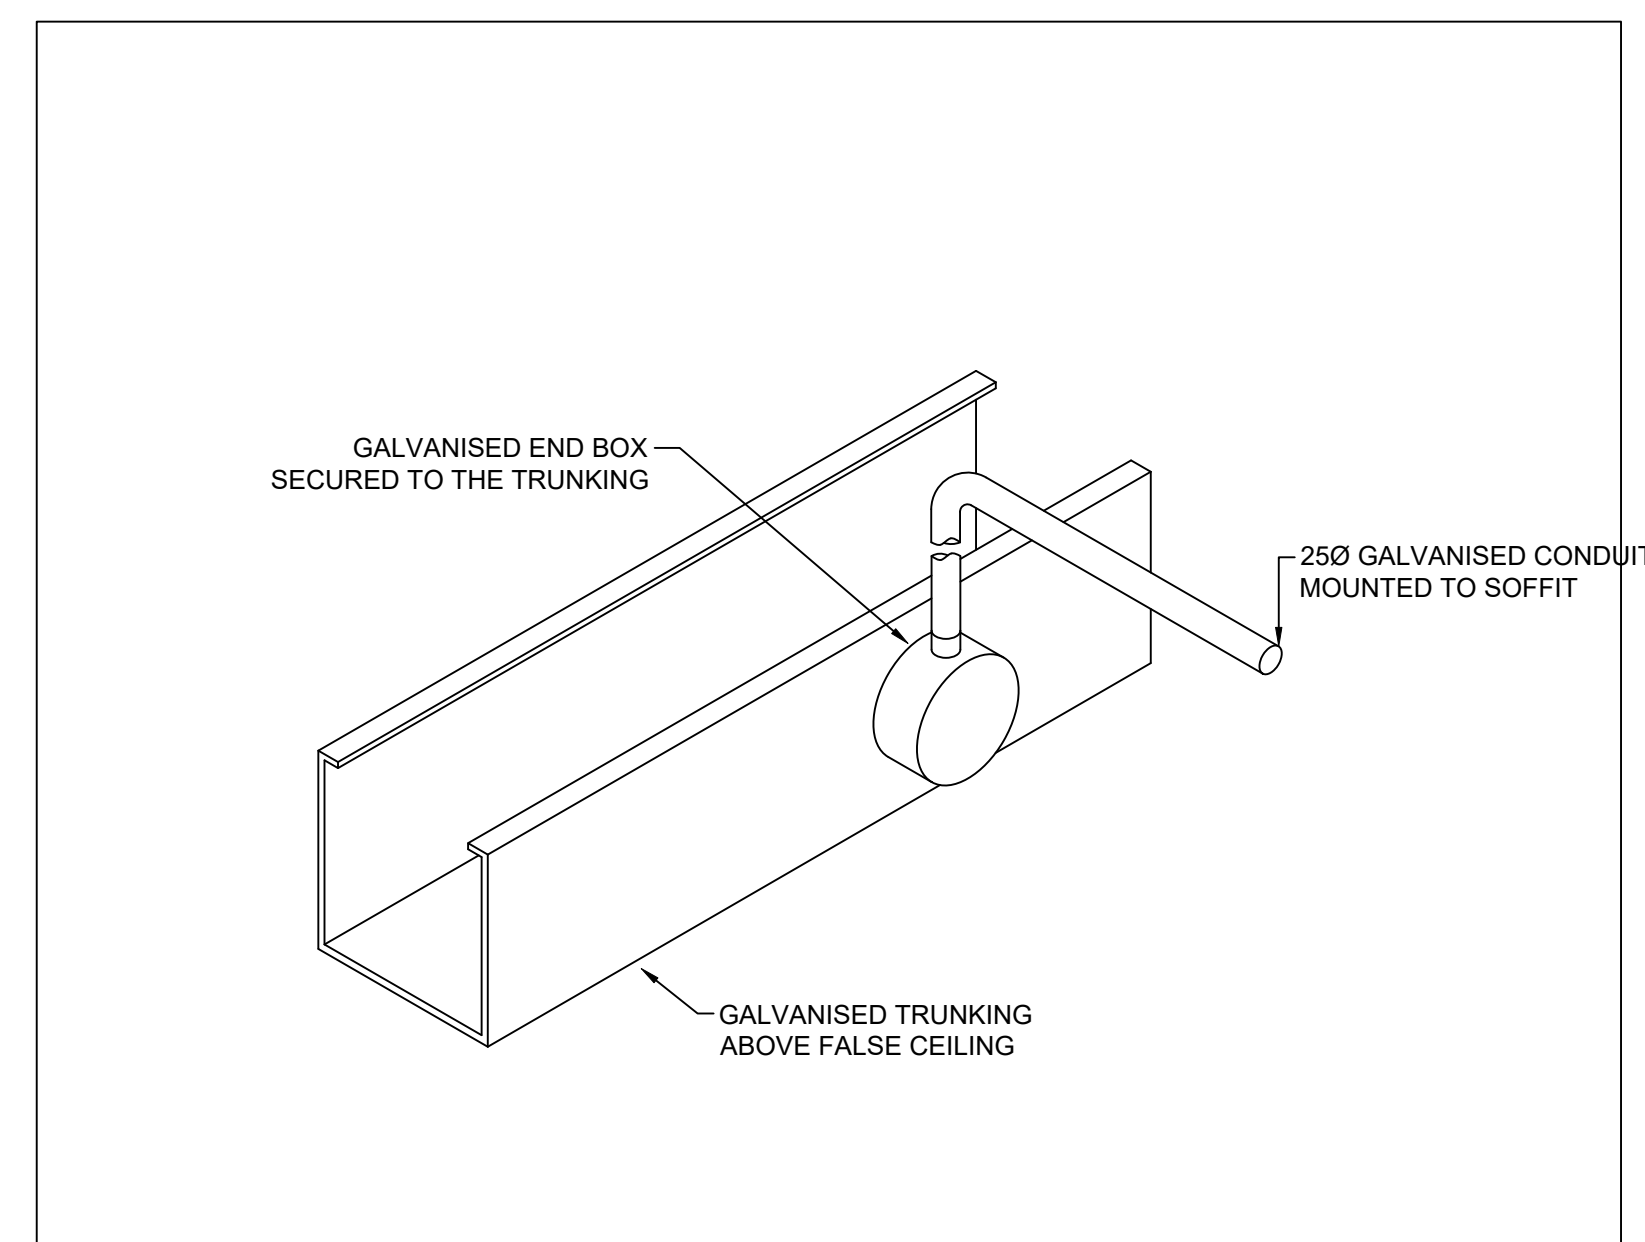
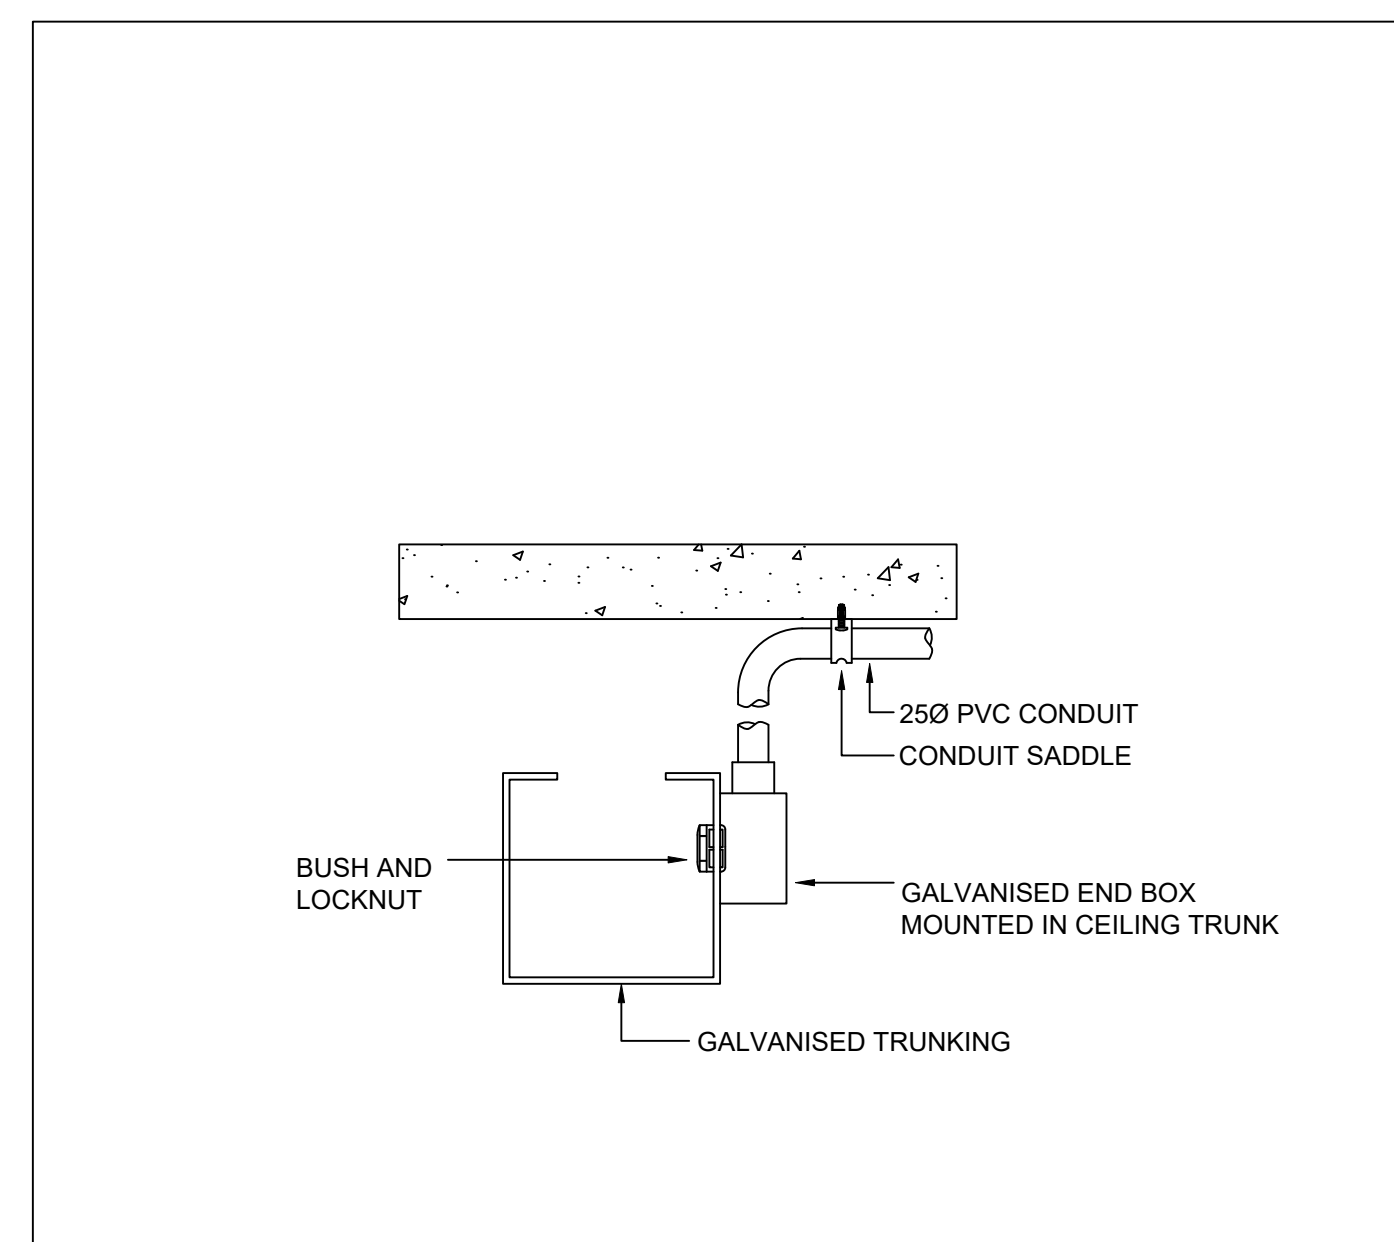


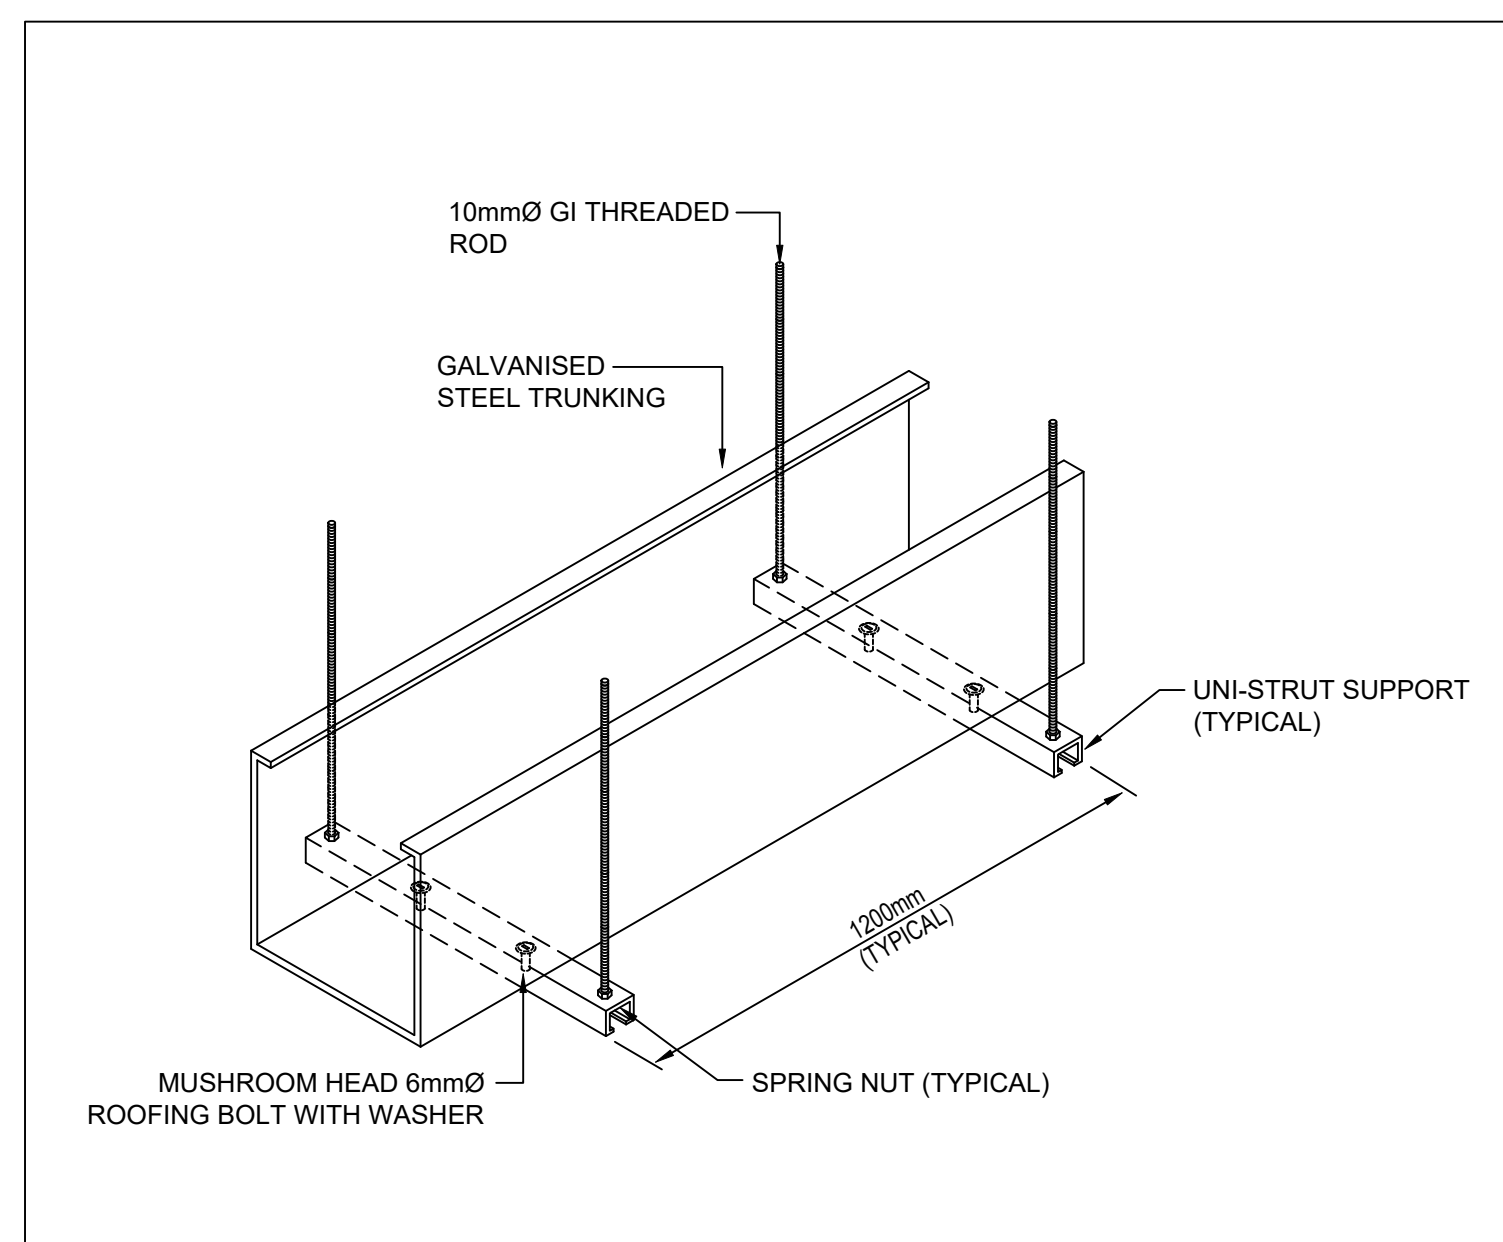

LEGEND OF DISTRIBUTION & SMALL POWER SYMBOLS	
SYMBOL	DESCRIPTION
	SWITCH-BOARD
	THREE PHASE (TPN) DISTRIBUTION BOARD
	SWITCHED FUSED CONNECTION UNIT
	ISOLATING SWITCH SP&N
	ISOLATING SWITCH TPN
	GALVANISED TRUNKING
	GALVANISED TRUNKING

ASHP - AIR SOURCE HEAT PUMP
EPH - ELECTRIC PANEL HEATER
P - PUMP
PU - PRESSURISATION UNIT

This document and its contents are the property of the Purchaser/Employer and Crookes Walker Consulting. They may not be copied or reproduced in any way, in part or whole, without prior written approval of both parties. Violations will result in legal action.

This drawing shall be read in conjunction with the CWC Mechanical and Electrical Specification(s).

DO NOT SCALE FROM THIS DRAWING

DESIGNERS RISK ASSESSMENT

REFER TO APPENDIX 1 OF M&E SPECIFICATION FOR DESIGNERS RISK ASSESSMENT SCHEDULE



DRAWING BACKGROUND(S):

GENERAL NOTES:


1. THIS DRAWING IS TO BE READ IN CONJUNCTION WITH ALL RELEVANT ARCHITECTURAL & STRUCTURAL DRAWINGS.
2. THIS DRAWING IS TO BE READ IN CONJUNCTION WITH ALL RELEVANT BUILDING SERVICES DRAWINGS & THE RELEVANT SECTIONS OF THE SPECIFICATIONS & SCHEDULES.
3. THIS DRAWING IS NOT TO BE SCALED.
4. ALL DIMENSIONS ARE IN mm UNLESS OTHERWISE STATED.
5. ANY DISCREPANCIES, ERRORS OR OMISSIONS ARE TO BE CLARIFIED WITH THE RELEVANT ENGINEER AT THE EARLIEST OPPORTUNITY.

SMALL POWER NOTES

1. CIRCUITS SHALL BE INSTALLED TO THE LATEST VERSION OF ALL RELEVANT STANDARDS, INCLUDING, BUT NOT LIMITED TO BS7671.
2. ALL FUSED CONNECTION UNITS AND ISOLATORS ARE TO HAVE ENGRAVED/ FIXED LABELS TO INDICATE THE ITEM OF EQUIPMENT SERVED.
3. POSITION OF ALL POWER, DATA ARE INDICATIVE ONLY. FINAL SETTING OUT TO BE AGREED WITH THE ARCHITECT IN LINE WITH FINAL FEE LAYOUTS
4. ALL ISOLATORS ARE TO BE SELECTED TO ENSURE IP 67 RATING IS ACHIEVED
5. ALL CABLE GLANDS EXTERNAL TO THE BUILDING ARE TO BE CE GLANDS AND INSTALLED WITH THE ADDITION OF IP67 WASHERS
6. ALL NEW DISTRIBUTION EQUIPMENT SHALL BE BY EATON. ALL NEW MCCBS ARE TO BE RATED TO A MIN OF 100kVA.

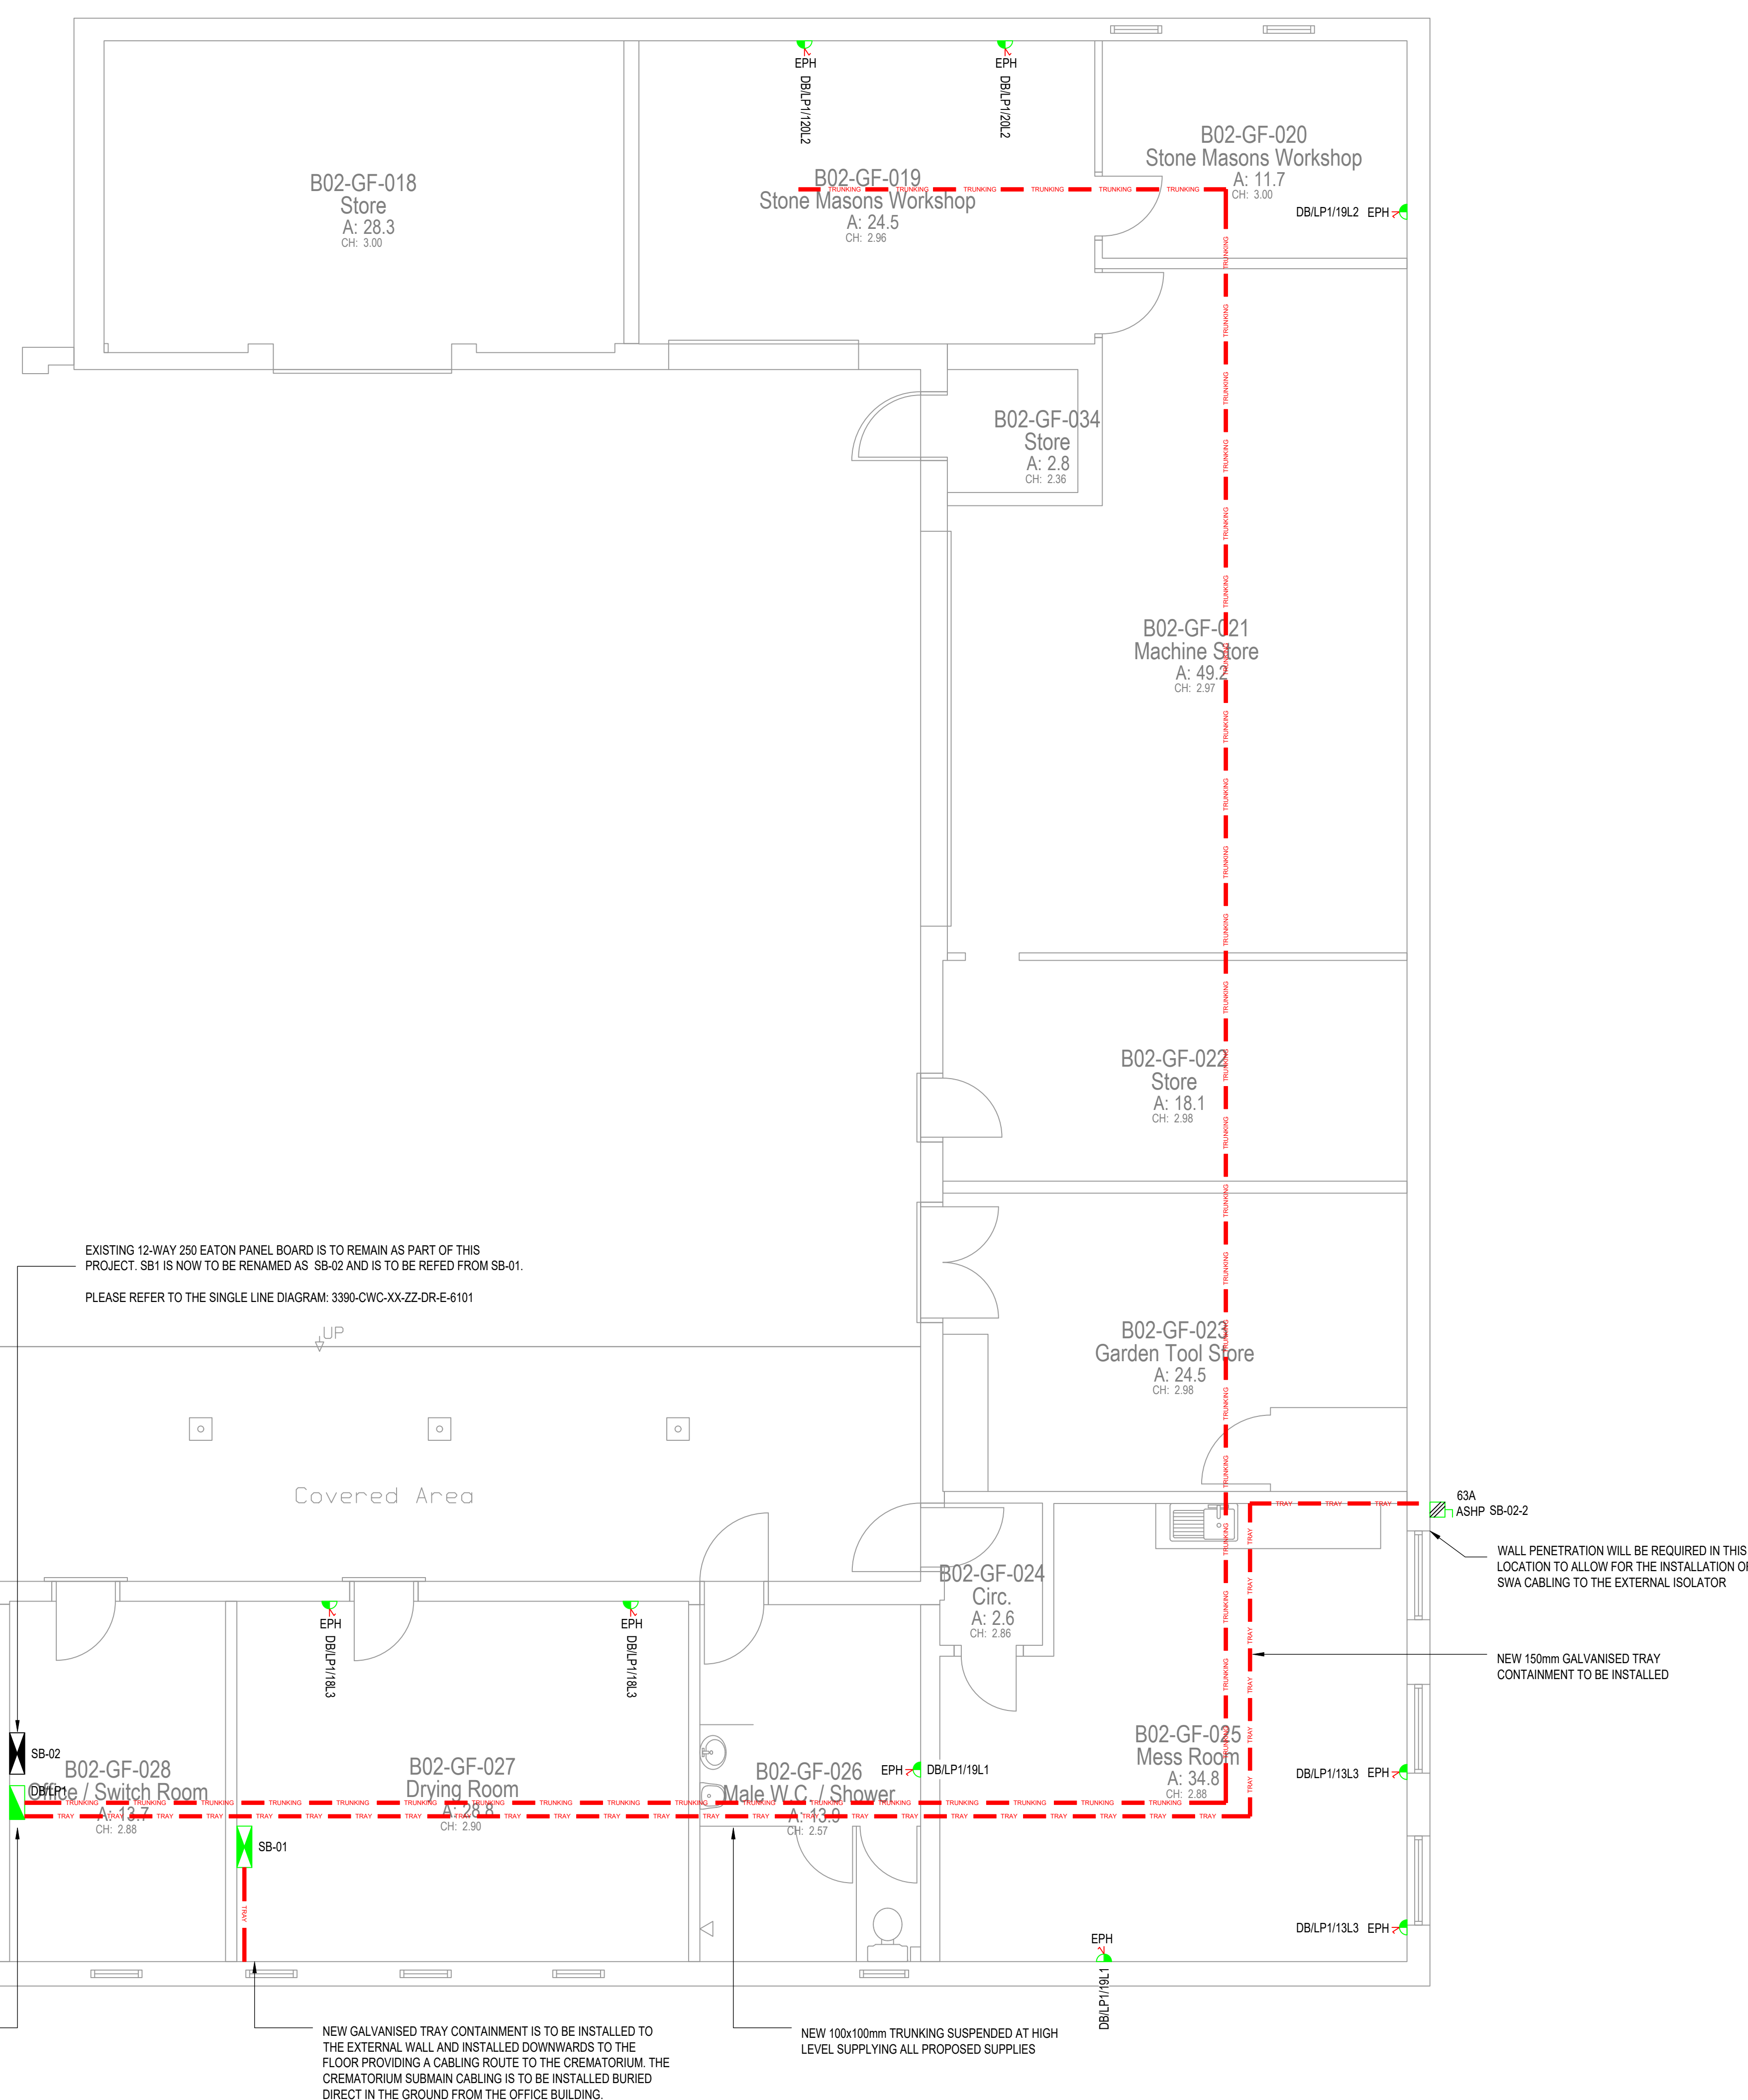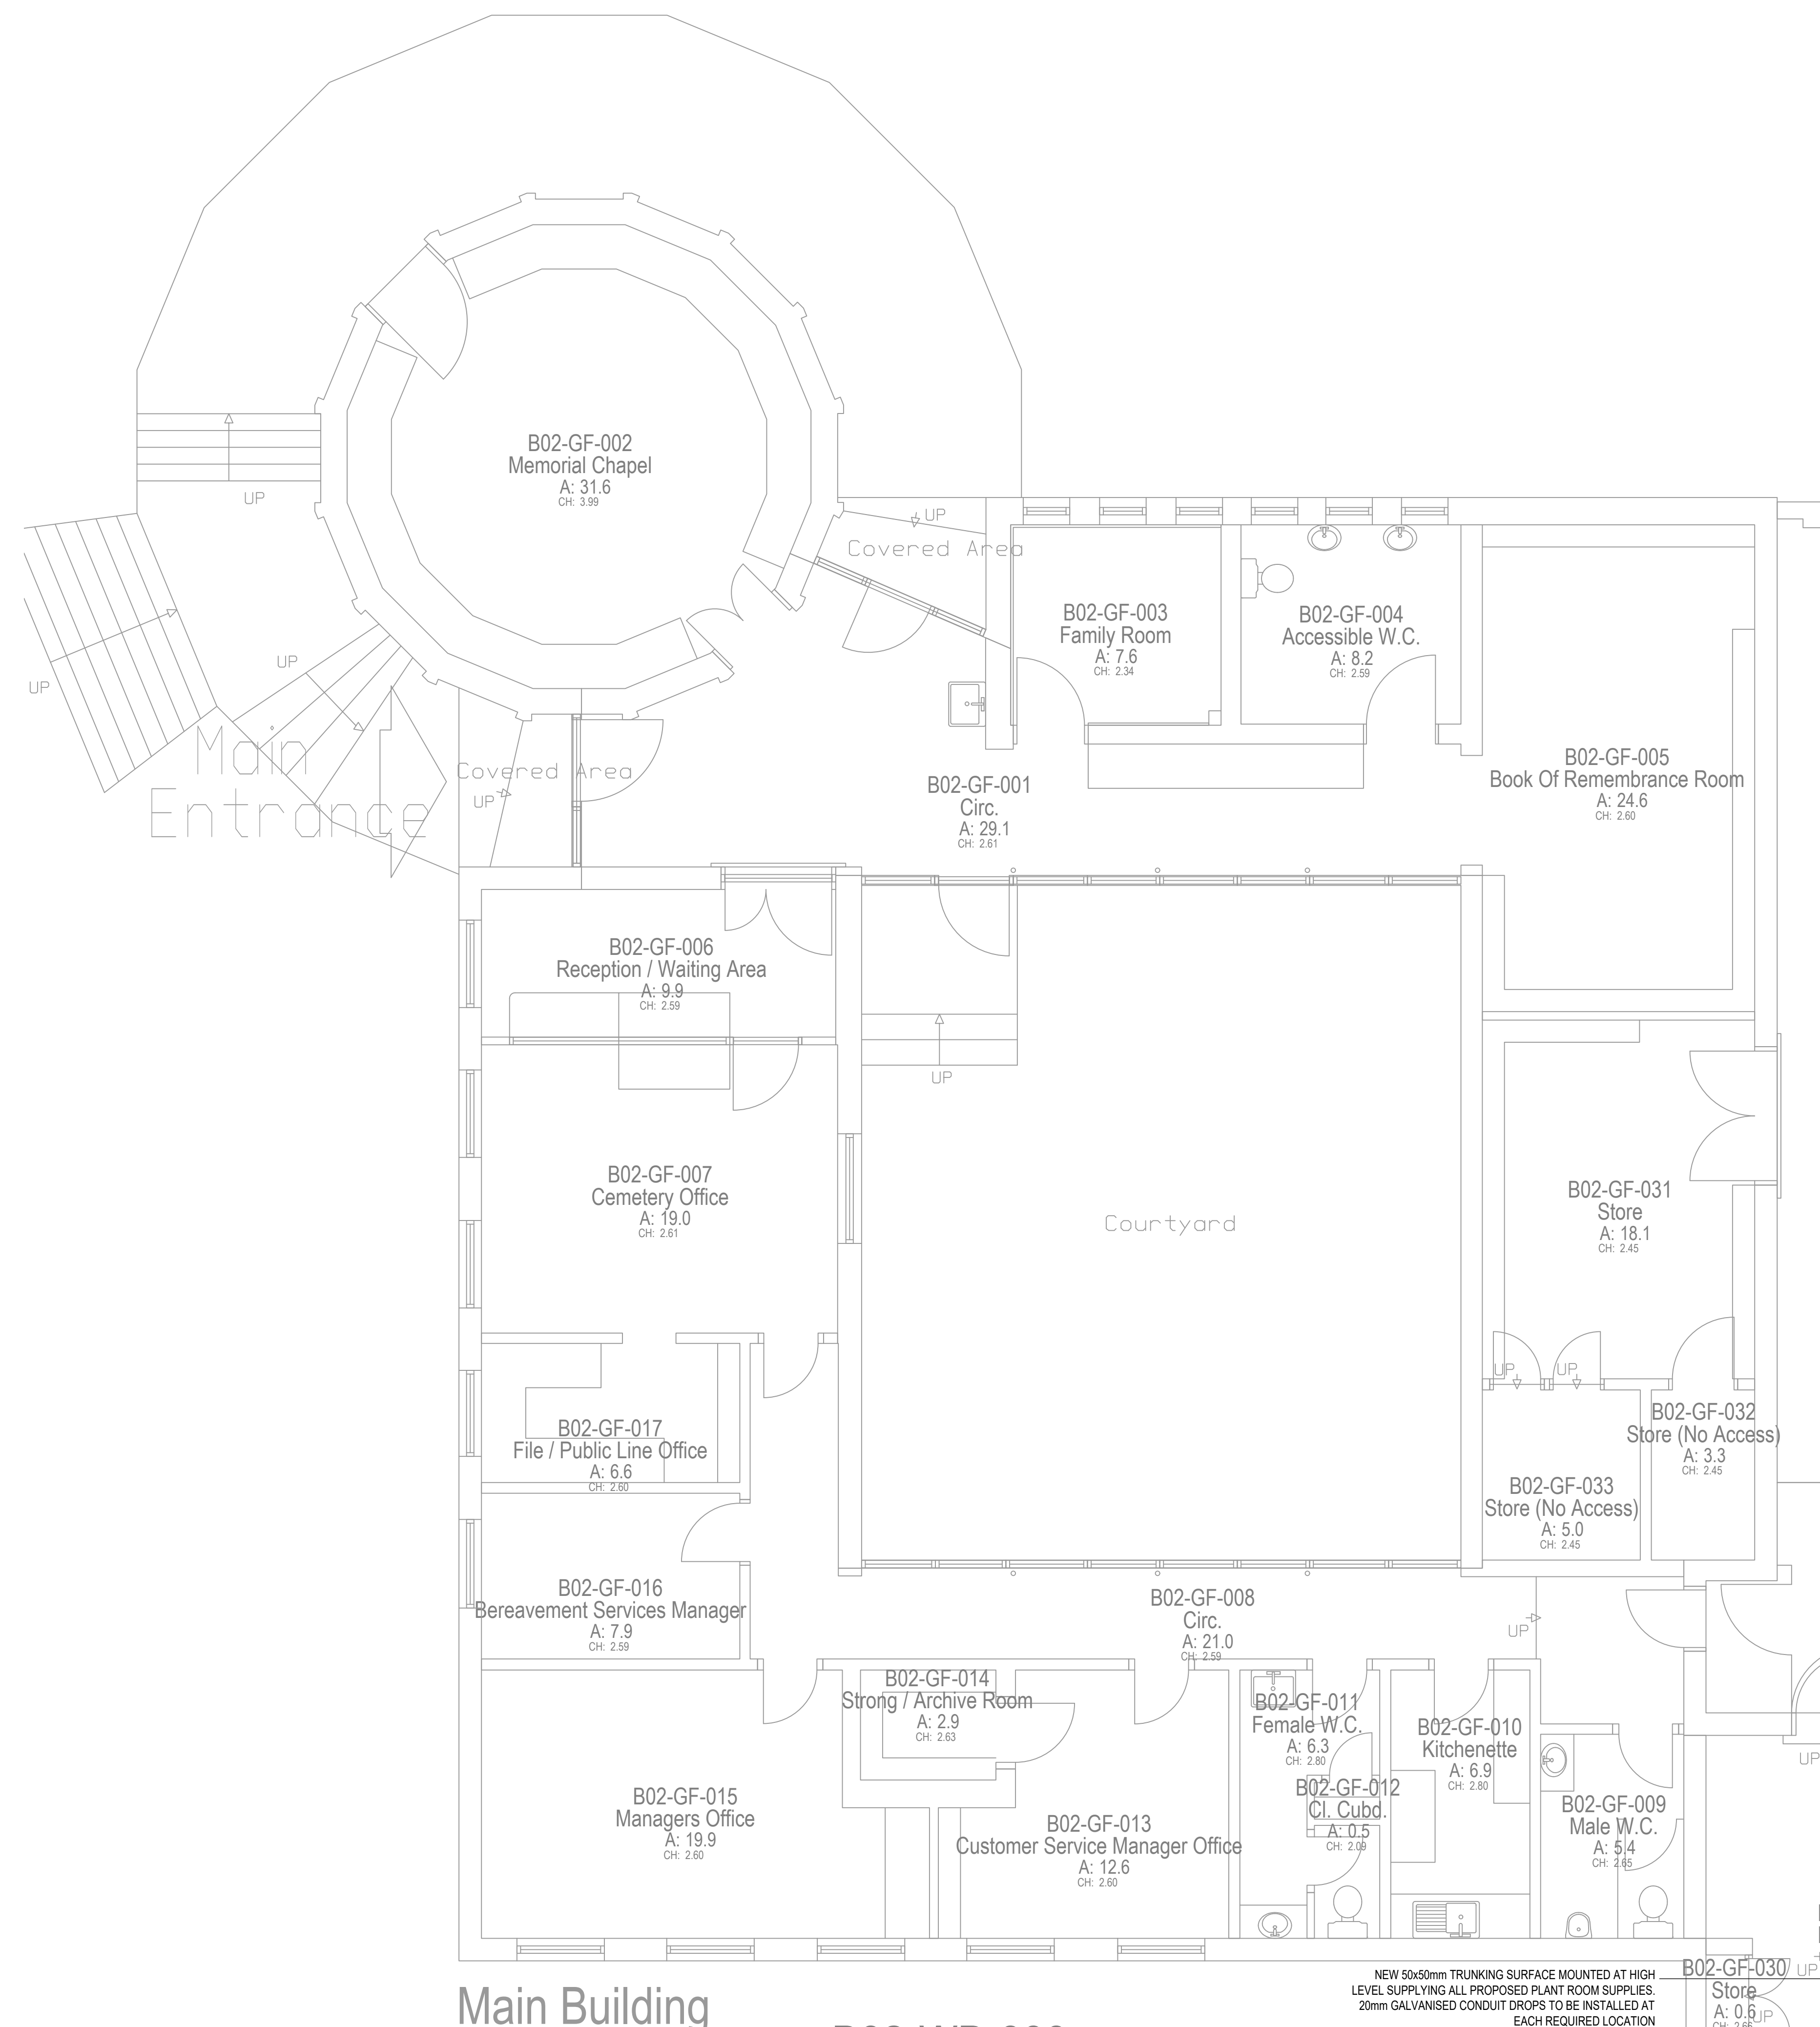

T2	16.12.24	TENDER ISSUE	RW	JS
T1	25.11.24	TENDER ISSUE	RW	JS
Rev	Date	Description	Eng	Ch

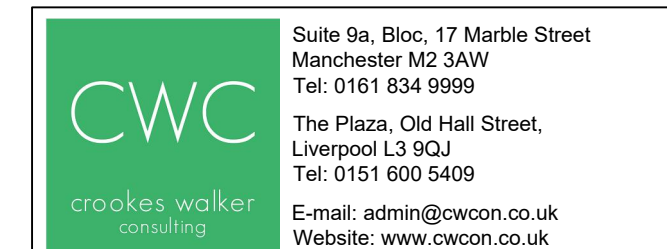

Client _____



Project
EQUANS MCC BLACKELY
CEMETERY OFFICE AND
YARD

Drawing Title
PROPOSED
SMALL POWER LAYOUT

Click on the **Clipboard** icon.

Project No. 3390	Drawn RW	Scale / Paper Size 1:50 @ A0
Drawing No. 3390-CWC-XX-00-DR-E-6201		Rev T2