


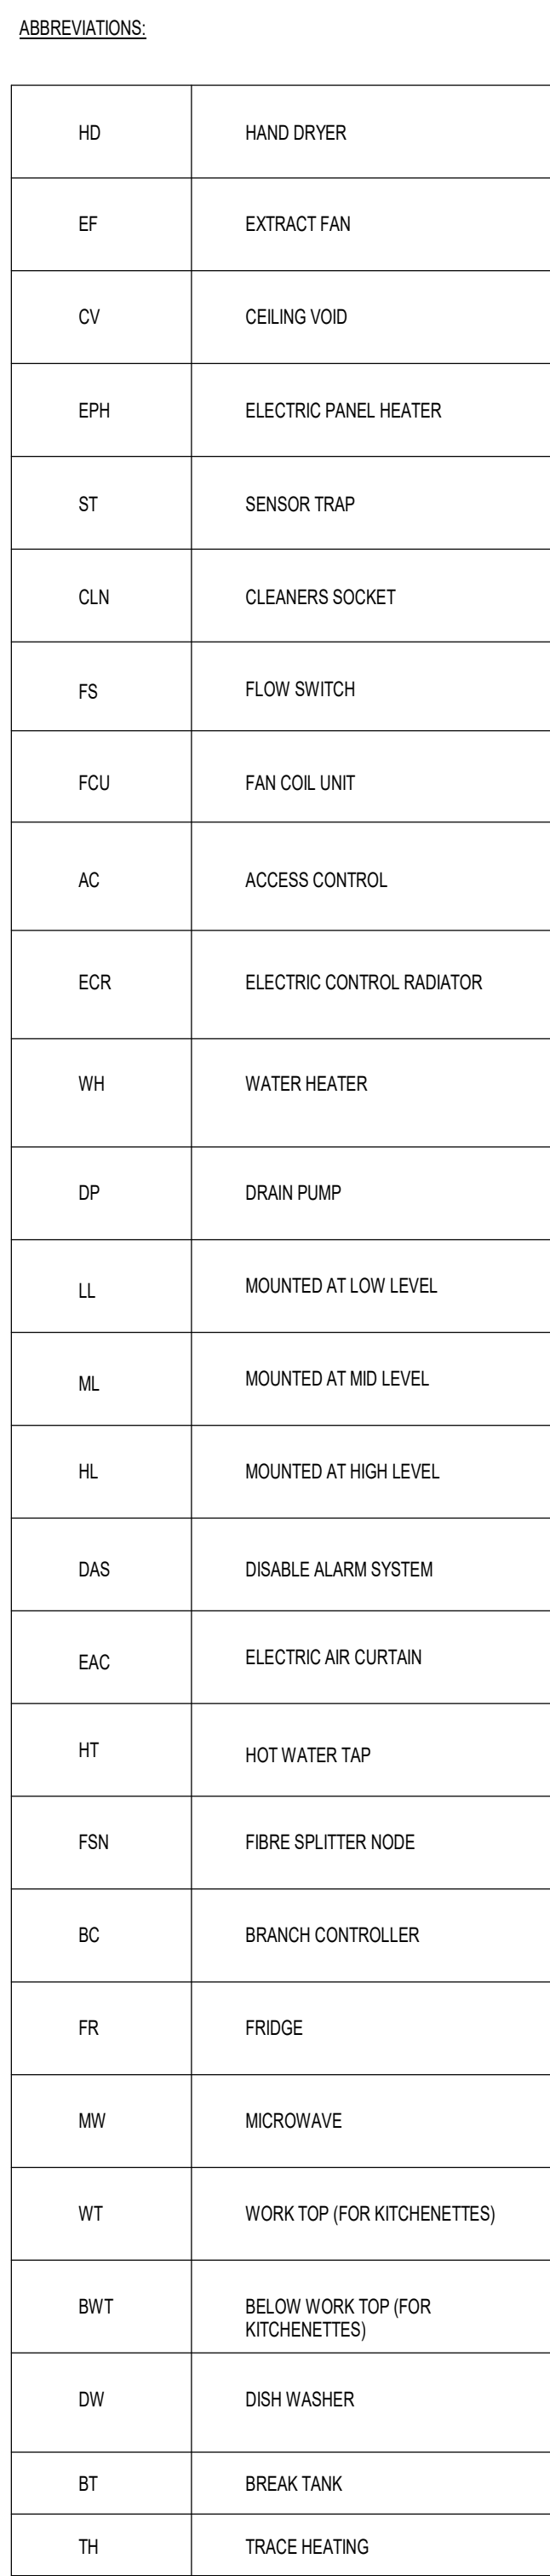

CLIENT	
G&H BUILDING SERVICES	
PROJECT	
SUNLIGHT HOUSE LITTLE QUAY STREET MANCHESTER M3 3HP	
TITLE	
ELECTRICAL SERVICES SMALL POWER AND DATA LAYOUT LEVEL 05	
SCALE B/M: 1:100	CSD REF: CSD 1298
DRAWN: MMV	ENGINEER: DB
STARTED: JUNE 24	ISSUED: NOVEMBER 24
CHECKED: DB	APPROVED: BW
DRAWING NO:	REV:
1298-CSD-XX-05-DR-E-6206	
C01	

ARCHITECTURE IS BASED ON ANOMALY DESIGN
ARCHITECTS DRAWING NO. SLH-ANO-PO-05-DR-A-05105
(C01) LEVEL 05 PLAN
REVISED: 05.08.2024