


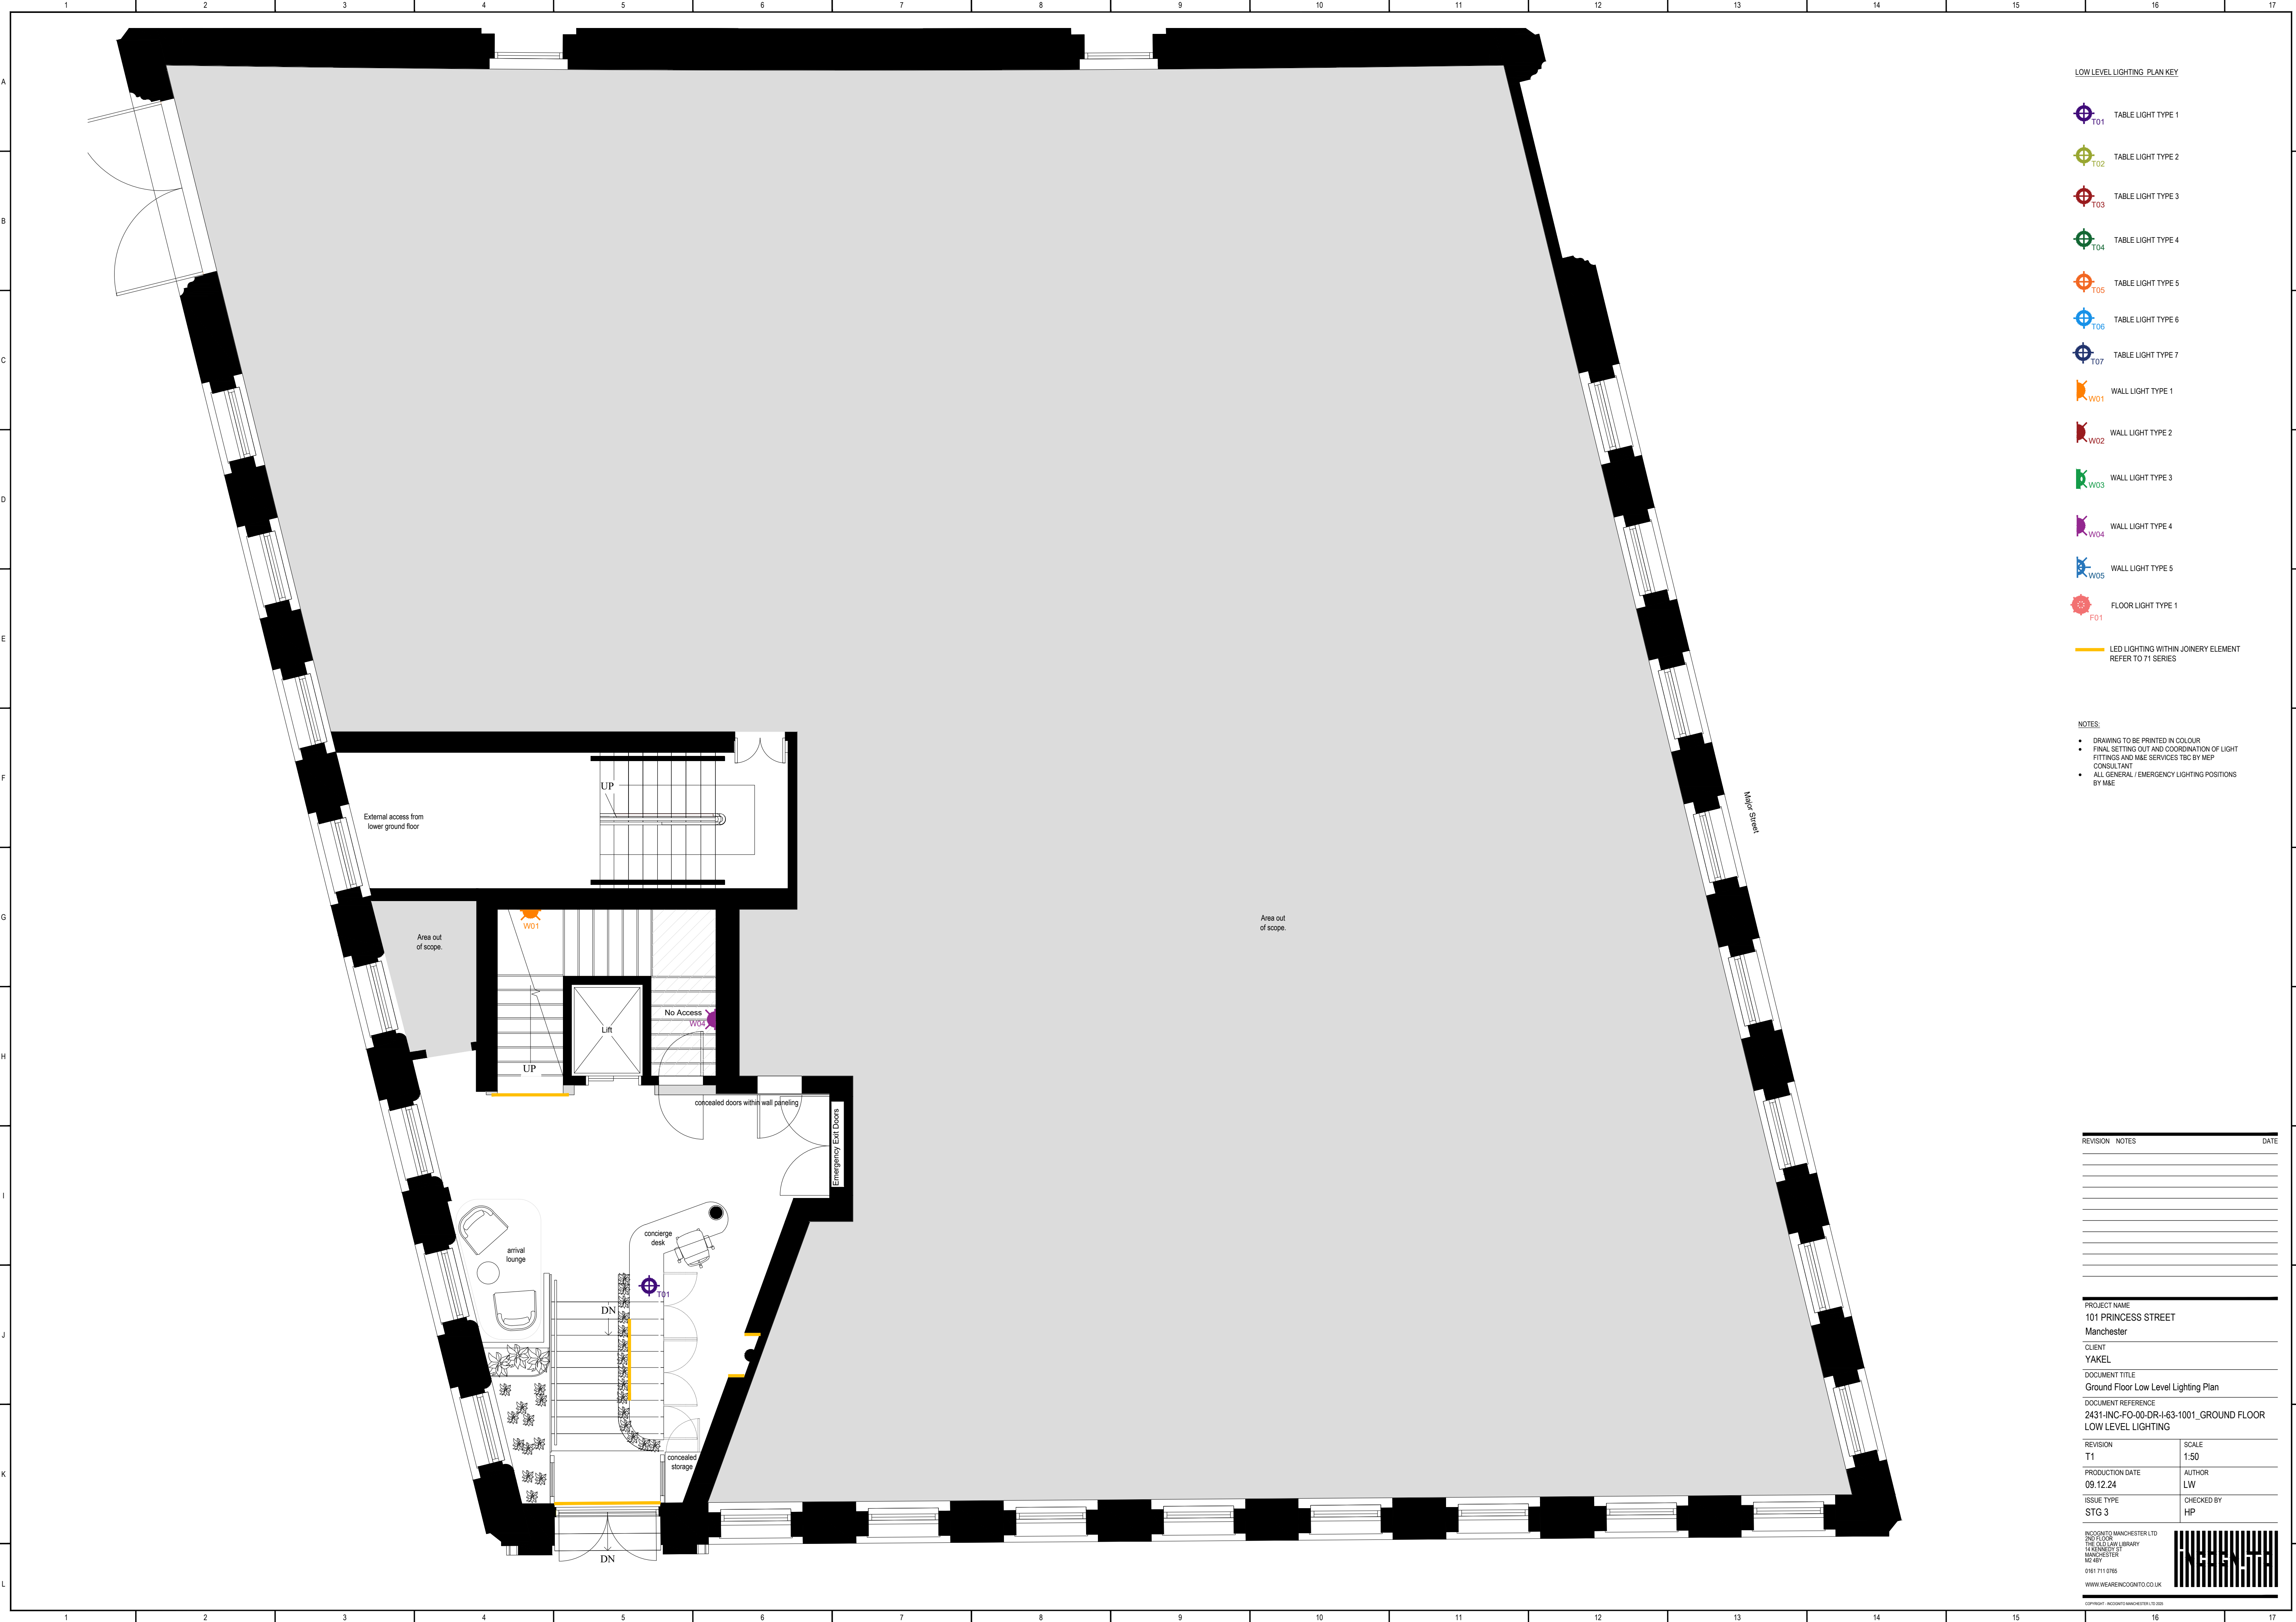

LOW LEVEL LIGHTING PLAN KEY

T01 TABLE LIGHT TYPE 1

T02 TABLE LIGHT TYPE 2

T03 TABLE LIGHT TYPE 3

T04 TABLE LIGHT TYPE 4

T05 TABLE LIGHT TYPE 5

T06 TABLE LIGHT TYPE 6

T07 TABLE LIGHT TYPE 7

W01 WALL LIGHT TYPE 1

W02 WALL LIGHT TYPE 2

W03 WALL LIGHT TYPE 3

W04 WALL LIGHT TYPE 4

W05 WALL LIGHT TYPE 5

F01 FLOOR LIGHT TYPE 1

LED LIGHTING WITHIN JOINERY ELEMENT REFER TO 71 SERIES

NOTES:

- DRAWING TO BE PRINTED IN COLOUR
- FINAL SETTING OUT AND COORDINATION OF LIGHT FITTINGS AND MAE SERVICES TBC BY MEP CONSULTANT
- ALL GENERAL / EMERGENCY LIGHTING POSITIONS BY MAE

REVISION	NOTES	DATE

PROJECT NAME 101 PRINCESS STREET Manchester	
CLIENT YAKEL	
DOCUMENT TITLE Ground Floor Low Level Lighting Plan	
DOCUMENT REFERENCE 2431-INC-FO-00-DR-I-63-1001_GROUND FLOOR LOW LEVEL LIGHTING	
REVISION T1	SCALE 1:50
PRODUCTION DATE 09.12.24	AUTHOR LW
ISSUE TYPE STG 3	CHECKED BY HP
INCognito MANCHESTER LTD 2ND FLOOR THE OLD LAW LIBRARY 14 ROXBURY ST MANCHESTER M2 8BY 0161 711 0785 WWW.WEAREINCognito.CO.UK	
COPYRIGHT © INCognito MANCHESTER LTD 2025	