


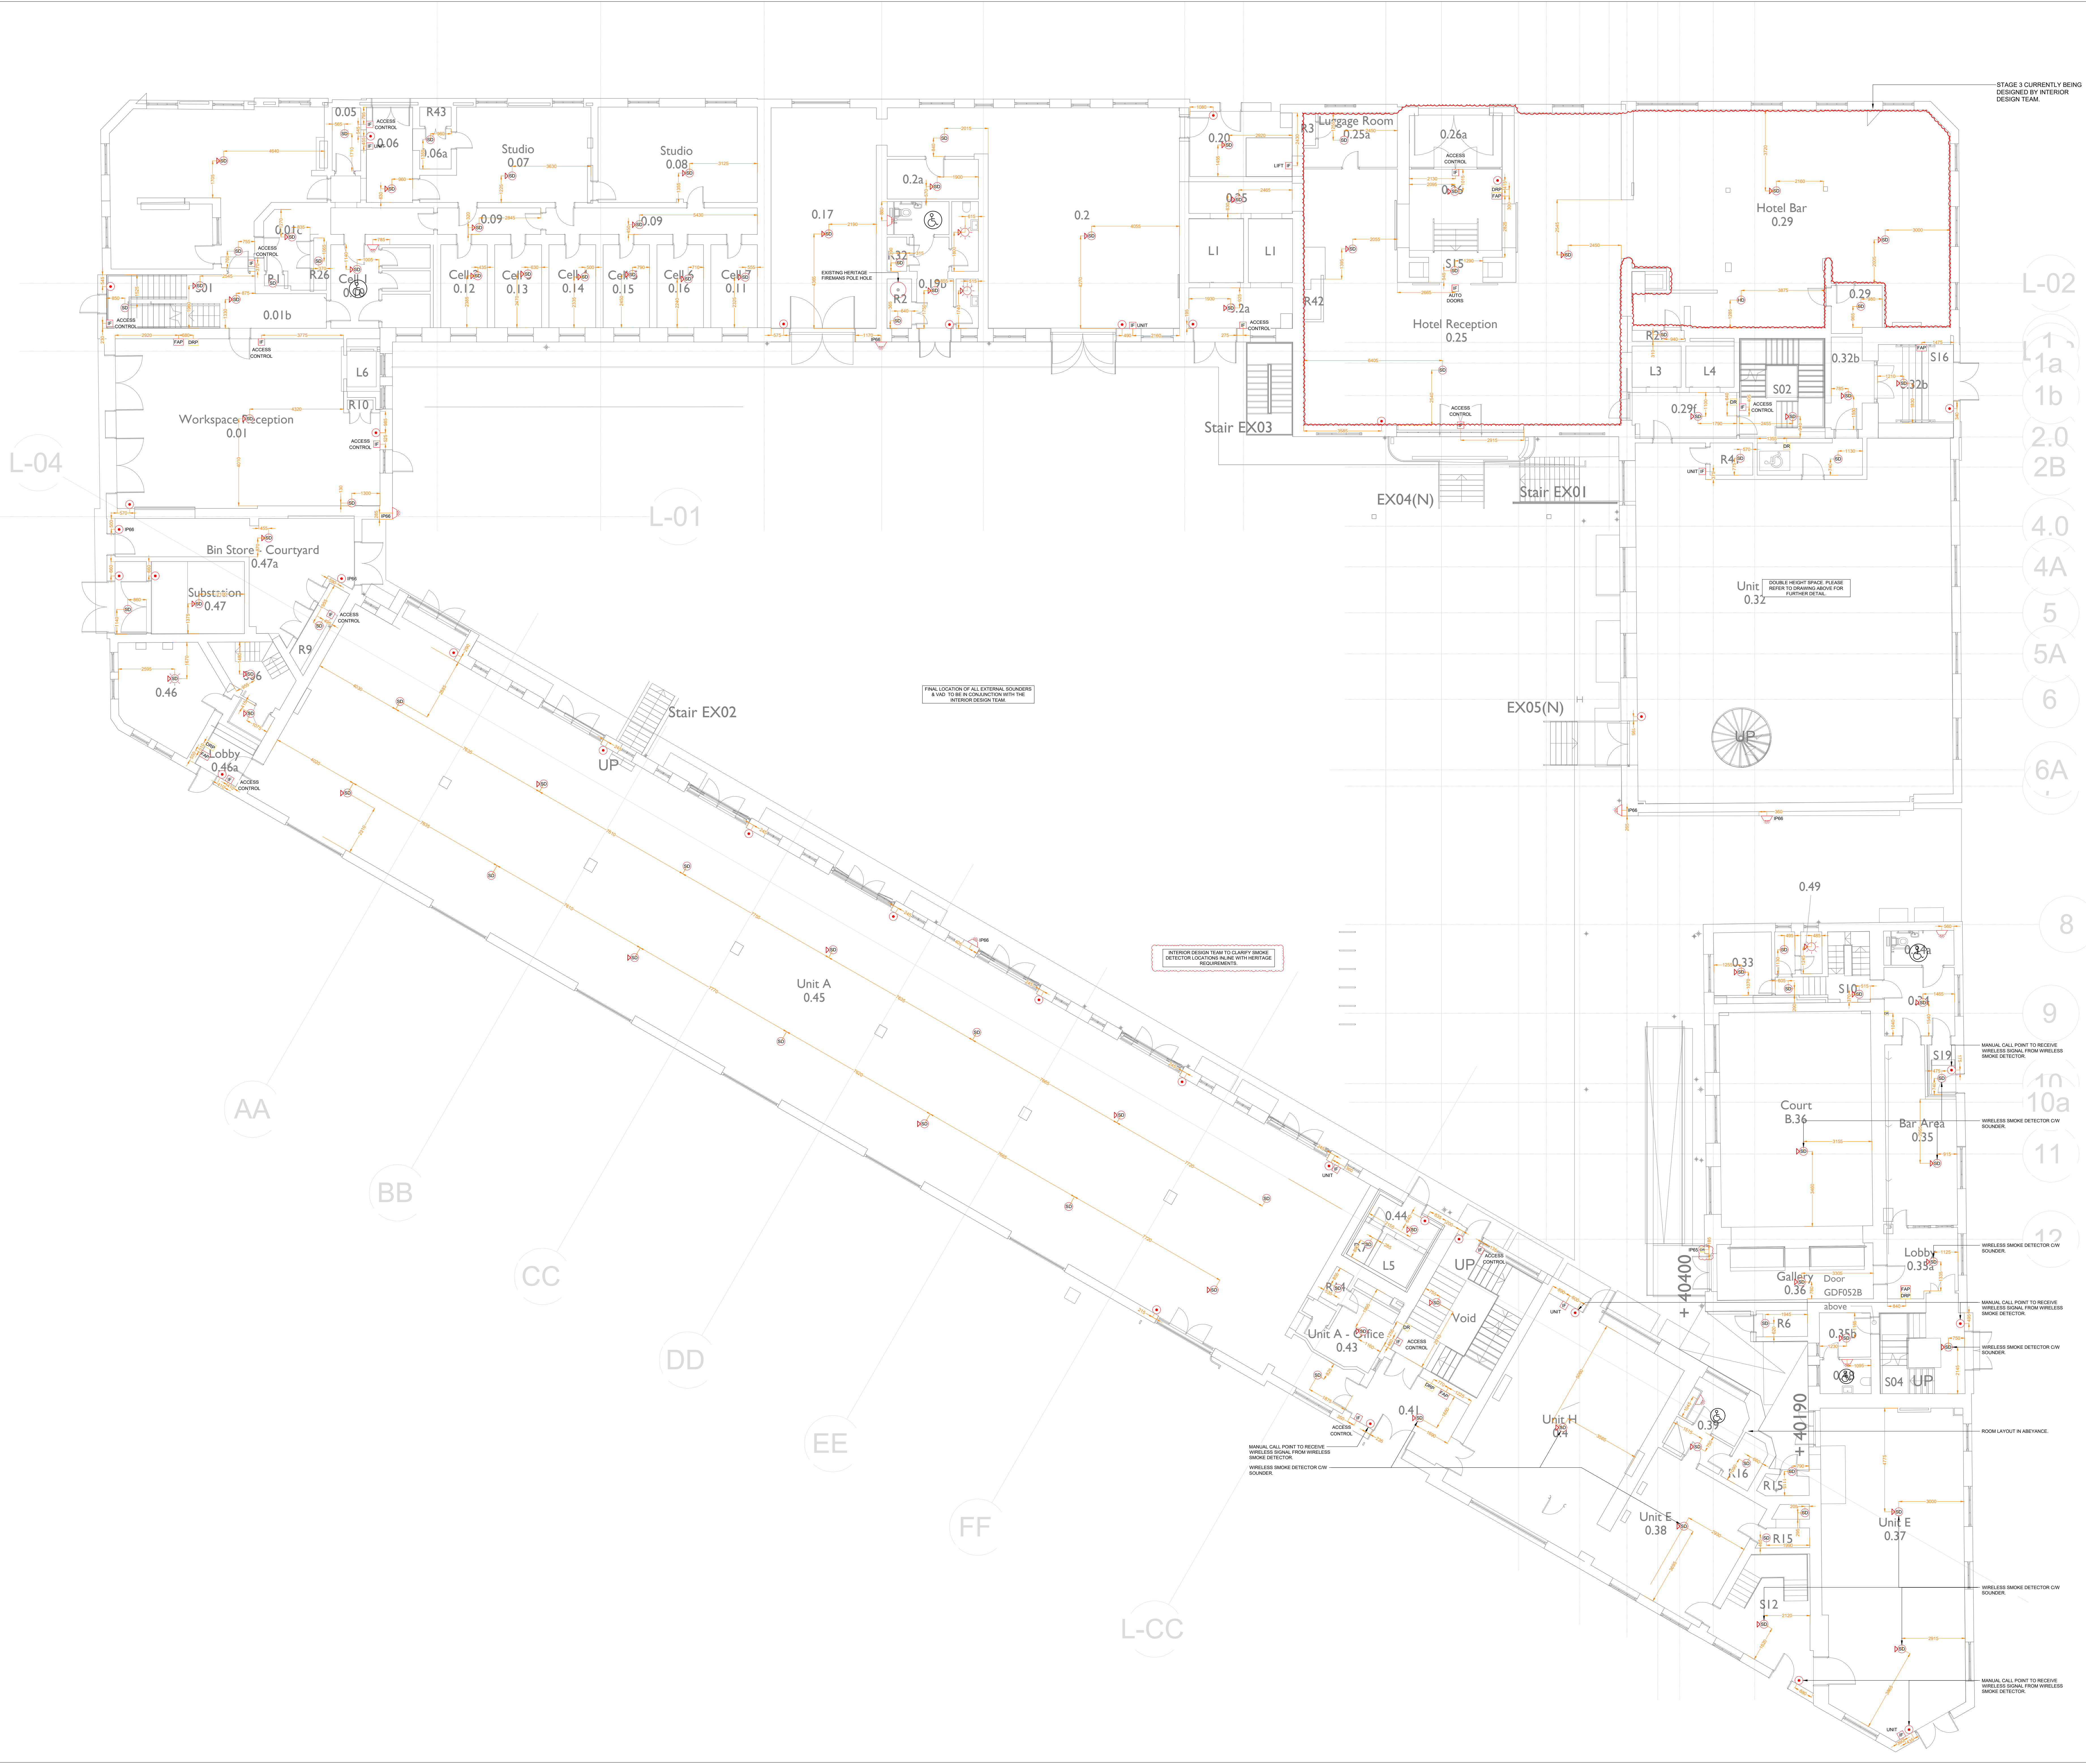

- NOTES
- DO NOT SCALE FROM THIS DRAWING
 - ALL DIMENSIONS TO BE CHECKED ON SITE BY THE CONTRACTOR PRIOR TO PREPARATION OF SHOP DRAWINGS, FABRICATION OF PARTS, ORDERING MATERIALS OR COMMENCING WORKS
 - THIS DRAWING IS TO BE READ IN CONJUNCTION WITH ALL OTHER CONSULTANTS DRAWINGS, SPECIFICATIONS AND SCHEDULES
 - ANY PENETRATION THROUGH FLOOR/WALL/CEILING SEEK STRUCTURAL ENGINEERS APPROVAL BEFORE COMMENCEMENT
 - ALL PLANT AND EQUIPMENT SHALL BE INSTALLED FULLY IN ACCORDANCE WITH MANUFACTURERS RECOMMENDATIONS
 - ANY FURTHER COMMENTS ON THIS DRAWING ARE TO BE MADE ON THE DRAWING ACCOMPANIED BY A CLOUD ADJACENT TO THE COMMENT. THE DRAWING STATUS IS TO BE CLEARLY DETAILED ON DRAWING
- FIRE ALARM NOTES
- THESE DESIGN DRAWINGS SHOW INFORMATION AND DETAILS BASED ON A NON-INTRUSIVE SURVEY ONLY. THE SELECTED FIRE ALARM SPECIALIST SHALL CARRY OUT AN INTRUSIVE DETAILED SURVEY TO PRODUCE THE FINAL DESIGN AND REQUIREMENTS. IN PARTICULAR CONFORMANCE TO THE ROOF VOID SPACES. DEVELOPMENT OF THIS INFORMATION INTO WORKING / INSTALLATION DRAWINGS WILL BE UNDERTAKEN IN CONJUNCTION WITH THE FIRE ALARM SPECIALIST & THE FIRE STRATEGY REPORT. THESE DRAWINGS ARE NOT TO BE RELIED UPON AS SITE INSTALLATION / WORKING DRAWINGS
 - THE FIRE ALARM SPECIALIST TO ENSURE THE FINAL DESIGN IS IN ACCORDANCE WITH THE REQUIREMENTS OF BS 5839 PART 1:2017 CATEGORY 'L1' AND THE FIRE STRATEGY REPORT
 - FINAL CALCULATION OF LOOPS, PANELS AND THE FIRE CAUSE AND EFFECT TO BE PRODUCED BY THE FIRE ALARM SPECIALIST
 - THIS DRAWING SHALL BE READ IN CONJUNCTION WITH THE FIRE ALARM SCHEMATIC
 - WORKSPACE FIRE ALARM INTERFACE UNITS TO BE LOCATED WITHIN THEIR RESPECTIVE WORKSPACE RISERS
 - ALL FIRE ALARM CABLEING WITHIN ALL AREAS AND TO ALL FIRE ALARM DETECTORS SHALL BE CONCEALED WITHIN GALVANISED CONDUIT IN A NEAT FASHION
- FIRE ALARM LEGEND
- FAD FIRE ALARM CONTROL PANEL
 - FAR FIRE ALARM REPEATER PANEL
 - MANUAL CALL POINT
 - SD SMOKE DETECTOR
 - SD SMOKE DETECTOR CW SOUNDER
 - SD SMOKE DETECTOR CW SOUNDER VAD
 - HD HEAT DETECTOR
 - HD HEAT DETECTOR CW SOUNDER
 - HD HEAT DETECTOR CW SOUNDER VAD
 - MS MULTI-SENSOR
 - MS MULTI-SENSOR CW SOUNDER
 - MS MULTI-SENSOR CW SOUNDER VAD
 - IF INTERFACE UNIT
 - WM WALL MOUNTED SOUNDER
 - WM WALL MOUNTED SOUNDER VAD
 - CS CEILING MOUNTED SOUNDER VAD
 - FA FIRE ALARM VAD
 - 4 4 CHANNEL
 - DRP DISABLED REFUGE LEGEND
 - DRP DISABLED REFUGE CONTROL PANEL
 - DRP DISABLED REFUGE INTERCOM
 - DRP DISABLED W/ ALARM TO BE COMPLETE WITH THE FOLLOWING:
 - DISABLED ALARM PANEL
 - CONTROLLER DISABLED ALARM
 - CEILING MOUNTED PULL CORD ALARM WITH HIGH & LOW LEVEL HANDLES
 - DISABLED ALARM OVERDOOR INDICATORS/SOUNDER UNIT
 - DISABLED ALARM EMERGENCY PULL & RESET UNIT
 - WORKING PULL OUTLET C/W WITH VIBRATING FOLLOW IN THE HOTEL ACC BEDROOMS
 - ABBREVIATIONS
 - IP66 WEATHER PROOF

P04	CG	06.03.25	GAS9 UPDATED
P03	JH	06.02.25	REVISED TO SUIT COMMENTS RECEIVED
P02	JH	14.09.24	REISSUED AT (P) STAGE 5 PREVIOUS DRAWINGS SUPERCEDED
P01	SM	18.04.24	REISSUED AT (P) STAGE 5 PREVIOUS DRAWINGS SUPERCEDED

REV	APPR	DATE	DESCRIPTION
Client: ALLIED LONDON			
Project: LONDON ROAD FIRE STATION, LONDON ROAD MANCHESTER, M1			
Drawing Title: ELECTRICAL SERVICES FIRE ALARM LAYOUT GROUND FLOOR			

THIS DRAWING WAS PRODUCED BY AutoCAD - DO NOT CHANGE MANUALLY			
Date	18.04.24	Drawn by	KD
Scale	1:100	Approved by	SM
DES Project No.		Status	S3
Drawing No.	LRFS-CMB-E-00-XX-DR-670 I	Rev.	P04

Copyright is retained by DES and the drawing is issued on the condition that it is not copied either wholly or in part without the written consent of DES Engineering Ltd. All dimensions to be checked on site before commencement of any work or shop drawings. The drawing is to be read in conjunction with the specification when making.



NOTES

- DO NOT SCALE FROM THIS DRAWING.
- ALL DIMENSIONS TO BE CHECKED ON SITE BY THE CONTRACTOR PRIOR TO PREPARATION OF SHOP DRAWINGS, FABRICATION OF PARTS, ORDERING MATERIALS OR COMMENCING WORKS.
- THIS DRAWING IS TO BE READ IN CONJUNCTION WITH ALL OTHER CONSULTANTS DRAWINGS, SPECIFICATIONS AND SCHEDULES.
- ANY PENETRATION THROUGH FLOOR/WALL/CILING SEEK STRUCTURAL ENGINEERS APPROVAL BEFORE COMMENCEMENT.
- ALL PLANT AND EQUIPMENT SHALL BE INSTALLED FULLY IN ACCORDANCE WITH MANUFACTURERS RECOMMENDATIONS.
- ALL FURTHER COMMENTS ON THIS DRAWING ARE TO BE MADE ON THE DRAWING ACCOMPANIED BY A CLOUD ADJACENT TO THE COMMENT. THE DRAWING STATUS IS TO BE CLEARLY DETAILED ON DRAWING.

FIRE ALARM NOTES

- THESE DESIGN DRAWINGS SHOW INFORMATION AND DETAILS BASED ON A NON-INTRUSIVE SURVEY ONLY. THE SELECTED FIRE ALARM SPECIALIST SHALL CARRY OUT AN INTRUSIVE DETAILED SURVEY TO PRODUCE THE FINAL DESIGN AND REQUIREMENTS. IN PARTICULAR CONFORMANCE TO THE ROOF VOID SPACES. DEVELOPMENT OF THIS INFORMATION INTO WORKING / INSTALLATION DRAWINGS WILL BE UNDERTAKEN IN CONJUNCTION WITH THE FIRE ALARM SPECIALIST & THE FIRE STRATEGY REPORT. THESE DRAWINGS ARE NOT TO BE RELIED UPON AS SITE INSTALLATION / WORKING DRAWINGS.
- THE FIRE ALARM SPECIALIST TO ENSURE THE FINAL DESIGN IS IN ACCORDANCE WITH THE REQUIREMENTS OF BS 5839 PART 1:2017 CATEGORY 'L1' AND THE FIRE STRATEGY REPORT.
- FINAL CALCULATION OF LOOPS, PANELS AND THE FIRE CAUSE AND EFFECT TO BE PRODUCED BY THE FIRE ALARM SPECIALIST.
- THIS DRAWING SHALL BE READ IN CONJUNCTION WITH THE FIRE ALARM SCHEMATIC.
- WORKSPACE FIRE ALARM INTERFACE UNITS TO BE LOCATED WITHIN THEIR RESPECTIVE WORKSPACE RISERS.
- ALL FIRE ALARM CABLING WITHIN ALL AREAS AND TO ALL FIRE ALARM DETECTORS SHALL BE CONCEALED WITHIN GALVANISED CONDUIT IN A NEAT FASHION.

FIRE ALARM LEGEND

FAS FIRE ALARM CONTROL PANEL
FAR FIRE ALARM REPEATER PANEL
MANUAL CALL POINT
SD SMOKE DETECTOR
SD SMOKE DETECTOR C/W SOUNDER
HD HEAT DETECTOR
HD HEAT DETECTOR C/W SOUNDER
HD HEAT DETECTOR C/W SOUNDER VAD
MS MULTI-SENSOR
MS MULTI-SENSOR C/W SOUNDER
MS MULTI-SENSOR C/W SOUNDER VAD
IF INTERFACE UNIT
WALL MOUNTED SOUNDER
WALL MOUNTED SOUNDER VAD
CEILING MOUNTED SOUNDER VAD
FIRE ALARM VAD
4 CHANNEL
DISABLED REFUGE LEGEND
DRP DISABLED REFUGE CONTROL PANEL
DRP DISABLED REFUGE INTERCOM
DISABLED WC ALARM TO BE COMPLETE WITH THE FOLLOWING:
• DISABLED ALARM PANEL
• CONTROLLER DISABLED ALARM
• CEILING MOUNTED PULL CORD ALARM WITH HIGH & LOW LEVEL HANDLES
• DISABLED ALARM OVERDOOR INDICATOR/SOUNDER UNIT
• DISABLED ALARM EMERGENCY PULL & RESET UNIT
• VIBRATING FLOW OUTLET C/W WITH VIBRATING PLOW IN THE HOTEL ACC BEDROOMS

ABBREVIATIONS
IP68 - WEATHER PROOF

P04	CG	06.03.25	GAS UPDATED
P03	JH	04.03.25	REISSUED AT (P) STAGE 5 PREVIOUS DRAWINGS SUPERCEDED
P02	JH	14.08.24	REISSUED AT (P) STAGE 5 PREVIOUS DRAWINGS SUPERCEDED
P01	SM	16.04.24	REISSUED AT (P) STAGE 5 PREVIOUS DRAWINGS SUPERCEDED
REV	APPR	DATE	DESCRIPTION

Client
ALLIED LONDON

Project
LONDON ROAD FIRE STATION
FIRE STATION, LONDON ROAD
MANCHESTER, M1

Drawing Title
ELECTRICAL SERVICES
FIRE ALARM LAYOUT
FIRST FLOOR

THIS DRAWING WAS PRODUCED BY AutoCAD - DO NOT CHANGE MANUALLY

Date	16.04.24	Drawn by	KD
Scale	1:100	Approved by	SM
DES Project No.		Status	SS
Drawing No.	LF5-CMB-E-01-XX-DR-6701	Rev.	P04

Copyright is reserved by DES and this drawing is created on the condition that it is not copied, altered, copied or in part without the written consent of DES Electrical Contractors LTD. All rights are reserved. No part of this drawing may be reproduced, stored in a retrieval system, or transmitted in any form or by any means, electronic, mechanical, photocopying, recording, or by any information storage or retrieval system, without the prior written permission of DES Electrical Contractors LTD. This drawing is to be read in conjunction with the specification and drawings.



- NOTES
1. DO NOT SCALE FROM THIS DRAWING.
 2. ALL DIMENSIONS TO BE CHECKED ON SITE BY THE CONTRACTOR PRIOR TO PREPARATION OF SHOP DRAWINGS, FABRICATION OF PARTS, ORDERING MATERIALS OR COMMENCING WORKS.
 3. THIS DRAWING IS TO BE READ IN CONJUNCTION WITH ALL OTHER CONSULTANTS DRAWINGS, SPECIFICATIONS AND SCHEDULES.
 4. ANY PENETRATION THROUGH FLOOR/WALL/CILING SEEK STRUCTURAL ENGINEERS APPROVAL BEFORE COMMENCEMENT.
 5. ALL PLANT AND EQUIPMENT SHALL BE INSTALLED FULLY IN ACCORDANCE WITH MANUFACTURER'S RECOMMENDATIONS.
 6. ALL FURTHER COMMENTS ON THIS DRAWING ARE TO BE MADE ON THE DRAWING ACCOMPANIED BY A CLOUD ADJACENT TO THE COMMENT. THE DRAWING STATUS IS TO BE CLEARLY DETAILED ON DRAWING.
- FIRE ALARM NOTES
1. THESE DESIGN DRAWINGS SHOW INFORMATION AND DETAILS BASED ON A NON-INTRUSIVE SURVEY ONLY. THE SELECTED FIRE ALARM SPECIALIST SHALL CARRY OUT AN INTRUSIVE DETAILED SURVEY TO PRODUCE THE FINAL DESIGN AND REQUIREMENTS. IN PARTICULAR CONSIDERANCE TO THE ROOF VOID SPACES. DEVELOPMENT OF THIS INFORMATION INTO WORKING / INSTALLATION DRAWINGS WILL BE UNDERTAKEN IN CONJUNCTION WITH THE FIRE ALARM SPECIALIST & THE FIRE STRATEGY REPORT. THESE DRAWINGS ARE NOT TO BE RELIED UPON AS SITE INSTALLATION / WORKING DRAWINGS.
 2. THE FIRE ALARM SPECIALIST TO ENSURE THE FINAL DESIGN IS IN ACCORDANCE WITH THE REQUIREMENTS OF BS 5839 PART 1:2017 CATEGORY 'L1' AND THE FIRE STRATEGY REPORT.
 3. FINAL CALCULATION OF LOOPS, PANELS AND THE FIRE CAUSE AND EFFECT TO BE PRODUCED BY THE FIRE ALARM SPECIALIST.
 4. THIS DRAWING SHALL BE READ IN CONJUNCTION WITH THE FIRE ALARM SCHEMATIC.
 5. WORKSPACE FIRE ALARM INTERFACE UNITS TO BE LOCATED WITHIN THEIR RESPECTIVE WORKSPACE RISERS.
 6. ALL FIRE ALARM CABLING WITHIN ALL AREAS AND TO ALL FIRE ALARM DETECTORS SHALL BE CONCEALED WITHIN GALVANISED CONDUIT IN A NEAT FASHION.
- FIRE ALARM LEGEND
- FASD FIRE ALARM CONTROL PANEL
 - FAR FIRE ALARM REPEATER PANEL
 - MANUAL CALL POINT
 - SD SMOKE DETECTOR
 - SD SMOKE DETECTOR C/W SOUNDER
 - HD HEAT DETECTOR
 - HD HEAT DETECTOR C/W SOUNDER
 - HD HEAT DETECTOR C/W SOUNDER VAD
 - MS MULTI-SENSOR
 - MS MULTI-SENSOR C/W SOUNDER
 - MS MULTI-SENSOR C/W SOUNDER VAD
 - IF INTERFACE UNIT
 - WALL MOUNTED SOUNDER
 - WALL MOUNTED SOUNDER VAD
 - CEILING MOUNTED SOUNDER VAD
 - FIRE ALARM VAD
 - 4 CHANNEL
 - DISABLED REFUGE LEGEND
 - DRP DISABLED REFUGE CONTROL PANEL
 - DRP DISABLED REFUGE INTERCOM
 - DISABLED WC ALARM TO BE COMPLETE WITH THE FOLLOWING:
 - DISABLED ALARM PANEL
 - CONTROLLER DISABLED ALARM
 - CEILING MOUNTED PULL CORD ALARM WITH HIGH & LOW LEVEL HANDLES
 - DISABLED ALARM OVERDOOR INDICATOR/SOUNDER UNIT
 - DISABLED ALARM EMERGENCY PULL & RESET UNIT
 - VIBRATING PULL OUTLET C/W WITH VIBRATING PULL IN THE HOTEL ACC BEDROOMS
 - ABBREVIATIONS
 - IP68 - WEATHER PROOF

P04	CG	06.03.25	GAS UPDATED
P03	JH	04.03.25	REISSUED AT (P) STAGE 5 PREVIOUS DRAWINGS SUPERCEDED
P02	JH	14.08.24	REISSUED AT (P) STAGE 5 PREVIOUS DRAWINGS SUPERCEDED
P01	SM	12.04.24	REISSUED AT (P) STAGE 5 PREVIOUS DRAWINGS SUPERCEDED

REV	APPR	DATE	DESCRIPTION
Client			ALLIED LONDON


Project
LONDON ROAD FIRE STATION
FIRE STATION, LONDON ROAD
MANCHESTER, M1

Drawing Title
ELECTRICAL SERVICES
FIRE ALARM LAYOUT
SECOND FLOOR



THIS DRAWING WAS PRODUCED BY AutoCAD - DO NOT CHANGE MANUALLY			
Date	12.04.24	Drawn by	KD
Scale	1:100	Approved by	SM
DES Project No.		Status	SS
Drawing No.	LF5-CMB-E-02-XX-DR-6701	Rev.	P04

Copyright is reserved by DES and the drawing is created on the condition that it is not copied or altered in any way or in part without the written consent of DES. The drawing is created on the condition that it is not copied or altered in any way or in part without the written consent of DES. The drawing is created on the condition that it is not copied or altered in any way or in part without the written consent of DES. The drawing is created on the condition that it is not copied or altered in any way or in part without the written consent of DES.

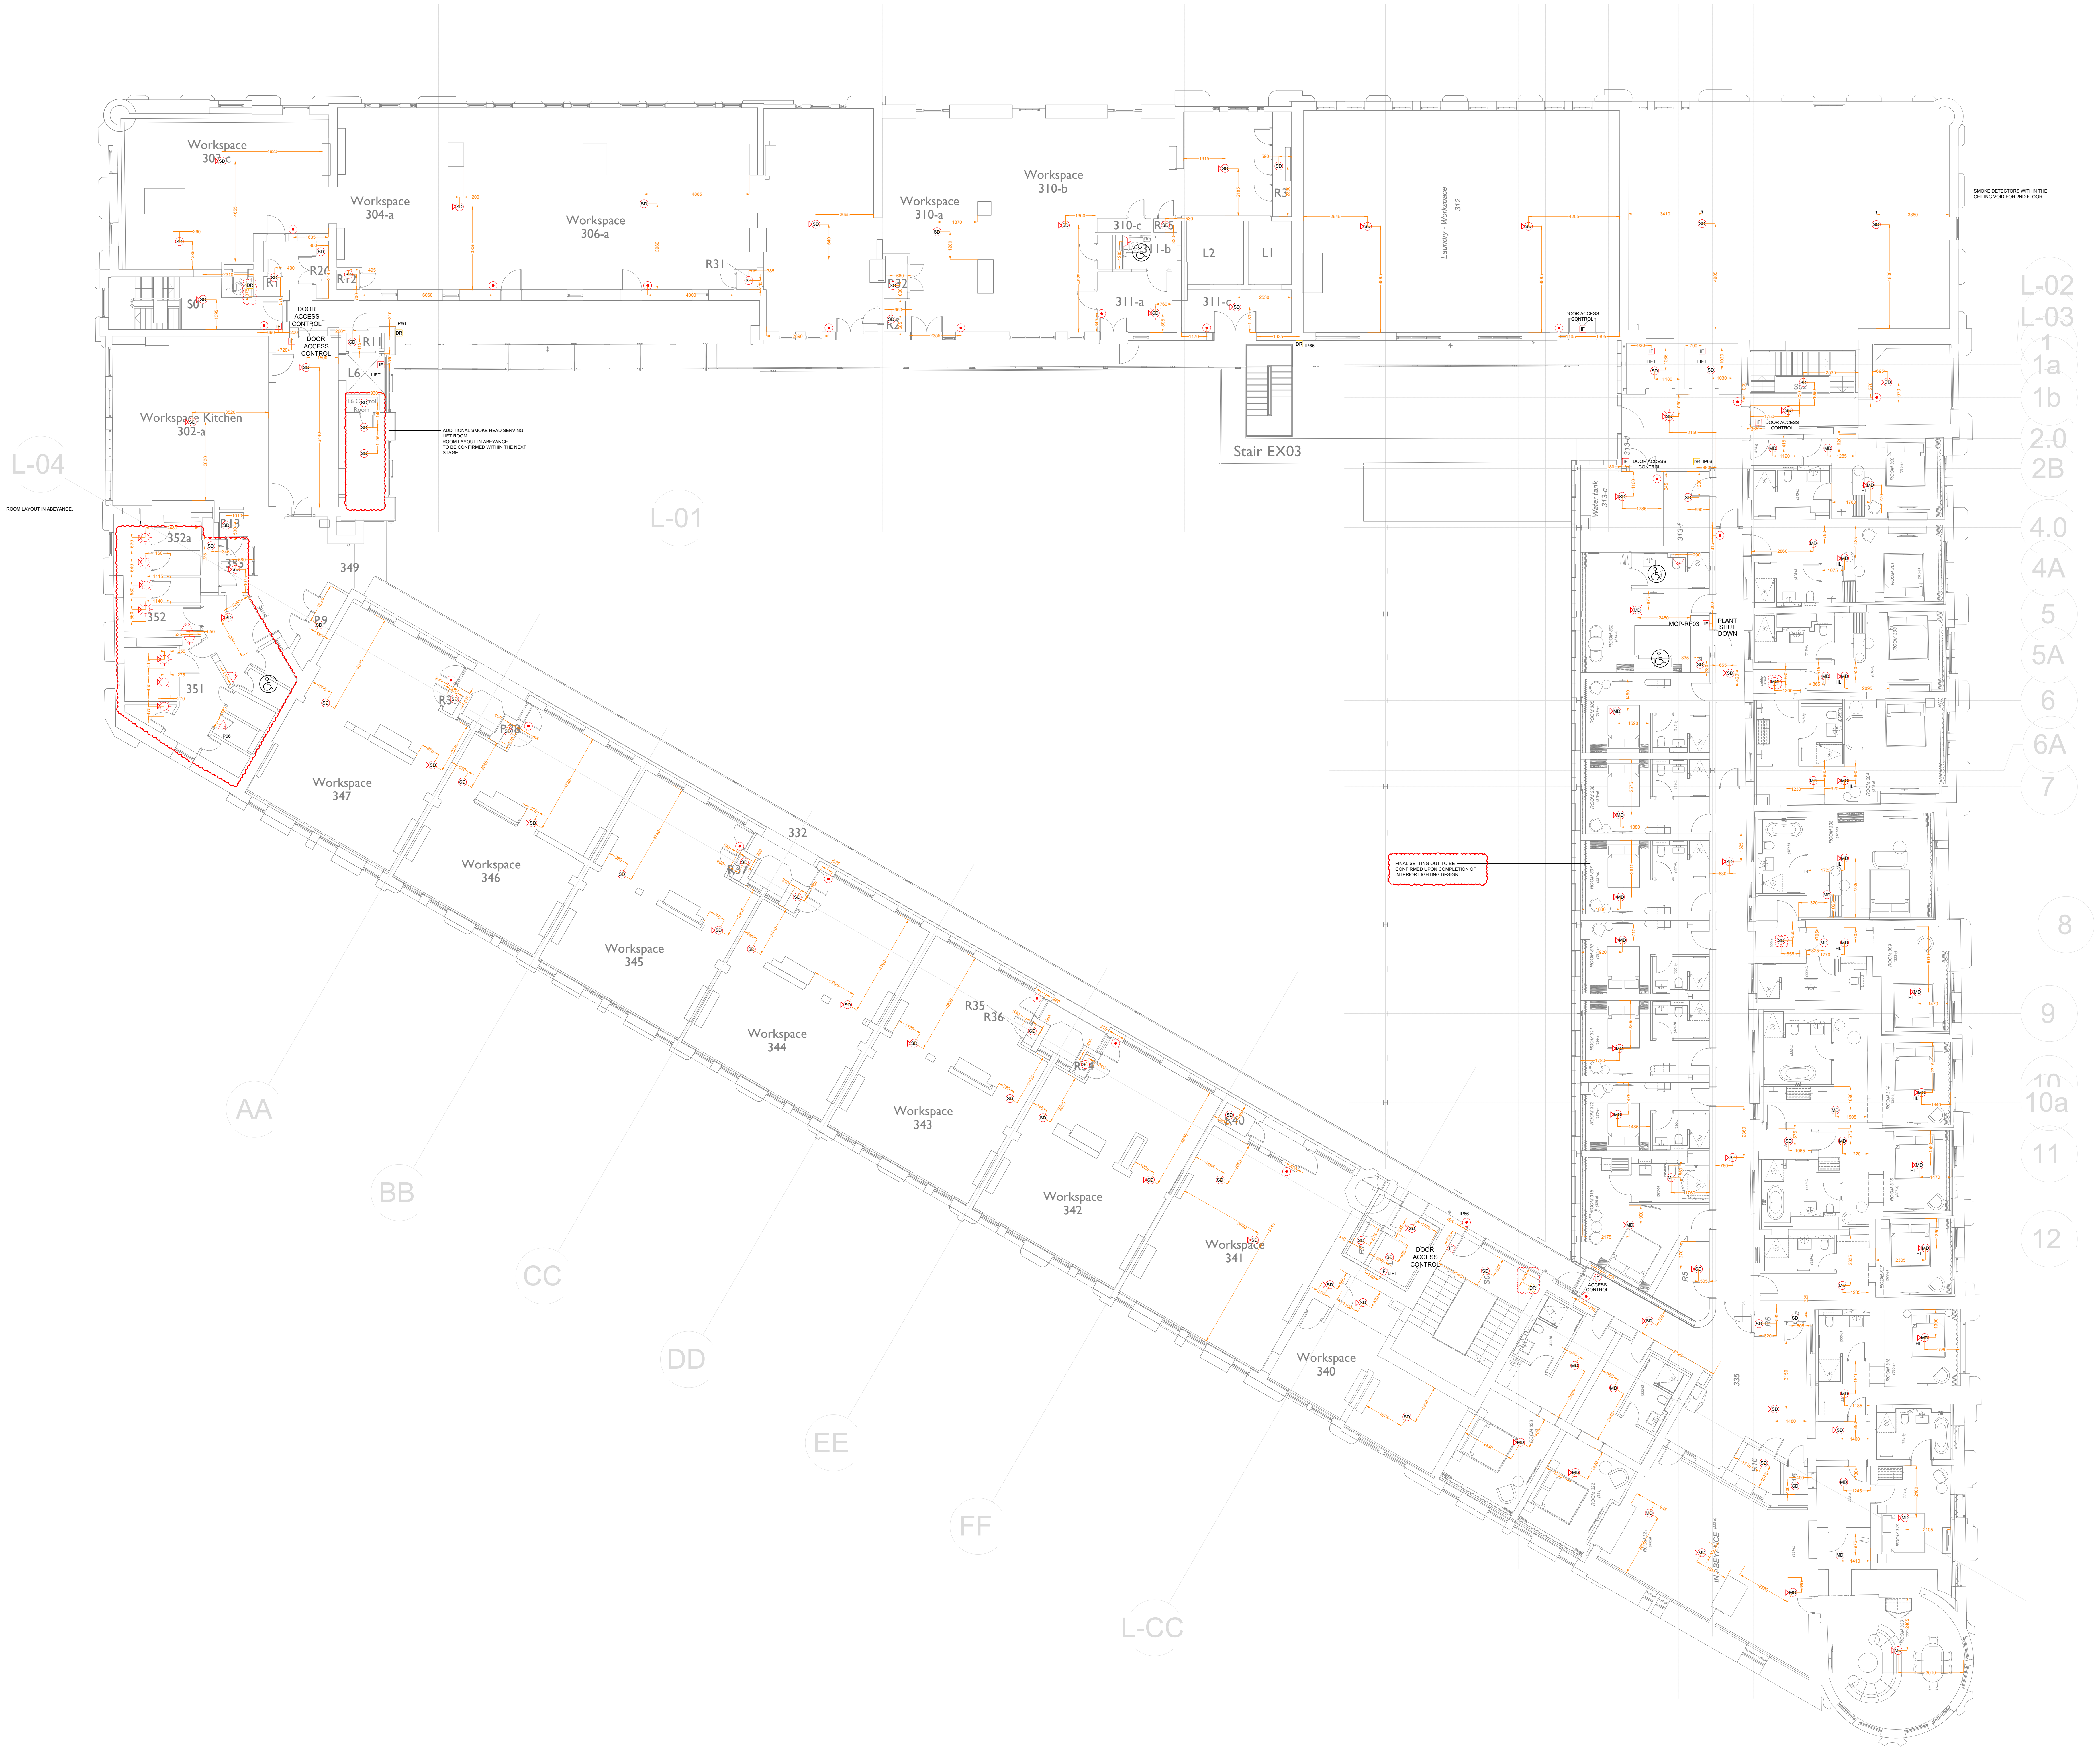

- NOTES
- DO NOT SCALE FROM THIS DRAWING.
 - ALL DIMENSIONS TO BE CHECKED ON SITE BY THE CONTRACTOR PRIOR TO PREPARATION OF SHOP DRAWINGS, FABRICATION OF PARTS, ORDERING MATERIALS OR COMMENCING WORKS.
 - THIS DRAWING IS TO BE READ IN CONJUNCTION WITH ALL OTHER CONSULTANTS DRAWINGS, SPECIFICATIONS AND SCHEDULES.
 - ANY PENETRATION THROUGH FLOOR/WALL/CILING SEEK STRUCTURAL ENGINEERS APPROVAL BEFORE COMMENCEMENT.
 - ALL PLANT AND EQUIPMENT SHALL BE INSTALLED FULLY IN ACCORDANCE WITH MANUFACTURER'S RECOMMENDATIONS.
 - ALL FURTHER COMMENTS ON THIS DRAWING ARE TO BE MADE ON THE DRAWING ACCOMPANIED BY A CLOUD ADJACENT TO THE COMMENT. THE DRAWING STATUS IS TO BE CLEARLY DETAILED ON DRAWING.
- FIRE ALARM NOTES
- THESE DESIGN DRAWINGS SHOW INFORMATION AND DETAILS BASED ON A NON-INTRUSIVE SURVEY ONLY. THE SELECTED FIRE ALARM SPECIALIST SHALL CARRY OUT AN INTRUSIVE DETAILED SURVEY TO PRODUCE THE FINAL DESIGN AND REQUIREMENTS. IN PARTICULAR CONFORMANCE TO THE ROOF VOID SPACES. DEVELOPMENT OF THIS INFORMATION INTO WORKING / INSTALLATION DRAWINGS WILL BE UNDERTAKEN IN CONJUNCTION WITH THE FIRE ALARM SPECIALIST & THE FIRE STRATEGY REPORT. THESE DRAWINGS ARE NOT TO BE RELIED UPON AS SITE INSTALLATION / WORKING DRAWINGS.
 - THE FIRE ALARM SPECIALIST TO ENSURE THE FINAL DESIGN IS IN ACCORDANCE WITH THE REQUIREMENTS OF BS 5839 PART 1:2017 CATEGORY 'L1' AND THE FIRE STRATEGY REPORT.
 - FINAL CALCULATION OF LOOPS, PANELS AND THE FIRE CAUSE AND EFFECT TO BE PRODUCED BY THE FIRE ALARM SPECIALIST.
 - THIS DRAWING SHALL BE READ IN CONJUNCTION WITH THE FIRE ALARM SCHEMATIC.
 - WORKSPACE FIRE ALARM INTERFACE UNITS TO BE LOCATED WITHIN THEIR RESPECTIVE WORKSPACE RISERS.
 - ALL FIRE ALARM CABLING WITHIN ALL AREAS AND TO ALL FIRE ALARM DETECTORS SHALL BE CONCEALED WITHIN GALVANISED CONDUIT IN A NEAT FASHION.
- FIRE ALARM LEGEND
- FAS FIRE ALARM CONTROL PANEL
 - FAR FIRE ALARM REPEATER PANEL
 - MANUAL CALL POINT
 - SD SMOKE DETECTOR
 - SD SMOKE DETECTOR C/W SOUNDER VAD
 - HD HEAT DETECTOR
 - HD HEAT DETECTOR C/W SOUNDER VAD
 - HD HEAT DETECTOR C/W SOUNDER VAD
 - MS MULTI-SENSOR
 - MS MULTI-SENSOR C/W SOUNDER
 - MS MULTI-SENSOR C/W SOUNDER VAD
 - IF INTERFACE UNIT
 - WALL MOUNTED SOUNDER
 - CEILING MOUNTED SOUNDER VAD
 - CEILING MOUNTED SOUNDER VAD
 - 4 CHANNEL
 - 4 CHANNEL
 - DISABLED REFUGE LEGEND
 - DRP DISABLED REFUGE CONTROL PANEL
 - DRP DISABLED REFUGE INTERCOM
 - DISABLED WC ALARM TO BE COMPLETE WITH THE FOLLOWING:
 - DISABLED ALARM PANEL
 - CONTROLLER DISABLED ALARM
 - CEILING MOUNTED PULL CORD ALARM WITH HIGH & LOW LEVEL HANDLES
 - DISABLED ALARM OVERDOOR INDICATOR/SOUNDER UNIT
 - DISABLED ALARM EMERGENCY PULL & RESET UNIT
 - VIBRATING PULL OUTLET C/W WITH VIBRATING PULL IN THE HOTEL ACC BEDROOMS
 - ABBREVIATIONS
 - IP68 - WEATHER PROOF

P04	CG	06.03.25	GAS UPDATED
P03	JH	04.03.25	REISSUED AT (P) STAGE 5 PREVIOUS DRAWINGS SUPERCEDED
P02	JH	14.08.24	REISSUED AT (P) STAGE 5 PREVIOUS DRAWINGS SUPERCEDED
P01	SM	11.04.24	REISSUED AT (P) STAGE 5 PREVIOUS DRAWINGS SUPERCEDED
REV	APPR	DATE	DESCRIPTION

Client
ALLIED LONDON


Project
LONDON ROAD FIRE STATION
FIRE STATION, LONDON ROAD
MANCHESTER, M1

Drawing Title
ELECTRICAL SERVICES
FIRE ALARM LAYOUT
THIRD FLOOR



THIS DRAWING WAS PRODUCED BY AUTOCAD - DO NOT CHANGE MANUALLY			
Date	11.04.24	Drawn by	KD
Scale	1:100	Approved by	SM
DES Project No.		Status	SS
Drawing No.	LF5-CMB-E-03-XX-DR-6701	Rev.	P04

Copyright is reserved by DES and this drawing is created on the condition that it is not copied or otherwise used in any part without the express written consent of DES. All rights are reserved. All dimensions to be checked on site before commencement of any work or shop drawings. This drawing is to be read in conjunction with the specification and other drawings.

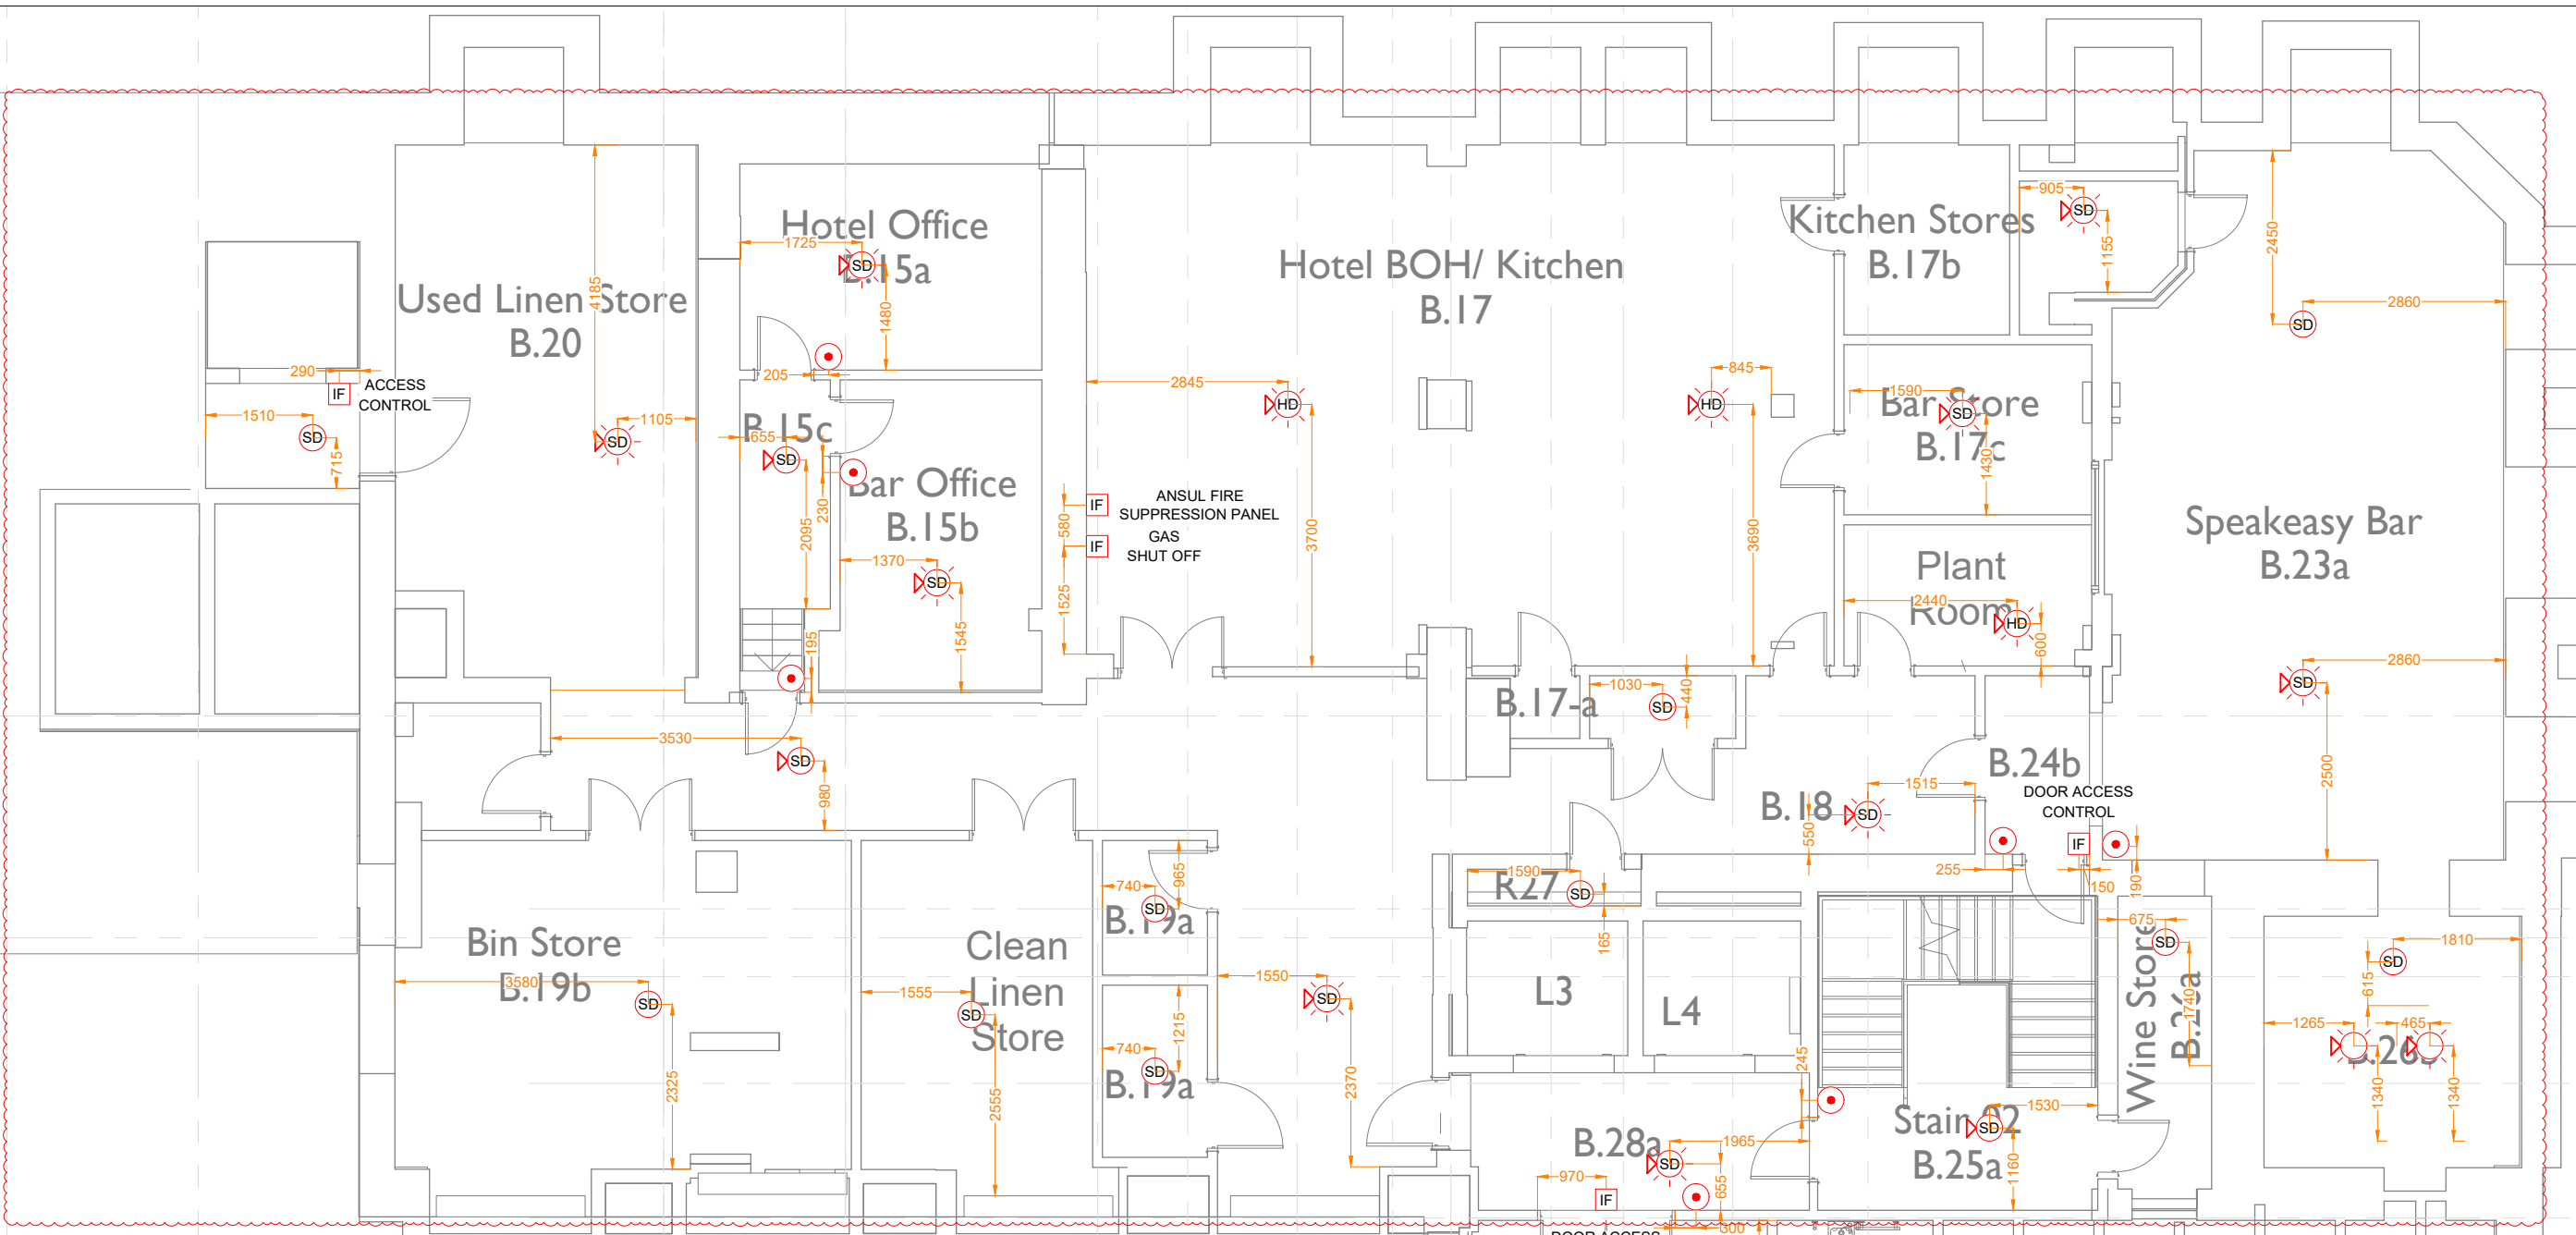

- | | | | | |
|---|----------|----------|---|-------------|
| P04 | CG | 06.03.25 | GAS UPDATED | |
| P03 | JH | 04.03.25 | REISSUED AT (P) STAGE 5
PREVIOUS DRAWINGS SUPERCEDED | |
| P02 | JH | 14.08.24 | REISSUED AT (P) STAGE 5
PREVIOUS DRAWINGS SUPERCEDED | |
| P01 | SM | 19.04.24 | REISSUED AT (P) STAGE 5
PREVIOUS DRAWINGS SUPERCEDED | |
| REV | APPR. | DATE | DESCRIPTION | |
| Client
ALLIED LONDON | | | | |
| Project
LONDON ROAD FIRE STATION
FIRE STATION, LONDON ROAD
MANCHESTER, M1 | | | | |
| Drawing Title
ELECTRICAL SERVICES
FIRE ALARM LAYOUT
BASEMENT LEVEL | | | | |
|  | | | | |
|  | | | | |
| THIS DRAWING WAS PRODUCED BY AUTOCAD - DO NOT CHANGE MANUALLY | | | | |
| Date | 19.04.24 | | Drawn by | KD |
| Scale | 1 : 100 | | Approved by | SM |
| DES Project No. | | | Status | 53 |
| Drawing No.
LRF5-CMB-E-B1-XX-DR-6701 | | | | Rev.
P04 |
- Copyright is reserved by DES and the drawing is issued on the condition that it is not copied either wholly or in part without the consent in writing of DES Electrical Contractors Ltd Ltd. Further permission to take preference over those holding. All drawings to be checked on site before construction of any work on shop drawings.
This drawing is to be read in conjunction with the specification when existing.

