

DO NOT SCALE FROM THIS DRAWING.
ALL DIMENSIONS TO BE CHECKED ON SITE.
(DRAWINGS MAYBE SCALED FOR LOCAL AUTHORITY & PLANNING PURPOSE ONLY)
COPYRIGHT PROTECTED.

 



FOR PLANNING
DO NOT USE FOR CONSTRUCTION

CONSULTANT REFERENCES IN DRAWING:

STRUCTURAL - REF/REVISION

KEY

NEW CONDENSERS

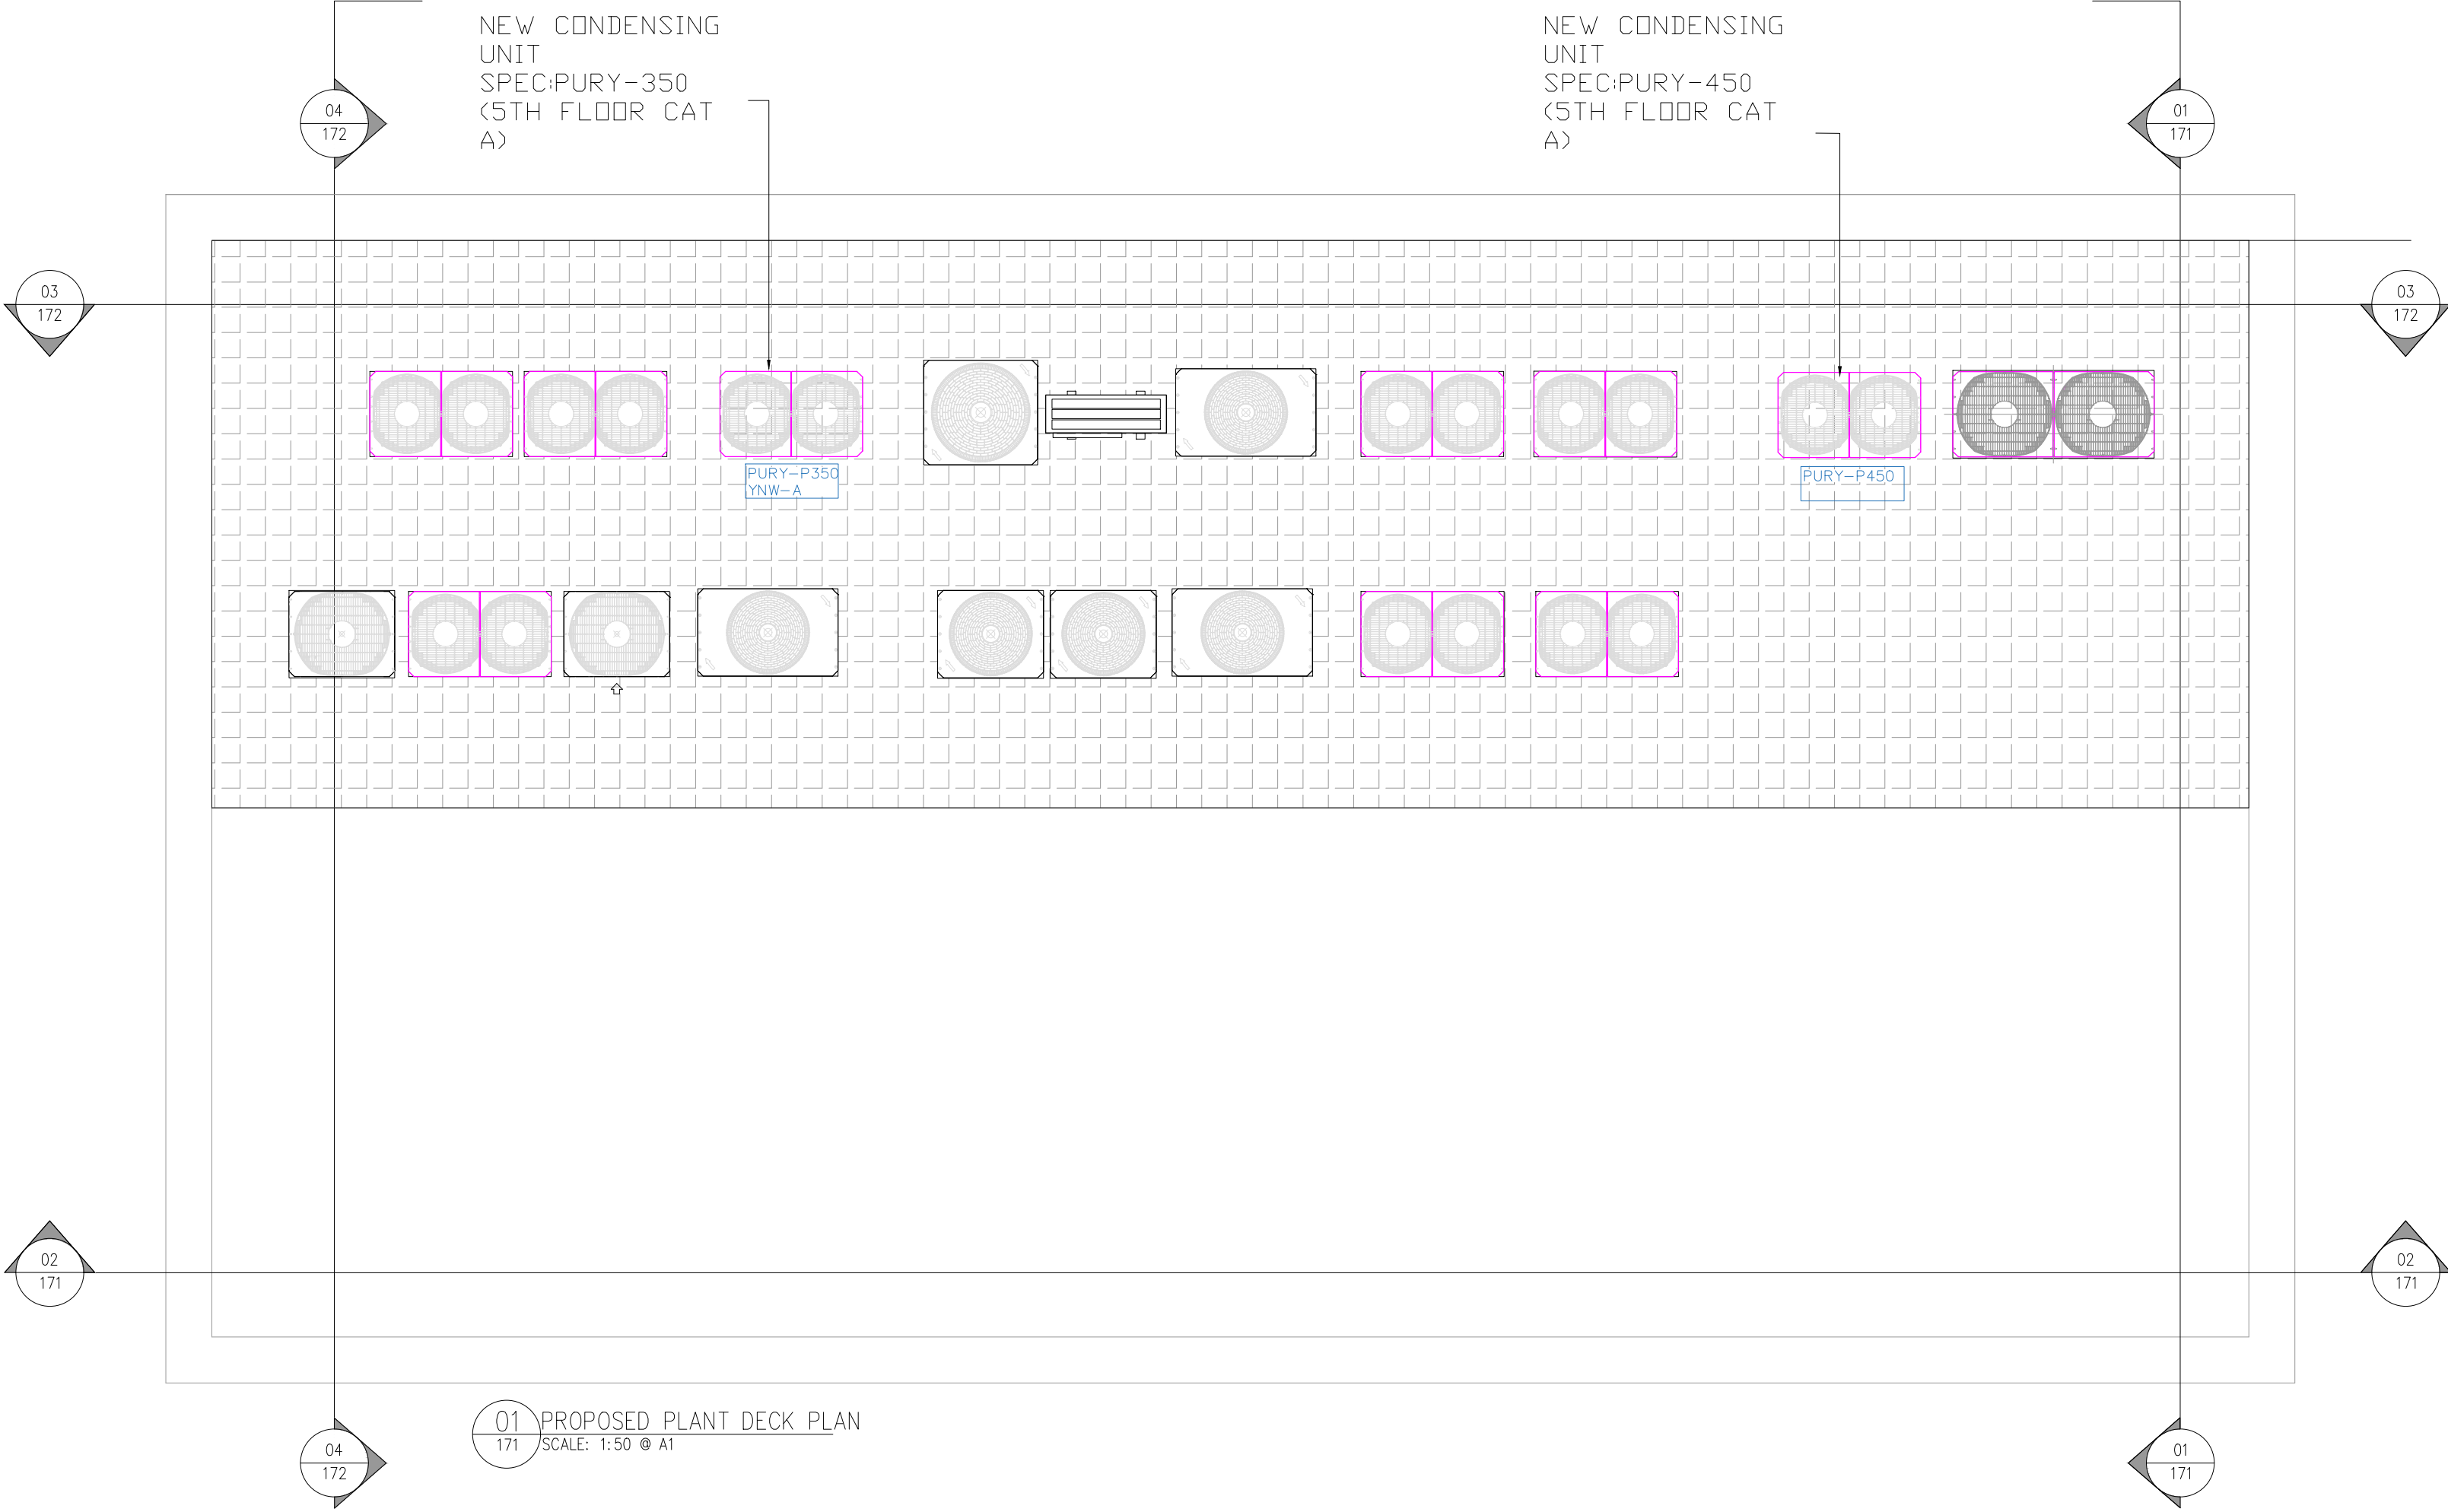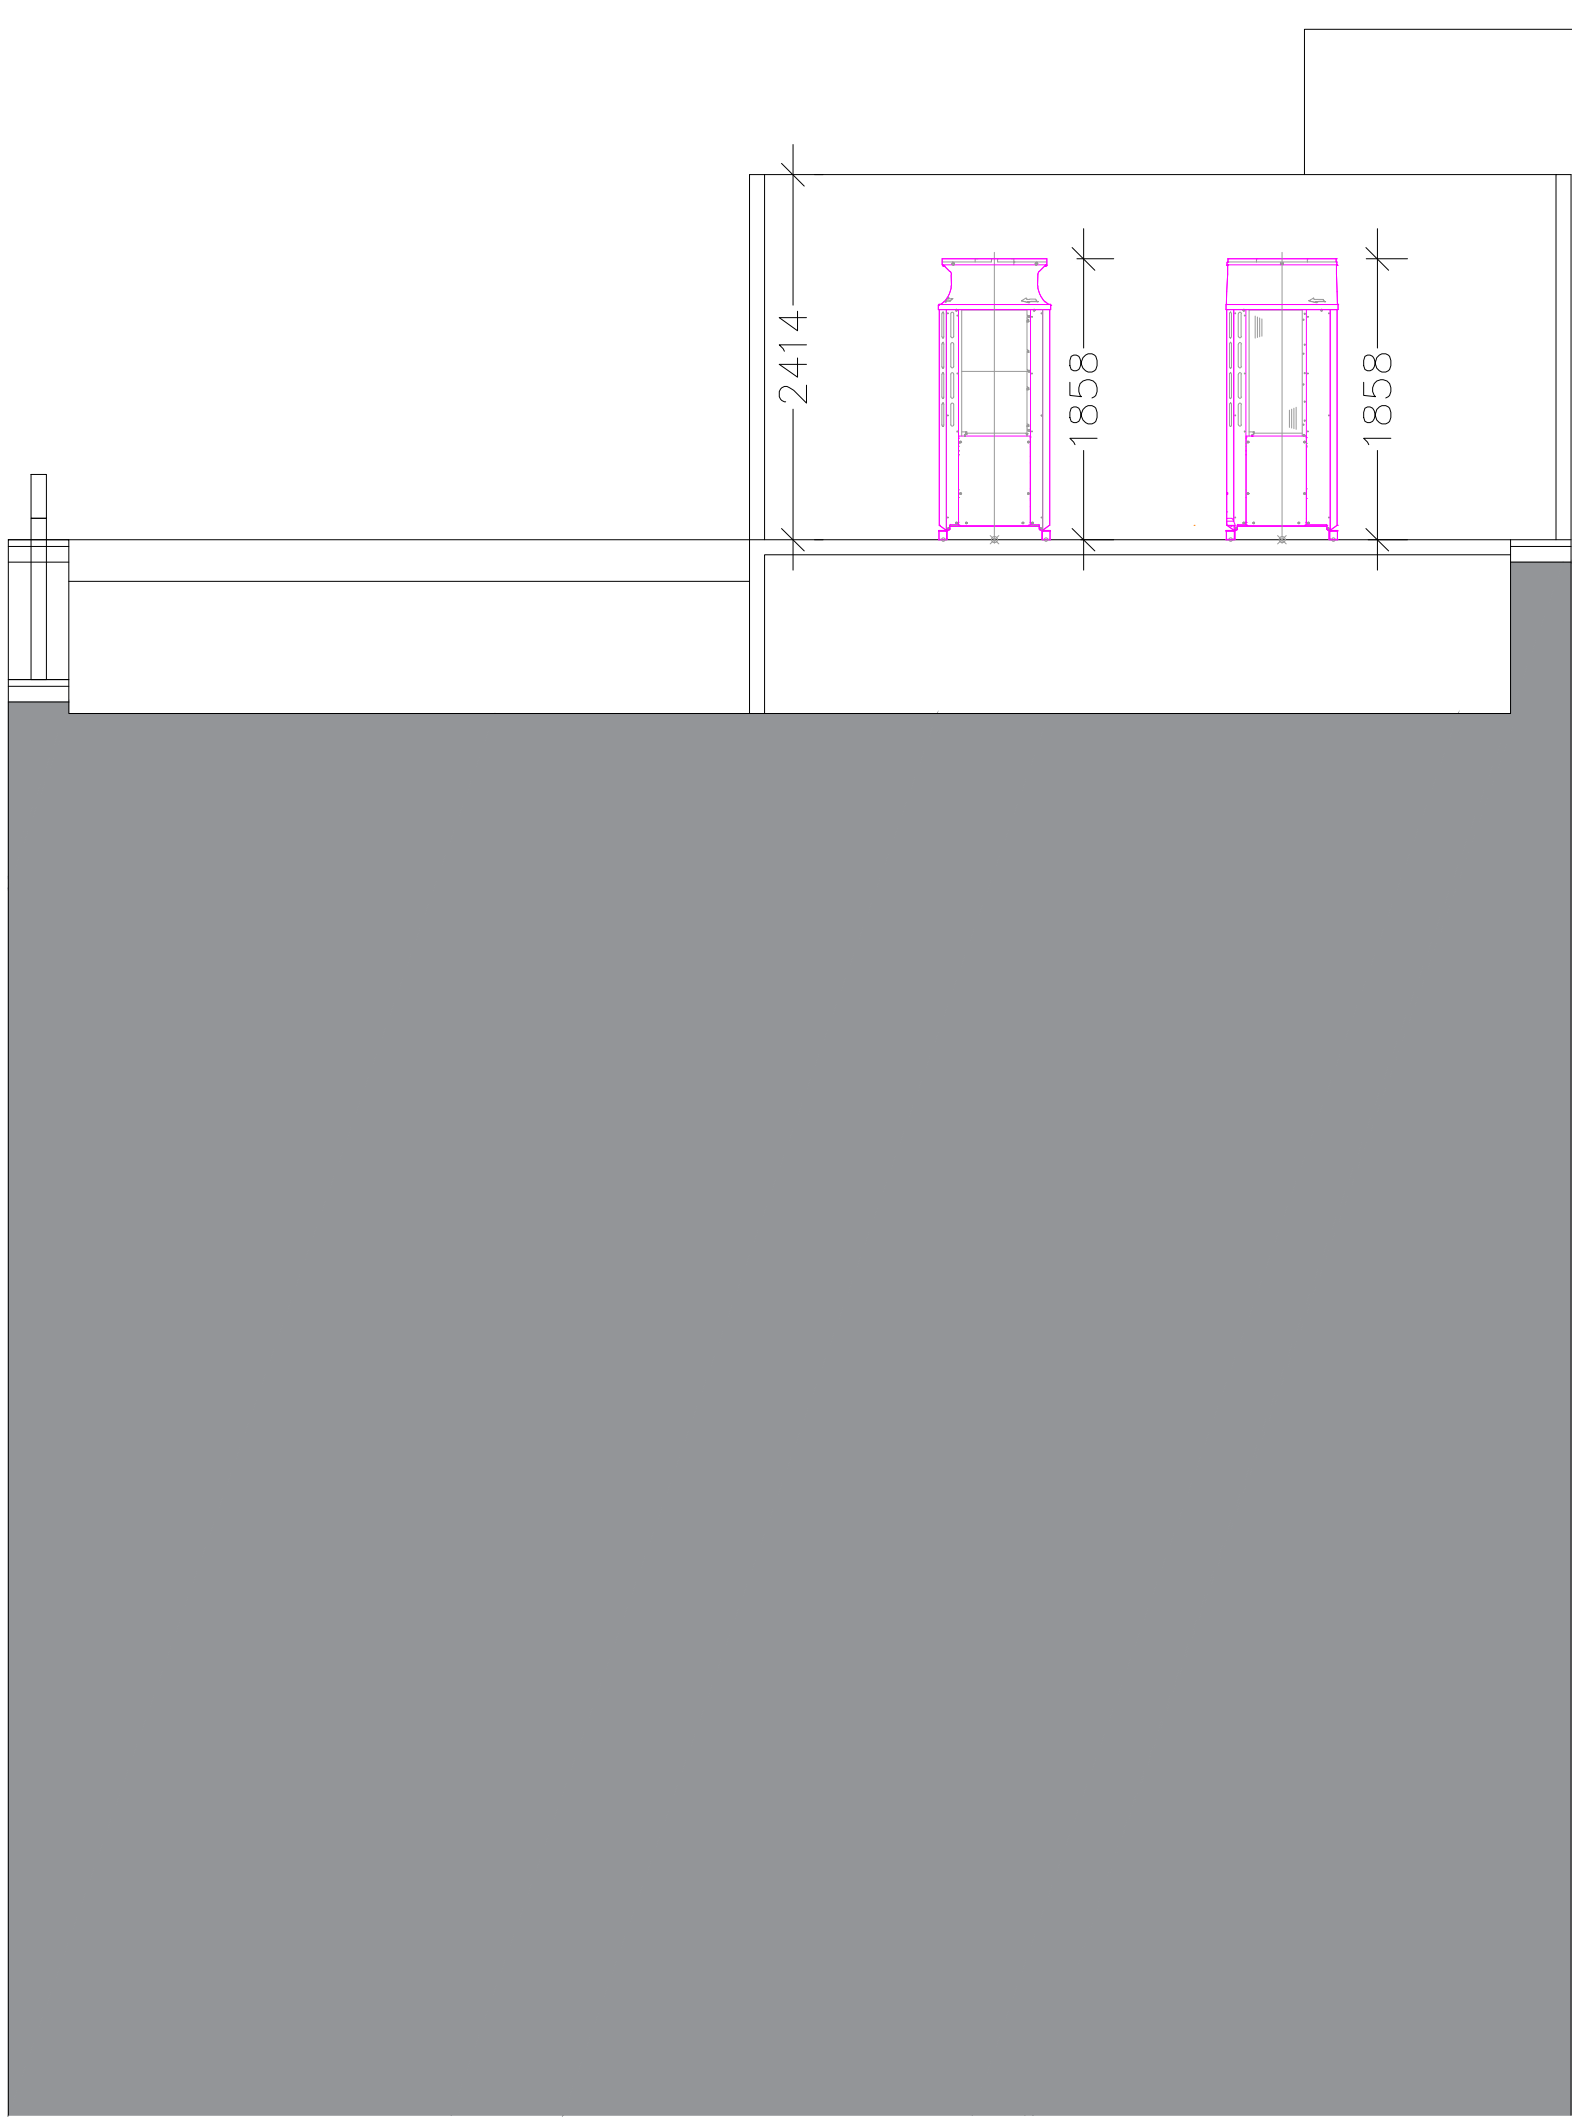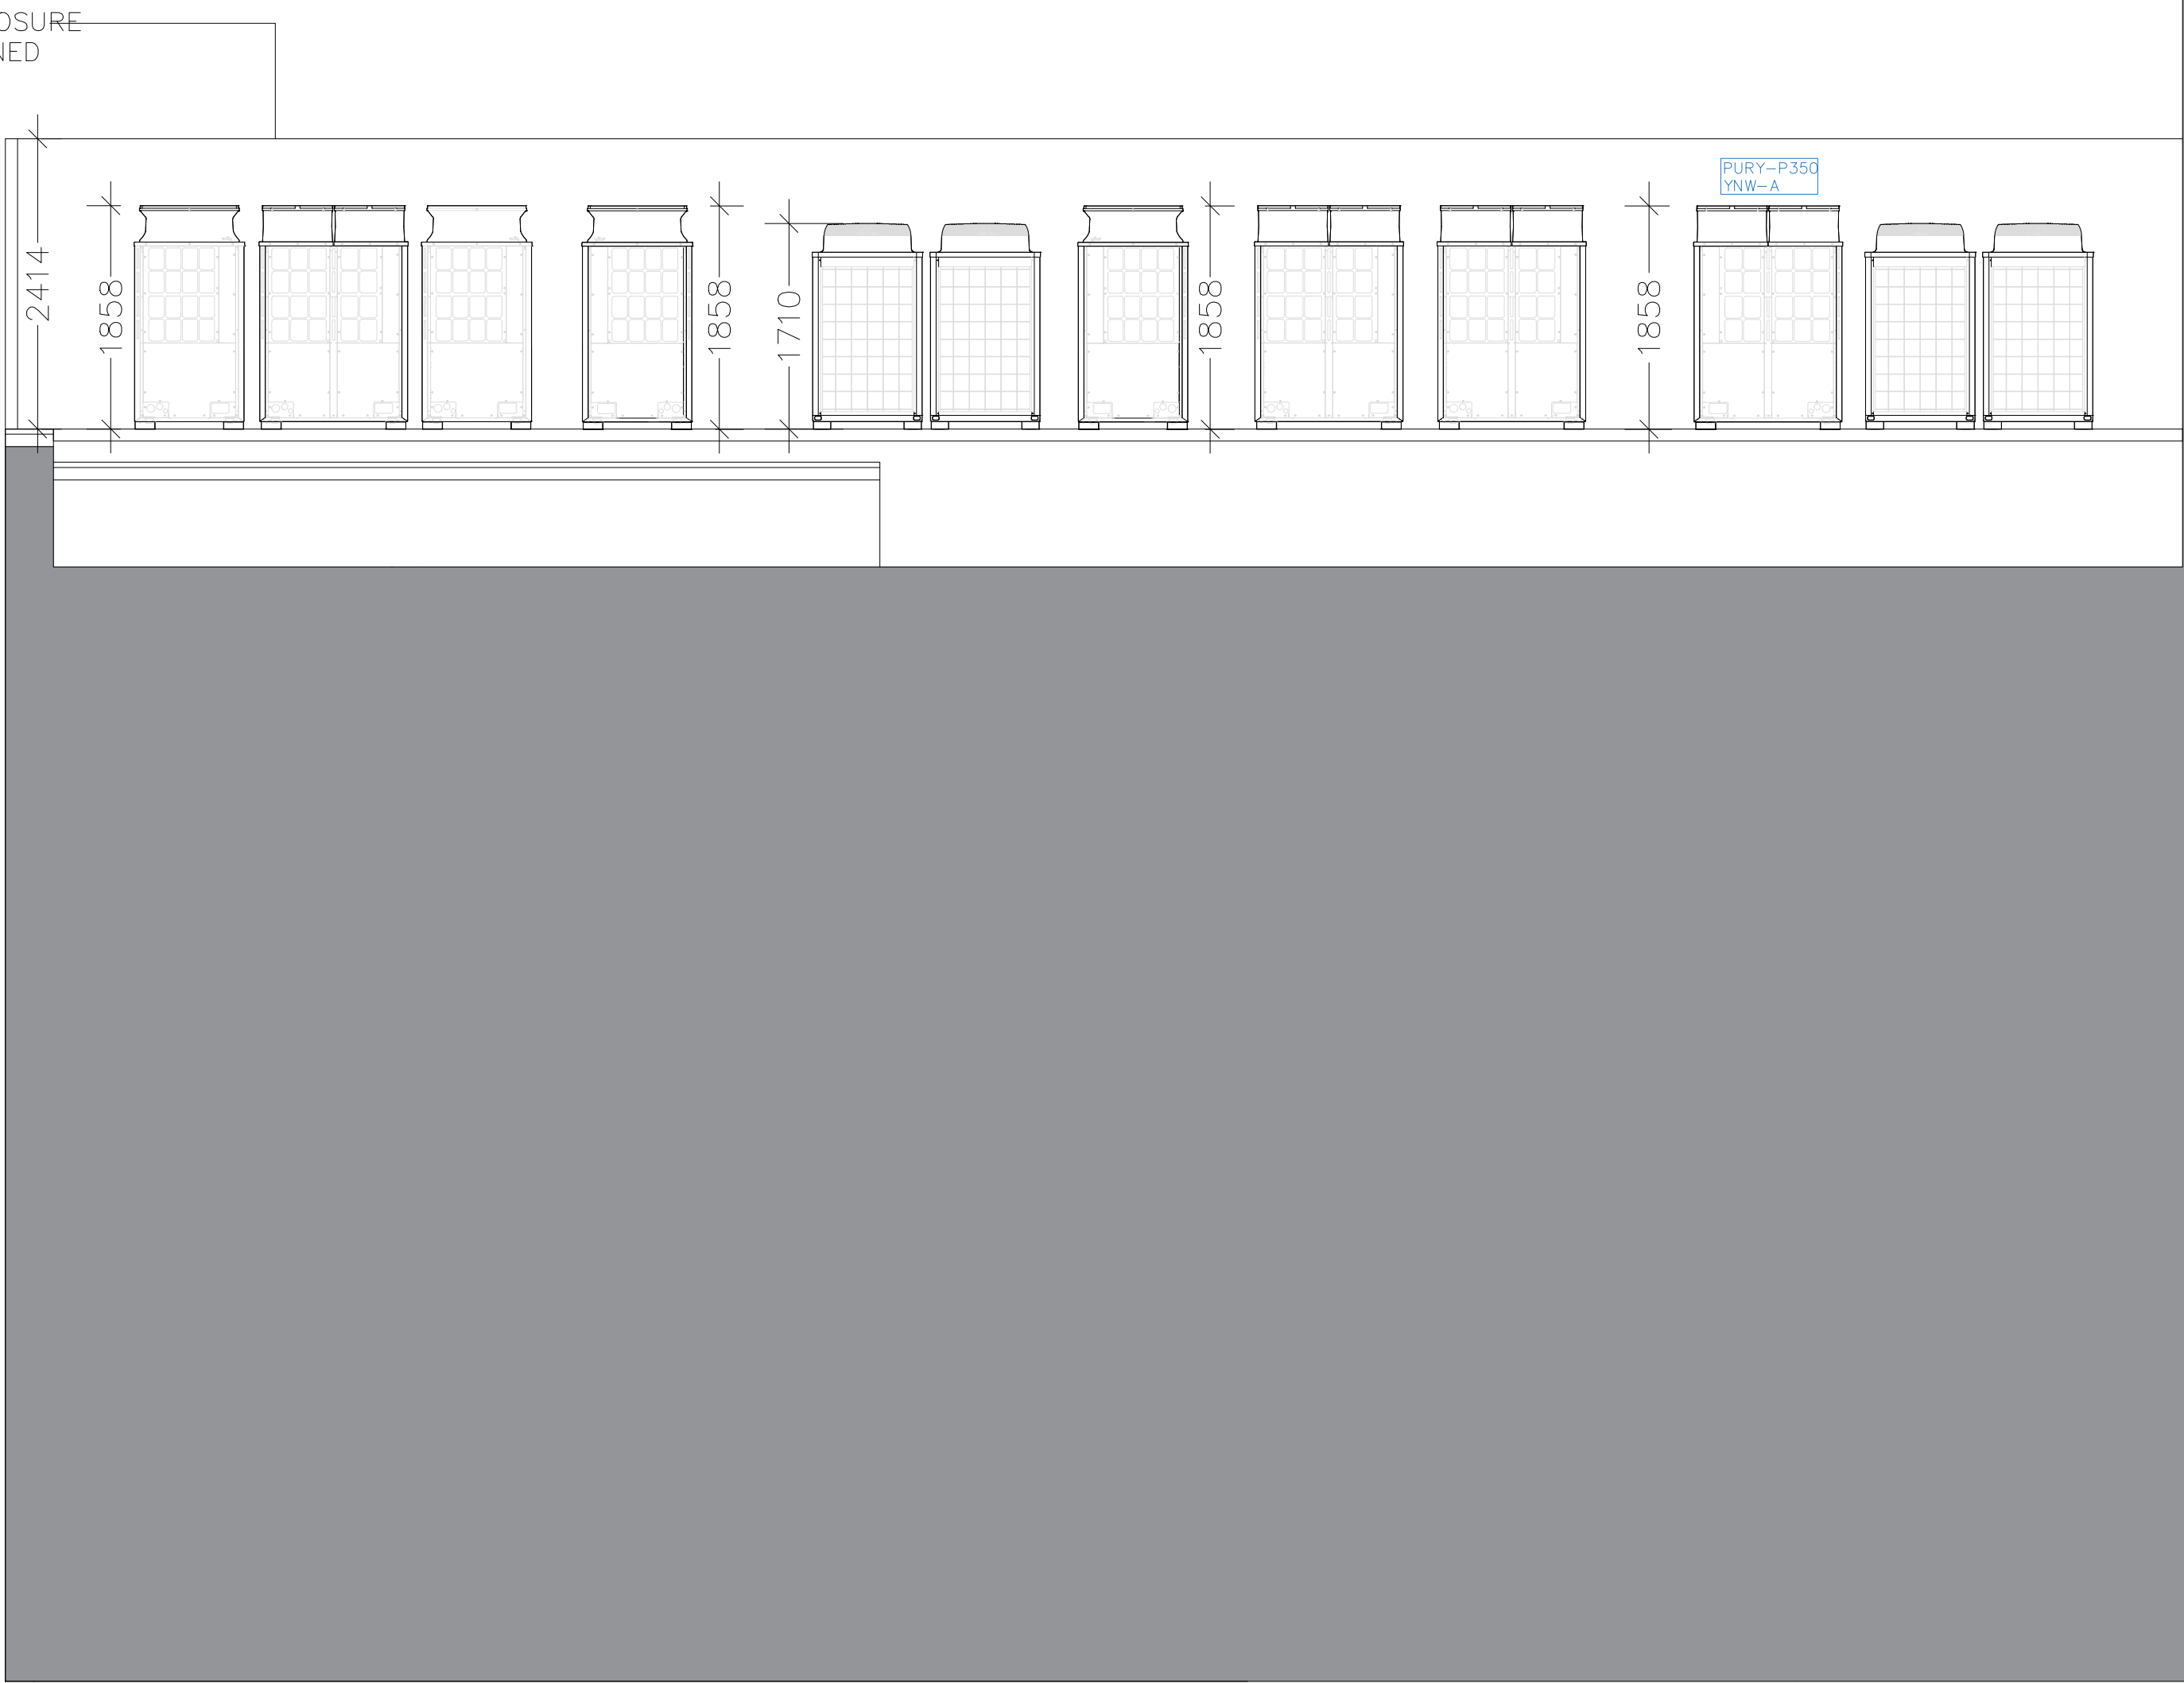

3.00	28/01/24	ISSUED FOR PLANNING Issued for planning.	JW	ARB
REV	DATE	DESCRIPTION	DRAWN	CHECKED



PROJECT
**LINLEY HOUSE
MANCHESTER**

DRAWING REFERENCE
**PROPOSED MECHANICAL PLANT
SECTION SHEET ONE**

DRAWN	CHECKED	DRAWING No		
ARB	JG	BP - PL 171		
STAGE	REV	JOB REFERENCE	DRAWING SCALE	DATE
3	00	24-235	1:50@A1	28.01.24
WEBSITE :		www.blokprojects.com		
TELEPHONE :		+44 (0)161 452 3668		
EMAIL :		info@blokprojects.com		