


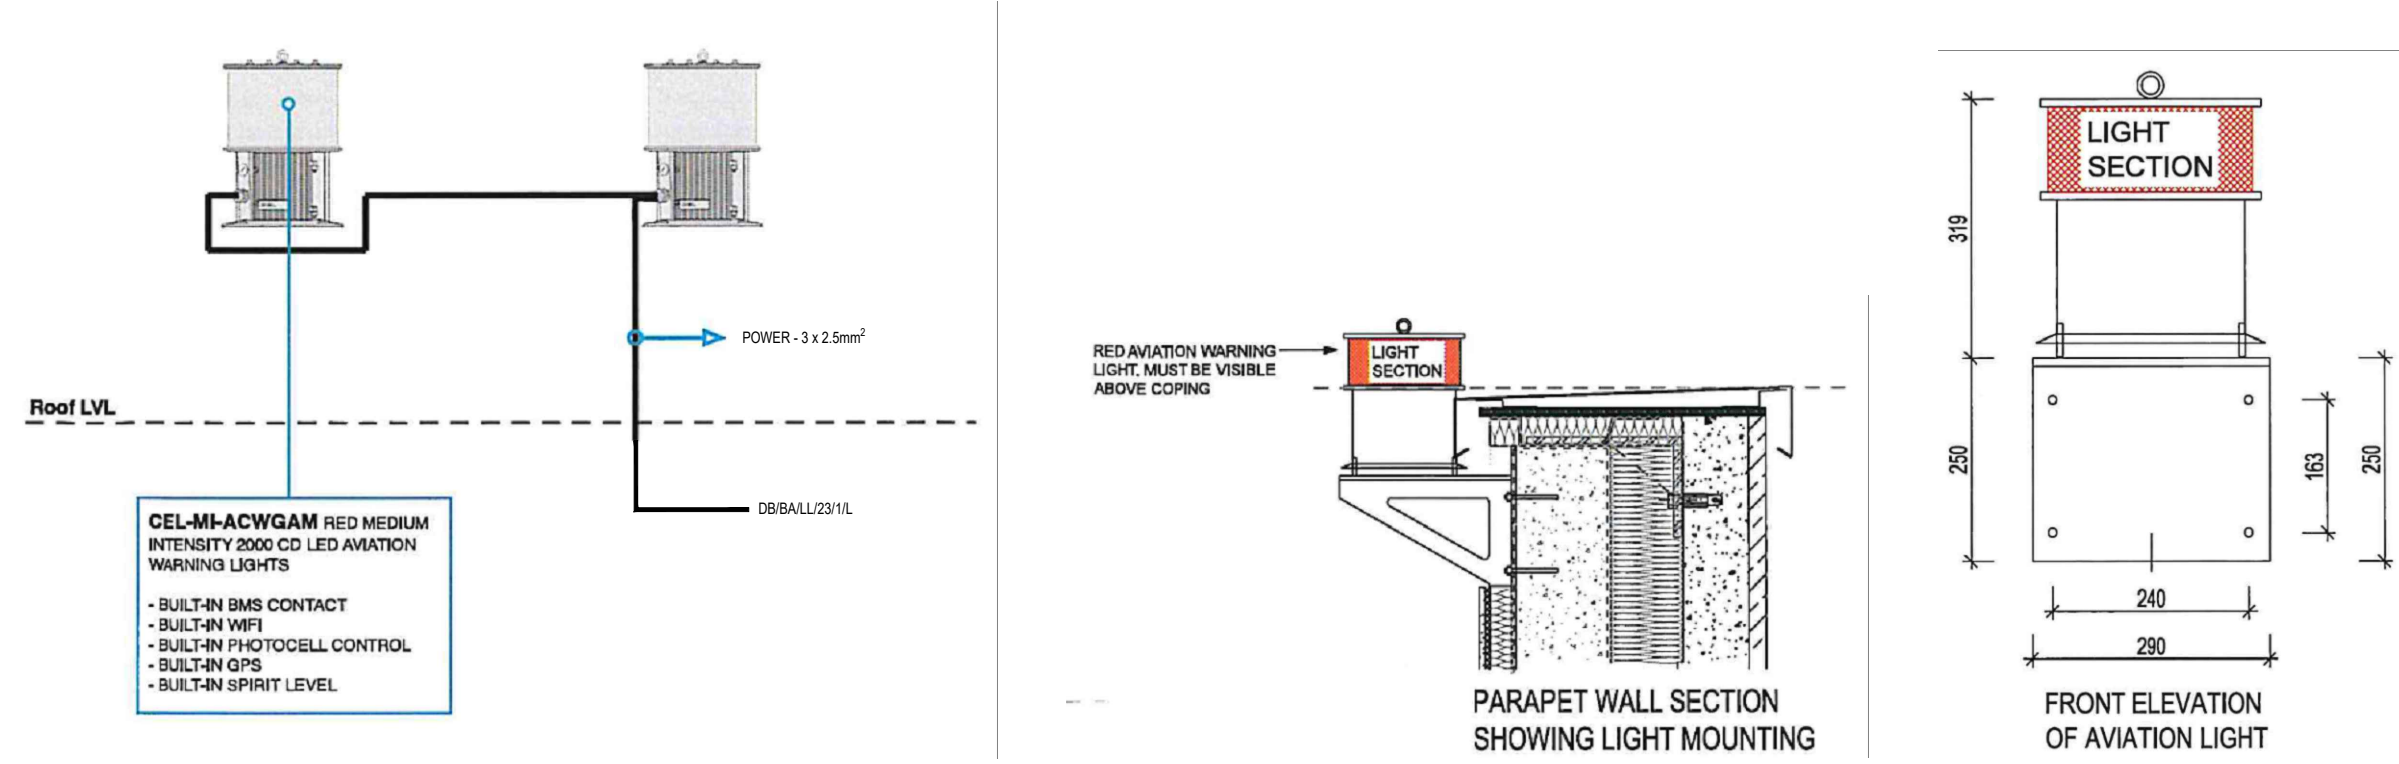



PROTECTED BY UK COPYRIGHT LAW
DO NOT SCALE OFF THIS DRAWING

DESIGNERS RISK ASSESSMENT
Under section 11, 18 - Construction (Design and Management)
Regulations 2015

SAFETY, HEALTH & ENVIRONMENTAL INFORMATION
There are no significant, unusual or location specific risks which are not obvious to a competent contractor or likely to be difficult to manage

PHOTOVOLTAIC SYSTEM BASED ON 500W
PANELS TO ACHIEVE 57.04kWp CURRENTLY
SHOWING 109 PANELS IN TOTAL

FINAL DESIGN BY SPECIALIST

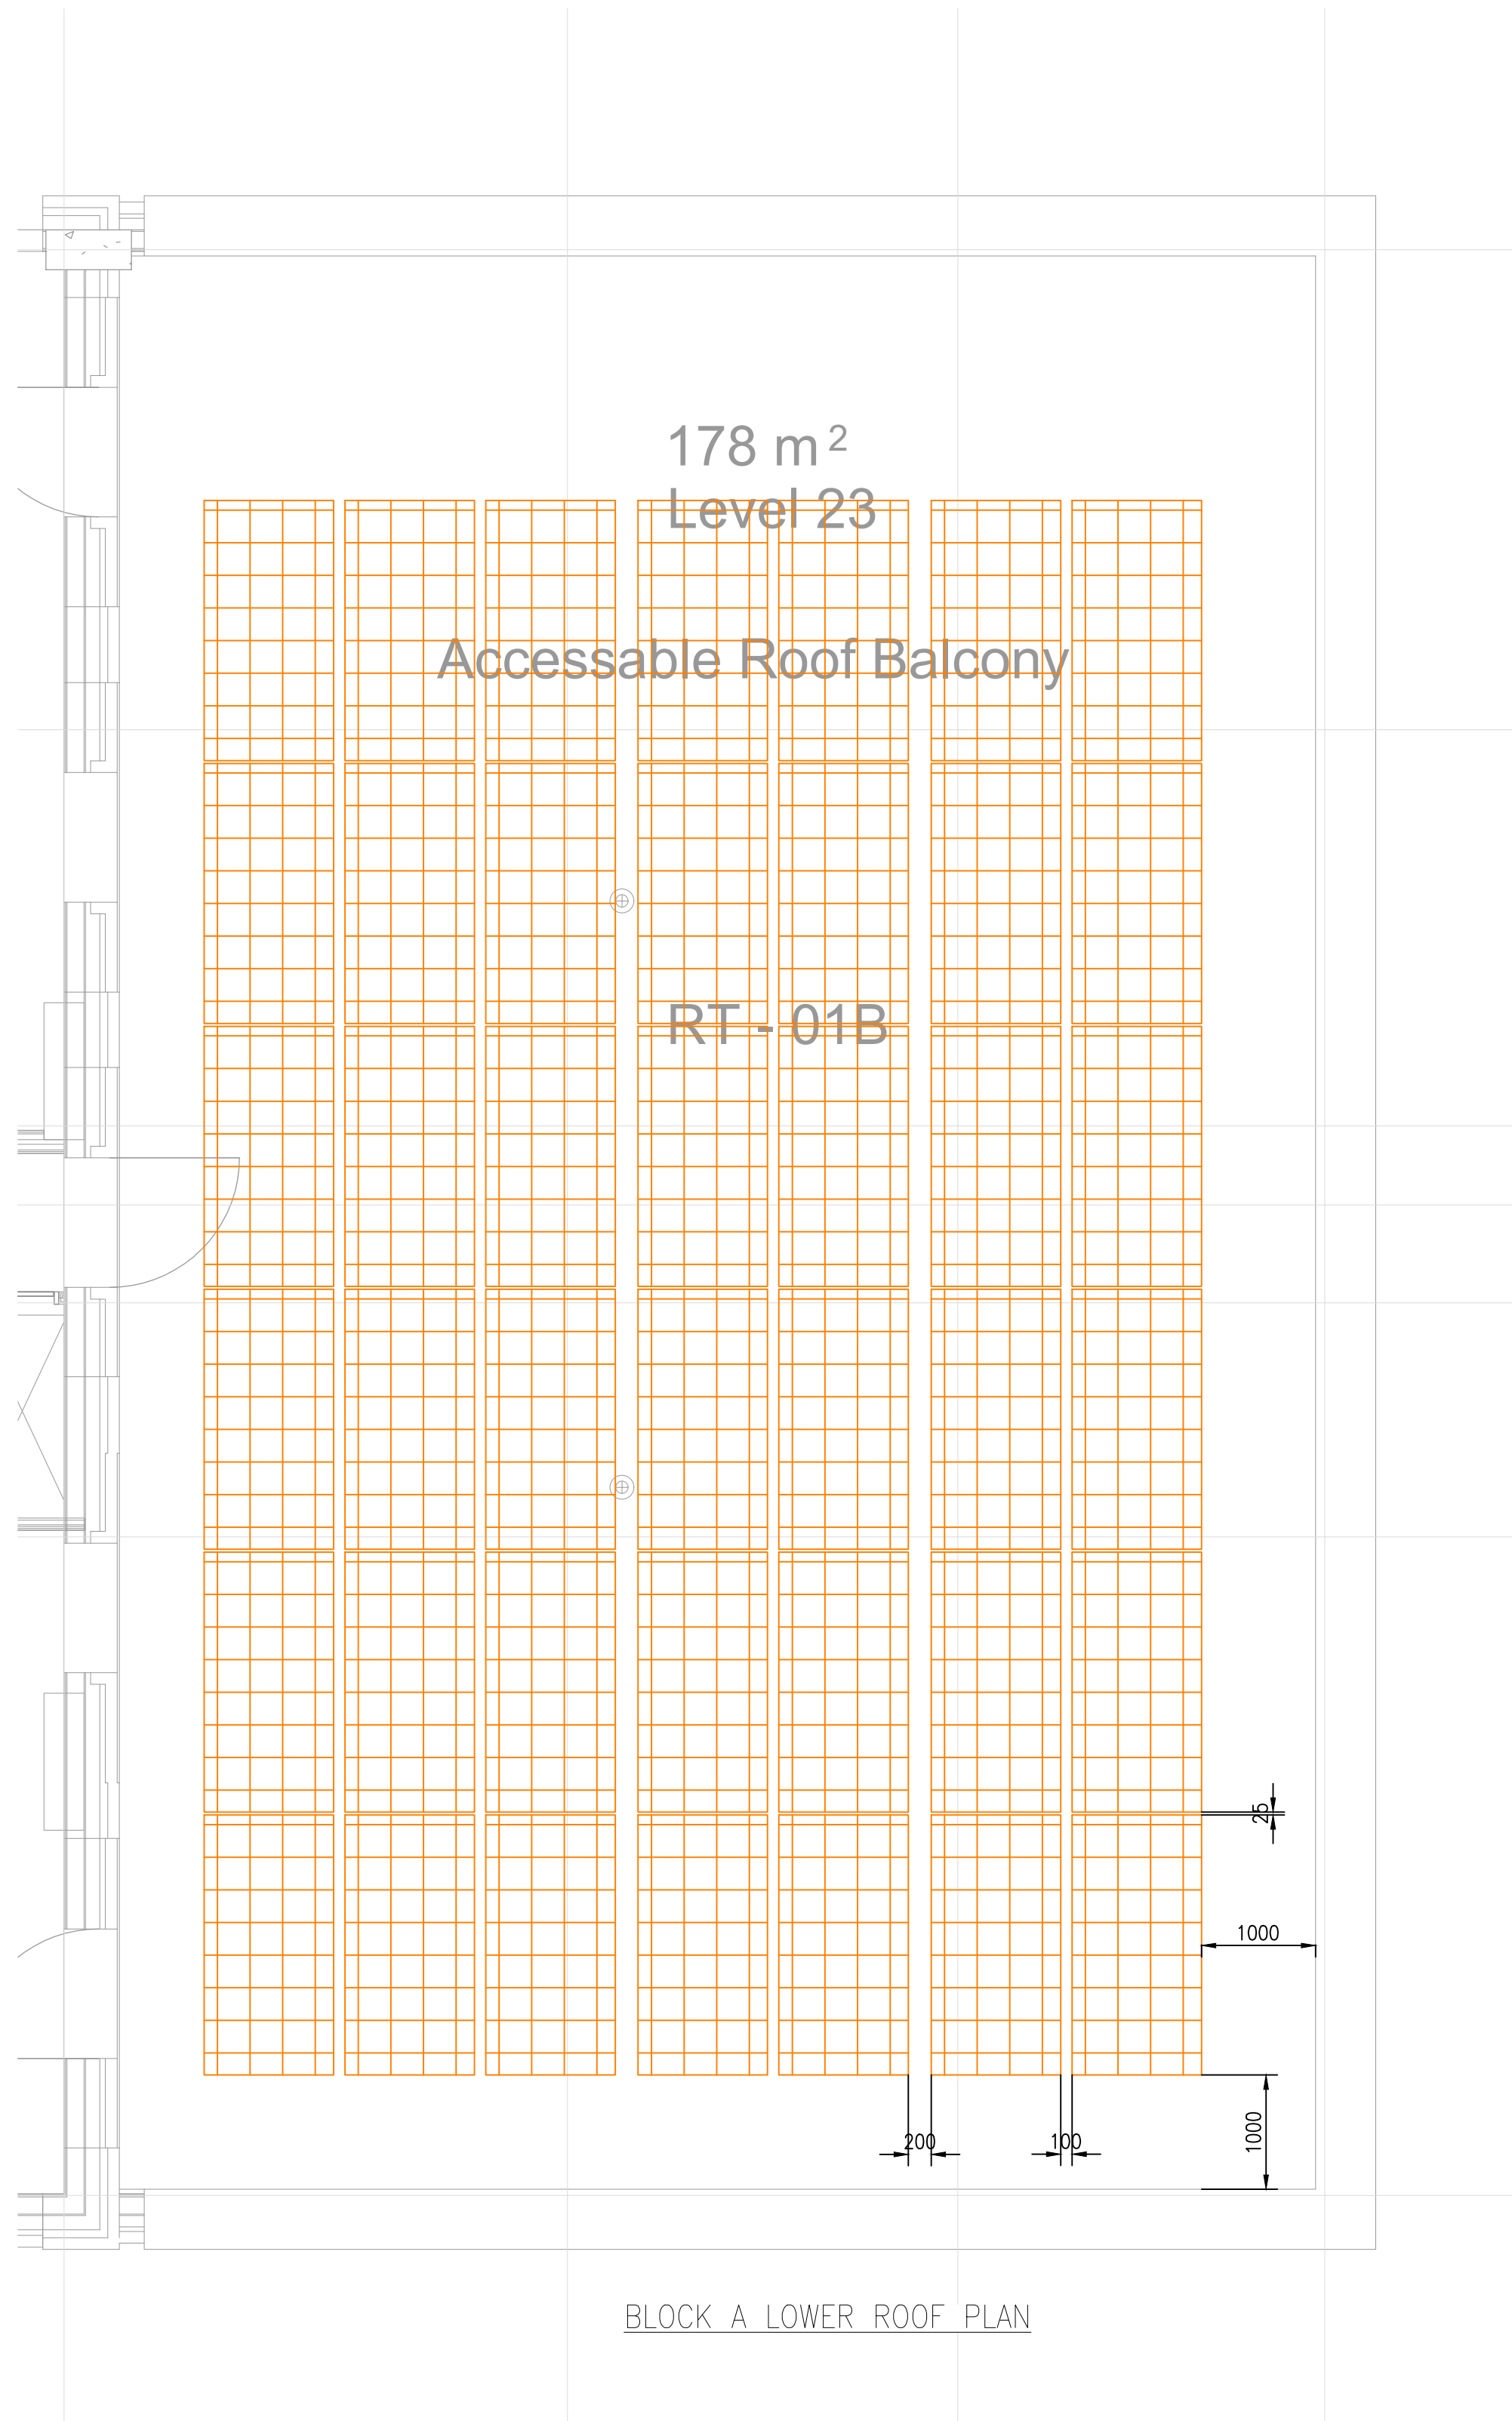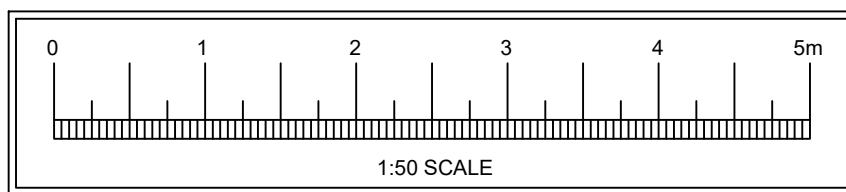

-	P02	PV UPDATED TO SUIT GLAZING SPECIFICATION.	CW	BD	07.08.23
-	P01	PRELIMINARY ISSUE	CW	BD	21.07.23
STA	REV	DESCRIPTION	DES	CHD	DATE

PURPOSE OF ISSUE	PRELIMINARY
------------------	-------------

NOVO
Integration Ltd
7 Feast Field, Horsforth, Leeds,
West Yorkshire, LS18 4TJ
t: +44(0)113 2577300 e: novocad@novovo.eu.com

CLIENT	 SALBOY
PROJECT	WATERHOUSE GARDENS MANCHESTER
TITLE	ELECTRICAL SERVICES BLOCK A LOWER & UPPER ROOF PLAN PV & AVIATION LIGHTING

SCALE 1:50	ORIGINAL SIZE A1	DATE JUL '23
DRAWN EG	DESIGNED CW	CHECKED BD
PROJECT ORIGINATOR ZONE LEVEL TYPE ROLE CLASS NUMBER P1981-NOV-BA-RF-DR-E-9000		REVISION P02