
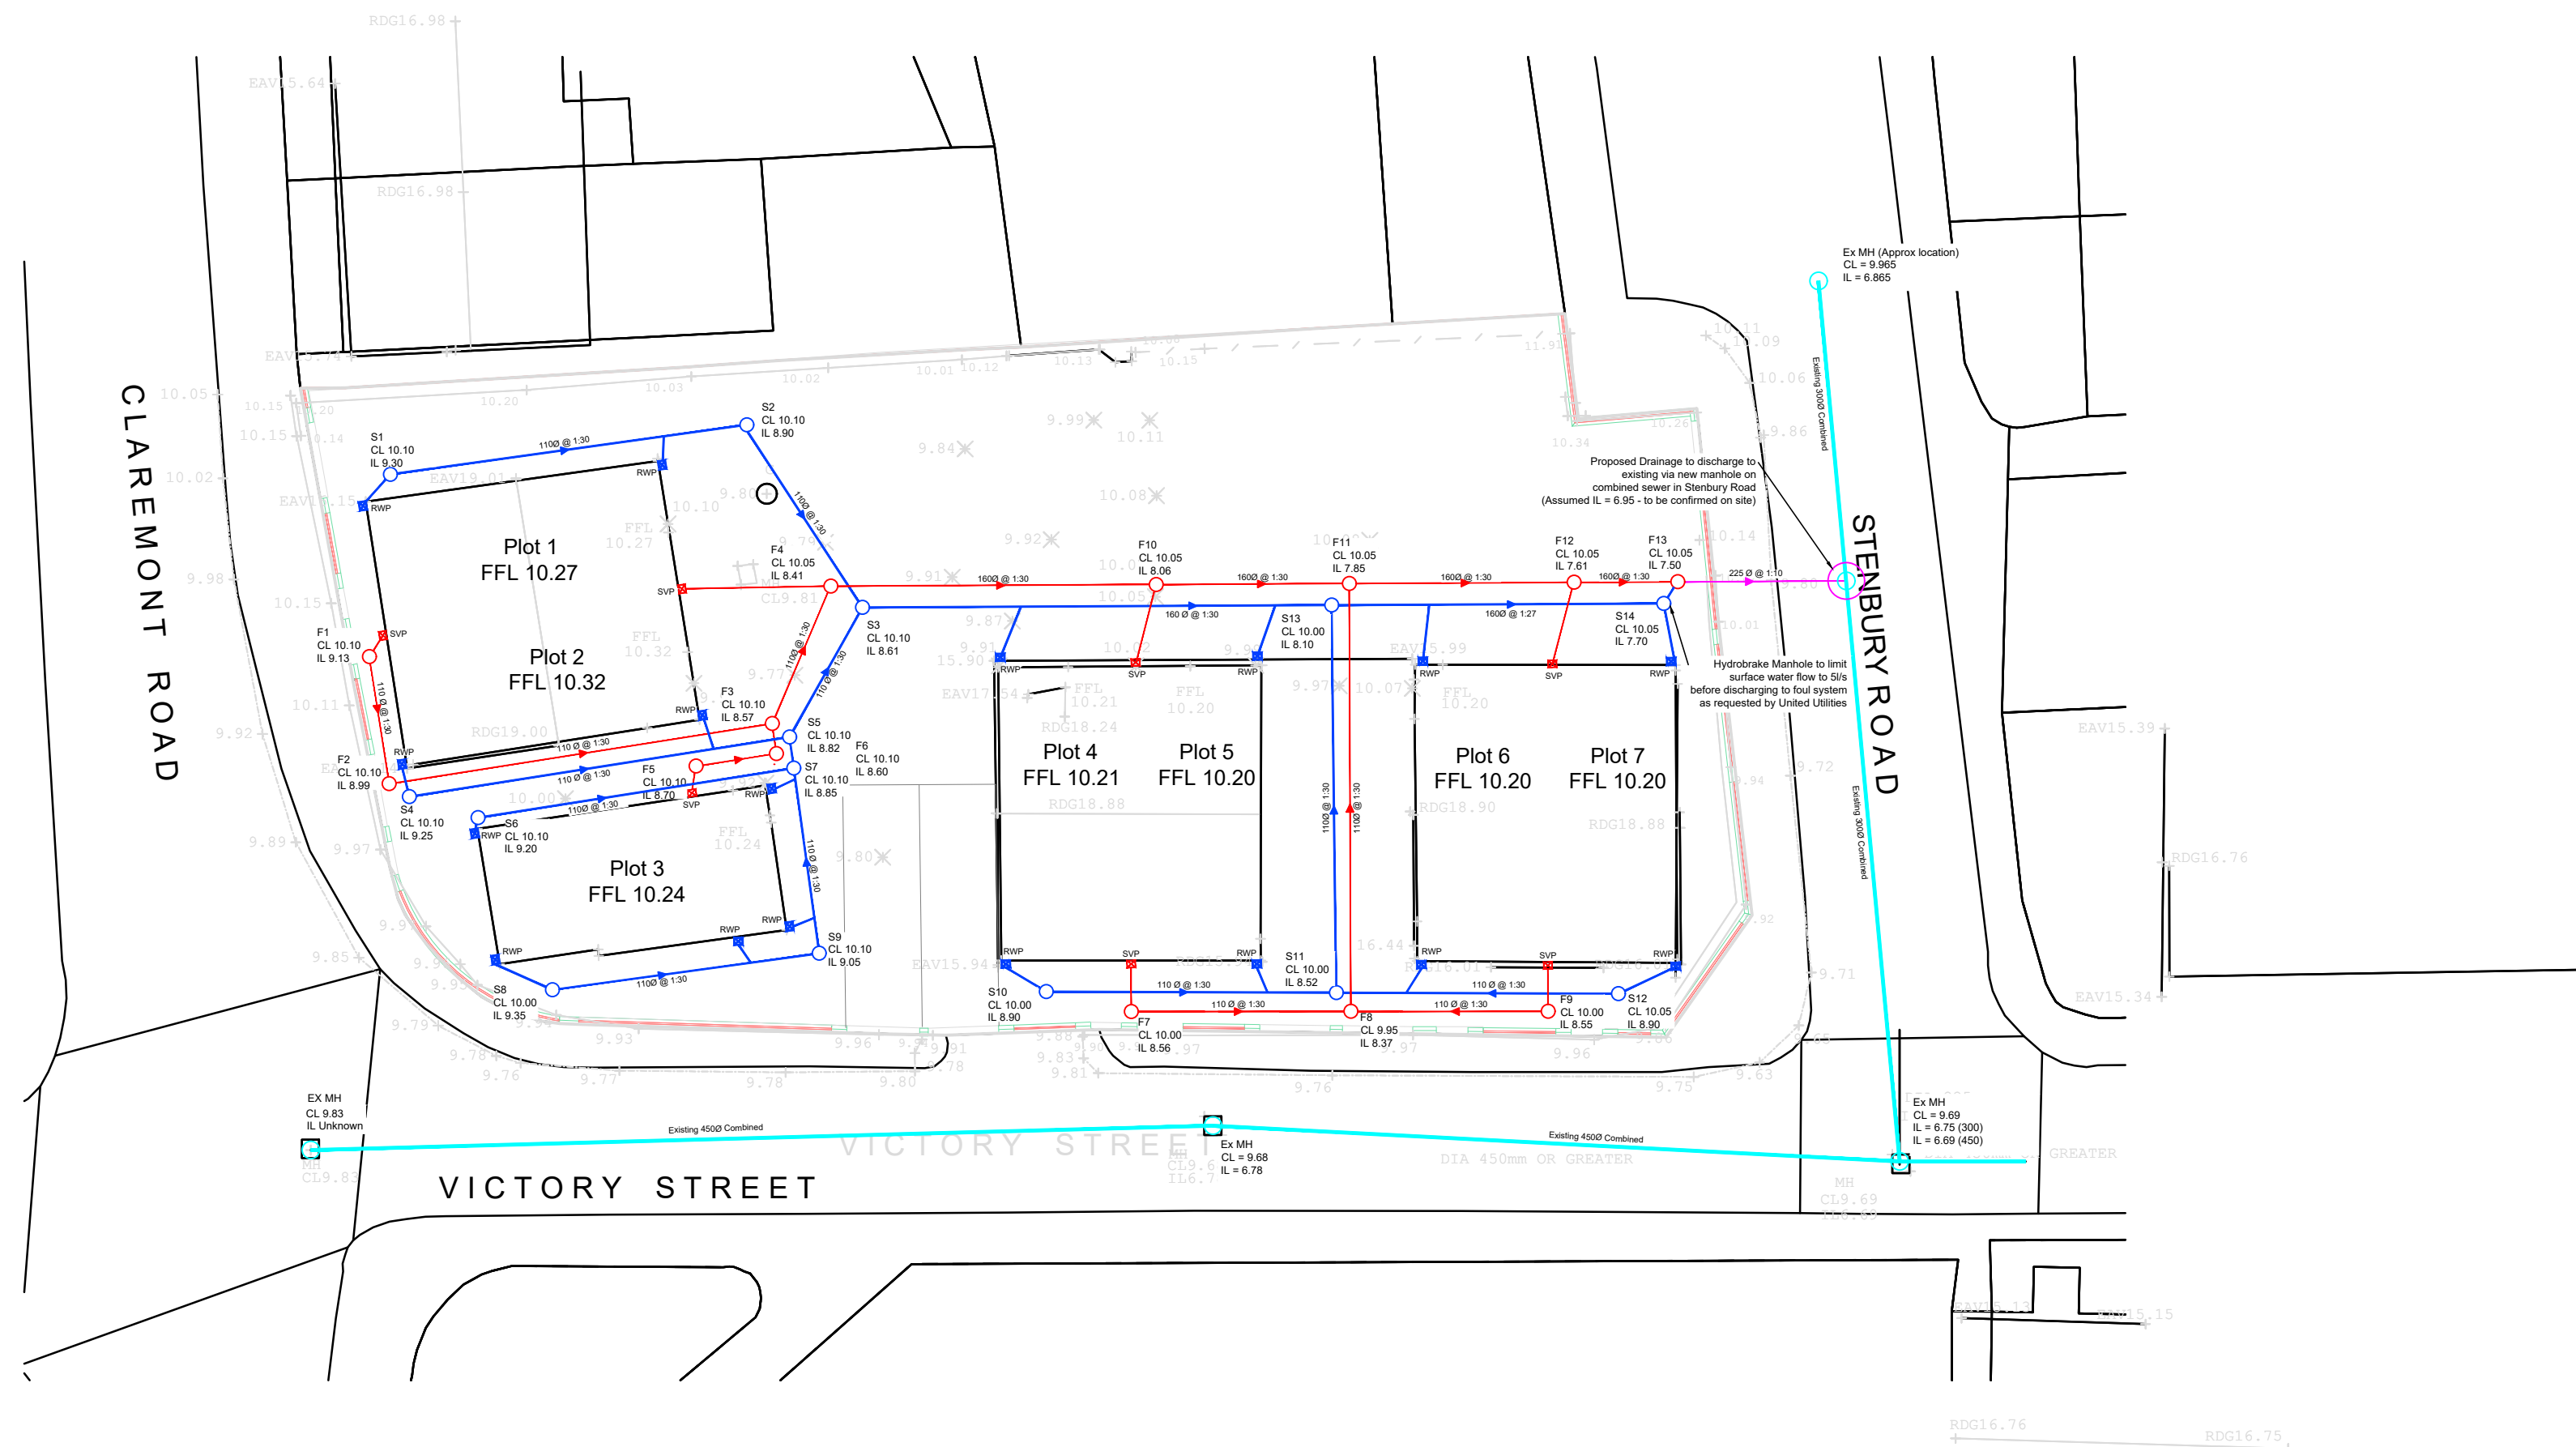


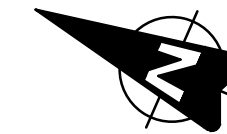

Notes:

1. Do not scale from drawing
2. All dimensions in metres unless otherwise stated
3. All manhole cover levels have been proposed using existing topographical survey information. Contractor to confirm with consultant if proposed levels are to be lower.
4. Existing combined sewer information in Victory Street taken from topographical survey. All inverts to be confirmed by contractor prior to construction.
5. RWP & SVP locations provided by architect and should be confirmed prior to drainage construction.

Key

- Proposed Foul Inspection Chamber
- Surface Water Inspection Chamber
- Proposed Surface Water
- Proposed Foul Water
- Proposed Combined
- Existing Combined Sewers
- ▣ RWP Proposed Rainwater Pipe
- ▣ SVP Proposed Soil Vent Pipe

FFL 10.20 Finished Floor Level

9.65 Existing Level

B	Aug'21	Amendments following UU review.	KS	JC	GR
A	Aug'21	Amendments following client & architect review.	KS	JC	GR

Rev.	Date	Revision details	Drawn	Checked	Approved
------	------	------------------	-------	---------	----------

© This drawing is the property of SYSTRA Limited and the information can only be reproduced with their prior permission.



Centrum House,
38 Queen Street
Glasgow, G1 3DX

T 0141 468 4205
F 0800 066 4367
E UK_Scotland@systra.co.uk

Client Xenon 303 Limited

Project Claremont Road
Rusholme Manchester

Title Drainage Layout

Drawn KS	Checked JC	Approved JC
Original dwg. size A2	Date May'21	Scale 1:200
Drawing Status Approval	Drawing Number 110506/A/DL/01	Rev. B