


DO NOT SCALE FROM THIS DRAWING.
ALL DIMENSIONS TO BE CHECKED ON SITE.
(DRAWINGS MAYBE SCALED FOR LOCAL AUTHORITY & PLANNING PURPOSE ONLY)
COPYRIGHT PROTECTED.

FOR PLANNING
DO NOT USE FOR CONSTRUCTION


CONSULTANT REFERENCES IN DRAWING:

STRUCTURAL - REF/REVISION

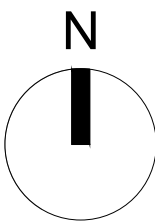

KEY


NEW CONDENSERS

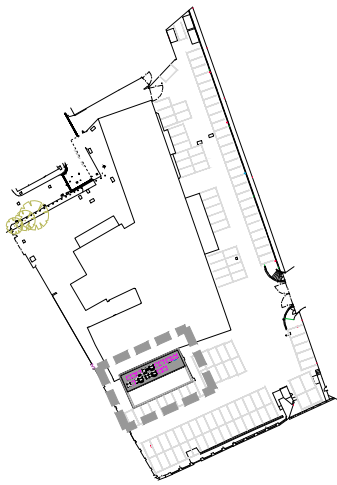

01 PROPOSED ROOF PLANT PLAN 2ND FLOOR LEVEL
100 SCALE 1:200 @A1

NEW CONDENSING
UNIT SPEC:PURY-350
(5TH FLOOR CAT A)

NEW CONDENSING
UNIT SPEC:PURY-450
(5TH FLOOR CAT A)

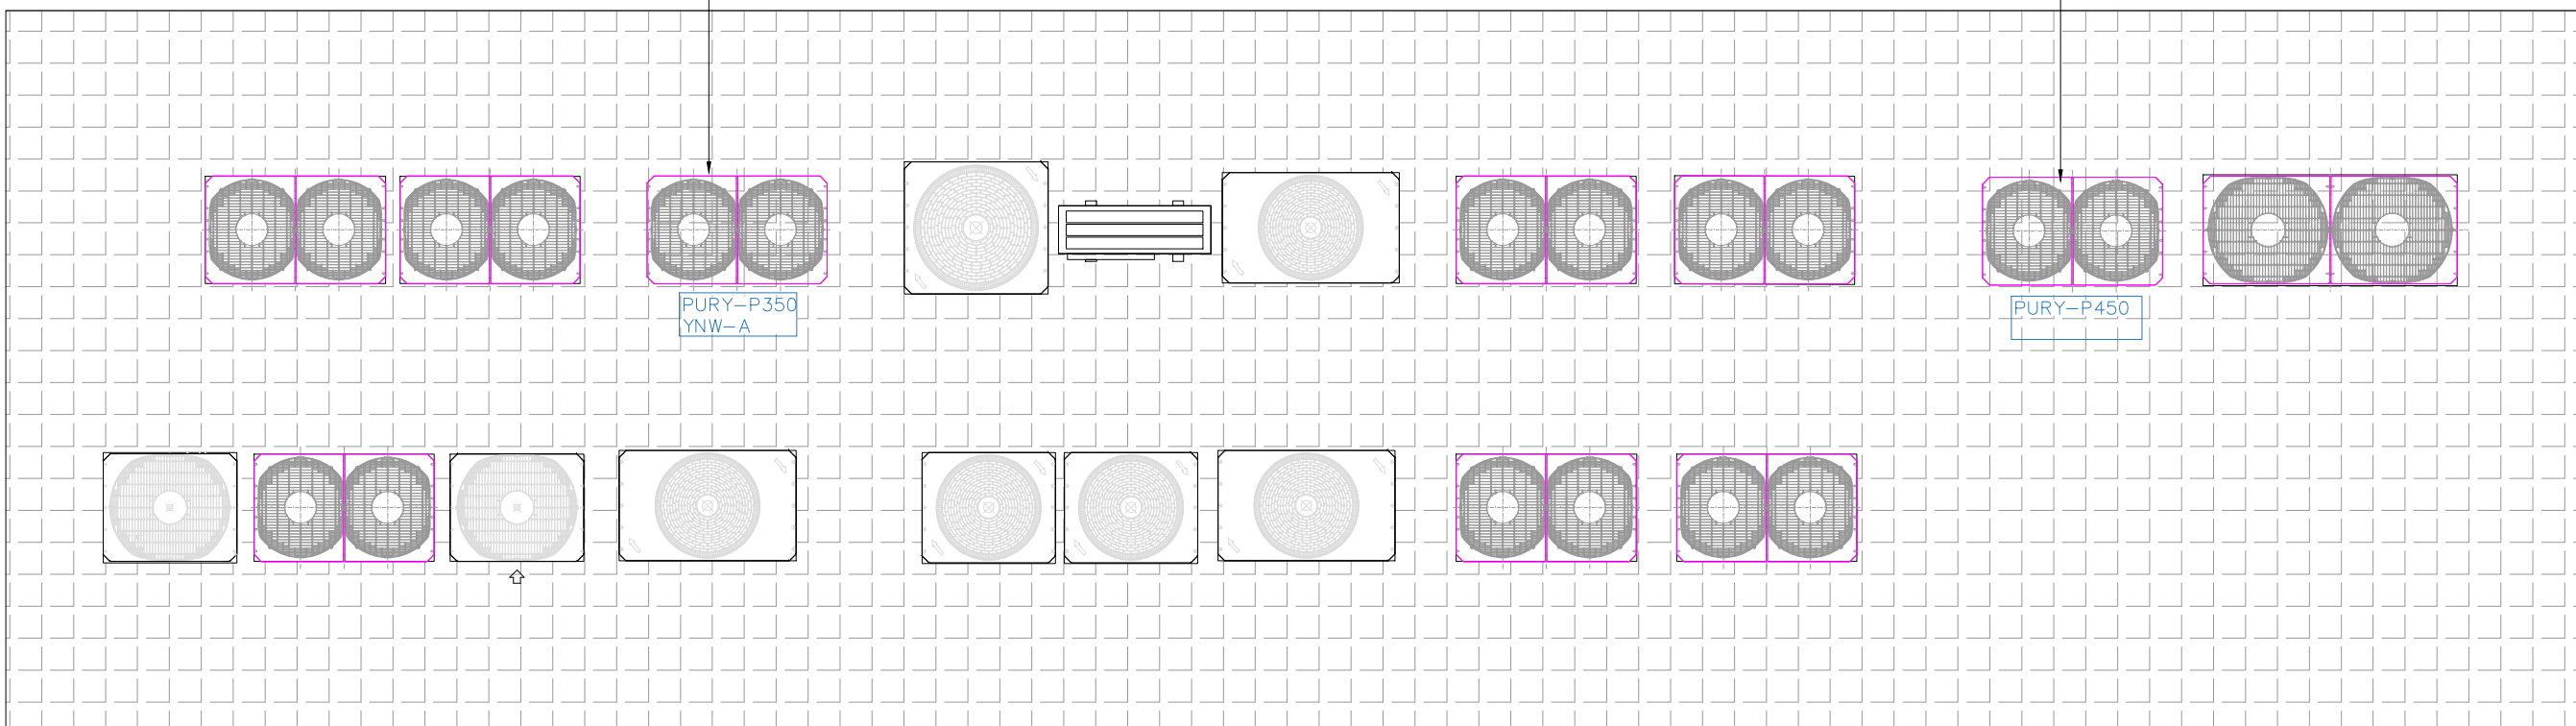

0 2 4 6 8 10m
Scale 1:200

0 0.5 1.0 2.0 2.5m
Scale 1:50

02 PROPOSED ROOF PLANT PLAN 2ND FLOOR LEVEL
100 SCALE 1:50 @A1

4.00	20/11/24	ISSUED FOR TENDER Issued for tender.	JW	ARB
REV	DATE	DESCRIPTION	DRAWN	CHECKED



PROJECT
**LINLEY HOUSE
MANCHESTER**

DRAWING REFERENCE
**PROPOSED MECHANICAL PLANT
SECOND FLOOR ROOF DECK**

DRAWN	CHECKED	DRAWING No		
ARB	JG	BP - PL 100		
STAGE	REV	JOB REFERENCE	DRAWING SCALE	DATE
3	00	24-235	VAR @ A1	29.11.24
WEBSITE	TELEPHONE	EMAIL	www.blokprojects.com	+44 (0)151 452 2668 info@blokprojects.com