 





Reproduced by permission of Ordnance Survey on behalf of the Controller of Her Majesty's Stationery Office All rights reserved. © Crown Copyright licence no. 100022432

SITE AREA PLAN

Scale 1:50,000




SITE PHOTOGRAPH

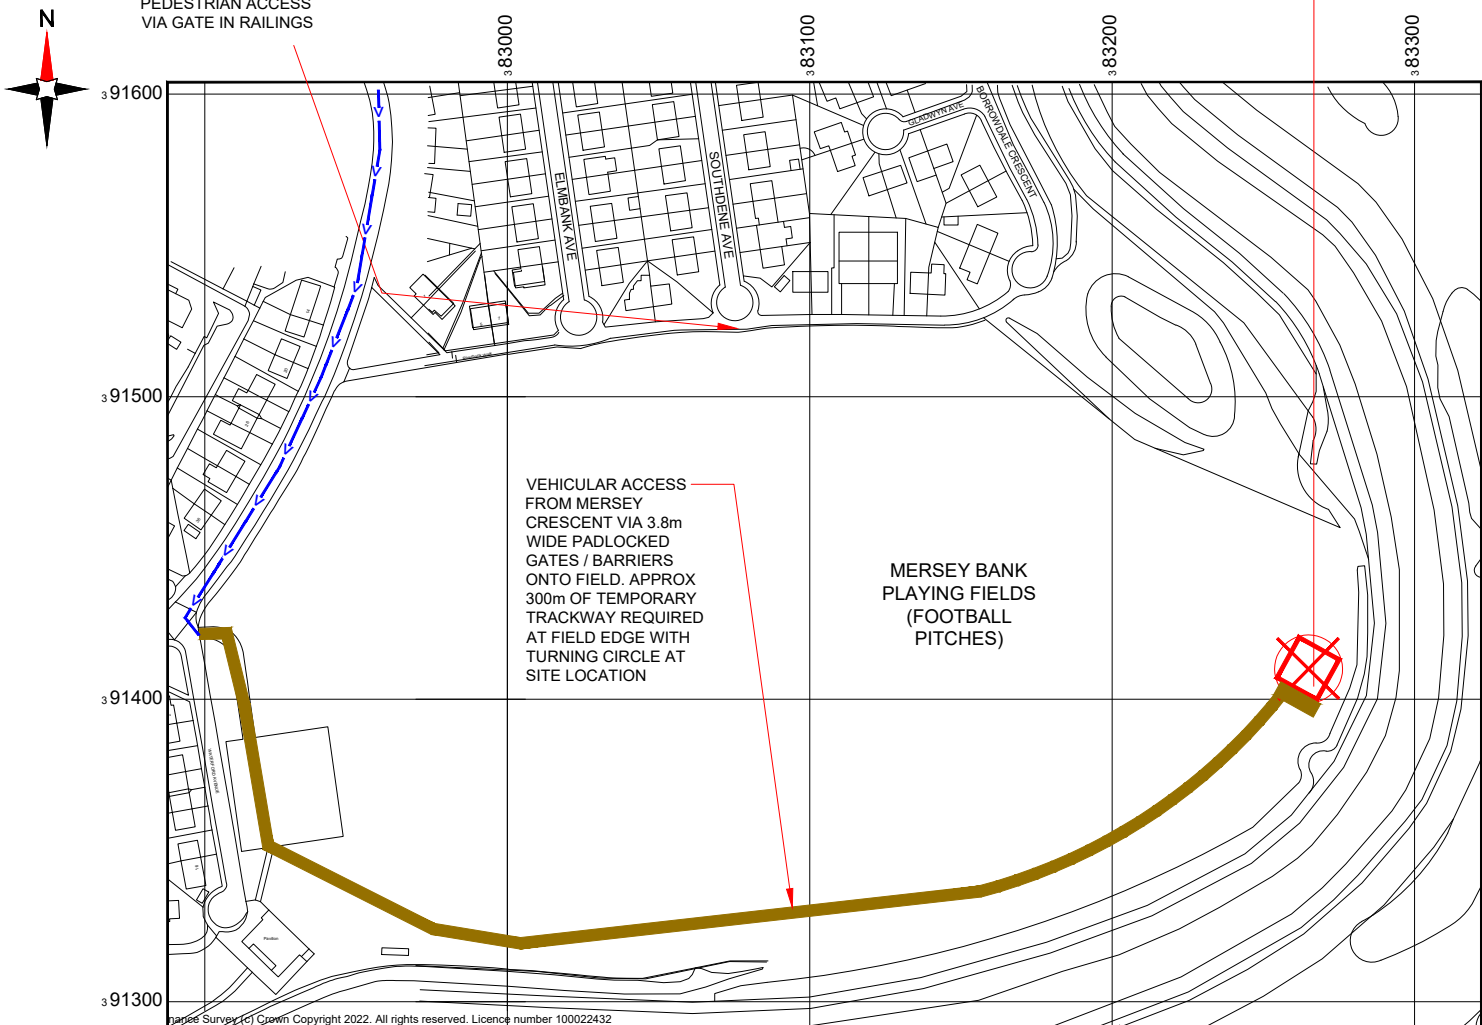

Reproduced by permission of Ordnance Survey on behalf of the Controller of Her Majesty's Stationery Office All rights reserved. © Crown Copyright licence no. 100022432

SITE LOCATION PLAN

 Scale 1:2500



GOOGLE MAPS QR CODE

GOOGLE MAP - Hyperlink to map of the site

GOOGLE STREETVIEW - Hyperlink to streetview of the site

NOTES:

1. ALL DIMENSIONS IN MM UNLESS OTHERWISE NOTED.

From M60 junction 5 head towards Manchester on the A5103. At the junction with the A5145 perform a u-turn back on the A5103. Take the second left onto Mersey Crescent. Continue for 260m and vehicular access onto the playing fields is on the left hand side via padlocked gates / barriers. The site is located at the far end of the playing fields (approx. 300m along field edge).

Site Boundary:



Access Route To Site:



Access Route:



Master:	MBNL / EE / H3G:	Project:	Purpose of Issue:	Issue:
M004	MBNL	NTQ	Construction	A3
Date:	03/05/2022	Revision / Upgrade Description:		
Drawn:	D.PARTON	Tower Type & position Amended		
Checked:	A.FANNING			
Approved:	P.CONVERY			
Master:	MBNL / EE / H3G:	Project:	Purpose of Issue:	Issue:
M003	MBNL	NTQ	Construction	A2
Date:	15/03/22	Revision / Upgrade Description:		
Drawn:	L.COLEBOURN	Site location amended		
Checked:	A.FANNING			
Approved:	P.CONVERY			
Master:	MBNL / EE / H3G:	Project:	Purpose of Issue:	Issue:
M002	MBNL	NTQ	Construction	A1
Date:	04/03/22	Revision / Upgrade Description:		
Drawn:	A.FANNING	Construction Issue		
Checked:	J. CAMPBELL			
Approved:	J. CAMPBELL			
Master:	MBNL / EE / H3G:	Project:	Purpose of Issue:	Issue:
M001	MBNL	NTQ	Planning	A
Date:	13/01/22	Revision / Upgrade Description:		
Drawn:	J. BOOTE	First Issue		
Checked:	J. STOCKDALE			
Approved:	J. STOCKDALE			



Hutchison 3G UK Limited
Star House, 20 Grenfell Road
Maidenhead, SL6 1EH
Tel: 01628 765 000
Fax: 01628 765 001



Hatfield Business Park
Hatfield
Hertfordshire
AL10 9BW
Tel: 01707 315000
Fax: 01707 319001



Mobile Broadband Network Limited
Sixth Floor, Thames Tower, Station Road, Reading, RG1 1LX

Design Consultant & Principal Contractor:




WHP Telecoms

Unit 1 Maple Park,
Low Fields Avenue, Leeds
LS12 6HH

Tel: 01133023550
e-mail: info@whptelecoms.com

Site Name:	MERSEY BANK TEMP		
Site ID:	1664166		
Address:	MERSEY BANK PLAYING FIELDS, MERSEY CRESCENT, WEST DIDSBURY, MANCHESTER, M20 2YJ		
Title:	002 SITE LOCATION PLAN		
Project:	NTQ		
Purpose of Issue:	CONSTRUCTION		
EE Cell ID:	39053	MBNL Cell ID:	MAN560
3UK Cell ID:	-		
Master Drawing No:	1664166_MAN560_39053_M004		
Issue:	A3		

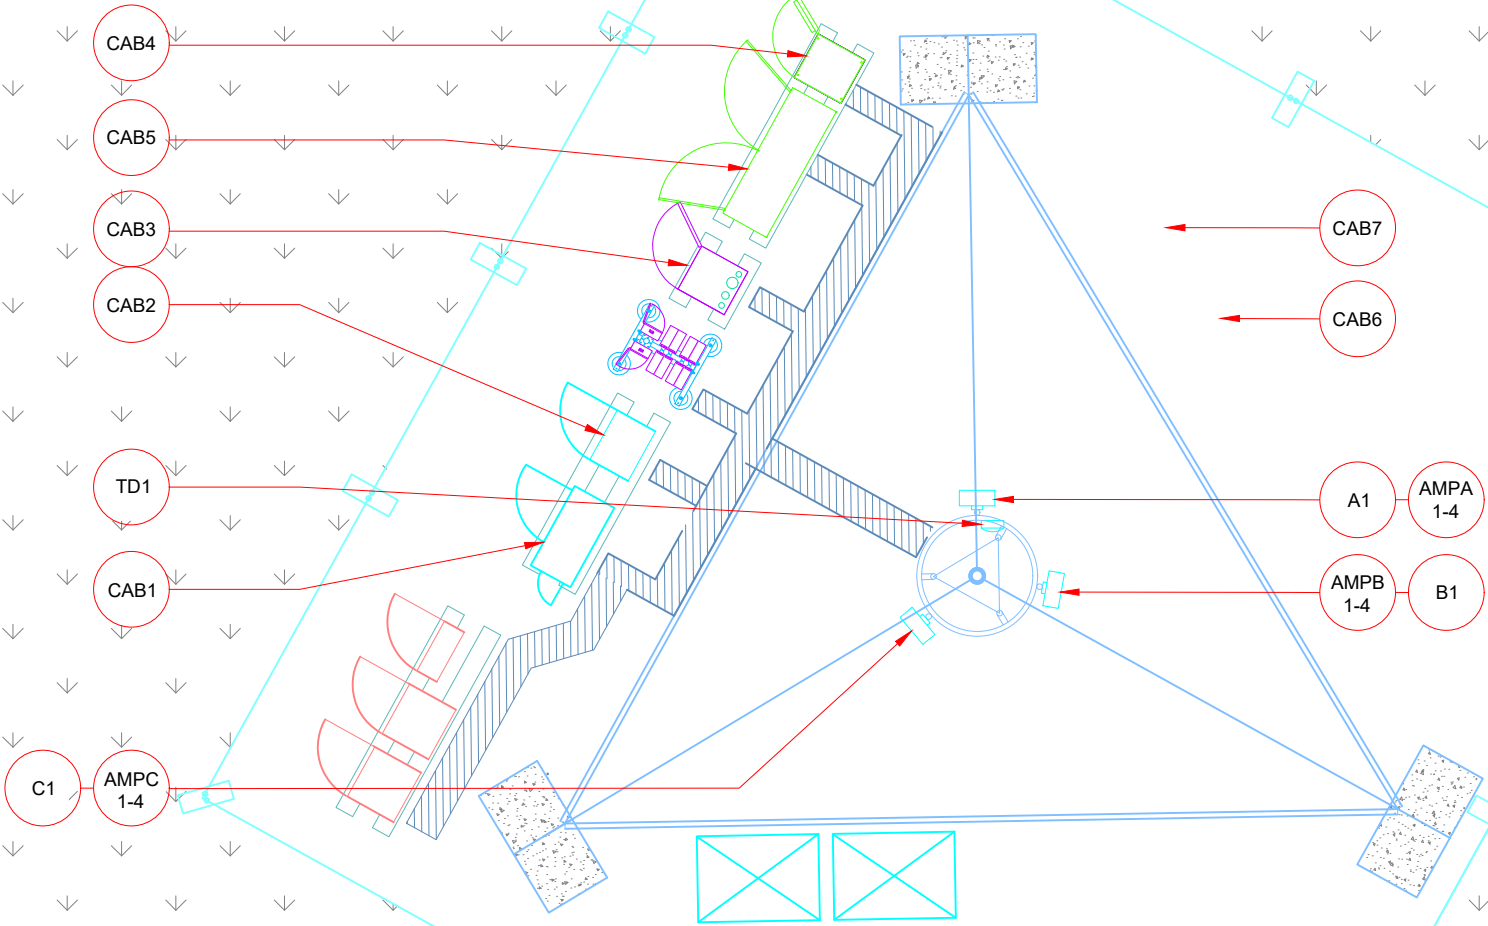

Asset Reference	Asset Description:	Asset Status:	Antenna / Dish / MHA / RRU / Equipment Access Description:
A1	Antenna	Proposed	Rigger access only
B1	Antenna	Proposed	Rigger access only
C1	Antenna	Proposed	Rigger access only
AMPA1-4	MHA	Proposed	Rigger access only
AMPB1-4	MHA	Proposed	Rigger access only
AMPC1-4	MHA	Proposed	Rigger access only
TD1	Dish	Proposed	Rigger access only
CAB1-7	Cabinet	Proposed	Unrestricted access

NOTES:
1. ALL DIMENSIONS IN MM UNLESS OTHERWISE NOTED.

SHARED CONFIGURATION SITE

CONFIG TYPE TEMP B

Master:	MBNL / EE / H3G:	Project:	Purpose of Issue:	Issue:
M004	MBNL	NTQ	Construction	A3
Date:	03/05/2022	Revision / Upgrade Description:		
Drawn:	D.PARTON	Tower Type & position Amended		
Checked:	A.FANNING			
Approved:	P.CONVERY			
Master:	MBNL / EE / H3G:	Project:	Purpose of Issue:	Issue:
M003	MBNL	NTQ	Construction	A2
Date:	15/03/22	Revision / Upgrade Description:		
Drawn:	L.COLEBOURN	Site location amended		
Checked:	A.FANNING			
Approved:	P.CONVERY			
Master:	MBNL / EE / H3G:	Project:	Purpose of Issue:	Issue:
M002	MBNL	NTQ	Construction	A1
Date:	04/03/22	Revision / Upgrade Description:		
Drawn:	A.FANNING	Construction Issue		
Checked:	J.CAMPBELL			
Approved:	J.CAMPBELL			
Master:	MBNL / EE / H3G:	Project:	Purpose of Issue:	Issue:
M001	MBNL	NTQ	Planning	A
Date:	13/01/22	Revision / Upgrade Description:		
Drawn:	J. BOOTE	First Issue		
Checked:	J. STOCKDALE			
Approved:	J. STOCKDALE			



Hutchison 3G UK Limited
Star House, 20 Grenfell Road
Maidenhead, SL6 1EH
Tel: 01628 765 000
Fax: 01628 765 001



Hatfield Business Park
Hatfield
Hertfordshire
AL10 9BW
Tel: 01707 315000
Fax: 01707 319001



Mobile Broadband Network Limited
Sixth Floor, Thames Tower, Station Road, Reading, RG1 1LX

Design Consultant & Principal Contractor:



WHP Telecoms
Unit 1 Maple Park,
Low Fields Avenue, Leeds
LS12 6HH

Tel: 01133023550
e-mail: info@whptelecoms.com

Site Name:
MERSEY BANK TEMP

Site ID:
1664166

Address:
**MERSEY BANK PLAYING FIELDS,
MERSEY CRESCENT,
WEST DIDSBURY,
MANCHESTER,
M20 2YJ**



Title:
003 ACCESS PLAN

Project:
NTQ

Purpose of Issue:
CONSTRUCTION

EE Cell ID: 39053	MBNL Cell ID: MAN560	3UK Cell ID: -
-----------------------------	--------------------------------	--------------------------


Master Drawing No: 1664166_MAN560_39053_M004	Issue: A3
--	---------------------

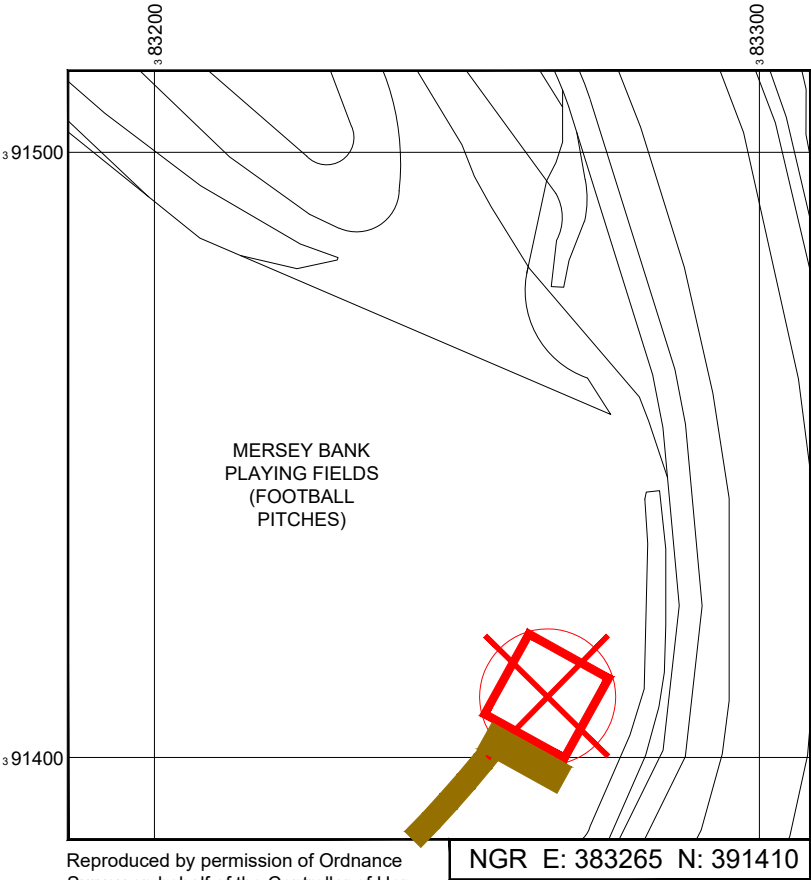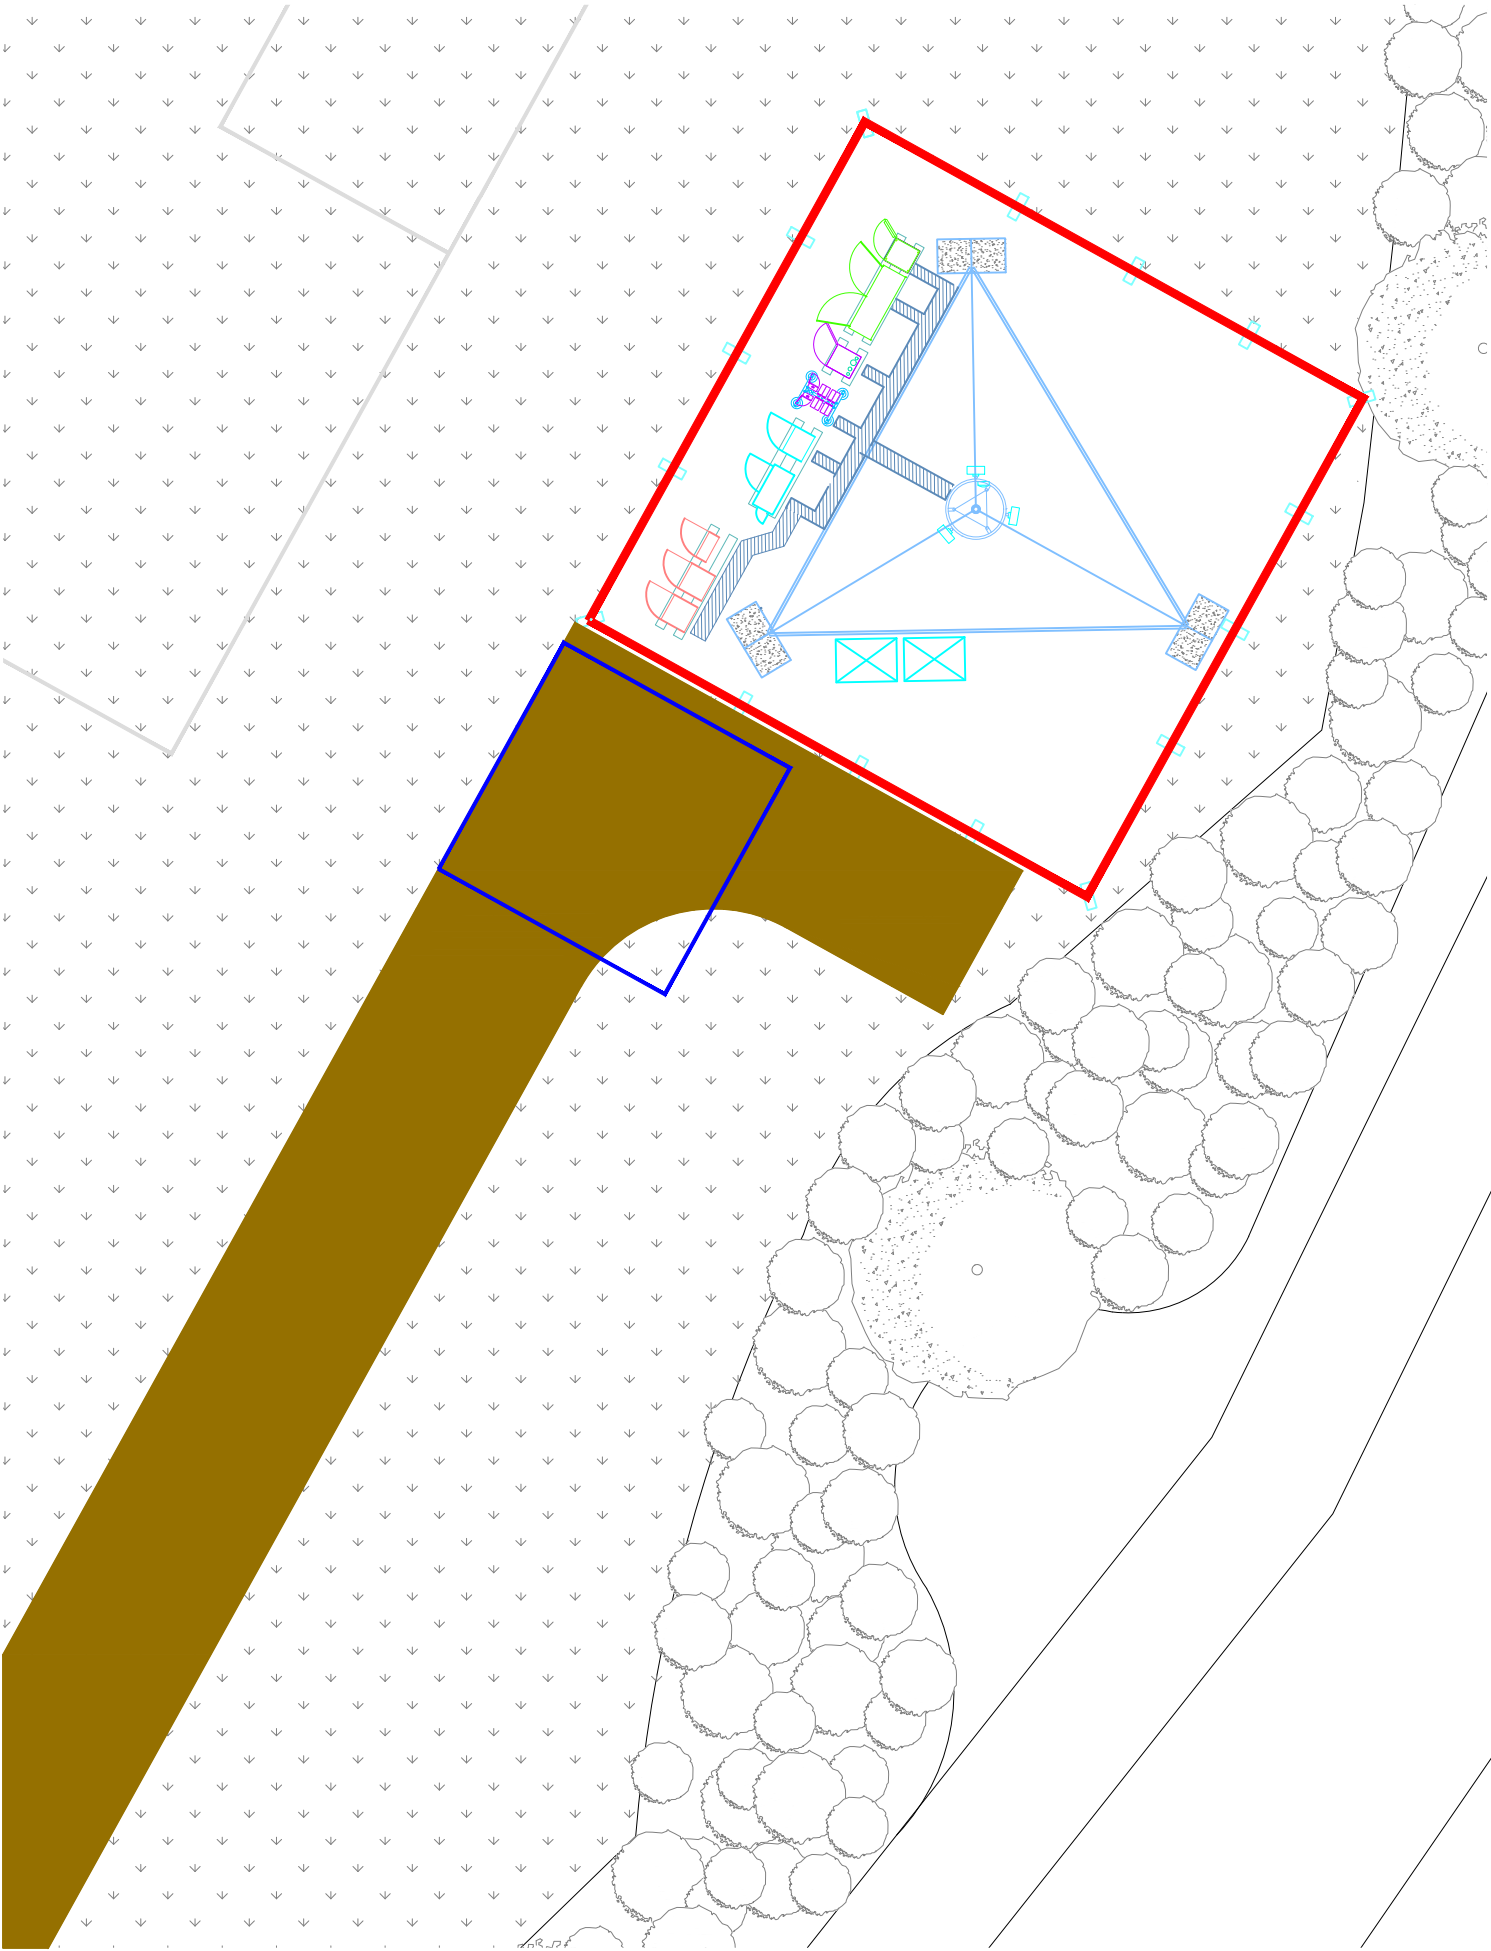

Reproduced by permission of Ordnance
Survey on behalf of the Controller of Her
Majesty's Stationery Office All rights reserved.
© Crown Copyright licence no. 100022432

SITE LOCATION PLAN

 Scale 1:1250



NEW CODE:		
Demise:	Outlined in Red	
Access Route:	Solid Brown	
Set Down Area:	Outlined in Blue	

Master:	MBNL / EE / H3G:	Project:	Purpose of Issue:	Issue:
M004	MBNL	NTQ	Construction	A3
Date:	03/05/2022	Revision / Upgrade Description:		
Drawn:	D.PARTON	Tower Type & position Amended		
Checked:	A.FANNING			
Approved:	P.CONVERY			
Master:	MBNL / EE / H3G:	Project:	Purpose of Issue:	Issue:
M003	MBNL	NTQ	Construction	A2
Date:	15/03/22	Revision / Upgrade Description:		
Drawn:	L.COLEBOURN	Site location amended		
Checked:	A.FANNING			
Approved:	P.CONVERY			
Master:	MBNL / EE / H3G:	Project:	Purpose of Issue:	Issue:
M002	MBNL	NTQ	Construction	A1
Date:	04/03/22	Revision / Upgrade Description:		
Drawn:	A.FANNING	Construction Issue		
Checked:	J.CAMPBELL			
Approved:	J.CAMPBELL			
Master:	MBNL / EE / H3G:	Project:	Purpose of Issue:	Issue:
M001	MBNL	NTQ	Planning	A
Date:	13/01/22	Revision / Upgrade Description:		
Drawn:	J. BOOTE	First Issue		
Checked:	J. STOCKDALE			
Approved:	J. STOCKDALE			



Hutchison 3G UK Limited
Star House, 20 Grenfell Road
Maidenhead, SL6 1EH
Tel: 01628 765 500
Fax: 01628 765 501

H3G Base Station Information line:
0845 6043000
Available 8am-8pm Monday to Friday



Hatfield Business Park
Hatfield
Hertfordshire
AL10 9BW

Tel: 01707 315000
Fax: 01707 319001



Mobile Broadband Network Limited
Sixth Floor, Thames Tower, Station Road, Reading, RG1 1LX

Design Consultant & Principal Contractor:



WHP Telecoms
Unit 1 Maple Park,
Low Fields Avenue, Leeds
LS12 6HH

Tel: 01133023550
e-mail: info@whptelecoms.com

Site Name:
MERSEY BANK TEMP

Site ID:
1664166

Address:
MERSEY BANK PLAYING FIELDS,
MERSEY CRESCENT,
WEST DIDSBURY,
MANCHESTER,
M20 2YJ

Title:
002 SITE LOCATION PLAN

Project:
NTQ

Purpose of Issue:
CONSTRUCTION

EE Cell ID: 39053	MBNL Cell ID: MAN560	3UK Cell ID: -
Master Drawing No: 1664166_MAN560_39053_M004		Issue: A3



FOOTBALL
PITCH

BRAMBLES

RIVER
MERSEY

GRASS /
GROUND LEVEL
0.0m

PROPOSED CHERRY
PICKER/CRAVE LOCATION.
TRACKWAY REQUIRED

CHERRY PICKER / CRANE LOCATION

Scale 1:200



NOTES:

1. ALL DIMENSIONS IN MM UNLESS OTHERWISE NOTED.

PROPOSED CRANE OR CHERRY PICKER LOCATION:



Master:	MBNL / EE / H3G:	Project:	Purpose of Issue:	Issue:
M004	MBNL	NTQ	Construction	A3
Date:	03/05/2022	Revision / Upgrade Description:		
Drawn:	D.PARTON	Tower Type & position Amended		
Checked:	A.FANNING			
Approved:	P.CONVERY			
Master:	MBNL / EE / H3G:	Project:	Purpose of Issue:	Issue:
M003	MBNL	NTQ	Construction	A2
Date:	15/03/22	Revision / Upgrade Description:		
Drawn:	L.COLEBOURN	Site location amended		
Checked:	A.FANNING			
Approved:	P.CONVERY			
Master:	MBNL / EE / H3G:	Project:	Purpose of Issue:	Issue:
M002	MBNL	NTQ	Construction	A1
Date:	04/03/22	Revision / Upgrade Description:		
Drawn:	A.FANNING	Construction Issue		
Checked:	J.CAMPBELL			
Approved:	J.CAMPBELL			
Master:	MBNL / EE / H3G:	Project:	Purpose of Issue:	Issue:
M001	MBNL	NTQ	Planning	A
Date:	13/01/22	Revision / Upgrade Description:		
Drawn:	J. BOOTE	First Issue		
Checked:	J. STOCKDALE			
Approved:	J. STOCKDALE			



Hutchison 3G UK Limited
Star House, 20 Grenfell Road
Maidenhead, SL6 1EH
Tel: 01628 765 500
Fax: 01628 765 501

H3G Base Station Information line:
0845 6043000
Available 8am-8pm Monday to Friday



Hatfield Business Park
Hatfield
Hertfordshire
AL10 9BW

Tel: 01707 315000
Fax: 01707 319001



Mobile Broadband Network Limited
Sixth Floor, Thames Tower, Station Road, Reading, RG1 1LX


Design Consultant & Principal Contractor:



WHP Telecoms
Unit 1 Maple Park,
Low Fields Avenue, Leeds
LS12 6HH

Tel: 01133023550
e-mail: info@whptelecoms.com

Site Name:	MERSEY BANK TEMP		
Site ID:	1664166		
Address:	MERSEY BANK PLAYING FIELDS, MERSEY CRESCENT, WEST DIDSBURY, MANCHESTER, M20 2YJ		
Title:	005 CHERRY PICKER & CRANE LOCATION		
Project:	NTQ		
Purpose of Issue:	CONSTRUCTION		
EE Cell ID:	39053	MBNL Cell ID:	MAN560
3UK Cell ID:	-		
Master Drawing No:			Issue:
1664166_MAN560_39053_M004			A3

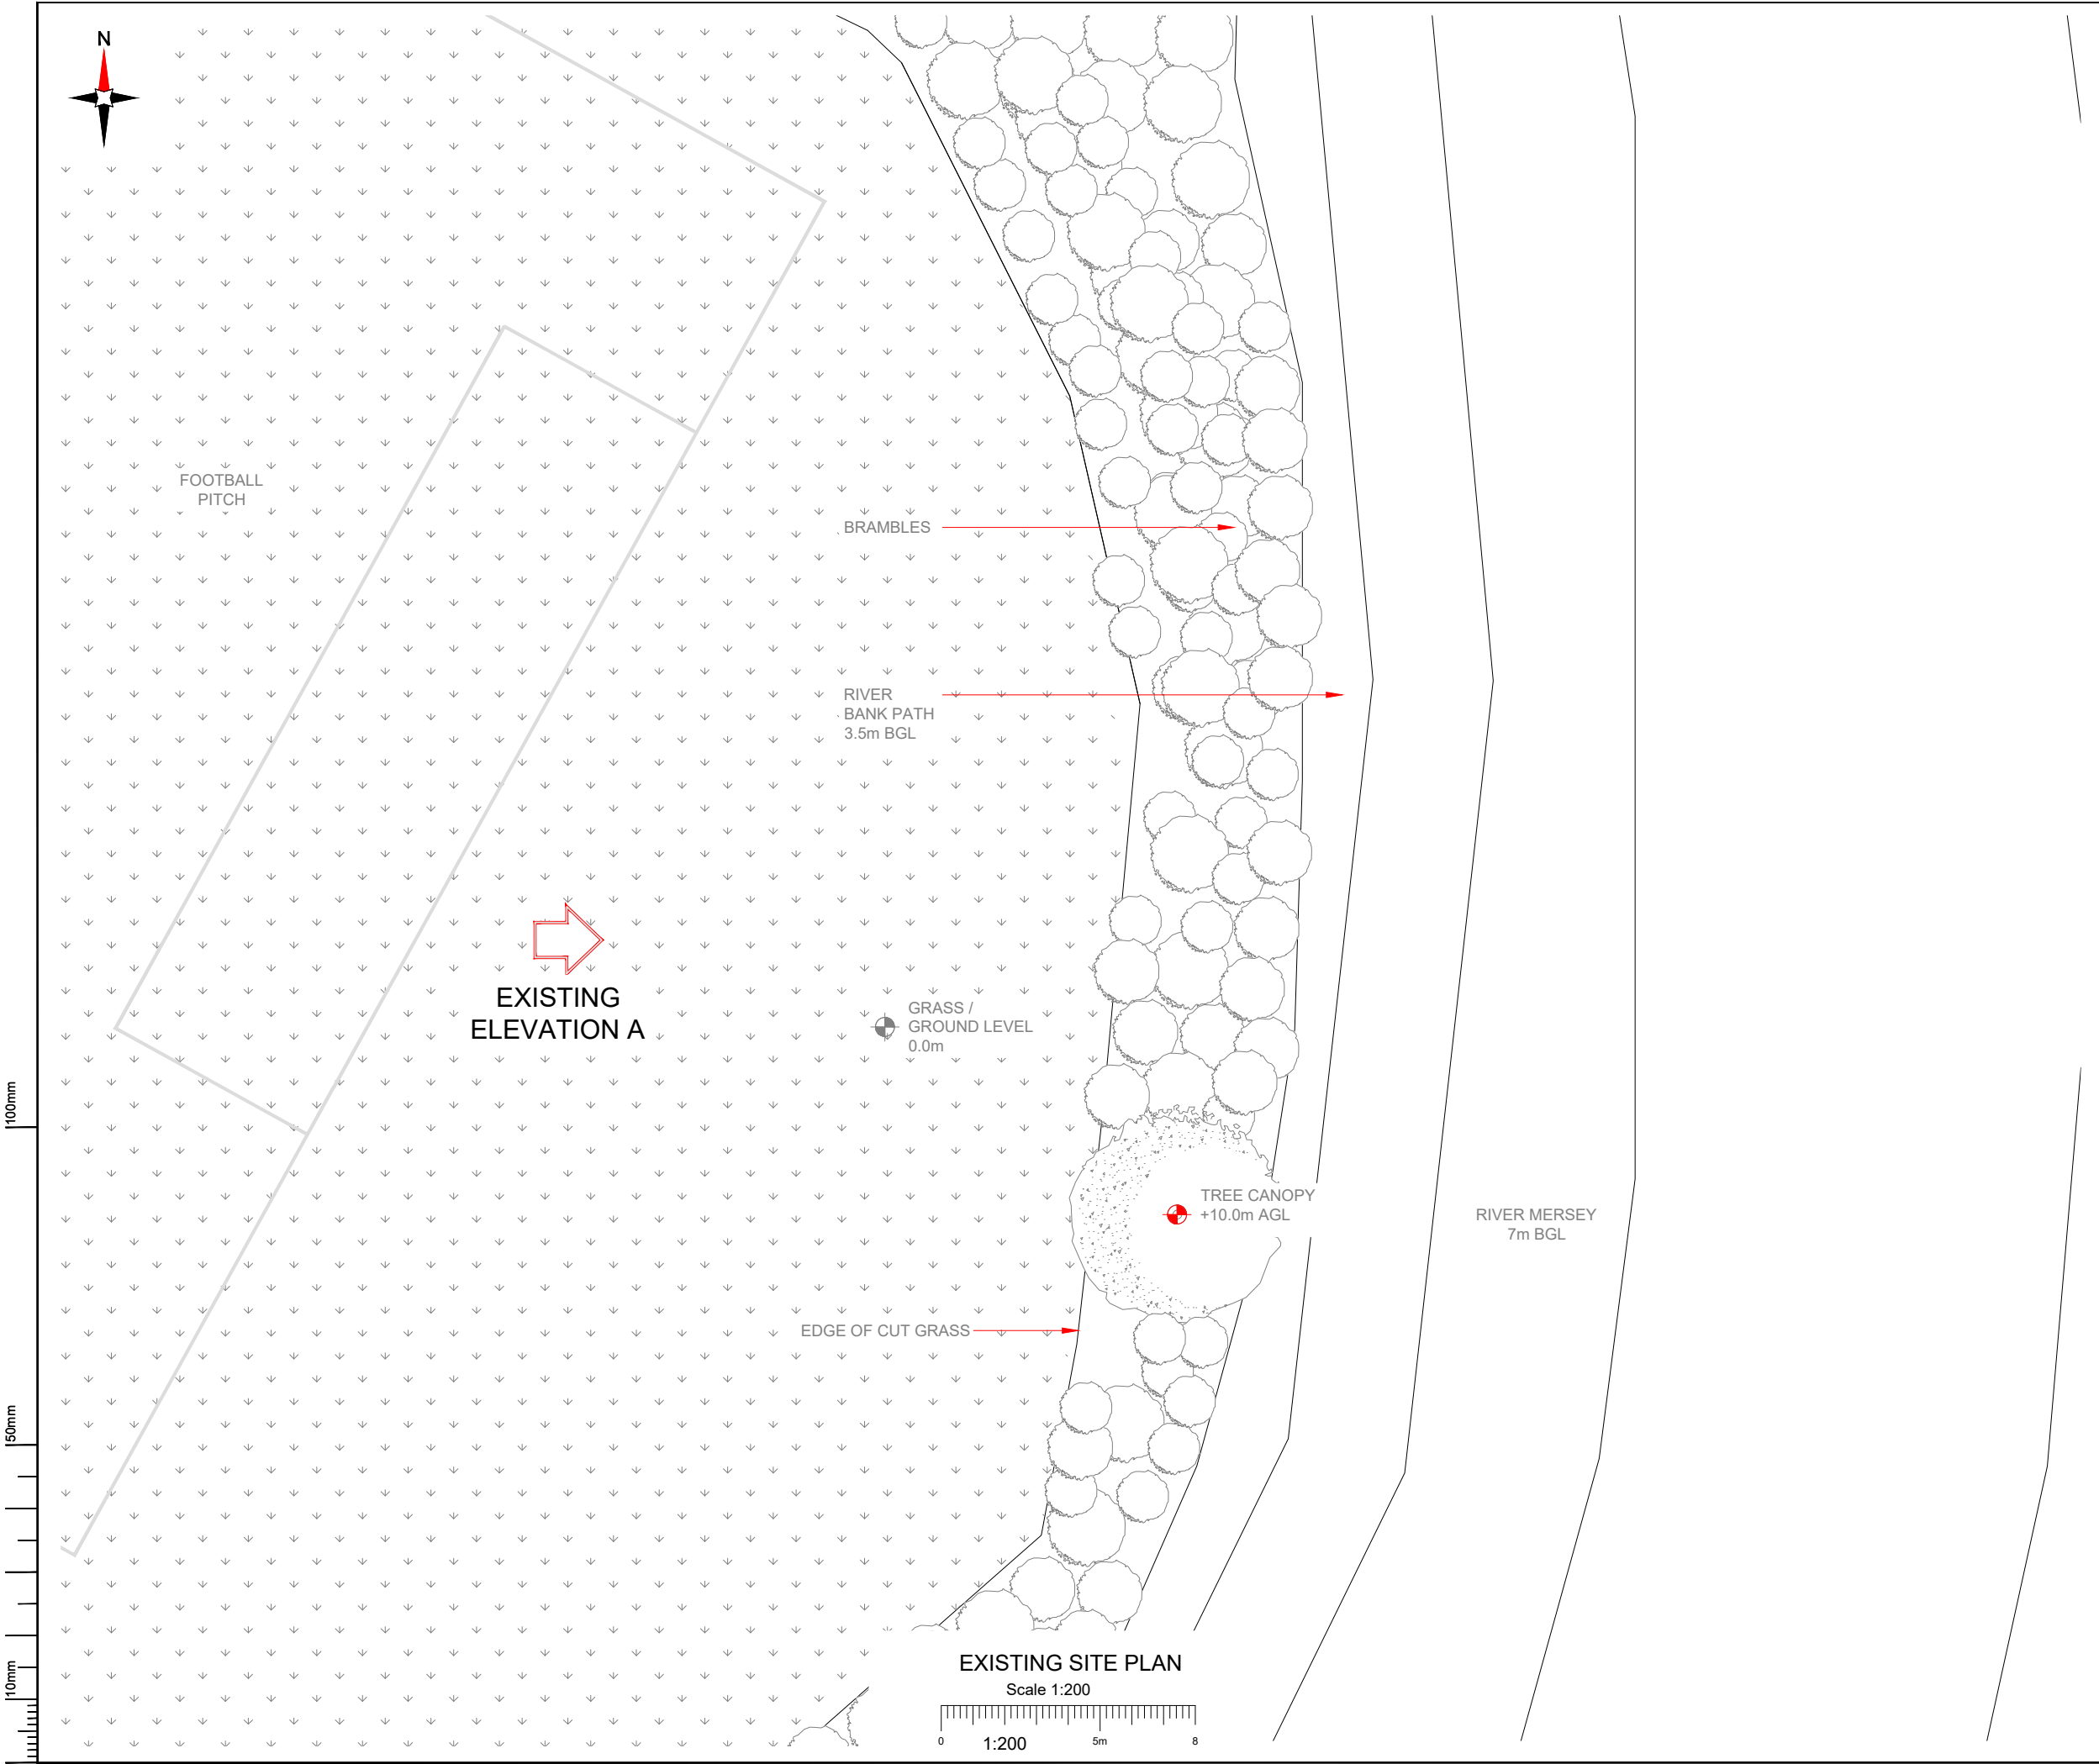

NOTES:

1. ALL DIMENSIONS IN MM UNLESS OTHERWISE NOTED.

Master:	MBNL / EE / H3G:	Project:	Purpose of Issue:	Issue:
M004	MBNL	NTQ	Construction	A3
Date:	03/05/2022	Revision / Upgrade Description:		
Drawn:	D.PARTON	Tower Type & position Amended		
Checked:	A.FANNING			
Approved:	P.CONVERY			
Master:	MBNL / EE / H3G:	Project:	Purpose of Issue:	Issue:
M003	MBNL	NTQ	Construction	A2
Date:	15/03/22	Revision / Upgrade Description:		
Drawn:	L.COLEBOURN	Site location amended		
Checked:	A.FANNING			
Approved:	P.CONVERY			
Master:	MBNL / EE / H3G:	Project:	Purpose of Issue:	Issue:
M002	MBNL	NTQ	Construction	A1
Date:	04/03/22	Revision / Upgrade Description:		
Drawn:	A.FANNING	Construction Issue		
Checked:	J. CAMPBELL			
Approved:	J. CAMPBELL			
Master:	MBNL / EE / H3G:	Project:	Purpose of Issue:	Issue:
M001	MBNL	NTQ	Planning	A
Date:	13/01/22	Revision / Upgrade Description:		
Drawn:	J. BOOTE	First Issue		
Checked:	J. STOCKDALE			
Approved:	J. STOCKDALE			

Hutchison 3G UK Limited
Star House, 20 Grenfell Road
Maidenhead, SL6 1EH
Tel: 01628 765 000
Fax: 01628 765 001

H3G Base Station Information line:
0845 6043000
Available 8am-8pm Monday to Friday

Hatfield Business Park
Hatfield
Hertfordshire
AL10 9BW

Tel: 01707 315000
Fax: 01707 319001

Mobile Broadband Network Limited
Sixth Floor, Thames Tower, Station Road, Reading, RG1 1LX

Design Consultant & Principal Contractor:

WHP Telecoms
Unit 1 Maple Park,
Low Fields Avenue, Leeds
LS12 6HH

Tel: 01133023550
e-mail: info@whptelecoms.com

Site Name:

MERSEY BANK TEMP

Site ID:

1664166

Address:

**MERSEY BANK PLAYING FIELDS,
MERSEY CRESCENT,
WEST DIDSBURY,
MANCHESTER,
M20 2YJ**

Title:

100 EXISTING SITE PLAN

Project:

NTQ

Purpose of Issue:

CONSTRUCTION

EE Cell ID:	MBNL Cell ID:	3UK Cell ID:
39053	MAN560	-

Master Drawing No:

1664166_MAN560_39053_M004


Issue:

A3

100mm


150mm

10mm

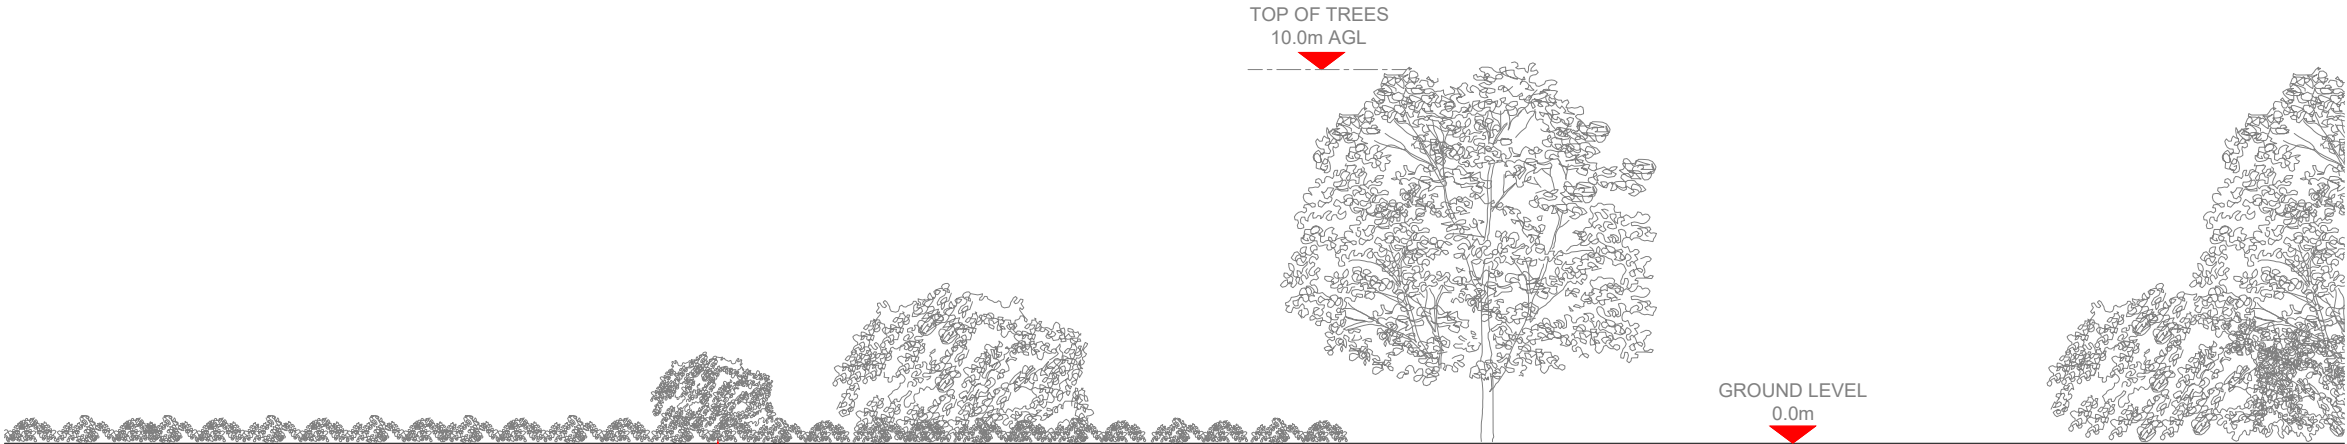

EXISTING ELEVATION A

 Scale 1:200



- NOTES:
- ALL DIMENSIONS IN MM UNLESS OTHERWISE NOTED.

Master:	MBNL / EE / H3G:	Project:	Purpose of Issue:	Issue:
M004	MBNL	NTQ	Construction	A3
Date:	03/05/2022	Revision / Upgrade Description:		
Drawn:	D.PARTON	Tower Type & position Amended		
Checked:	A.FANNING			
Approved:	P.CONVERY			
Master:	MBNL / EE / H3G:	Project:	Purpose of Issue:	Issue:
M003	MBNL	NTQ	Construction	A2
Date:	15/03/22	Revision / Upgrade Description:		
Drawn:	L.COLEBOURN	Site location amended		
Checked:	A.FANNING			
Approved:	P.CONVERY			
Master:	MBNL / EE / H3G:	Project:	Purpose of Issue:	Issue:
M002	MBNL	NTQ	Construction	A1
Date:	04/03/22	Revision / Upgrade Description:		
Drawn:	A.FANNING	Construction Issue		
Checked:	J.CAMPBELL			
Approved:	J.CAMPBELL			
Master:	MBNL / EE / H3G:	Project:	Purpose of Issue:	Issue:
M001	MBNL	NTQ	Planning	A
Date:	13/01/22	Revision / Upgrade Description:		
Drawn:	J.BOOTE	First Issue		
Checked:	J.STOCKDALE			
Approved:	J.STOCKDALE			



Hutchison 3G UK Limited
Star House, 20 Grenfell Road
Maidenhead, SL6 1EH
Tel: 01628 765 000
Fax: 01628 765 001



Hatfield Business Park
Hatfield
Hertfordshire
AL10 9BW
Tel: 01707 315000
Fax: 01707 319001



Mobile Broadband Network Limited
Sixth Floor, Thames Tower, Station Road, Reading, RG1 1LX

Design Consultant & Principal Contractor:



WHP Telecoms
Unit 1 Maple Park,
Low Fields Avenue, Leeds
LS12 6HH

Tel: 01133023550
e-mail: info@whptelecoms.com

Site Name:
MERSEY BANK TEMP

Site ID:
1664166


Address:
MERSEY BANK PLAYING FIELDS,
MERSEY CRESCENT,
WEST DIDSBURY,
MANCHESTER,
M20 2YJ

Title:
150 EXISTING ELEVATION A

Project:
NTQ

Purpose of Issue:
CONSTRUCTION

EE Cell ID:	MBNL Cell ID:	3UK Cell ID:
39053	MAN560	-
Master Drawing No:		Issue:
1664166_MAN560_39053_M004		A3

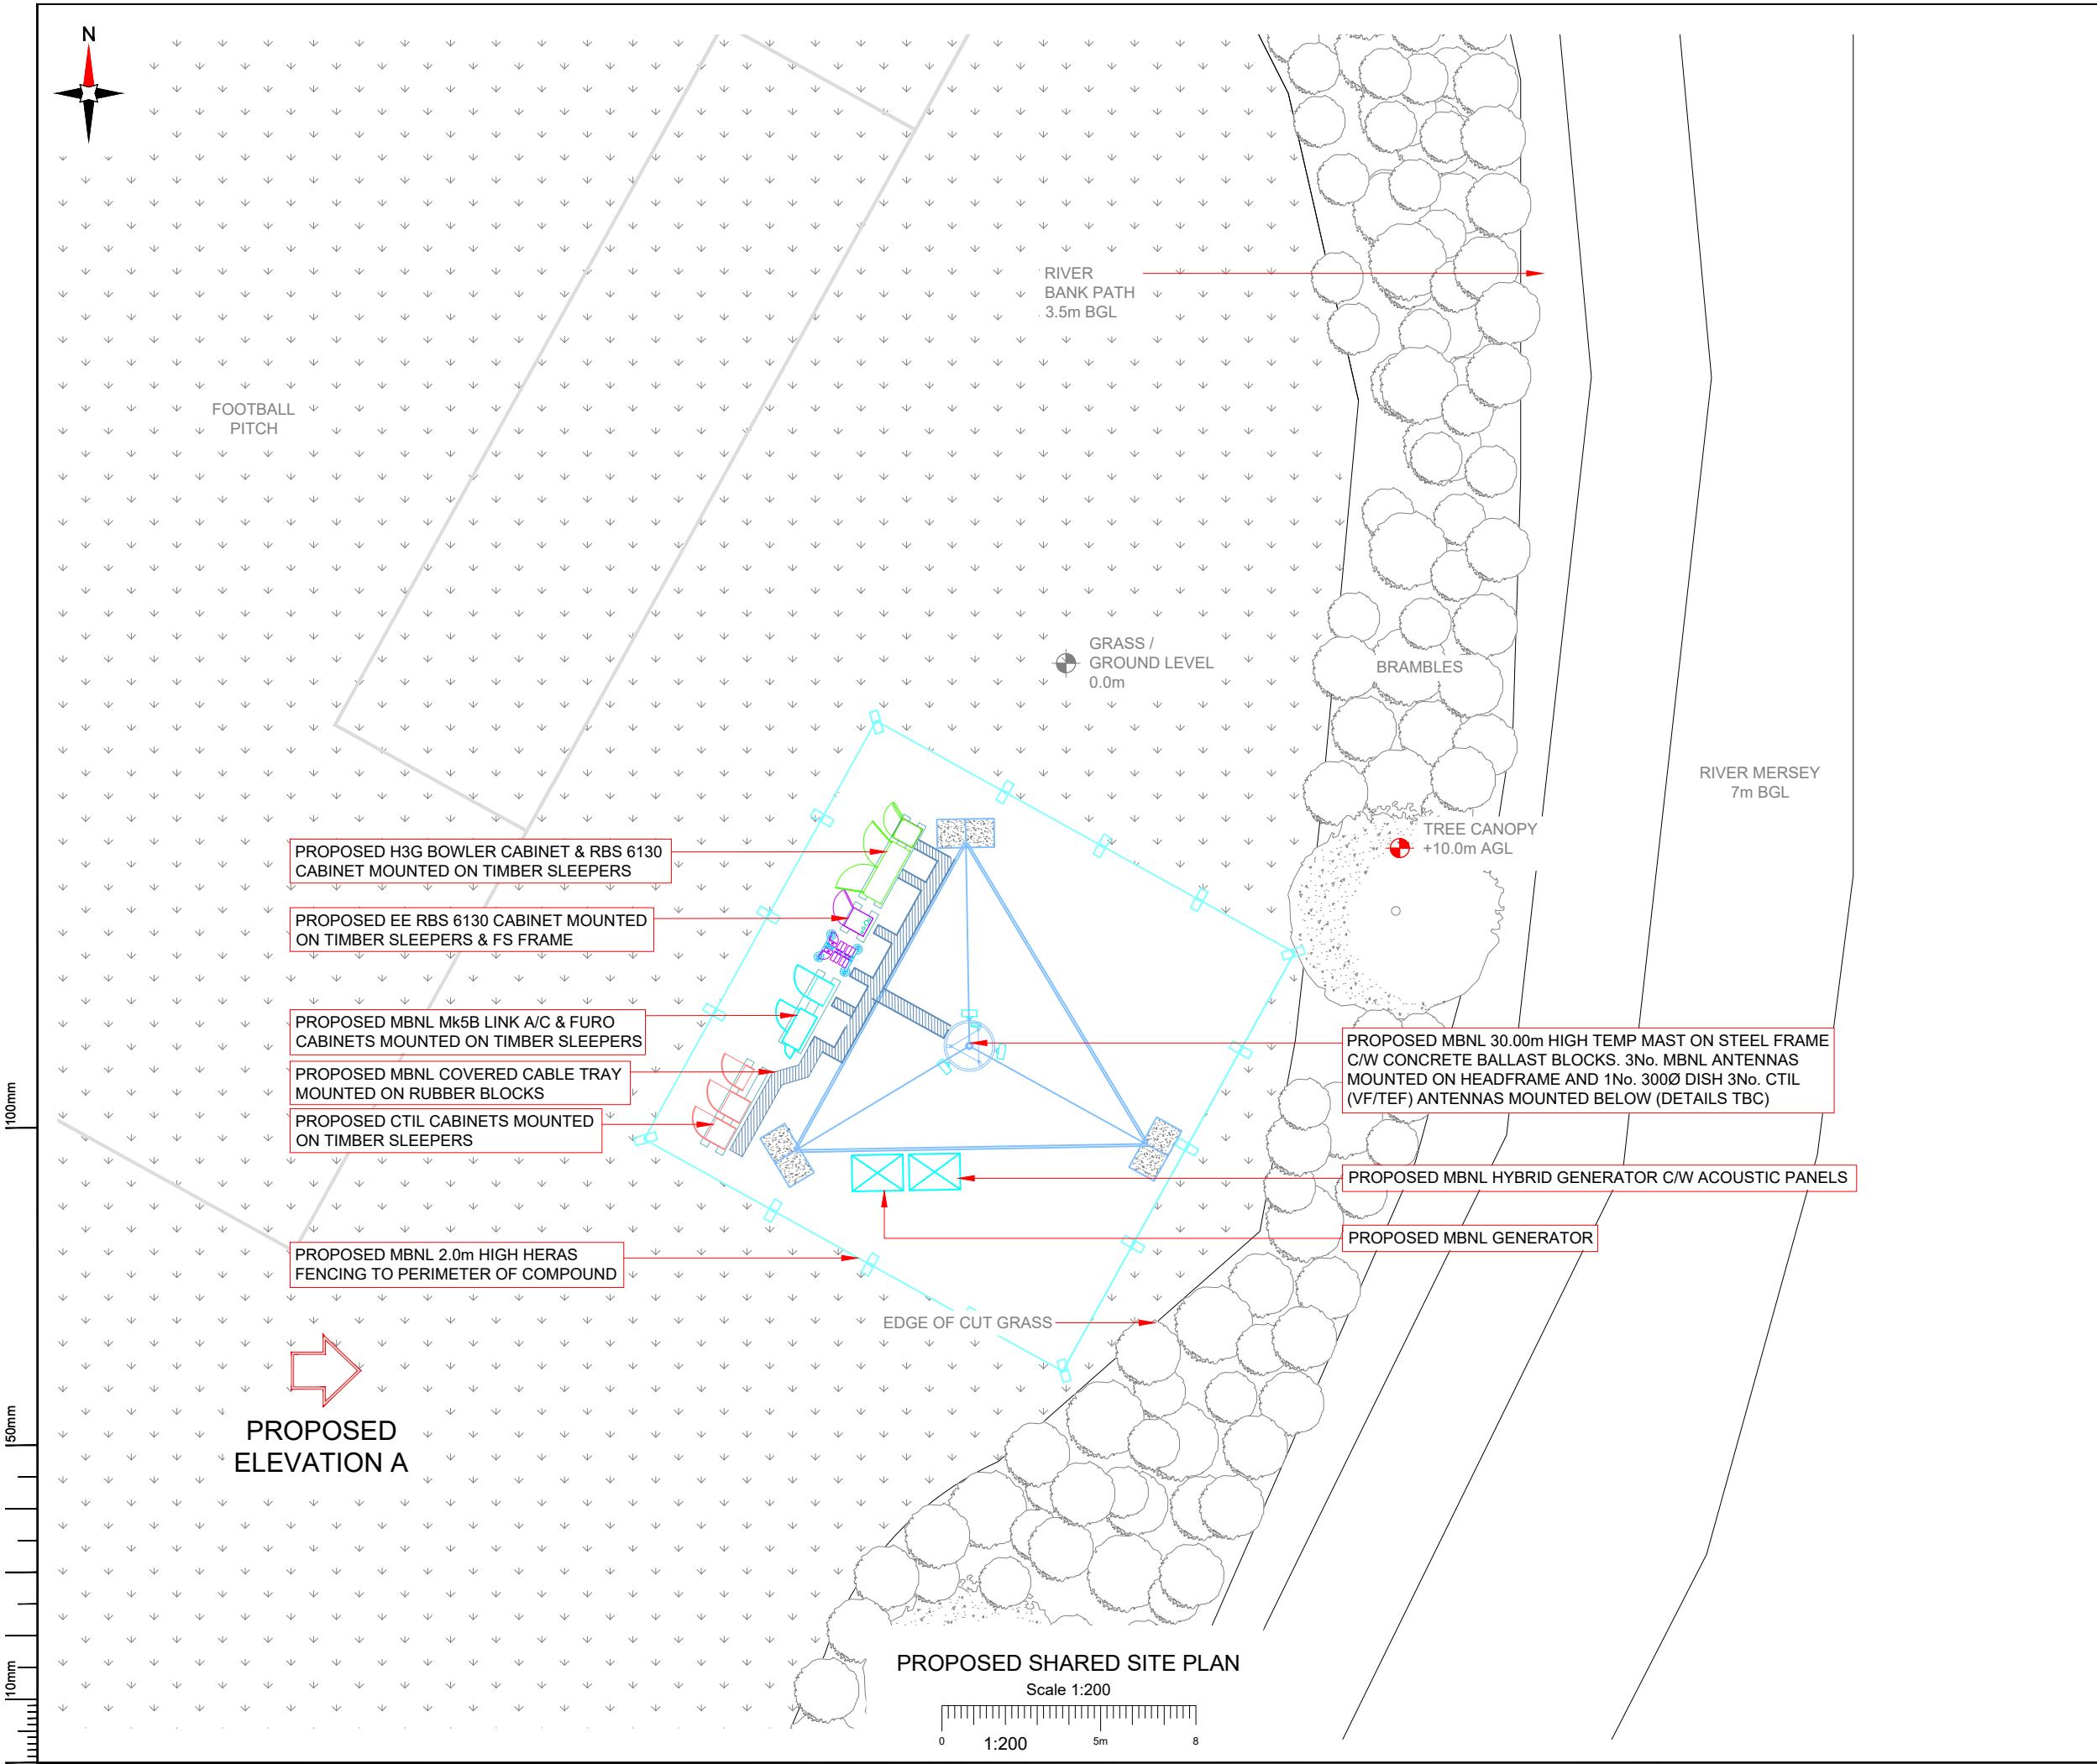

NOTES:

1. ALL DIMENSIONS IN MM UNLESS OTHERWISE NOTED.

SHARED CONFIGURATION SITE	
CONFIG TYPE	TEMP B

Master:	MBNL / EE / H3G:	Project:	Purpose of Issue:	Issue:
M004	MBNL	NTQ	Construction	A3
Date:	03/05/2022	Revision / Upgrade Description:		
Drawn:	D.PARTON	Tower Type & position Amended		
Checked:	A.FANNING			
Approved:	P.CONVERY			
Master:	MBNL / EE / H3G:	Project:	Purpose of Issue:	Issue:
M003	MBNL	NTQ	Construction	A2
Date:	15/03/22	Revision / Upgrade Description:		
Drawn:	L.COLEBOURN	Site location amended		
Checked:	A.FANNING			
Approved:	P.CONVERY			
Master:	MBNL / EE / H3G:	Project:	Purpose of Issue:	Issue:
M002	MBNL	NTQ	Construction	A1
Date:	04/03/22	Revision / Upgrade Description:		
Drawn:	A.FANNING	Construction Issue		
Checked:	J.CAMPBELL			
Approved:	J.CAMPBELL			
Master:	MBNL / EE / H3G:	Project:	Purpose of Issue:	Issue:
M001	MBNL	NTQ	Planning	A
Date:	13/01/22	Revision / Upgrade Description:		
Drawn:	J. BOOTE	First Issue		
Checked:	J. STOCKDALE			
Approved:	J. STOCKDALE			

Hutchison 3G UK Limited
Star House, 20 Grenfell Road
Maidenhead, SL6 1EH
Tel: 01628 765 000
Fax: 01628 765 001

H3G Base Station Information line:
0845 6043000
Available 8am-8pm Monday to Friday

Hatfield Business Park
Hatfield
Hertfordshire
AL10 9BW

Tel: 01707 315000
Fax: 01707 319001

MBNL Mobile Broadband Network Limited
Sixth Floor, Thames Tower, Station Road, Reading, RG1 1LX

Design Consultant & Principal Contractor:

WHP Telecoms
Unit 1 Maple Park,
Low Fields Avenue, Leeds
LS12 6HH

Tel: 01133023550
e-mail: info@whptelecoms.com

Site Name:

MERSEY BANK TEMP

Site ID:

1664166

Address:

MERSEY BANK PLAYING FIELDS,
MERSEY CRESCENT,
WEST DIDSBURY,
MANCHESTER,
M20 2YJ

Title:

200 PROPOSED SHARED SITE PLAN

Project:

NTQ

Purpose of Issue:

CONSTRUCTION


EE Cell ID:	MBNL Cell ID:	3UK Cell ID:
39053	MAN560	-

Master Drawing No:

1664166_MAN560_39053_M004

Issue:

A3

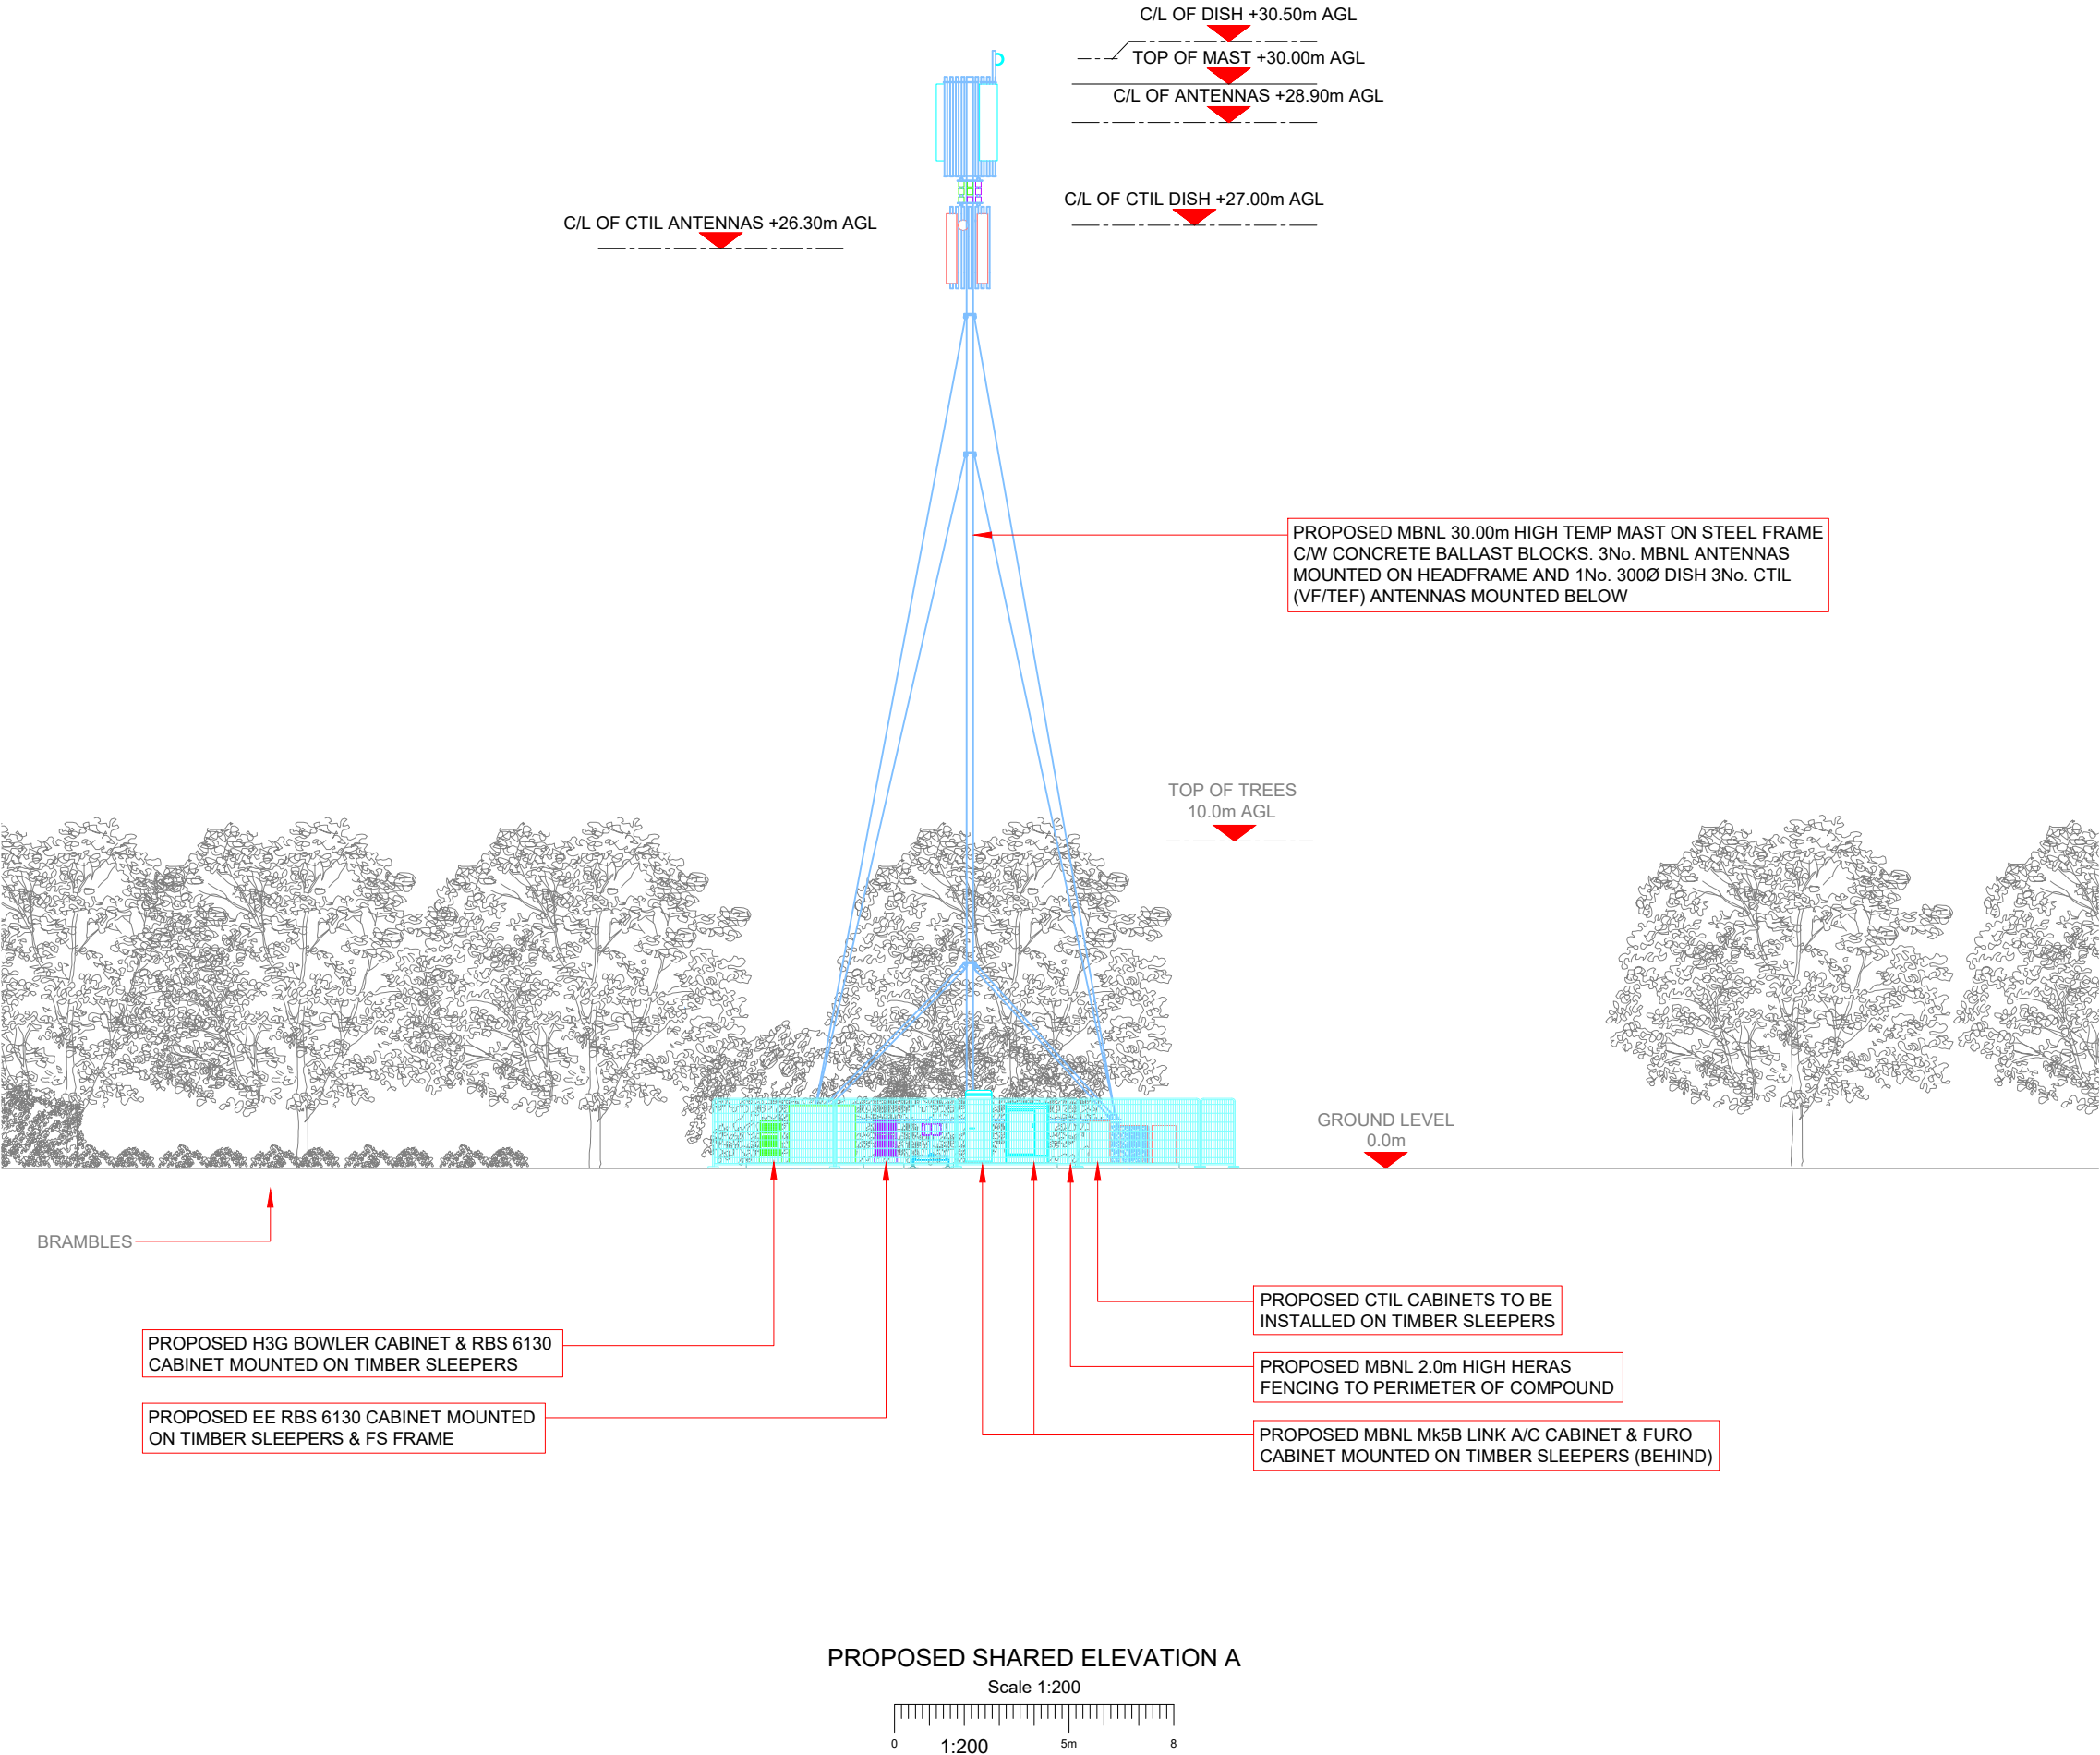

NOTES:

1. ALL DIMENSIONS IN MM UNLESS OTHERWISE NOTED.

SHARED CONFIGURATION SITE

CONFIG TYPETEMP B

Master:	MBNL / EE / H3G:	Project:	Purpose of Issue:	Issue:
M004	MBNL	NTQ	Construction	A3
Date:	03/05/2022	Revision / Upgrade Description:		
Drawn:	D.PARTON	Tower Type & position Amended		
Checked:	A.FANNING			
Approved:	P.CONVERY			
Master:	MBNL / EE / H3G:	Project:	Purpose of Issue:	Issue:
M003	MBNL	NTQ	Construction	A2
Date:	15/03/22	Revision / Upgrade Description:		
Drawn:	L.COLEBOURN	Site location amended		
Checked:	A.FANNING			
Approved:	P.CONVERY			
Master:	MBNL / EE / H3G:	Project:	Purpose of Issue:	Issue:
M002	MBNL	NTQ	Construction	A1
Date:	04/03/22	Revision / Upgrade Description:		
Drawn:	A.FANNING	Construction Issue		
Checked:	J.CAMPBELL			
Approved:	J.CAMPBELL			
Master:	MBNL / EE / H3G:	Project:	Purpose of Issue:	Issue:
M001	MBNL	NTQ	Planning	A
Date:	13/01/22	Revision / Upgrade Description:		
Drawn:	J.BOOTE	First Issue		
Checked:	J.STOCKDALE			
Approved:	J.STOCKDALE			



Hutchison 3G UK Limited
Star House, 20 Grenfell Road
Maidenhead, SL6 1EH
Tel: 01628 765 000
Fax: 01628 765 001

H3G Base Station Information line:
0845 6043000
Available 8am-8pm Monday to Friday



Hatfield Business Park
Hatfield
Hertfordshire
AL10 9BW

Tel: 01707 315000
Fax: 01707 319001

MBNL

Mobile Broadband Network Limited
Sixth Floor, Thames Tower, Station Road, Reading, RG1 1LX

Design Consultant & Principal Contractor:



WHP Telecoms
Unit 1 Maple Park,
Low Fields Avenue, Leeds
LS12 6HH

Tel: 01133023550
e-mail: info@whptelecoms.com

Site Name:

MERSEY BANK TEMP

Site ID:

1664166

Address:

MERSEY BANK PLAYING FIELDS,
MERSEY CRESCENT,
WEST DIDSBURY,
MANCHESTER,
M20 2YJ

Title:

250 PROPOSED SHARED ELEVATION A

Project:

NTQ

Purpose of Issue:

CONSTRUCTION

EE Cell ID:

39053

MBNL Cell ID:

MAN560

3UK Cell ID:

-

Master Drawing No:

1664166_MAN560_39053_M004

Issue:

A3

Max Configuration Antenna Aperture Schedule & RF Equipment Capacity																	
Antenna Aperture ID	Antenna Aperture Size (Length x Width x Depth)	Aperture Height C/L	Aperture Max Weight (kg)	Proposed Bearing	Tech:	Operator: Shared/ EE/H3G	Antenna Aperture Coordinates		RRU No. Max Size & Weight L=300mm W=400mm D=150mm Weight=25kg	MHA No. Max Size & Weight L=300mm W=300mm D=150mm Weight=10kg	Main Feeder			BOB Max Size & Weight (300x300x250mm & 5kg)		Active Router No. Max Size & Weight (370x260x150mm & 10kg)	Passive Router No. Max Size & Weight (350x220x150mm & 10kg)
							Eastings	Northings			Size	Length	No.	No. Top	No. Bottom		
A1	2200x550x350mm	28.9m	100kg	0°	2G/3G/4G	EE/H3G	-	-	-	4	LDF6-50	35m	8	-	-	-	-
B1	2200x550x350mm	28.9m	100kg	100°	2G/3G/4G	EE/H3G	-	-	-	4	LDF6-50	35m	8	-	-	-	-
C1	2200x550x350mm	28.9m	100kg	230°	2G/3G/4G	EE/H3G	-	-	-	4	LDF6-50	35m	8	-	-	-	-

Passive Infrastructure Equipment Capacity		
A	B	C
TEMP B	TEMP B	TEMP B

STATUS KEY:

Installed:

Retain:

Relocate:

Remove:

Proposed:

Existing

Existing and to remain

Existing and to be relocated

Existing to be removed from site

New on site

Master:	MBNL / EE / H3G:	Project:	Purpose of Issue:	Issue:
M004	MBNL	NTQ	Construction	A3
Date:	03/05/2022	Revision / Upgrade Description:		
Drawn:	D.PARTON	Tower Type & position Amended		
Checked:	A.FANNING			
Approved:	P.CONVERY			
Master:	MBNL / EE / H3G:	Project:	Purpose of Issue:	Issue:
M003	MBNL	NTQ	Construction	A2
Date:	15/03/22	Revision / Upgrade Description:		
Drawn:	L.COLEBOURN	Site location amended		
Checked:	A.FANNING			
Approved:	P.CONVERY			
Master:	MBNL / EE / H3G:	Project:	Purpose of Issue:	Issue:
M002	MBNL	NTQ	Construction	A1
Date:	04/03/22	Revision / Upgrade Description:		
Drawn:	A. FANNING	Construction Issue		
Checked:	J. CAMPBELL			
Approved:	J. CAMPBELL			
Master:	MBNL / EE / H3G:	Project:	Purpose of Issue:	Issue:
M001	MBNL	NTQ	Planning	A
Date:	13/01/22	Revision / Upgrade Description:		
Drawn:	J. BOOTE	First Issue		
Checked:	J. STOCKDALE			
Approved:	J. STOCKDALE			



Hutchison 3G UK Limited
Star House, 20 Grenfell Road
Maidenhead, SL6 1EH
Tel: 01628 765 000
Fax: 01628 765 001

H3G Base Station Information line:
0845 6043000
Available 8am-8pm Monday to Friday



Hatfield Business Park
Hatfield
Hertfordshire
AL10 9BW

Tel: 01707 315000
Fax: 01707 319001



Mobile Broadband Network Limited
Sixth Floor, Thames Tower, Station Road, Reading, RG1 1LX

Design Consultant & Principal Contractor:



WHP Telecoms
Unit 1 Maple Park,
Low Fields Avenue, Leeds
LS12 6HH

Tel: 01133023550
e-mail: info@whptelecoms.com

Site Name:

MERSEY BANK TEMP

Site ID:

1664166

Address:

MERSEY BANK PLAYING FIELDS,
MERSEY CRESCENT,
WEST DIDSBURY,
MANCHESTER,
M20 2YJ

Title:

304 MAX CONFIGURATION ANTENNA
SCHEDULE & LINE CONFIGURATION

Project:

NTQ

Purpose of Issue:

CONSTRUCTION

EE Cell ID:
39053

MBNL Cell ID:
MAN560

3UK Cell ID:
-

Master Drawing No:

1664166_MAN560_39053_M004

Issue:

A3

100mm

50mm

10mm

100mm

150mm

10mm

Support Structure Schedule										
Structure ID	Status	Equipment Description / Type	Structure Manufacturer	Height AGL (m)	Colour (RAL Colour)	Headframe Details	Foundation / Support Grillage / Host Structure Details	Support Bolt Details	MBNL Ref:	Comments
ST1	PROPOSED	TEMP MAST	TBC	30.00m	GALVANISED	LEG-MOUNTED	BALLAST FRAME	-	-	SEE NOTE BELOW

MAST MOUNTED ON STEEL FRAME C/W PRECAST CONCRETE BALLAST BLOCKS. FRAME FOOTPRINT (4mx4m) SITS ON ~200mm HIGH 5mx5m COMPACTED STONE SUB-BASE. MAST IS CLIMBABLE WITH ANTI-CLIMB FITTED AT ~5m AGL. PROPOSED CTIL 3No. ANTENNAS & 1No. DISH TO BE MOUNTED BELOW MBNL.

Equipment Schedule													
Equipment ID	Quantity	Status	Equipment Description / Type	Equipment Manufacturer	Dimensions (W x D x H)	Weight (kg)	Colour (RAL Colour)	Material	Location	Power	Power cable length (m)	MBNL Ref:	Comments
CAB1	1	Proposed	MK5B LINK AC	-	1200x600x1600	-	RAL 7035	STEEL	OUTDOOR	-	-	-	
CAB2	1	Proposed	EE/H3G - FURO	ICD	750x600x2100	-	RAL 7035	STEEL	OUTDOOR	-	-	-	
CAB3	1	Proposed	EE - RBS6130	-	650x700x950	-	RAL 7035	STEEL	OUTDOOR	-	-	-	-
CAB4	1	Proposed	H3g - RBS6130	-	650x700x950	-	RAL 7035	STEEL	OUTDOOR	-	-	-	-
CAB5	1	Proposed	H3G - BOWLER	COMMSCOPE	1900x600x1752	-	RAL 7035	STEEL	OUTDOOR	-	-	-	
CAB6	1	Proposed	GENERATOR	-	TBC	-	TBC	STEEL	OUTDOOR	-	-	-	DETAILS / SIZE TBC
CAB7	1	Proposed	HYBRID GENERATOR	-	TBC	-	TBC	STEEL	OUTDOOR	-	-	-	DETAILS / SIZE TBC
CTIL	1	Proposed	BTS3900AL	-	770x750x1725	-	RAL 7035	STEEL	OUTDOOR	-	-	-	-
CTIL	1	Proposed	BTS3900AL	-	770x750x1725	-	RAL 7035	STEEL	OUTDOOR	-	-	-	-
CTIL	1	Proposed	METER CABINET	-	655x255x1015	-	RAL 7035	STEEL	OUTDOOR	-	-	-	-
-	6	Proposed	BOB MK2	-	-	-	RAL 7035	-	-	-	-	-	EE -L800/GL1800/L2100 & L2600
-	3	Proposed	RD0800-H401	-	-	-	RAL 7035	-	FS FRAME	-	-	-	EE - GL1800/L2100 & L2600
-	3	Proposed	RD0725-H4-06	-	-	-	RAL 7035	-	SUPPORT POLE	-	-	-	EE - GL1800/L2100 & L2600
-	3	Proposed	ERS 2262	ERICSSON	-	-	RAL 7035	STEEL	FS FRAME	-	-	-	EE - 800
-	3	Proposed	ERS 2260	ERICSSON	-	-	RAL 7035	STEEL	FS FRAME	-	-	-	EE - GL1800/2100
-	3	Proposed	ERS 4419	ERICSSON	-	-	RAL 7035	STEEL	FS FRAME	-	-	-	EE - 2600
-	3	Proposed	UCU MK2	-	-	-	RAL 7035	-	FURO	-	-	-	H3G U2100 & EE U2100
-	3	Proposed	RD0569-H4-01	-	-	-	RAL 7035	-	SUPPORT POLE	-	-	-	EE & H3G 800
-	3	Proposed	E14R00P41	-	-	-	RAL 7035	-	SUPPORT POLE	-	-	-	EE & H3G 800
-	3	Proposed	RD0448-H412	-	-	-	RAL 7035	-	SUPPORT POLE	-	-	-	H3G - U2100 & EE U2100
-	3	Proposed	ERS 2460	ERICSSON	398x190x553	37.5kg	RAL 7035	STEEL	BOWLER	-	-	-	H3G - 800
-	3	Proposed	ERS 4480	ERICSSON	398x190x553	32kg	RAL 7035	STEEL	BOWLER	-	-	-	H3G - 1800/2100
-	3	Proposed	ERS 2012	ERICSSON	342x131x42	17kg	RAL 7035	STEEL	BOWLER	-	-	-	H3G - 1400
-	3	Proposed	KRF102 452	KATHREIN	-	-	-	-	BOWLER	-	-	-	H3G - 1400 FILTER
-	3	Proposed	Kathrein 78211533	-	-	-	RAL 7035	-	BOWLER	-	-	-	H3G -1400/1800/2100
-	3	Proposed	Kathrein 7821 1107	-	-	-	RAL 7035	-	SUPPORT POLE	-	-	-	H3G -1400/1800/2100
-	3	Proposed	RD0877-H4-06	-	-	-	RAL 7035	-	SUPPORT POLE	-	-	-	H3G - 700 & EE/H3G - 800

POWER SCHEDULE

Supply Status	Type	Supplier	Supply Type	Location	Comments
PROPOSED	GENERATOR	TBC	TBC	FENCED COMPOUND	C/W HYBRID (NOISE REDUCTION - NIGHT TIME RUNNING)

STATUS KEY:

Installed:

Retain:

Relocate:

Remove:

Proposed:

Existing

Existing and to remain

Existing and to be relocated

Existing to be removed from site

New on site

LOCATION KEY:

Outdoor:

Indoor:

Internal:

Located outside

Located within an equipment cabin or equipment room

located inside a cabinet or item of equipment

Master: M004	MBNL / EE / H3G: MBNL	Project: NTQ	Purpose of Issue: Construction	Issue: A3
Date: 03/05/2022	Revision / Upgrade Description: Tower Type & position Amended			
Drawn: D.PARTON				
Checked: A.FANNING				
Approved: P.CONVERY				
Master: M003	MBNL / EE / H3G: MBNL	Project: NTQ	Purpose of Issue: Construction	Issue: A2
Date: 15/03/22	Revision / Upgrade Description: Site location amended			
Drawn: L.COLEBOURN				
Checked: A.FANNING				
Approved: P.CONVERY				
Master: M002	MBNL / EE / H3G: MBNL	Project: NTQ	Purpose of Issue: Construction	Issue: A1
Date: 04/03/22	Revision / Upgrade Description: Construction Issue			
Drawn: A.FANNING				
Checked: J. CAMPBELL				
Approved: J. CAMPBELL				
Master: M001	MBNL / EE / H3G: MBNL	Project: NTQ	Purpose of Issue: Planning	Issue: A
Date: 13/01/22	Revision / Upgrade Description: First Issue			
Drawn: J. BOOTE				
Checked: J. STOCKDALE				
Approved: J. STOCKDALE				



Hutchison 3G UK Limited
Star House, 20 Grenfell Road
Maidenhead, SL6 1EH
Tel: 01628 765 000
Fax: 01628 765 001



Hatfield Business Park
Hatfield
Hertfordshire
AL10 9BW

Tel: 01707 315000
Fax: 01707 319001



Mobile Broadband Network Limited
Sixth Floor, Thames Tower, Station Road, Reading, RG1 1LX

Design Consultant & Principal Contractor:



WHP Telecoms
Unit 1 Maple Park,
Low Fields Avenue, Leeds
LS12 6HH

Tel: 01133023550
e-mail: info@whptelecoms.com

Site Name:		MERSEY BANK TEMP	
Site ID:		1664166	
Address:		MERSEY BANK PLAYING FIELDS, MERSEY CRESCENT, WEST DIDSBURY, MANCHESTER, M20 2YJ	
Title:		305 EQUIPMENT SCHEDULE & SUPPORT STRUCTURE DETAILS	
Project:		NTQ	
Purpose of Issue:		CONSTRUCTION	
EE Cell ID:	MBNL Cell ID:	3UK Cell ID:	
39053	MAN560	-	
Master Drawing No:			Issue:
1664166_MAN560_39053_M004			A3