


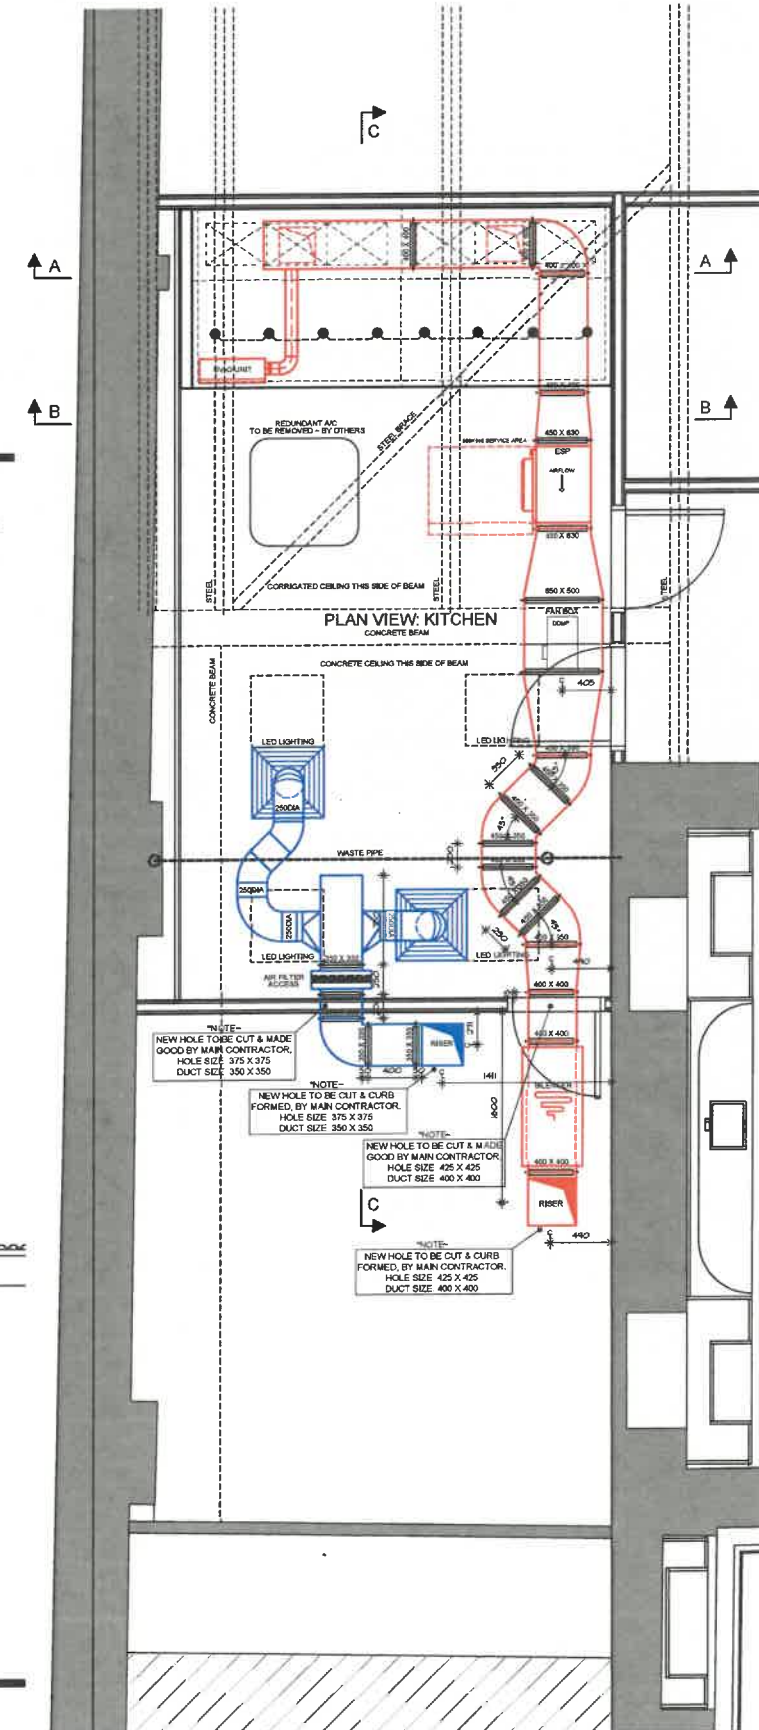

**FAN & ELECTRICAL DATA**

**KITCHEN EXTRACT FAN:**  
MANUFACTURER & MODEL: NICOTRA DDMF  
POWER SUPPLY: 230V-1PH  
ELECTRICAL LOADINGS: T.B.C  
CONTROLLER TYPE: POTENTIOMETER

**KITCHEN SUPPLY FAN:**  
MANUFACTURER & MODEL: N/A  
POWER SUPPLY: N/A  
ELECTRICAL LOADINGS: N/A  
CONTROLLER TYPE: N/A

PLAN VIEW: ROOF PLANT AREA

SECTION C-C ~ THROUGH FIRST FLOOR

LAYER KEY

|                     |                  |                 |
|---------------------|------------------|-----------------|
| FIRE RATED DUCTWORK | EXTRACT DUCTWORK | SUPPLY DUCTWORK |
|---------------------|------------------|-----------------|

**COPYRIGHT ©**  
This drawing is copyright and issued to you in confidence. It must not be copied, used or disclosed, in whole or in part, to third parties without our written permission. It remains the property of CYCLOHNE VENTILATION LIMITED and must not be used or reissued. ©  
**NOTE:** All dimensions are in millimetres unless stated otherwise. If in doubt ask. Do not scale from this drawing.

**DRAINING INFORMATION**  
The CAD drawing is plotted from file CY24-1250-001  
C:\Program Files\Autodesk\AutoCAD 2000\Drawings\Xenof\

STATUS

APPROVAL

|                                                 |        |                      |
|-------------------------------------------------|--------|----------------------|
| SUPPLY AIR SYSTEM ADDED<br>DUCTWORK ALTERATIONS | B<br>A | 06.12.24<br>14.11.24 |
| DESCRIPTION                                     | REV    | DATE                 |

**CYCLONE**  
VENTILATION

**Cyclone Ventilation Ltd.**  
UNIT 6, Ashfield Close, Whitehall Road  
Industrial Estate, Leeds, LS12 5JB.

Tel: 01132 632900  
email: [sales@cycloneventilation.co.uk](mailto:sales@cycloneventilation.co.uk)  
Web: [www.cycloneventilation.co.uk](http://www.cycloneventilation.co.uk)

CLIENT

## SALIX COMMERCIAL KITCHENS

PROJECT  
AP HOUSE, MANCHESTER

DRAWING

## NEW KITCHEN VENTILATION SYSTEM

|       |       |         |      |
|-------|-------|---------|------|
| SCALE | DRAWN | CHECKED | REV. |
|-------|-------|---------|------|

| SCALE     | DRAWN | CHECKED | REV. |
|-----------|-------|---------|------|
| 1:30 @ A1 | CJW   | RPW     | B    |

|      |         |          |
|------|---------|----------|
| DATE | JOB NO. | DWG. NO. |
|------|---------|----------|

|           |           |     |
|-----------|-----------|-----|
| JUNE 2024 | CV24-1250 | 001 |
|-----------|-----------|-----|

Original sheet size A1