
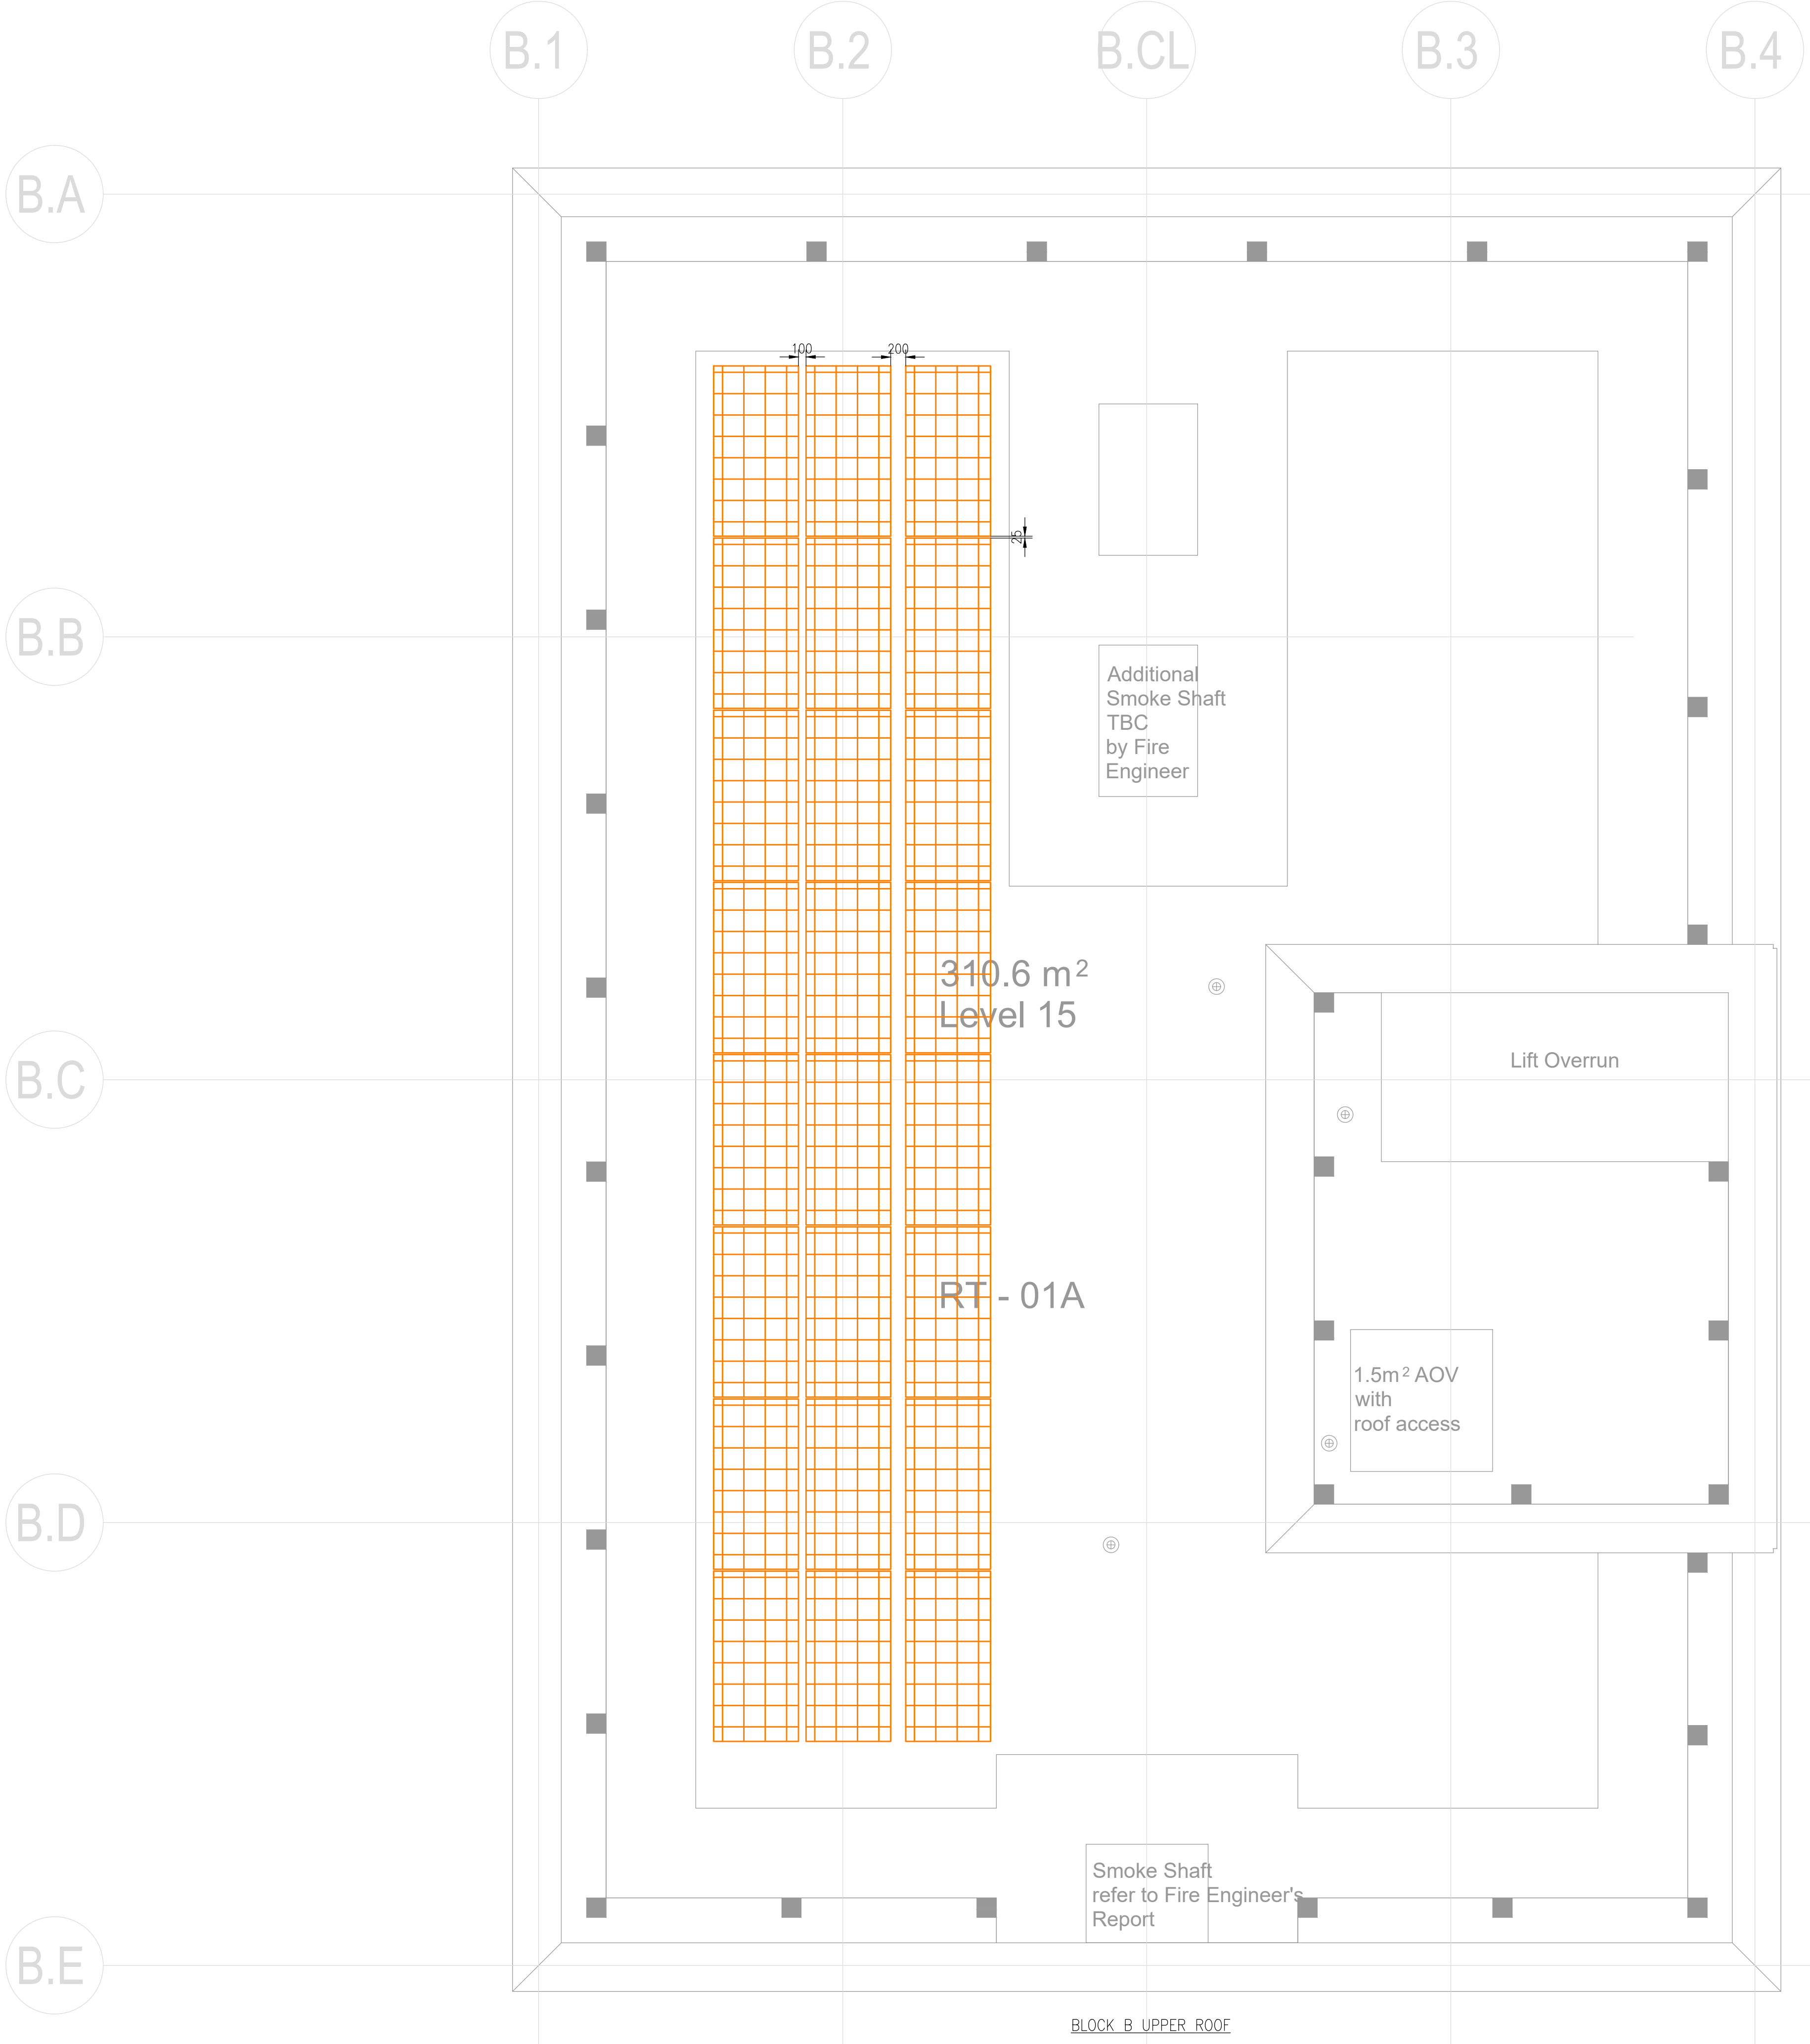


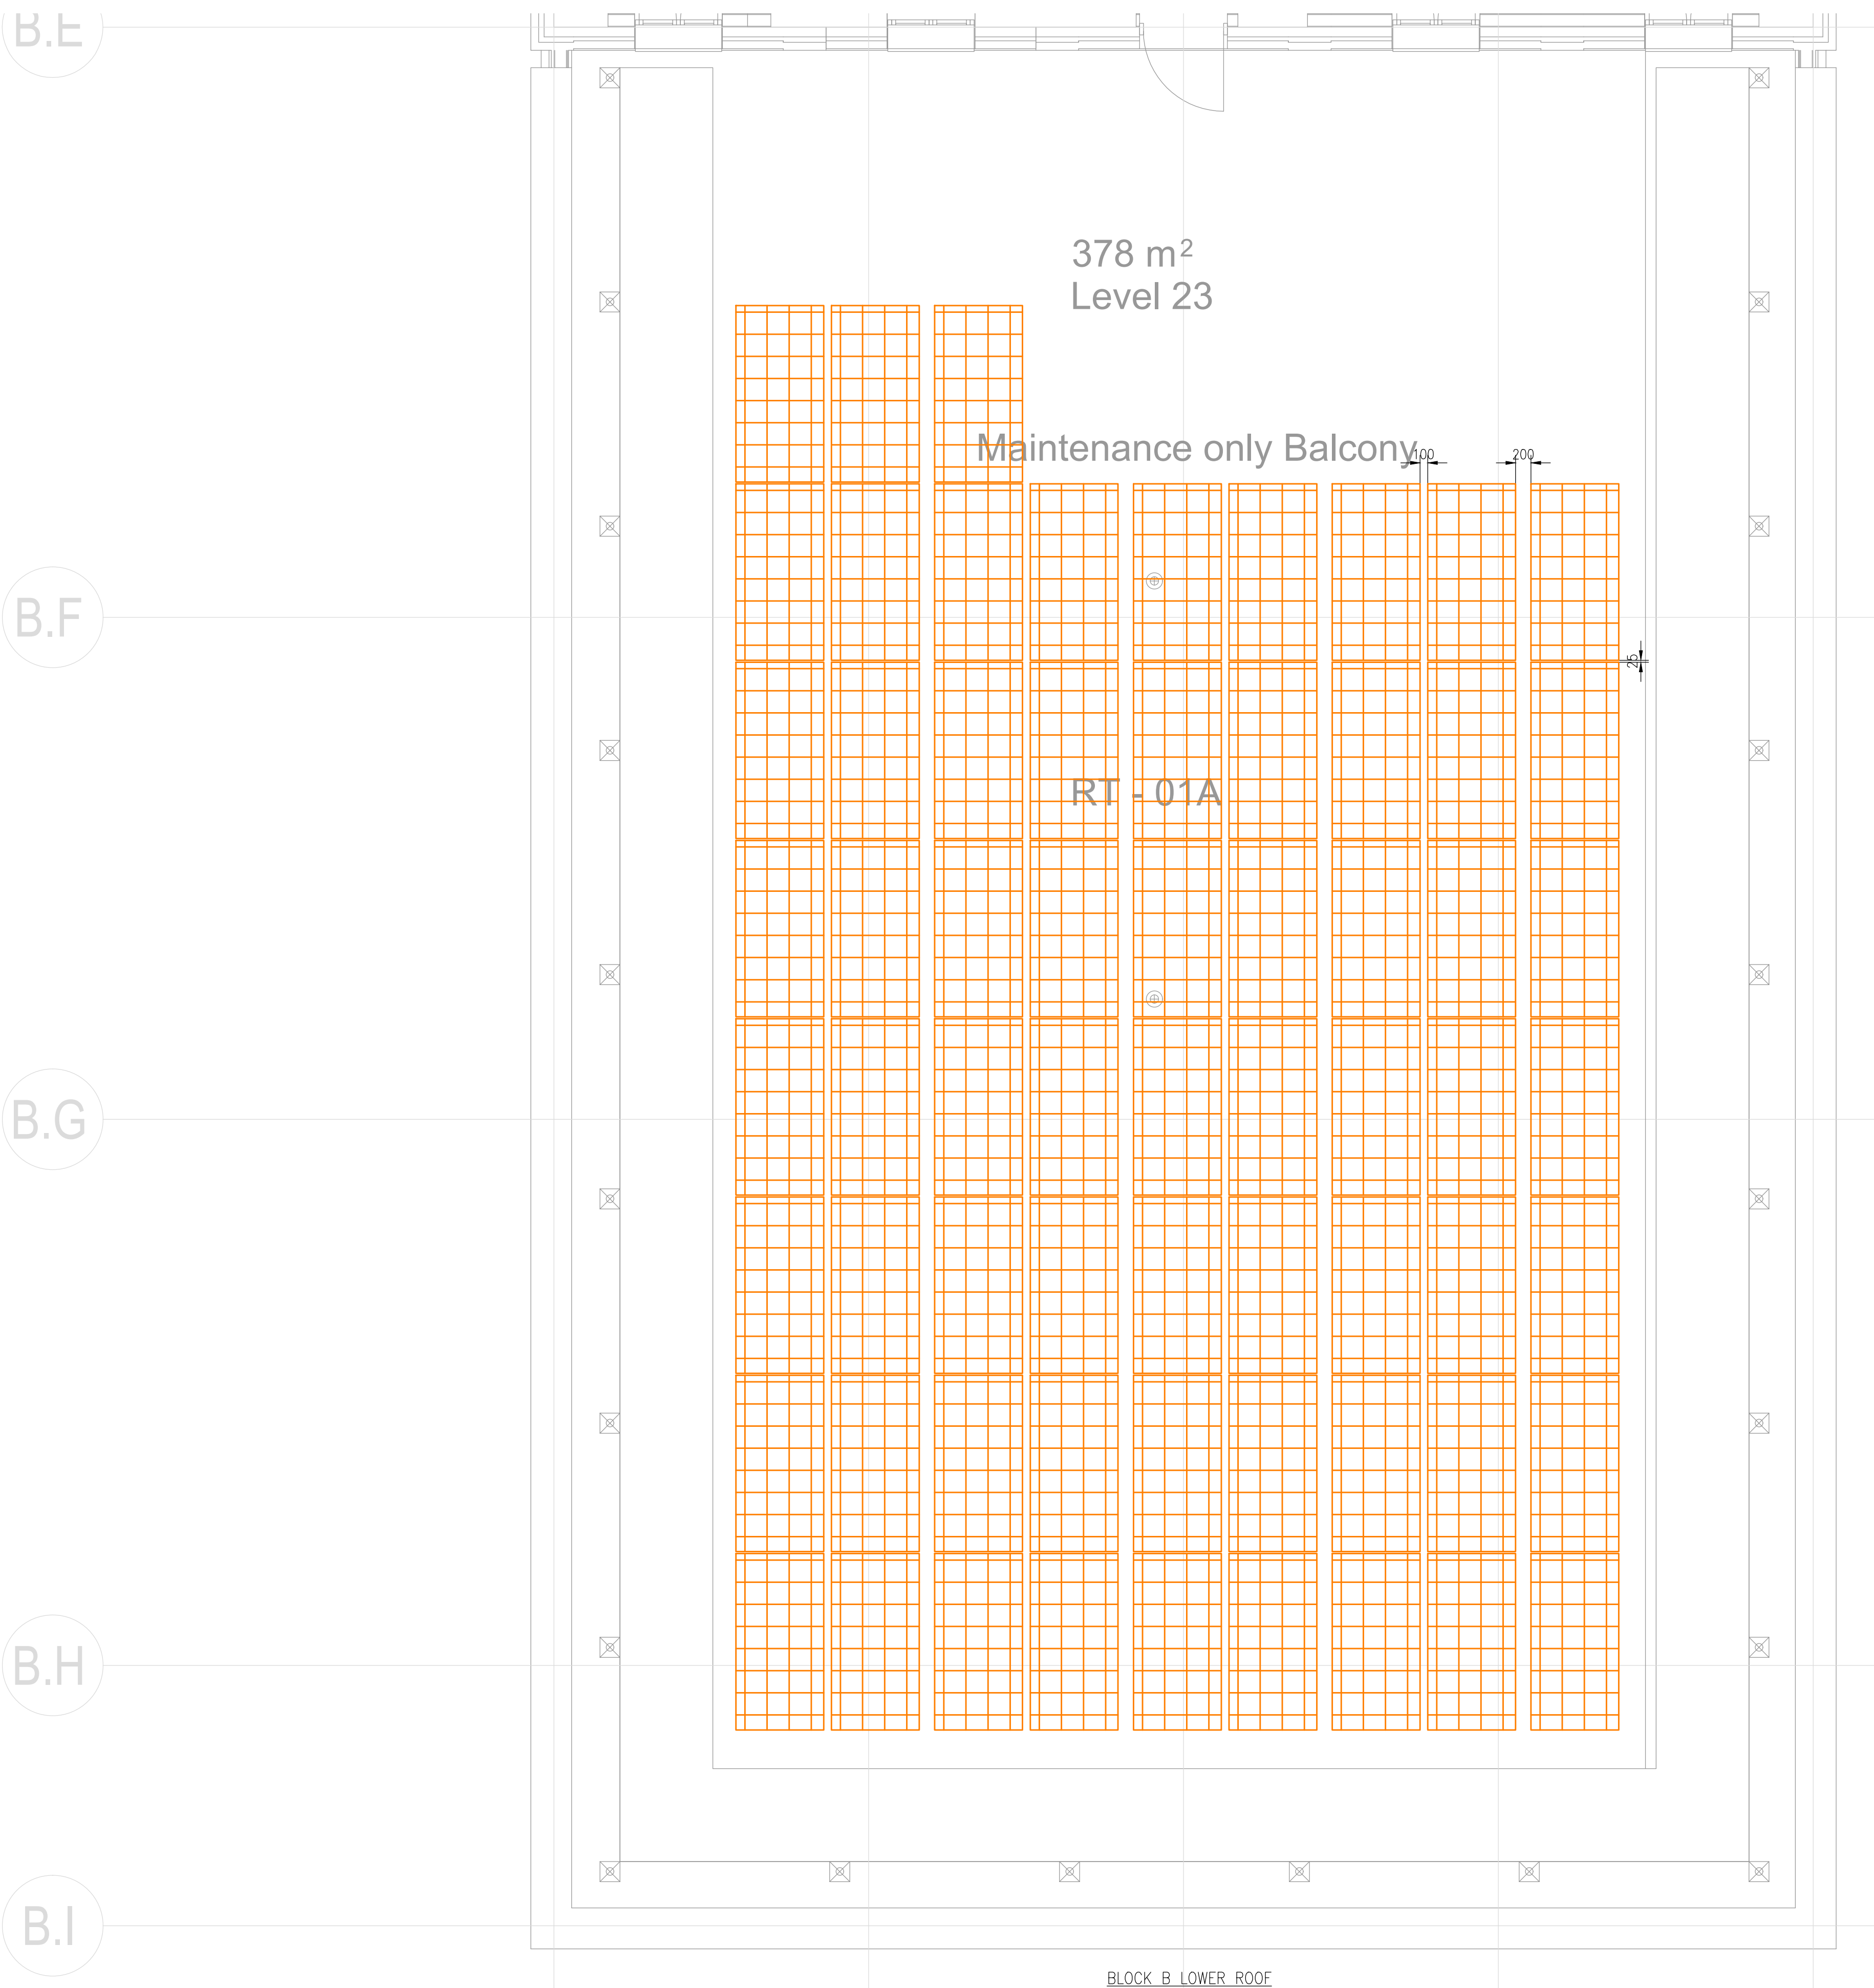

4

Technical Design

-	P02	PV UPDATED TO SUIT GLAZING SPECIFICATION	CW	BD	07.08.23
-	P01	PRELIMINARY ISSUE	CW	BD	21.07.23
STA	REV	DESCRIPTION	DES	CHD	DATE

PURPOSE OF ISSUE

PRELIMINARY

CLIENT

PROJECT

WATERHOUSE GARDENS MANCHESTER

TITLE

ELECTRICAL SERVICES
BLOCK B
LOWER & UPPER ROOF PLAN
PV LAYOUT

SCALE	1:50	ORIGINAL SIZE	A0	DATE	JUL '23
DRAWN	EG	DESIGNED	CW	CHECKED	BD

PROJECT / ORIGINATOR / ZONE / LEVEL / TYPE / ROLE / CLASS / NUMBER

P1981-NOV-BB-RF-DR-E-9000

REVISION

P02