

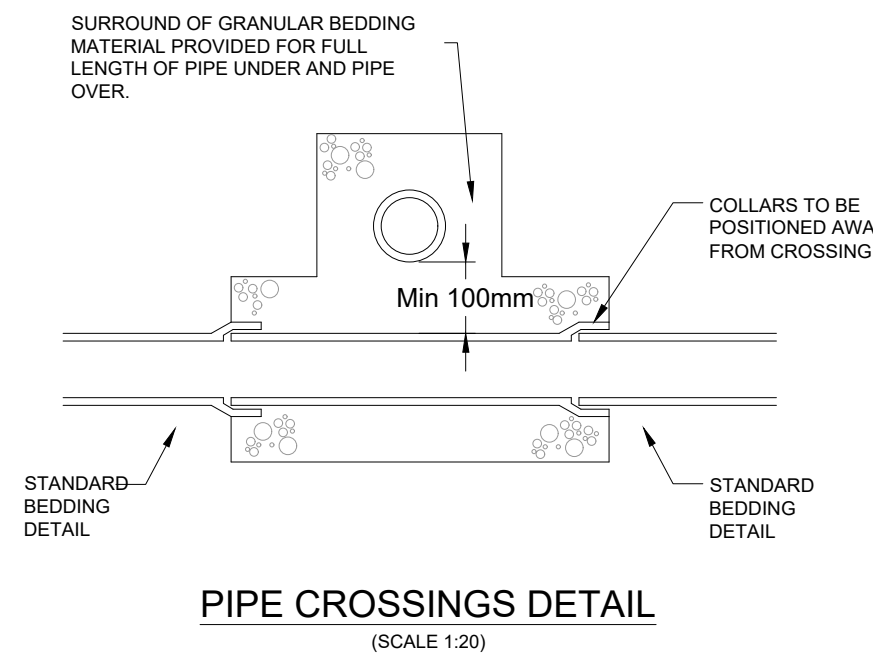
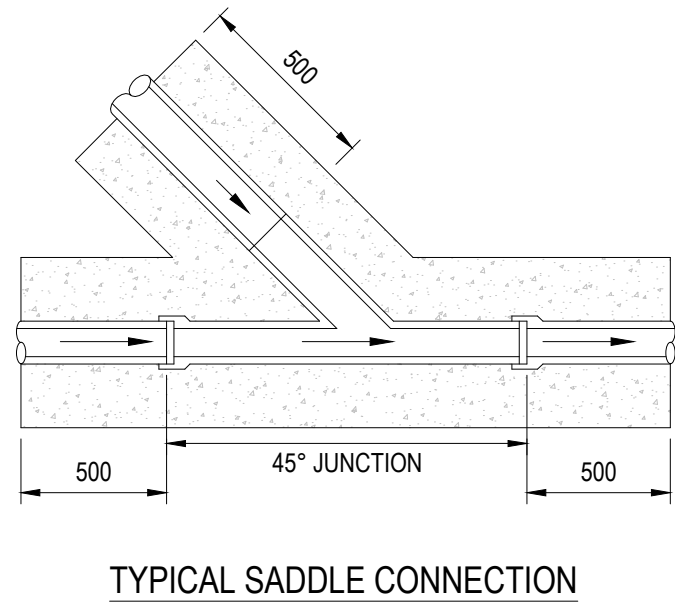
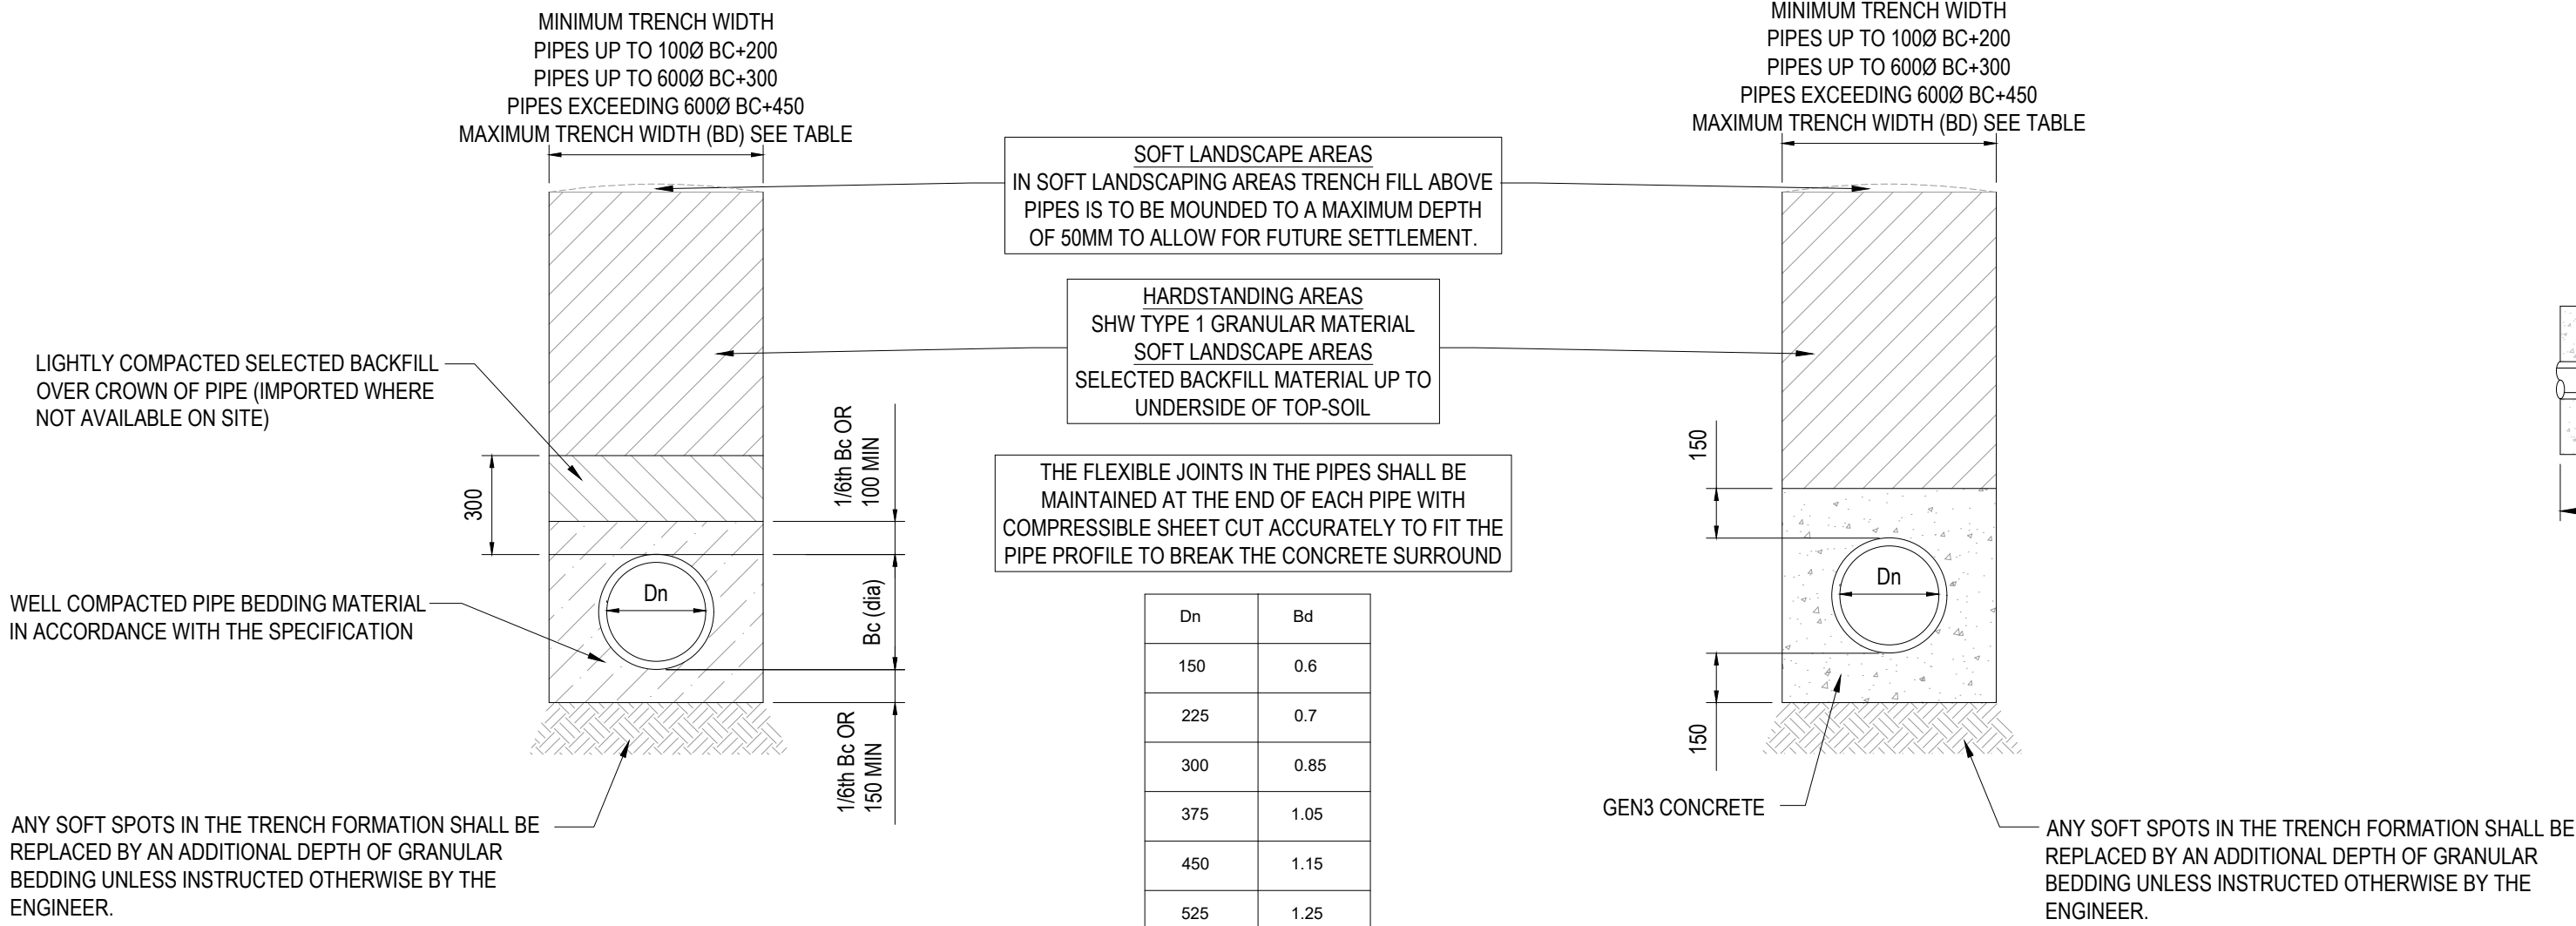
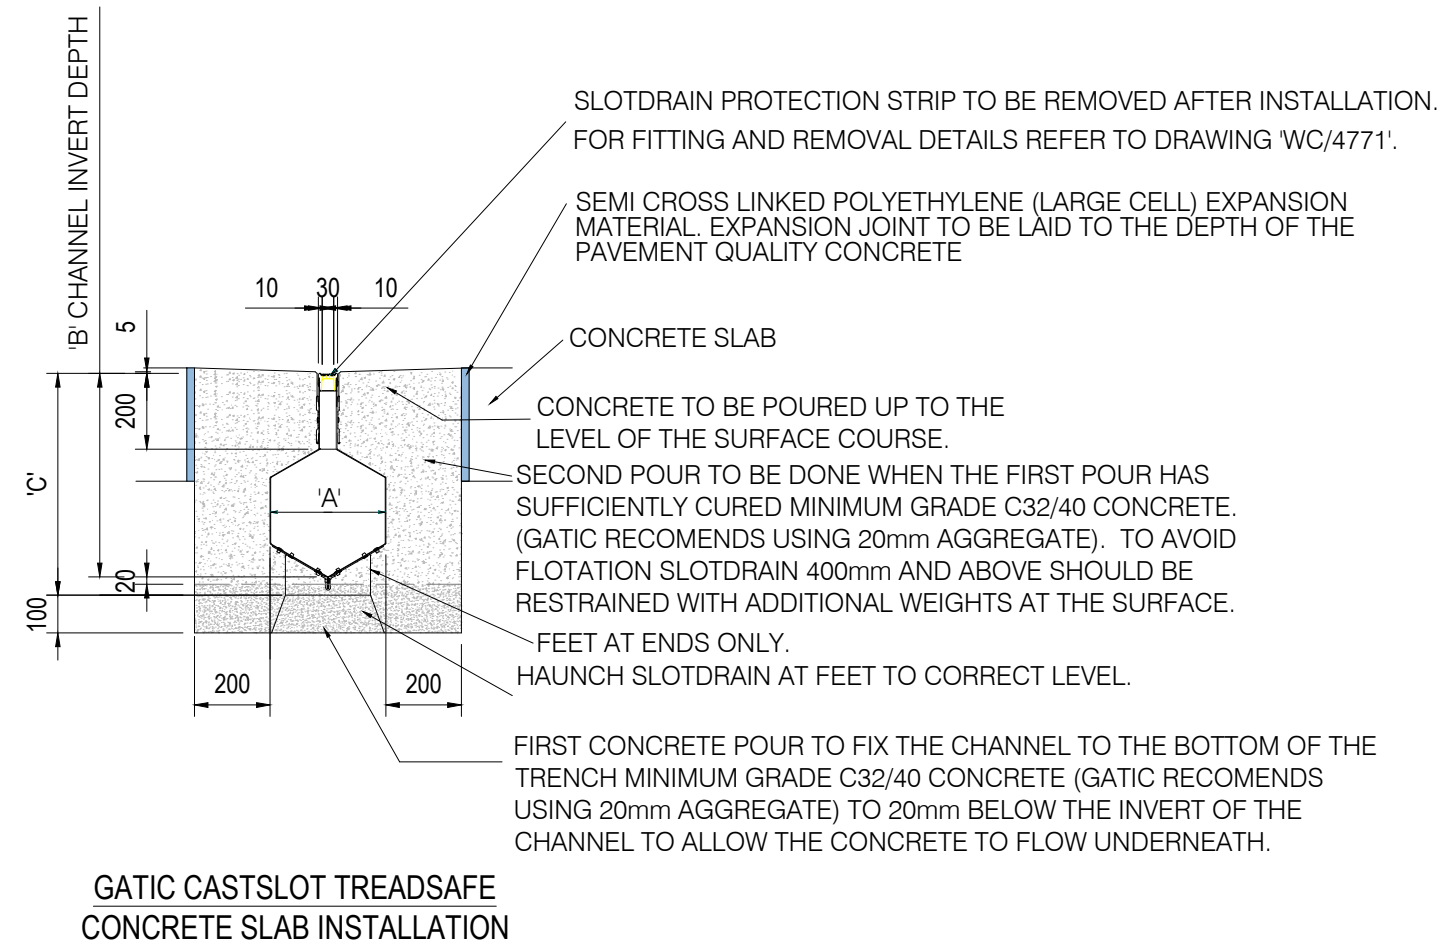
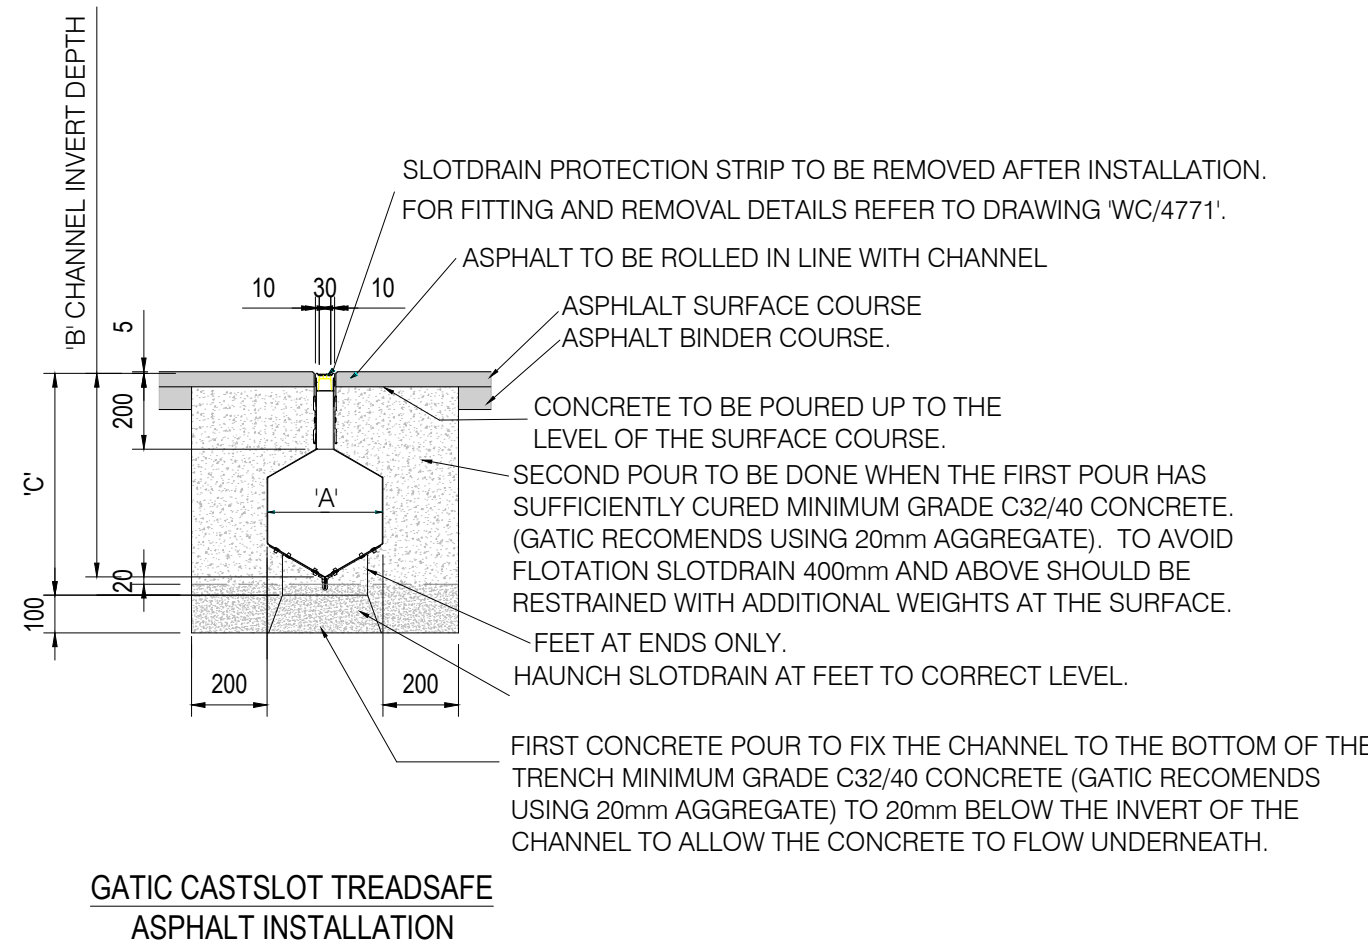
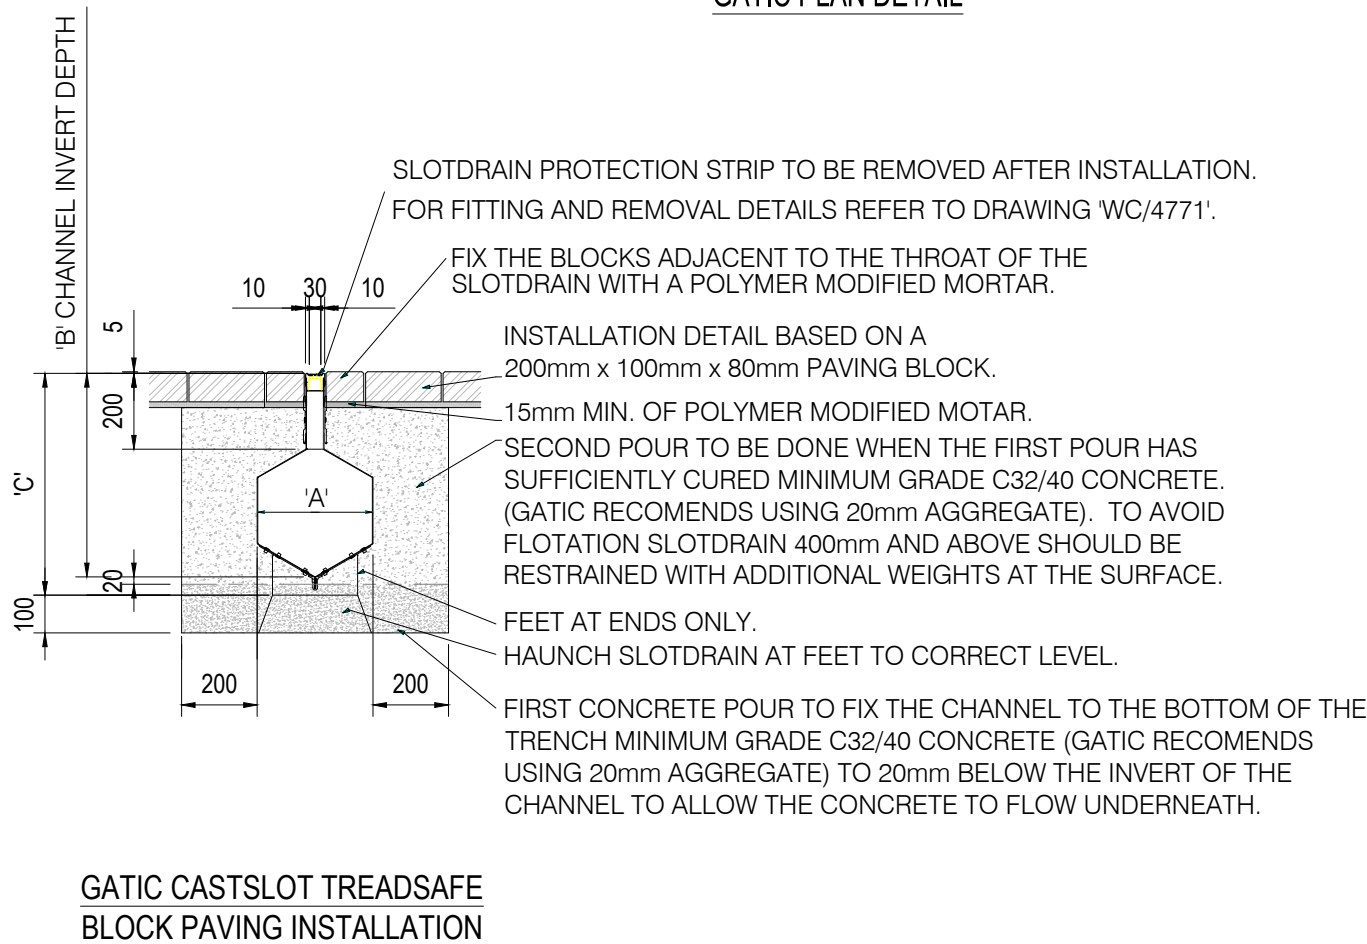
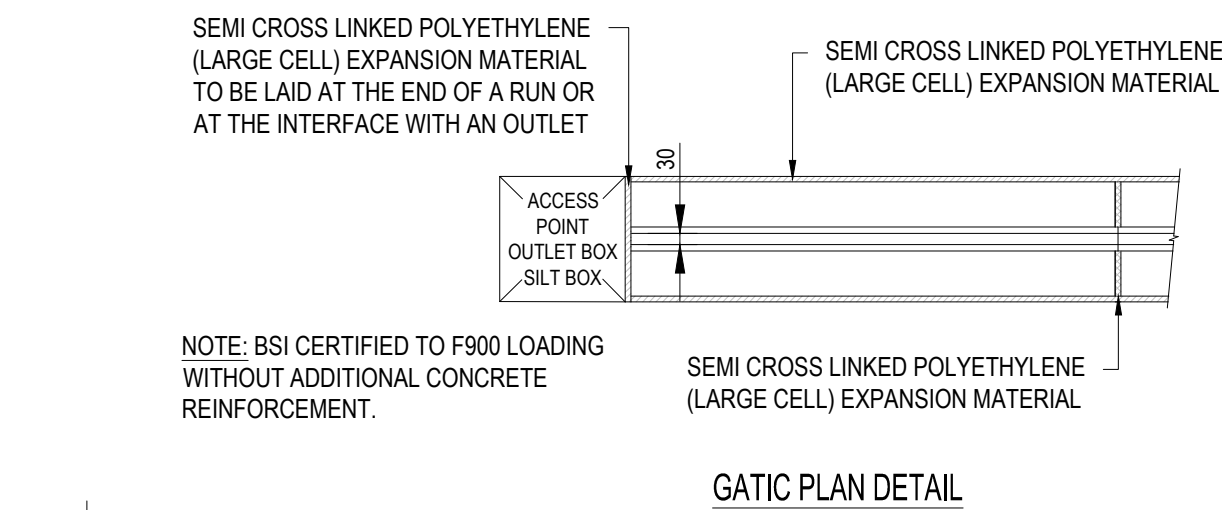
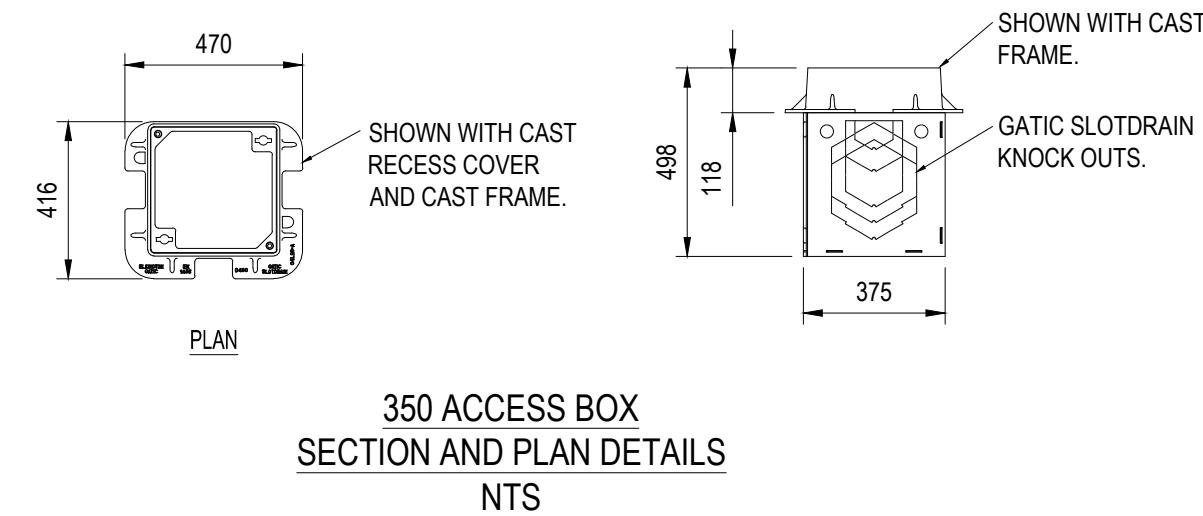
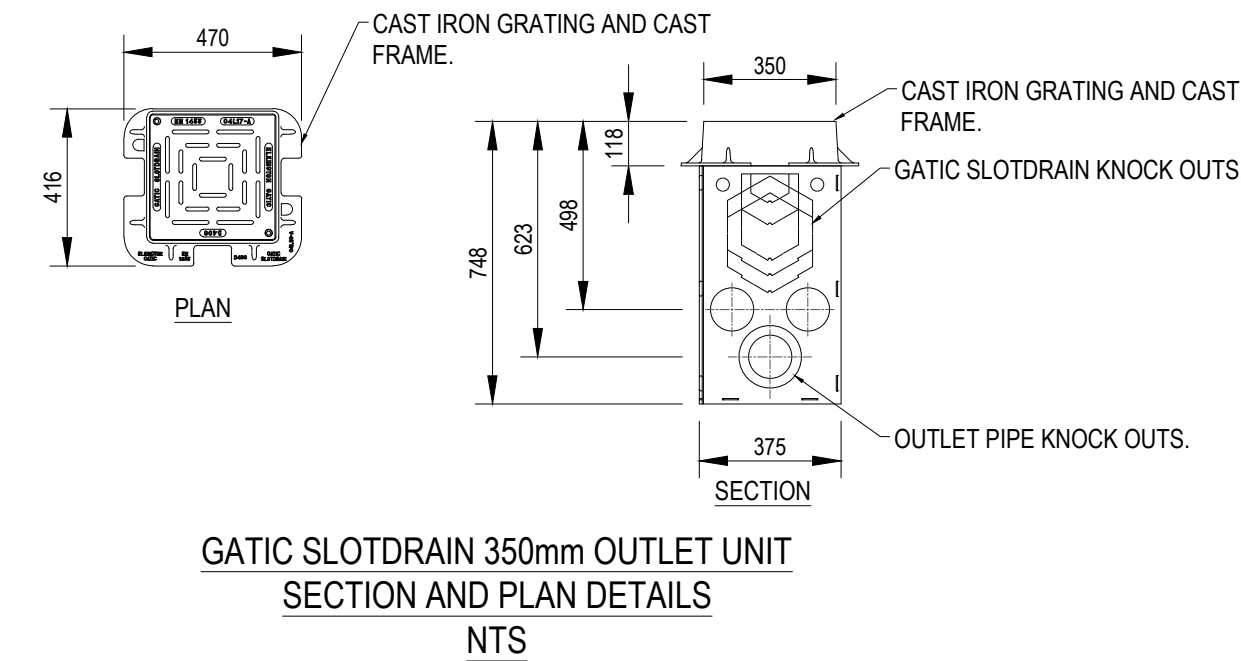
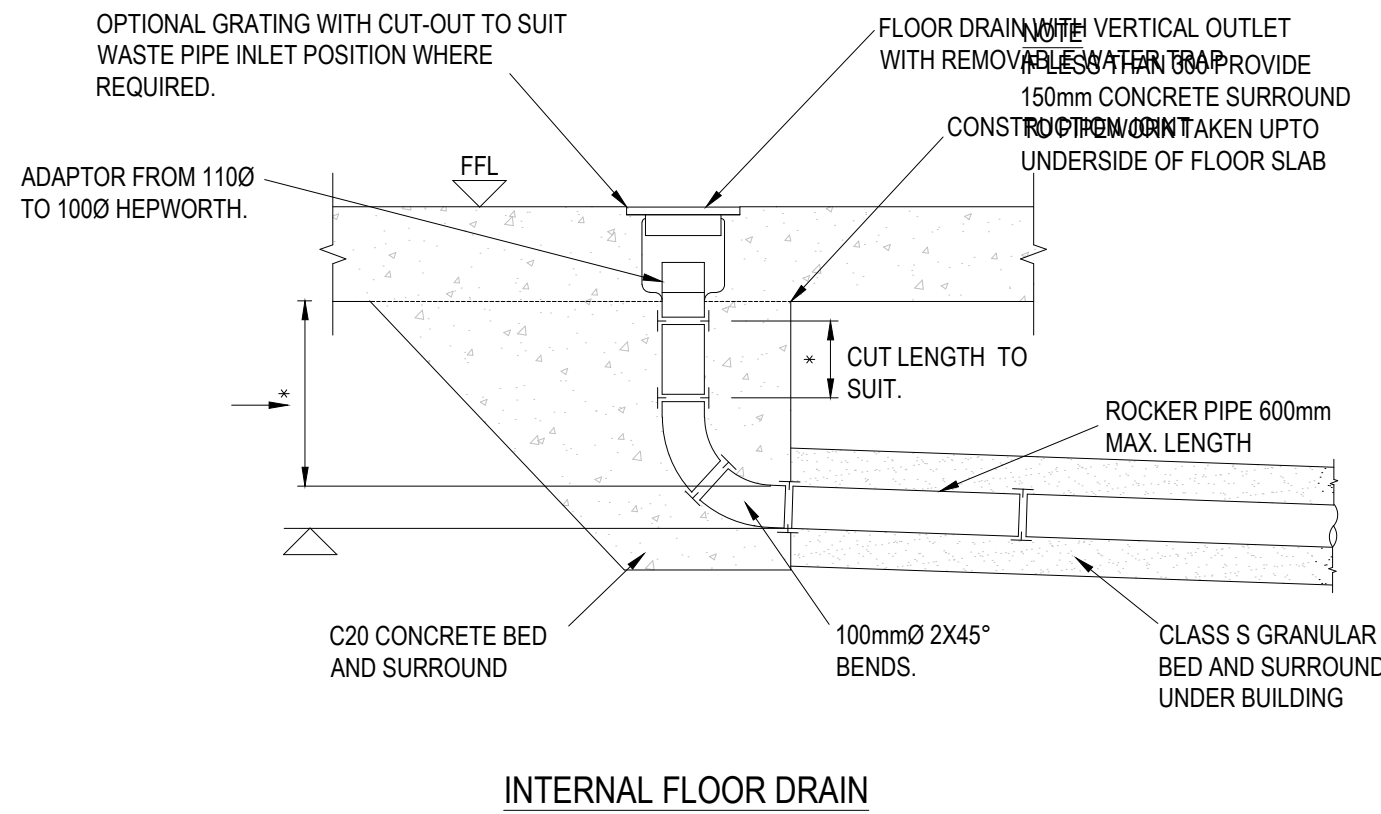


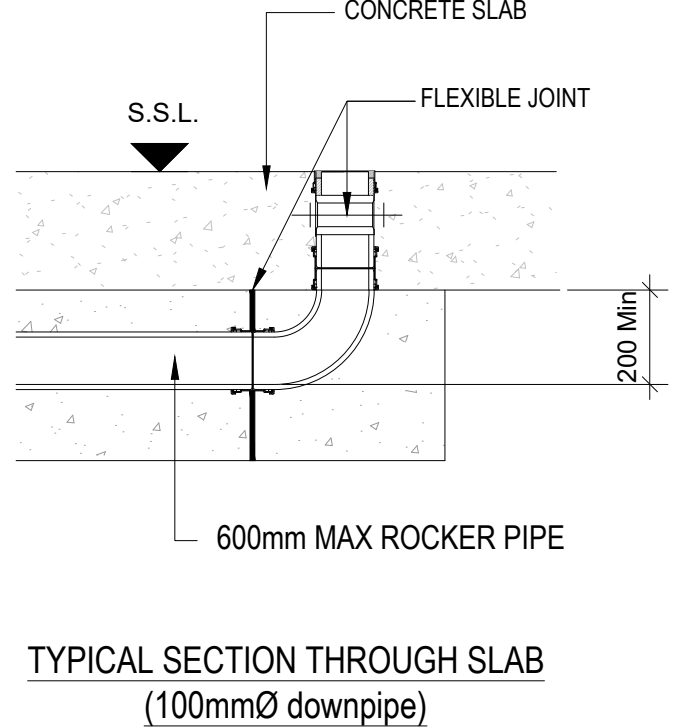

- GENERAL NOTES:
- THIS DRAWING IS TO BE READ IN CONJUNCTION WITH ALL RELEVANT ARCHITECTS AND ENGINEERS DRAWINGS AND SPECIFICATIONS.
 - DO NOT SCALE THIS DRAWING. ANY AMBIGUITIES, OMISSIONS AND ERRORS ON DRAWINGS SHALL BE BROUGHT TO THE ENGINEERS ATTENTION IMMEDIATELY. ALL DIMENSIONS MUST BE CHECKED / VERIFIED ON SITE.
 - ALL DIMENSIONS ARE IN METRES UNLESS NOTED OTHERWISE.
 - FOR FULL DRAINAGE LAYOUT REFER TO DWG: NMGH-CUR-WP6-XX-D-C-92500

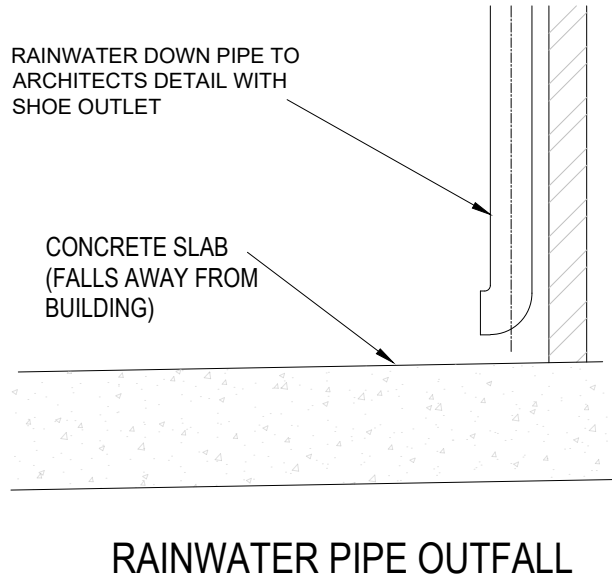

CASTSLOT TREADSAFE SLOT DRAIN						
WIDTH 'A'	INVERT 'B'	DEPTH 'C'	C.S.A.	3m PART No.	1m PART No.	500mm PART No.
100	308	357	9098	CAT00001	CAT00009	CAT00017
150	366	415	20325	CAT00002	CAT00010	CAT00018
225	452	501	45014	CAT00003	CAT00011	CAT00019

FOR CHANNEL SIZES AND LOADINGS - SEE DRAINAGE LAYOUT NMGH-CUR-WP6-XX-D-C-92500

STAGE 3 ISSUE

22/11/24

ATL

AR

Rev:

Description:

Date:

By:

Chkd:

Curtins

Merchant Exchange, 17-19 Whitworth Street West, Manchester, M1 5WG
0161 236 2394
manchester@curtins.com
www.curtins.com

Civils & Structures • Transport Planning • Environmental • Infrastructure • Geotechnical • Conservation & Heritage • Principal Designer
Birmingham • Bristol • Cambridge • Cardiff • Douglas • Dublin • Edinburgh • Glasgow • Kendal • Liverpool • London • Manchester • Nottingham

Status:

STAGE 3

Project:

NMGH WP06

Orig Title:

WP06
DRAINAGE DETAILS SHEET 2

Drawn By

ATL

Designed By

ATL

Checked By

AR

Date

18/11/24

Scales @ A1

NTS

Project No - Originator - Function - Spatial - Form - Discipline - Number

NMGH - CUR-WP6-XX-D-C-92521

Revision

P01