



Proposed signage drawings


Scale : 1:10 @ A3
Item E. 6no. Floodlights. (see CSI 211 F for details)
G/Cl - 7050mm D - 245mm

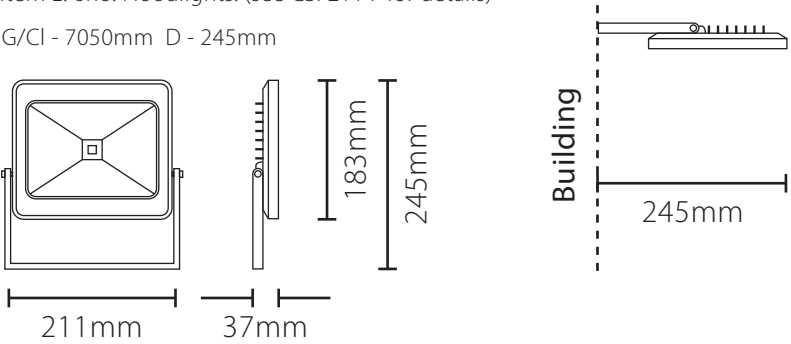



Scale : 1:10 @ A3
Item F. 4no. Aged brass lanterns to front. Fixed to building.

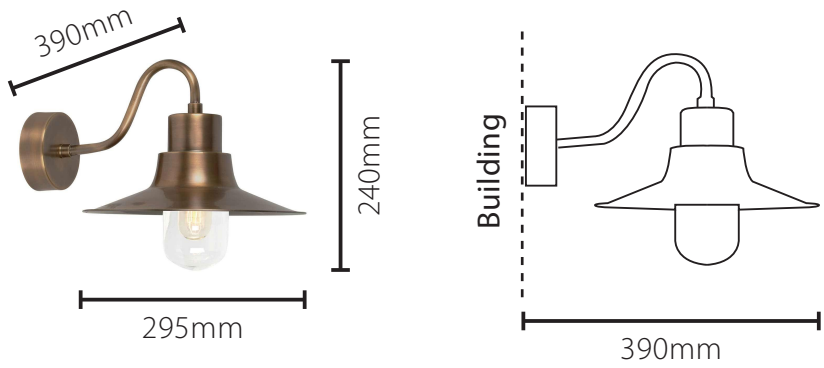

Scale : 1:20 @ A3
Item G. 2no. Sets of sprayed 19mm foamex letters. Lit by trough lights. (CSI 211 E for details)
G/Cl - 3300mm D - 19mm

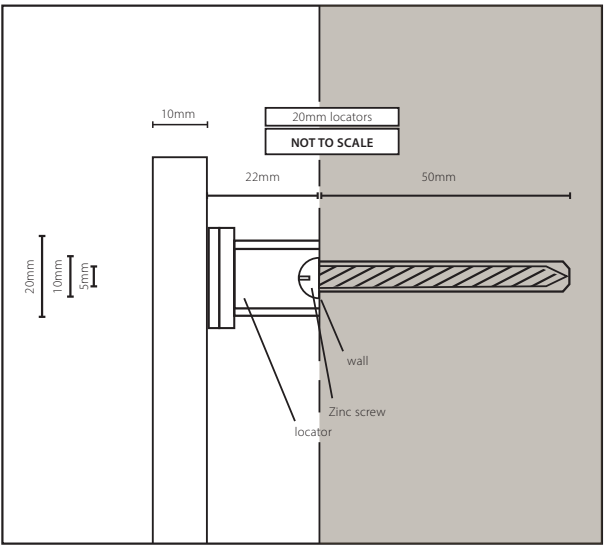

Scale : 1:10 @ A3
Item H and I. 4no. Planter boxes with real planting to front elevation windows. Fixed via brackets to building.

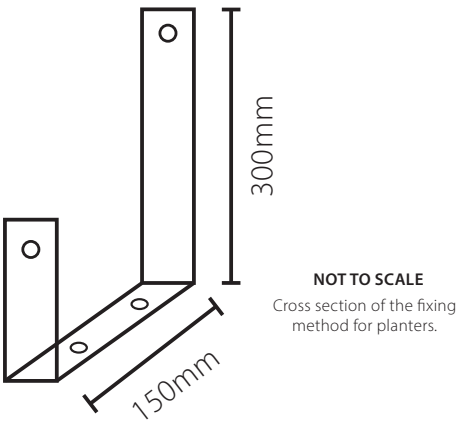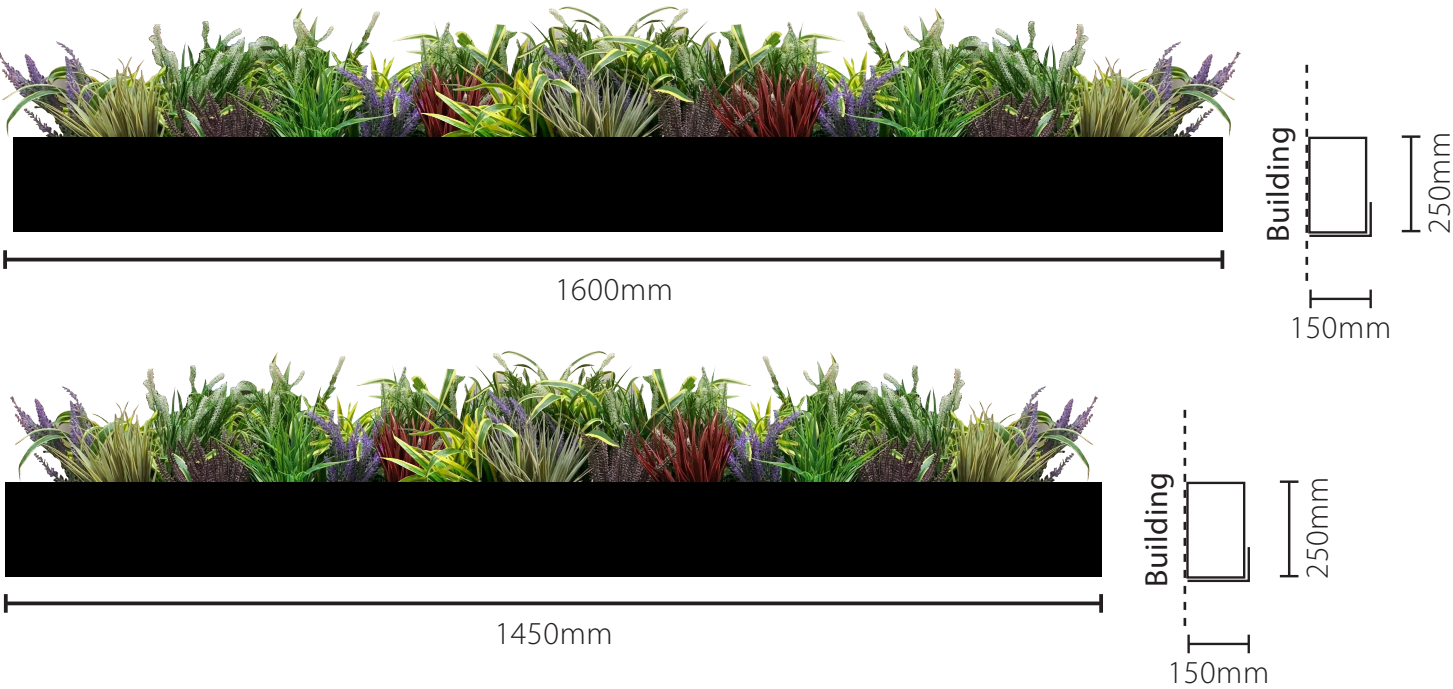

UNIT 14
CREAMERY INDUSTRIAL ESTATE
BARNACRE, PRESTON
LANCASHIRE
PR3 1GD
01995 604122
design@csisigns.co.uk

The designs, illustrations, and photography is the property of CSI Ltd. The contents are confidential, any form of reproduction, copying disclosure, modification or distribution without prior written consent is strictly prohibited.

Please note all colours shown are representative only and will not match sign products exactly. Please note paint codes and pantone codes where indicated.

Visuals shown are artists impressions only and must not be taken as an exact representation of the completed signage on site.

Project: The Brunswick,
Manchester

Drawn By: K.D

Drawing No: CSI 211 O

Date: 28/03/2025

Revision: C