


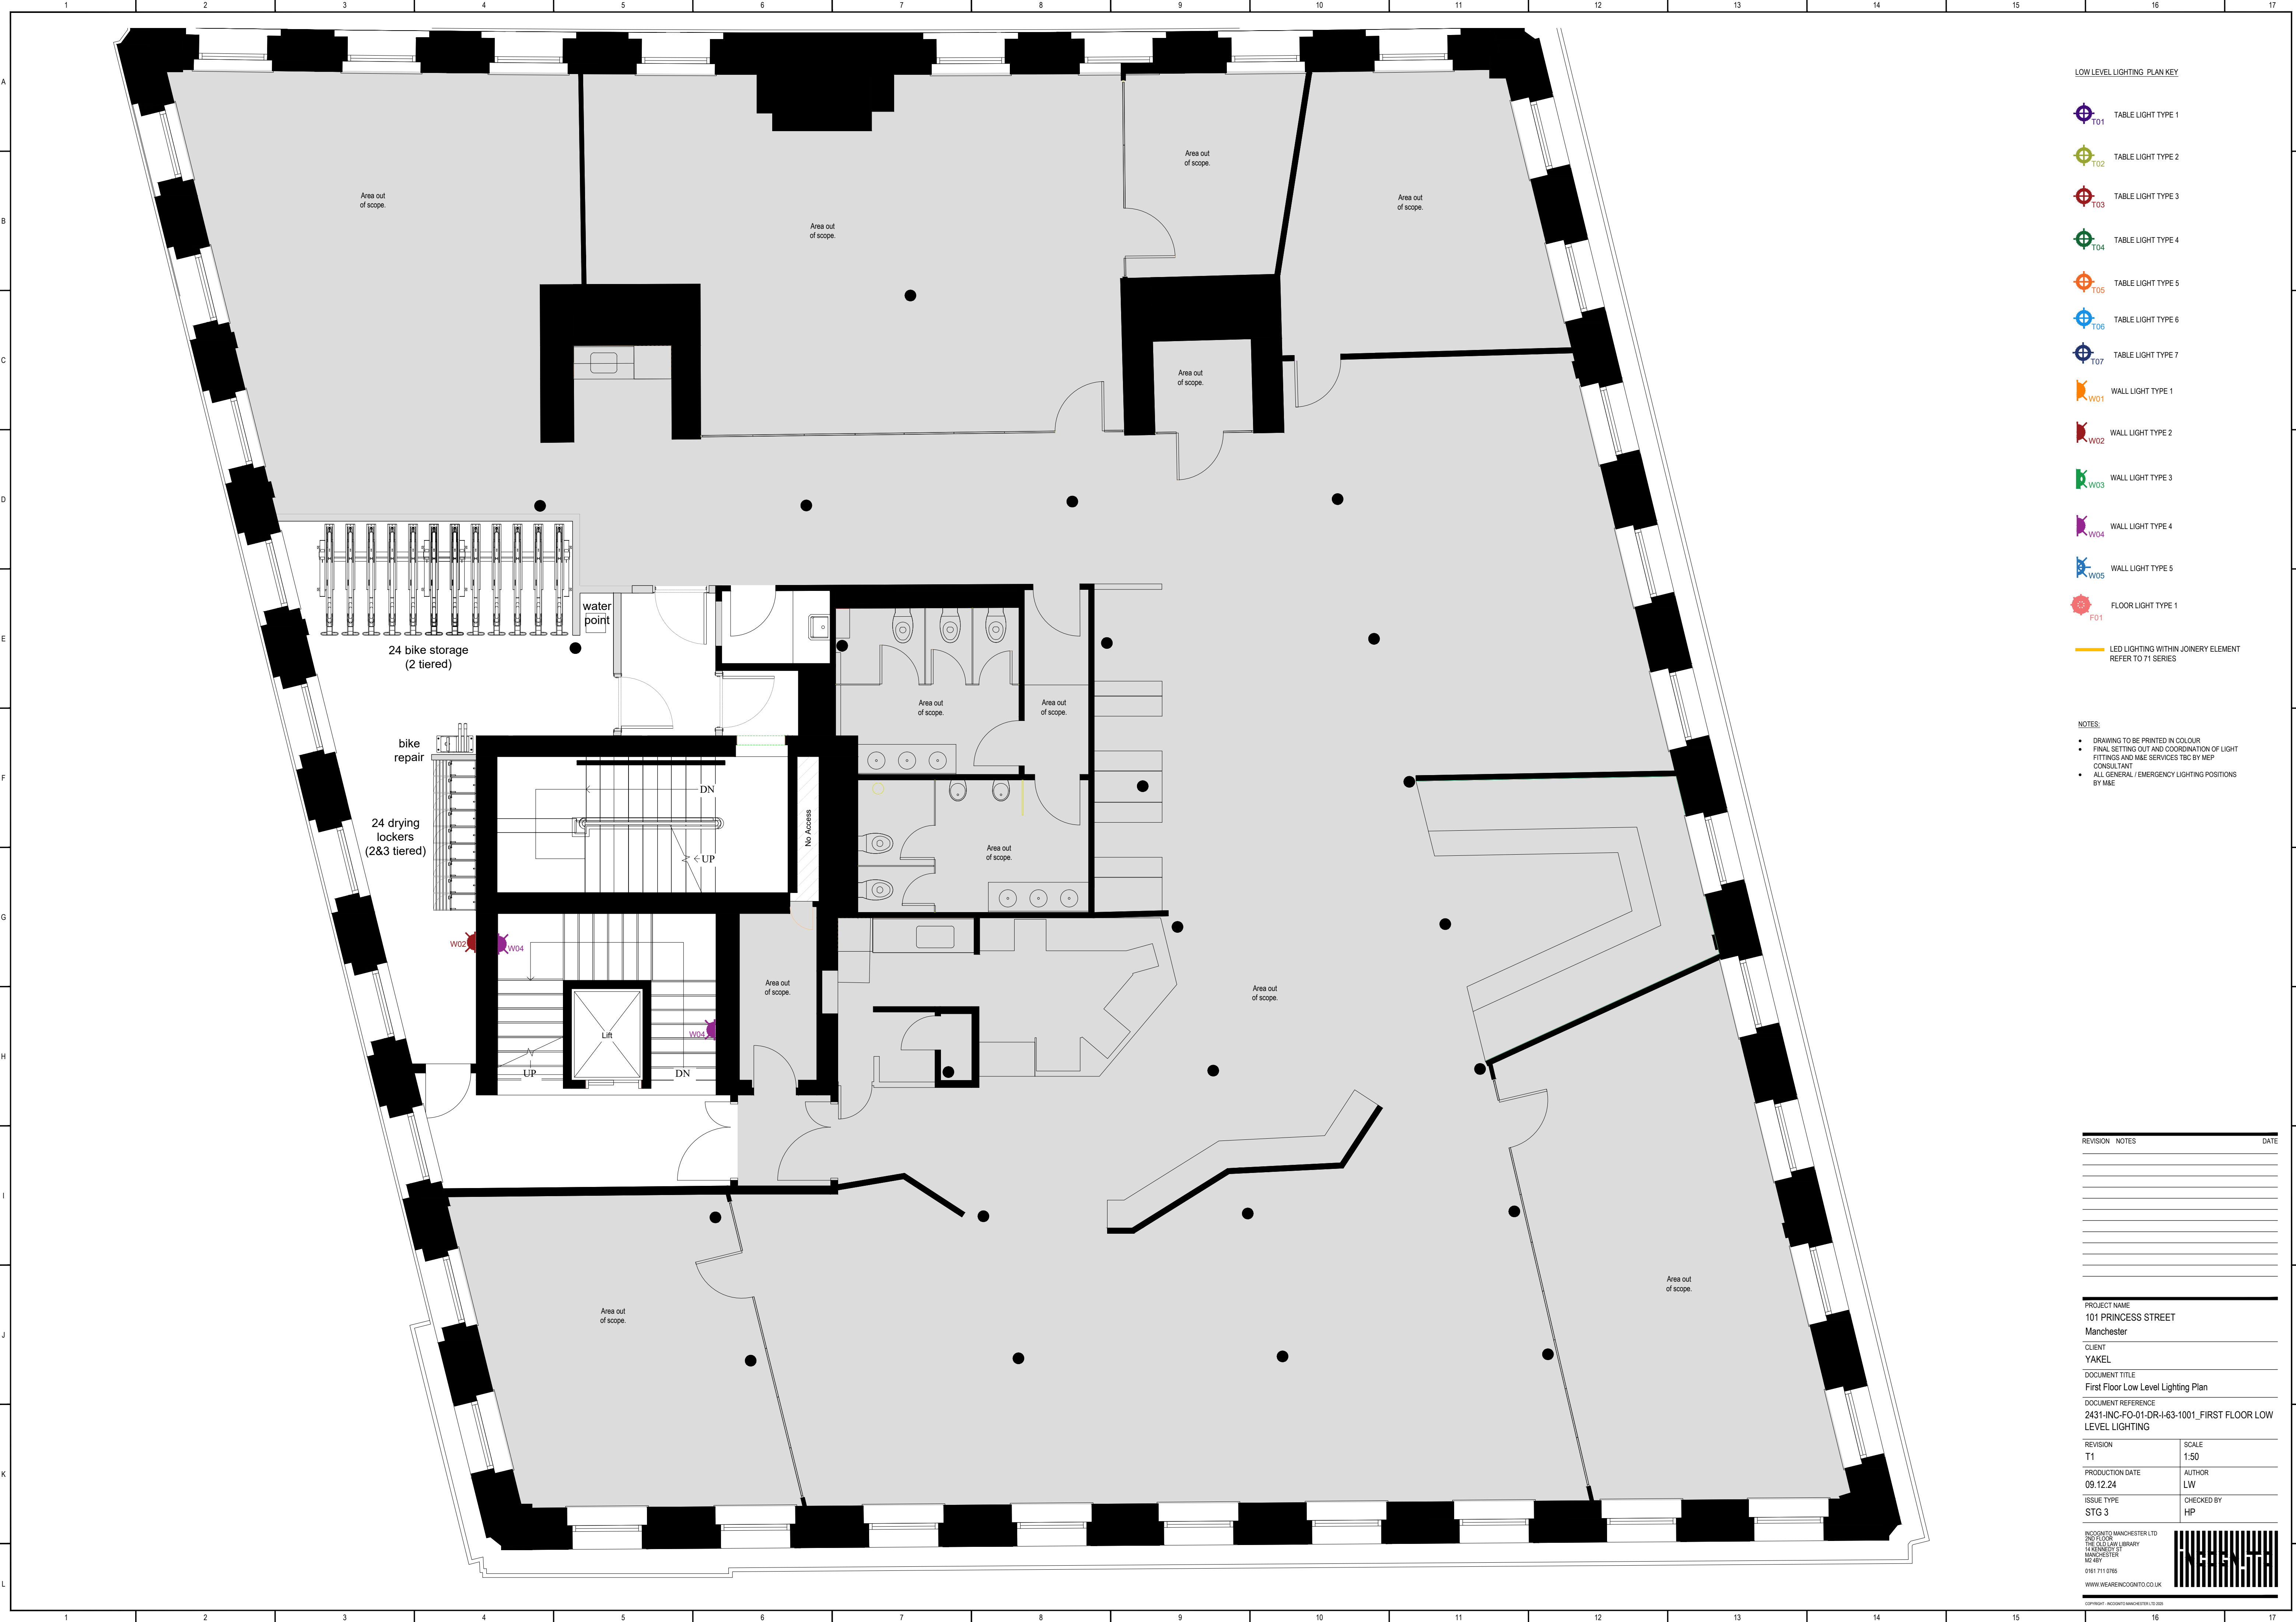

LOW LEVEL LIGHTING PLAN KEY

- T01 TABLE LIGHT TYPE 1
- T02 TABLE LIGHT TYPE 2
- T03 TABLE LIGHT TYPE 3
- T04 TABLE LIGHT TYPE 4
- T05 TABLE LIGHT TYPE 5
- T06 TABLE LIGHT TYPE 6
- T07 TABLE LIGHT TYPE 7
- W01 WALL LIGHT TYPE 1
- W02 WALL LIGHT TYPE 2
- W03 WALL LIGHT TYPE 3
- W04 WALL LIGHT TYPE 4
- W05 WALL LIGHT TYPE 5
- F01 FLOOR LIGHT TYPE 1

LED LIGHTING WITHIN JOINERY ELEMENT
REFER TO 71 SERIES

NOTES:

- DRAWING TO BE PRINTED IN COLOUR
- FINAL SETTING OUT AND COORDINATION OF LIGHT FITTINGS AND MAE SERVICES TBC BY MEP CONSULTANT
- ALL GENERAL / EMERGENCY LIGHTING POSITIONS BY MAE

REVISION	NOTES	DATE

PROJECT NAME
101 PRINCESS STREET
Manchester

CLIENT
YAKEL

DOCUMENT TITLE
First Floor Low Level Lighting Plan

DOCUMENT REFERENCE
2431-INC-FO-01-DR-I-63-1001_FIRST FLOOR LOW LEVEL LIGHTING

REVISION T1	SCALE 1:50
PRODUCTION DATE 09.12.24	AUTHOR LW
ISSUE TYPE STG 3	CHECKED BY HP

INCQINTO MANCHESTER LTD
2ND FLOOR
THE OLD LAW LIBRARY
14 ROXBURY ST
MANCHESTER
M2 8BY
0161 711 0785
WWW.WEAREINCQINTO.CO.UK

INCQINTO

COPYRIGHT © INCQINTO MANCHESTER LTD 2025