



FILE LOCATION PATH: P:\PROJECTS\HOT11076-27 MAYFIELD, MANCHESTER - PLOT M004 BIMCIVILSDRAWINGS\0197_MAY-CIV-SWI-XXXX-DR-C-310003_PLOT M EXTERNAL WORKS TYPICAL DRAINAGE DETAILS SHEET 3.DWG

NOTE:
ALL DRAINAGE CHANNELS SHALL BE INSTALLED STRICTLY
IN ACCORDANCE WITH MANUFACTURERS INSTRUCTIONS


CHANNEL/SLOT DRAINS TO BE INSTALLED WITH SLOPES
TOWARDS SUMP UNITS SHOWN ON DRAINAGE PLANS.
COVER TO BE D400 LOADING CLASS

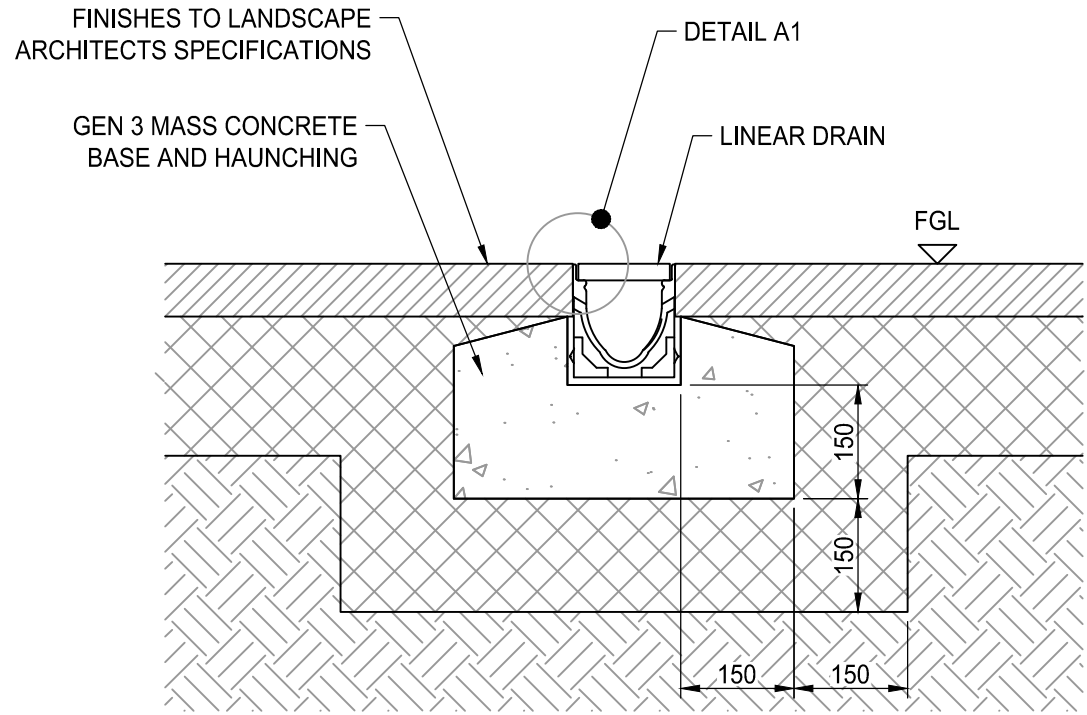


CHANNEL DRAIN DETAIL
SCALE: 1:10

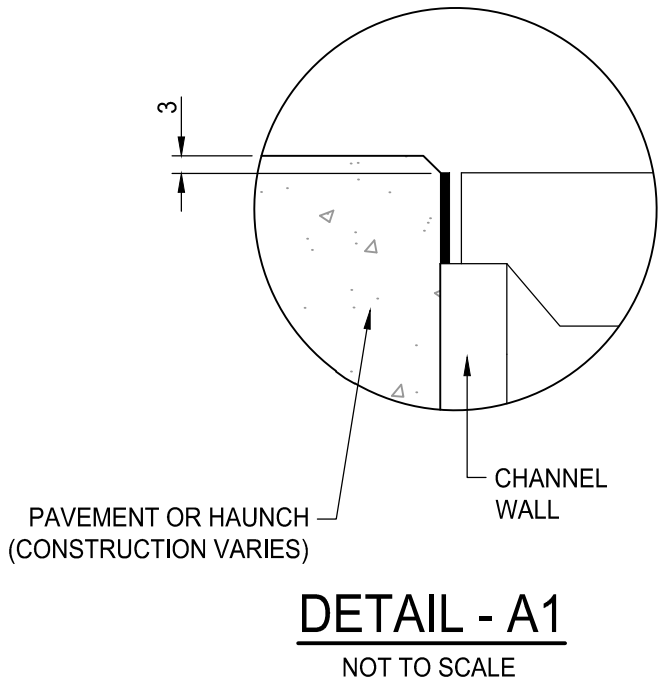


DETAIL - A1
NOT TO SCALE

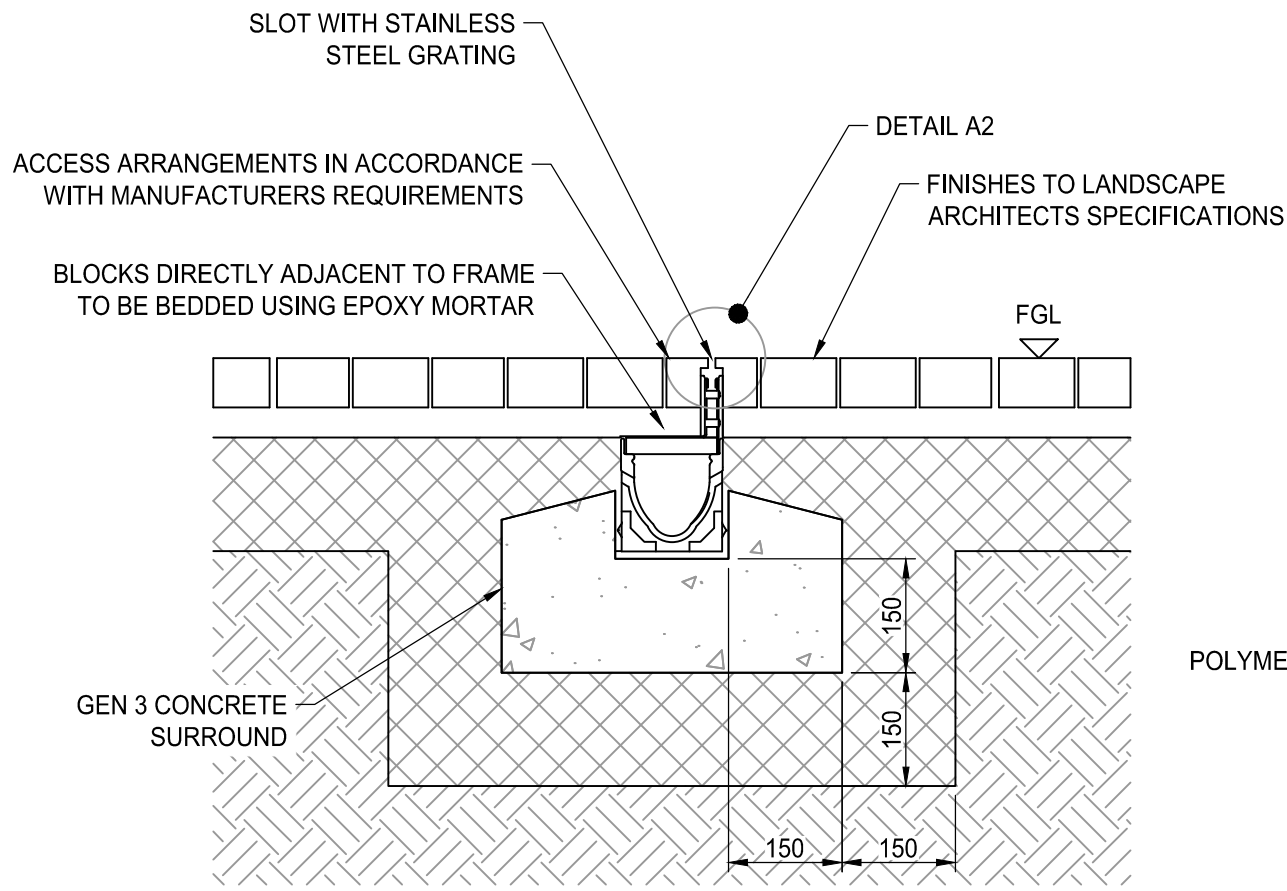




LINEAR SLOT DRAIN DETAIL
SCALE: 1:10

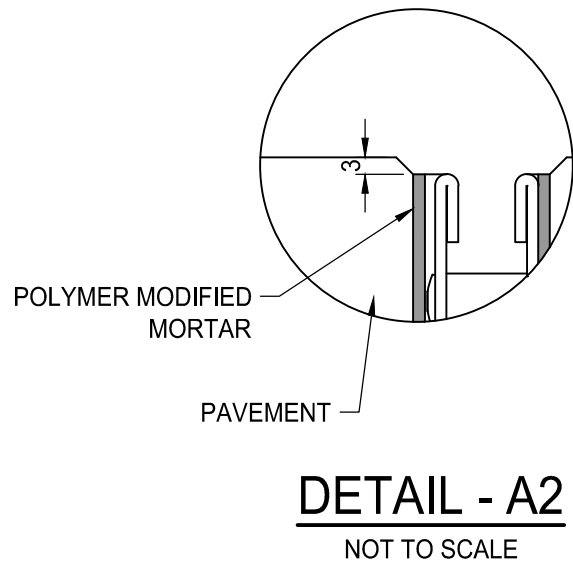


DETAIL - A2
NOT TO SCALE

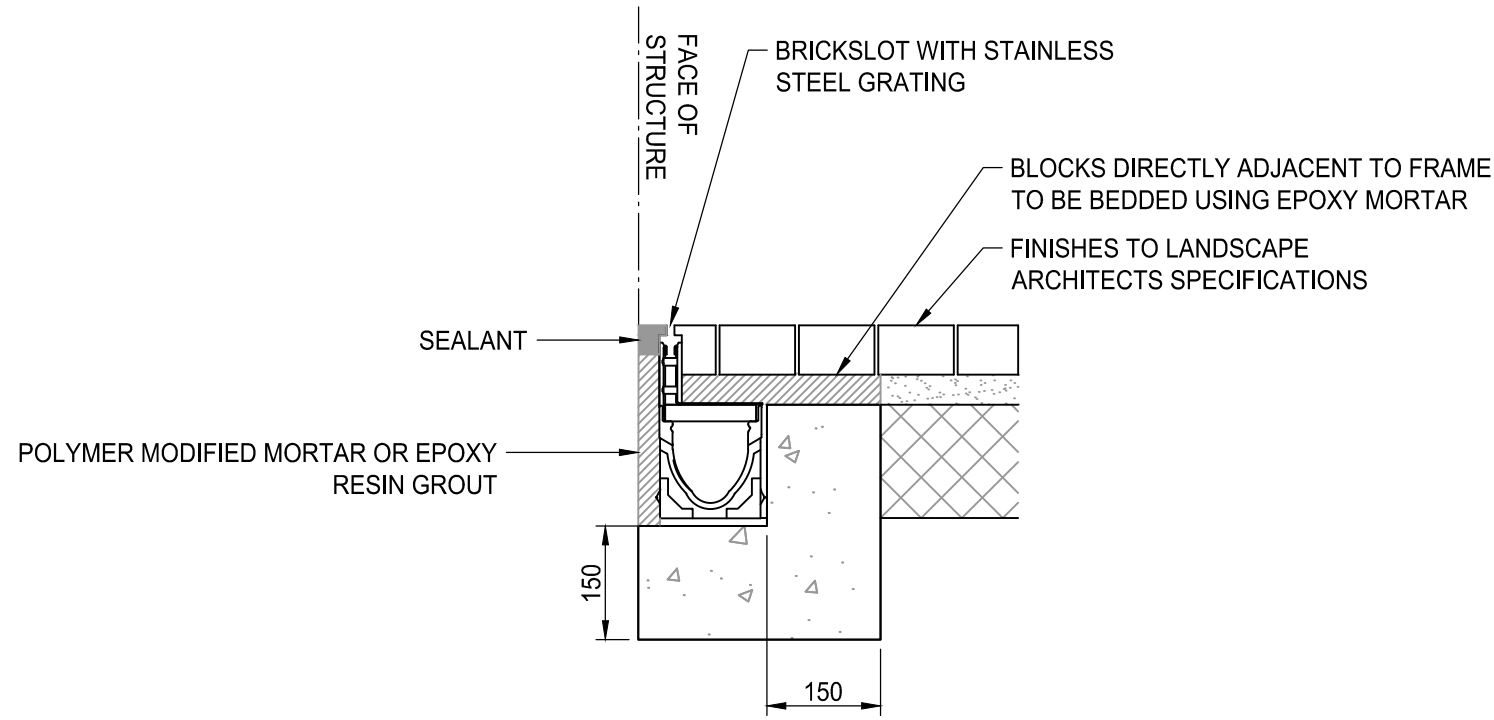


LINEAR SLOT DRAIN AT THRESHOLD DETAIL
SCALE: 1:10

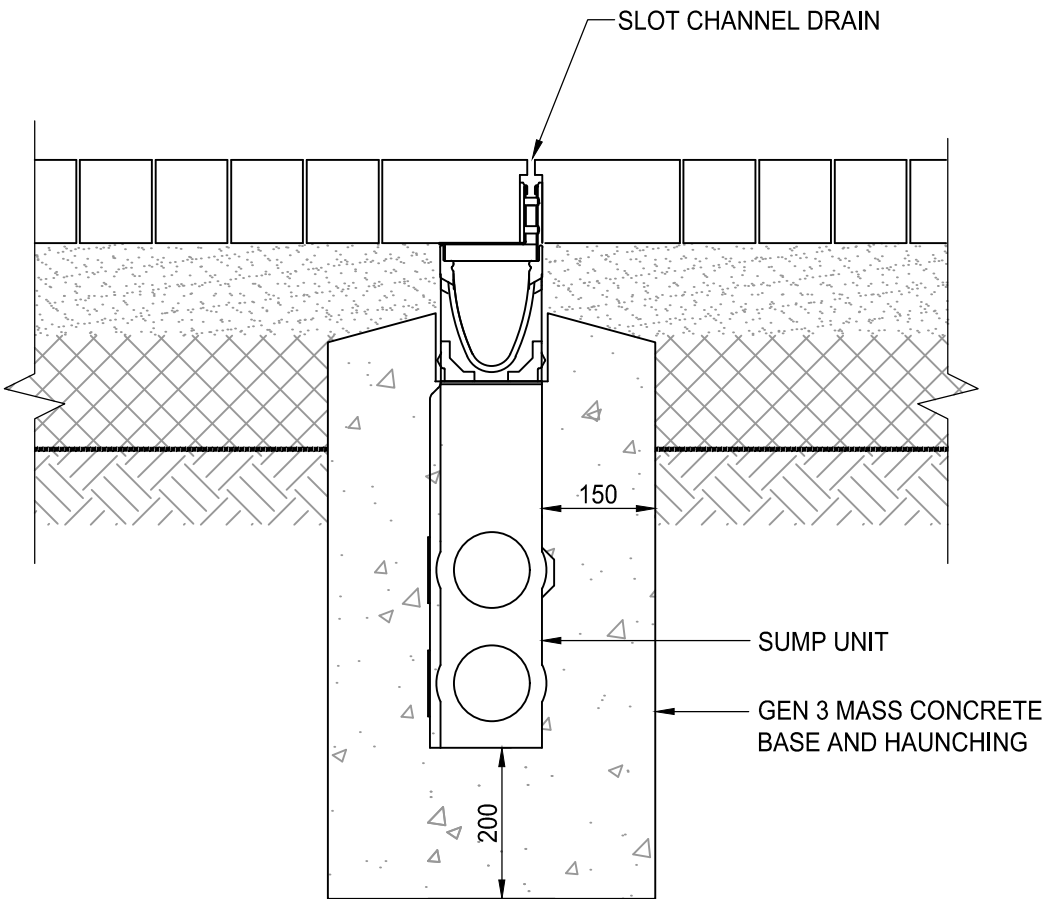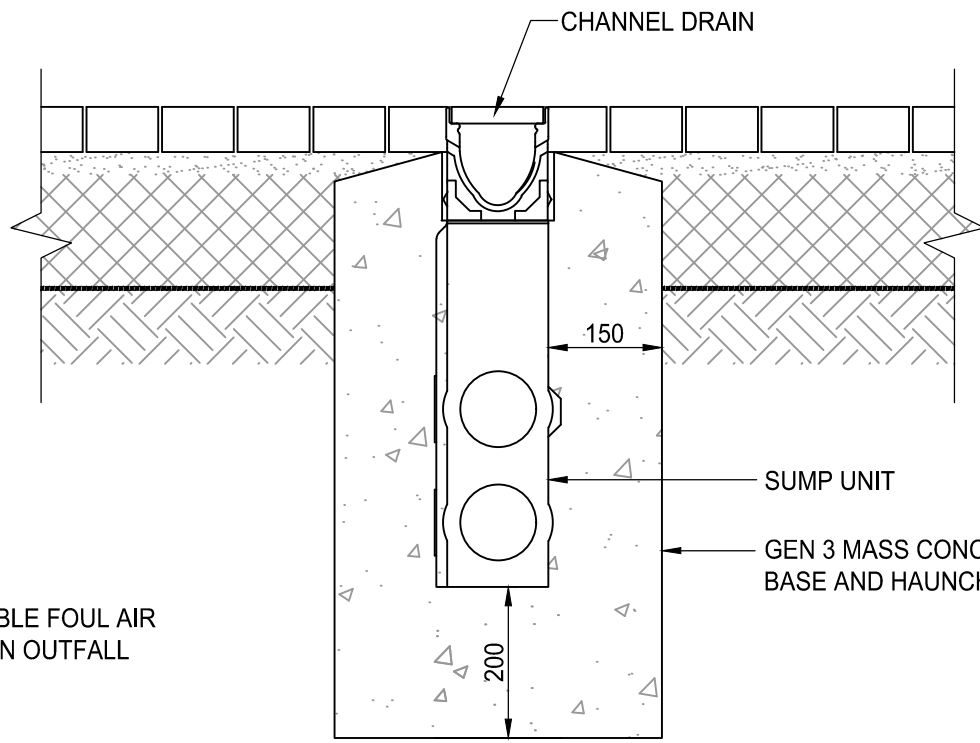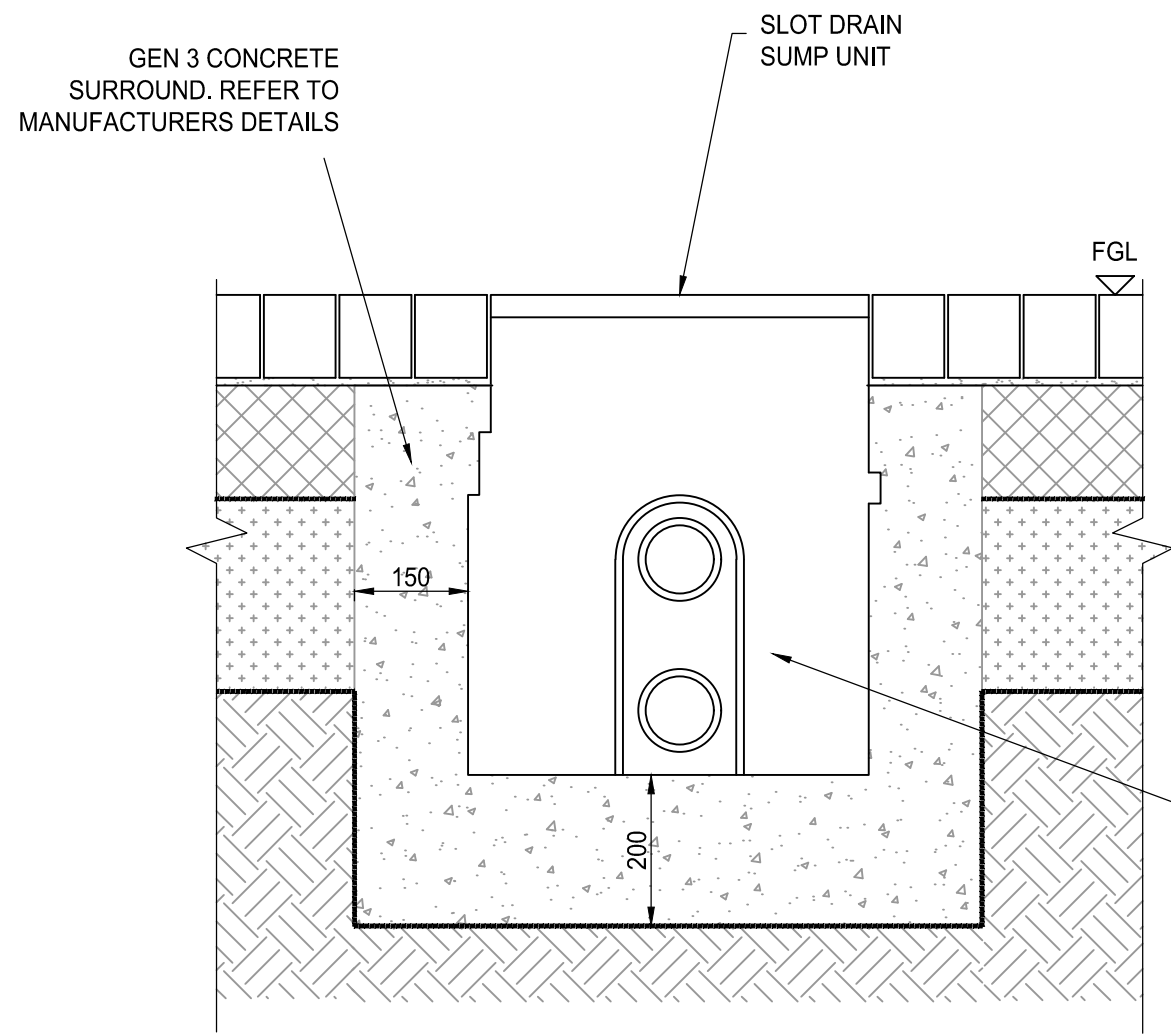


SUMP UNIT TO CHANNEL/SLOT DRAIN DETAIL
SCALE: 1:10

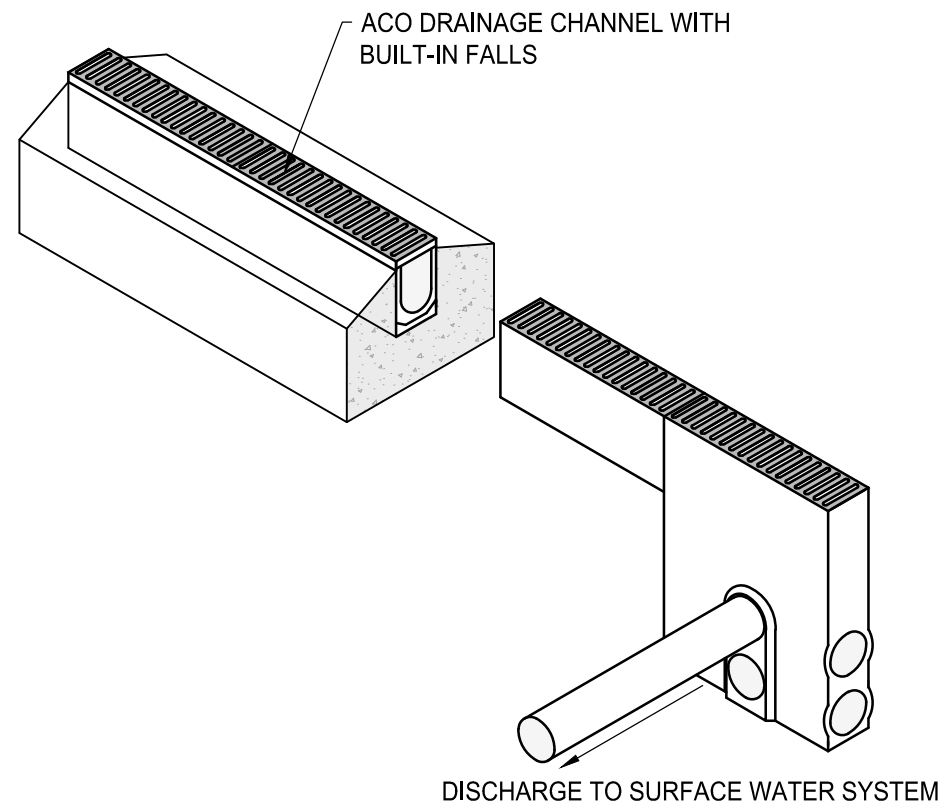


ACO DRAIN SCHEMATIC
NOT TO SCALE

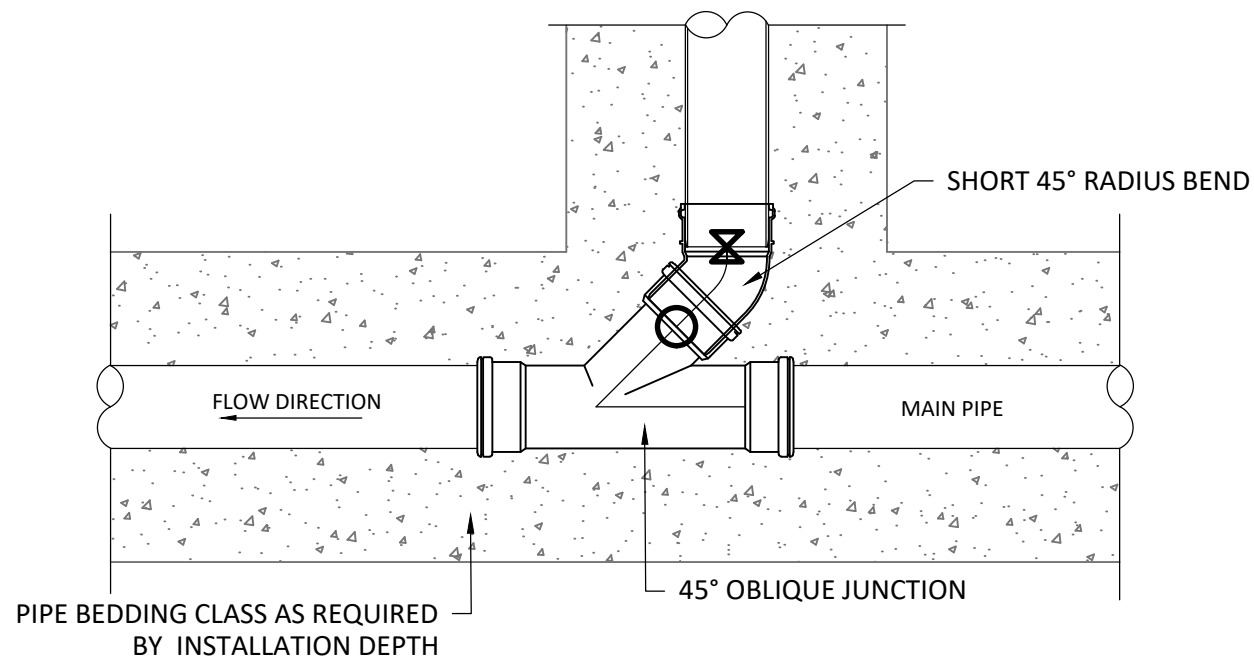


TYPICAL 45° PIPE JUNCTION CONNECTION DETAIL
SCALE: 1:20

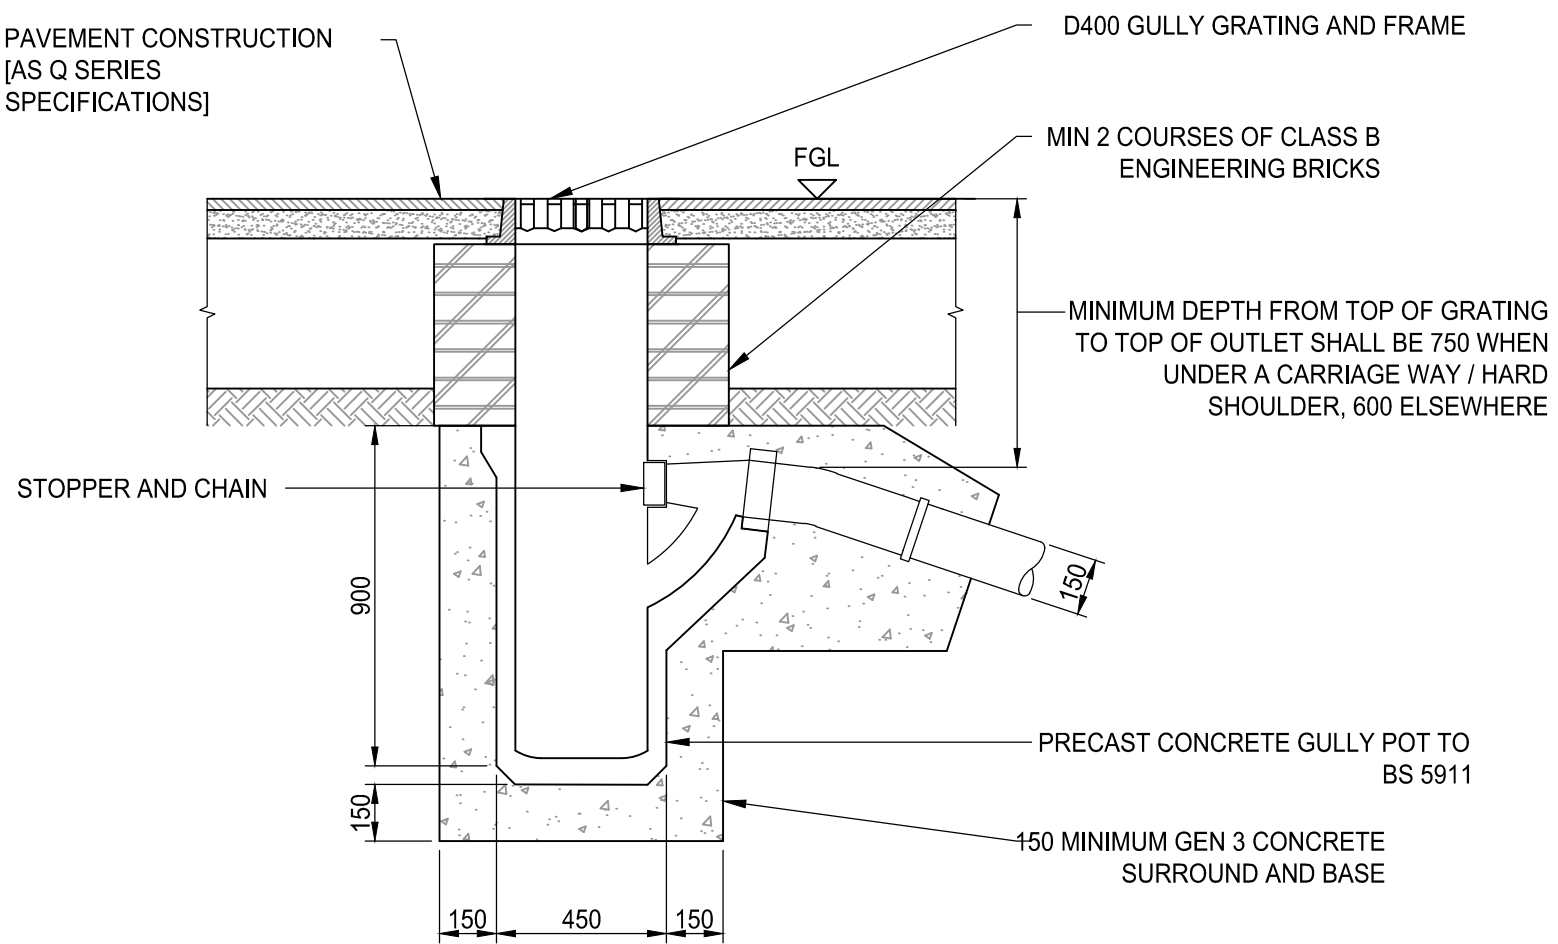

ROAD GULLY
SCALE: 1:20

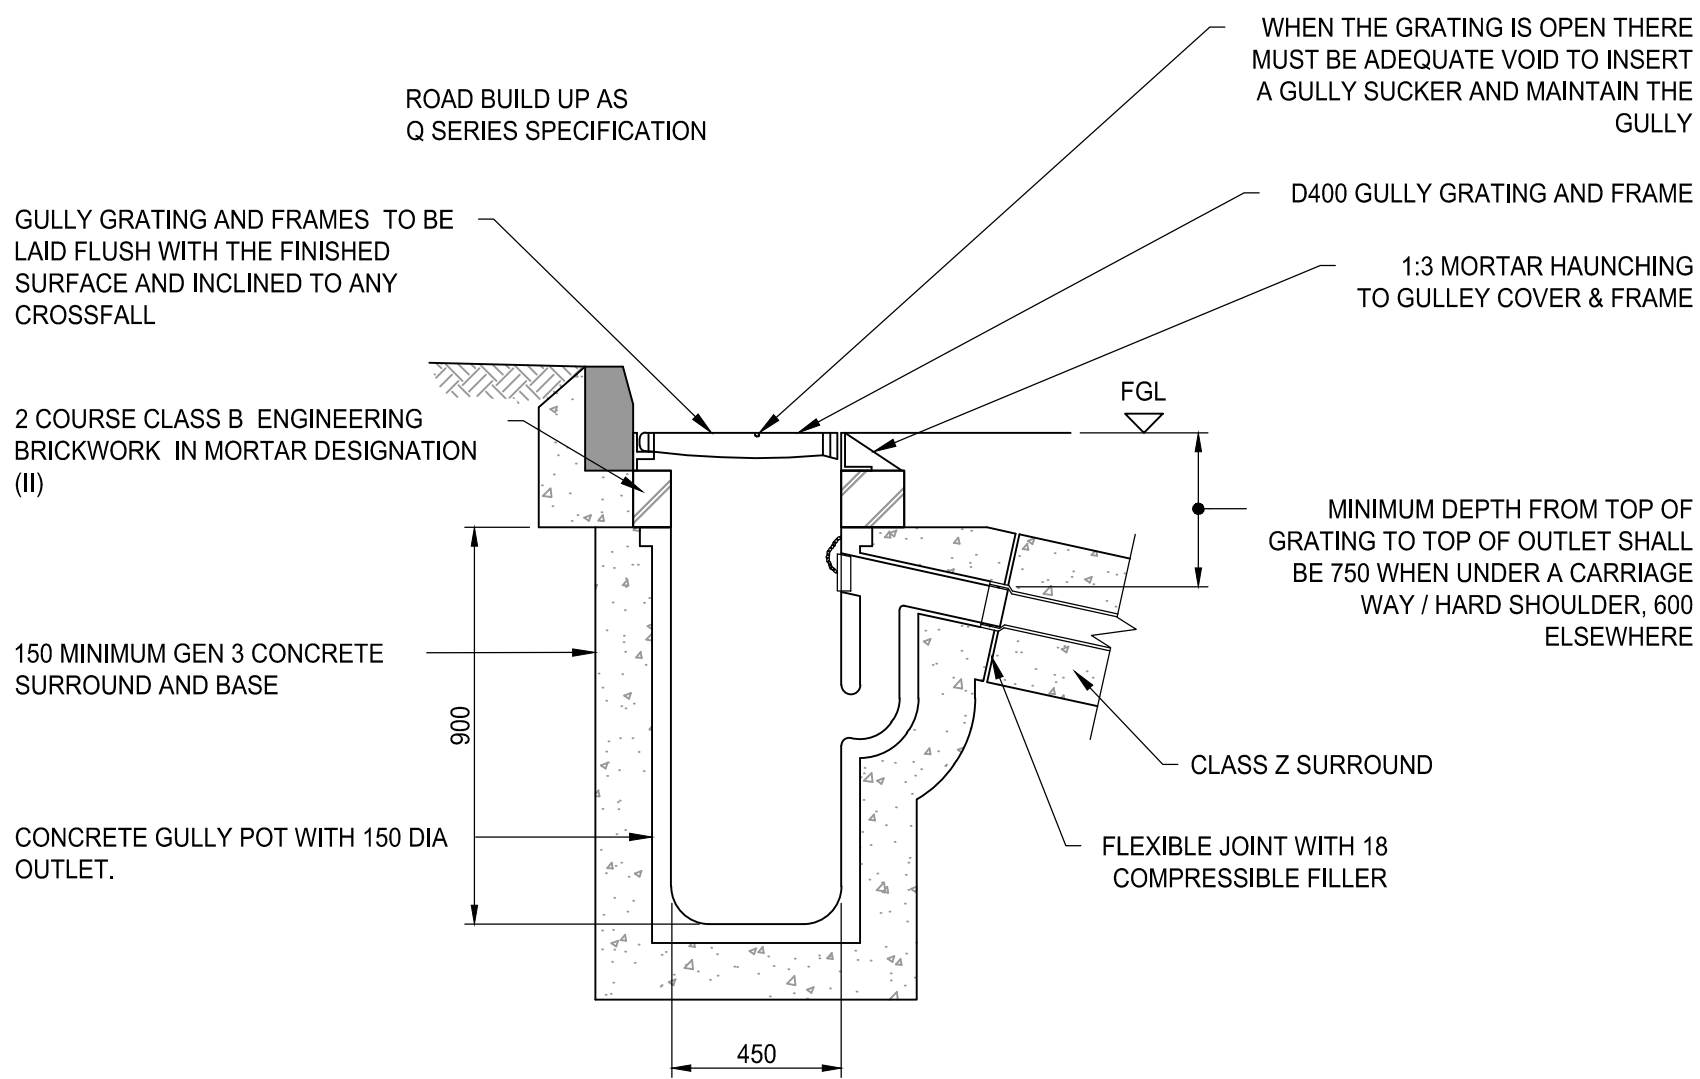

ROAD GULLY AT KERB
SCALE: 1:20

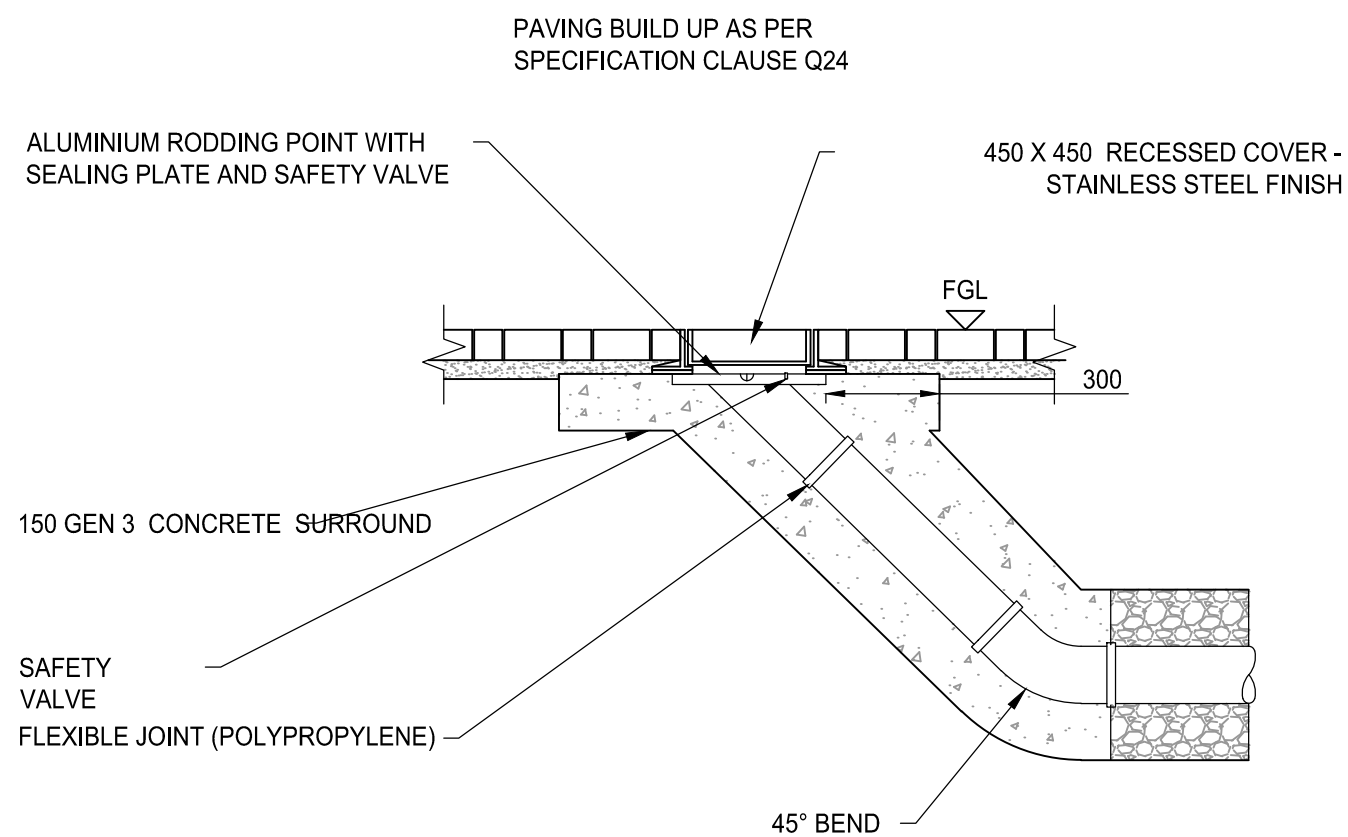

RECESSED RODDING EYE

- STANDARD NOTES
1. THIS DRAWING IS TO BE READ IN CONJUNCTION WITH ALL RELEVANT ARCHITECT'S AND ENGINEER'S DRAWINGS AND THE SPECIFICATIONS.
 2. THIS DRAWING SHOULD NOT BE SCALED.
 3. ALL DIMENSIONS ARE TO BE VERIFIED BY THE CONTRACTOR ON SITE.
 4. ALL DISCREPANCIES SHOULD BE REPORTED TO C.A./E.A. PRIOR TO THE COMMENCEMENT OF WORKS.

© CIVIC ENGINEERS LIMITED

08.04.25	P02	REPOSITIONED DETAILS	HCM	CK
12.07.24	P01	STAGE 4 ISSUE	CD	HCM
DATE	REV	DESCRIPTION	DRAWN	CHKD

CIVIC
ENGINEERS

civicingengineers.com

PROJECT
MAYFIELD PLOT M
THE REPUBLIC
MANCHESTER

TITLE
EXTERNAL WORKS
TYPICAL DRAINAGE DETAILS
SHEET 3

DRAWING STATUS		STATUS CODE	
STAGE 4		-	
CE PROJECT No.	SCALE @ A1	DATE CREATED	DRAWN
1076-27	1:20	JULY 24	CD
DRAWING No.		REV	HM
0197_MAY-CIV-SWI-XXXX-DR-C-310003		REV	P02