


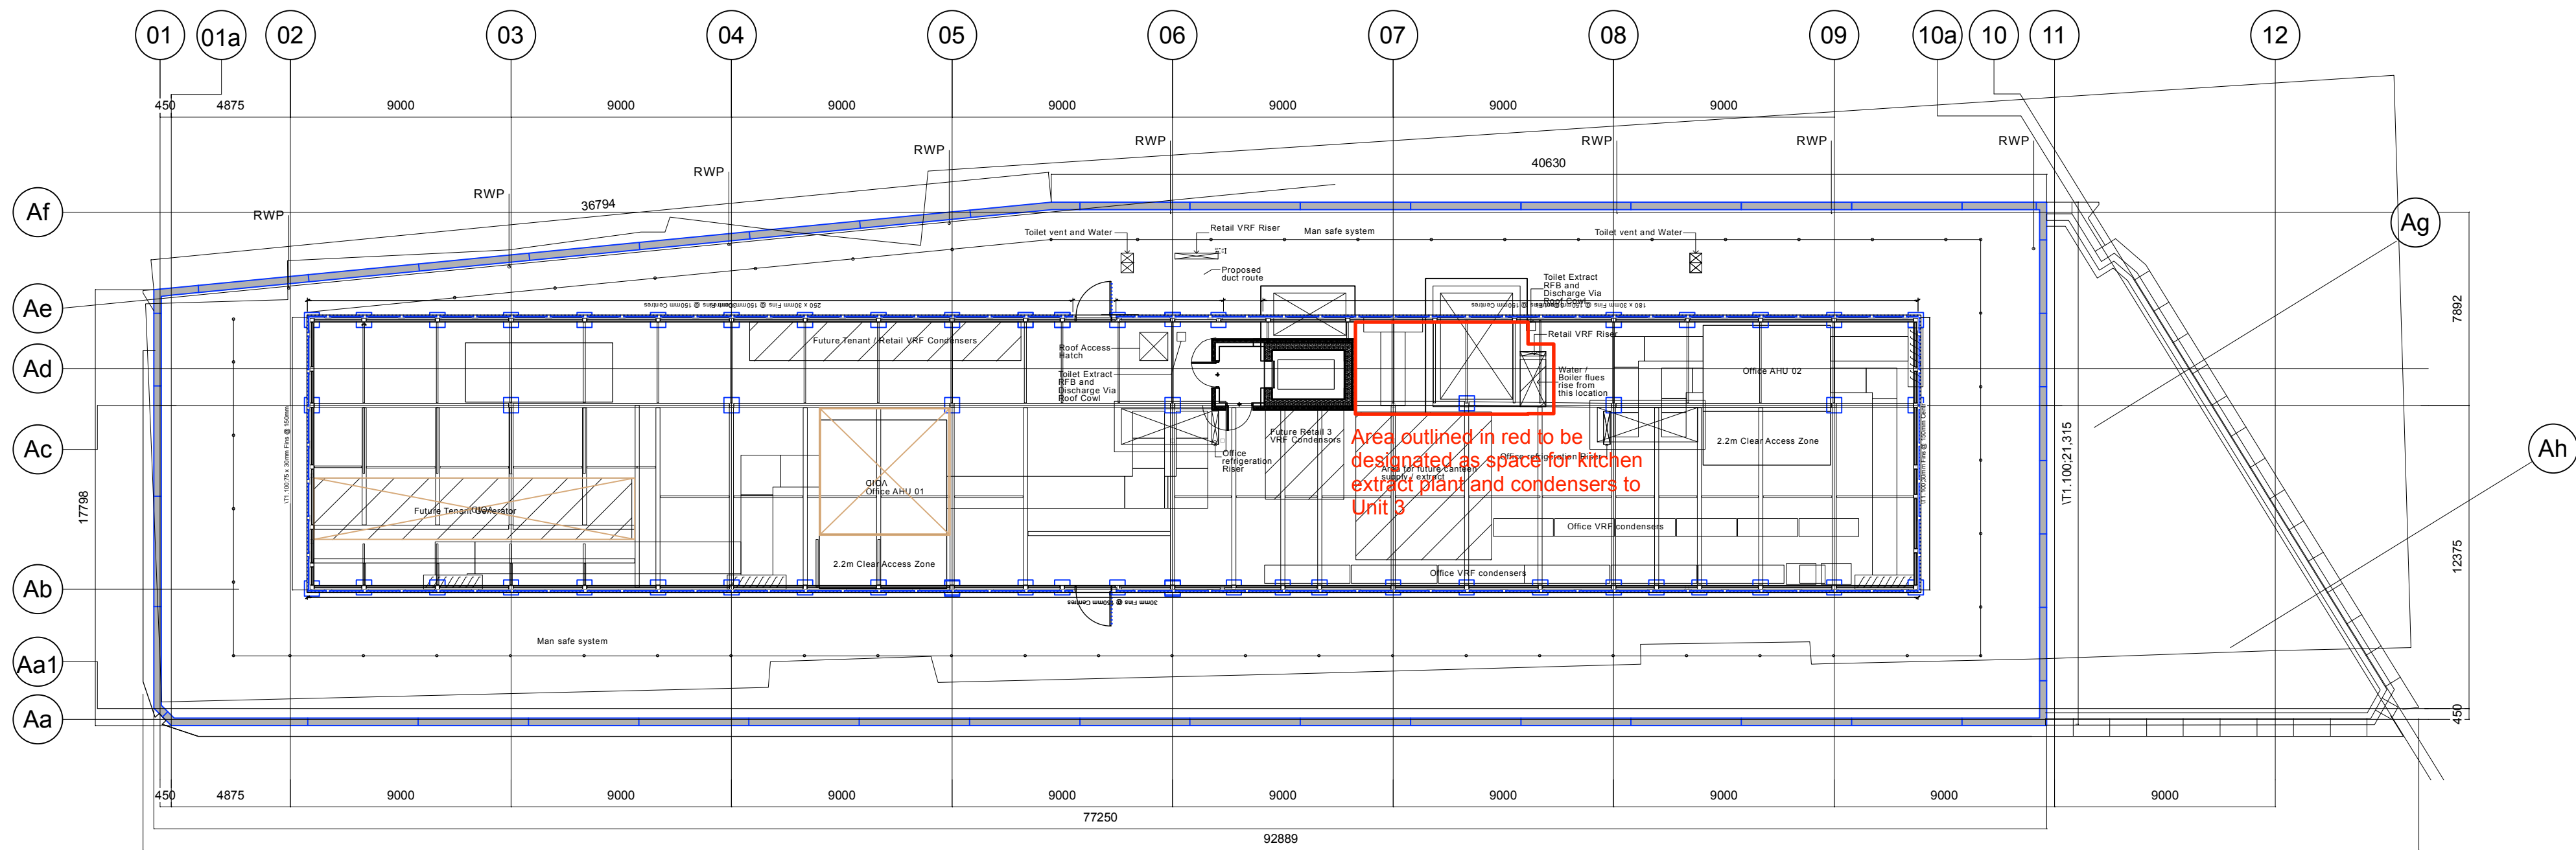


Roof Plan scale 1:200 Note: this drawing to be read in conjunction with INOX drawing 17072/005

Restaurant Air Conditioning & MVHR.

Scope of Works
Mechanical Heat Recovery Ventilation.
2 no HVHR Units
Based on 10 l/s Per Second

Each cassette indoor unit can serve a maximum area of 64m2. 218/64 = 3.4. - 4no cassettes required in total.

Position of cassettes within the restaurant area to be agreed on site prior to installation.

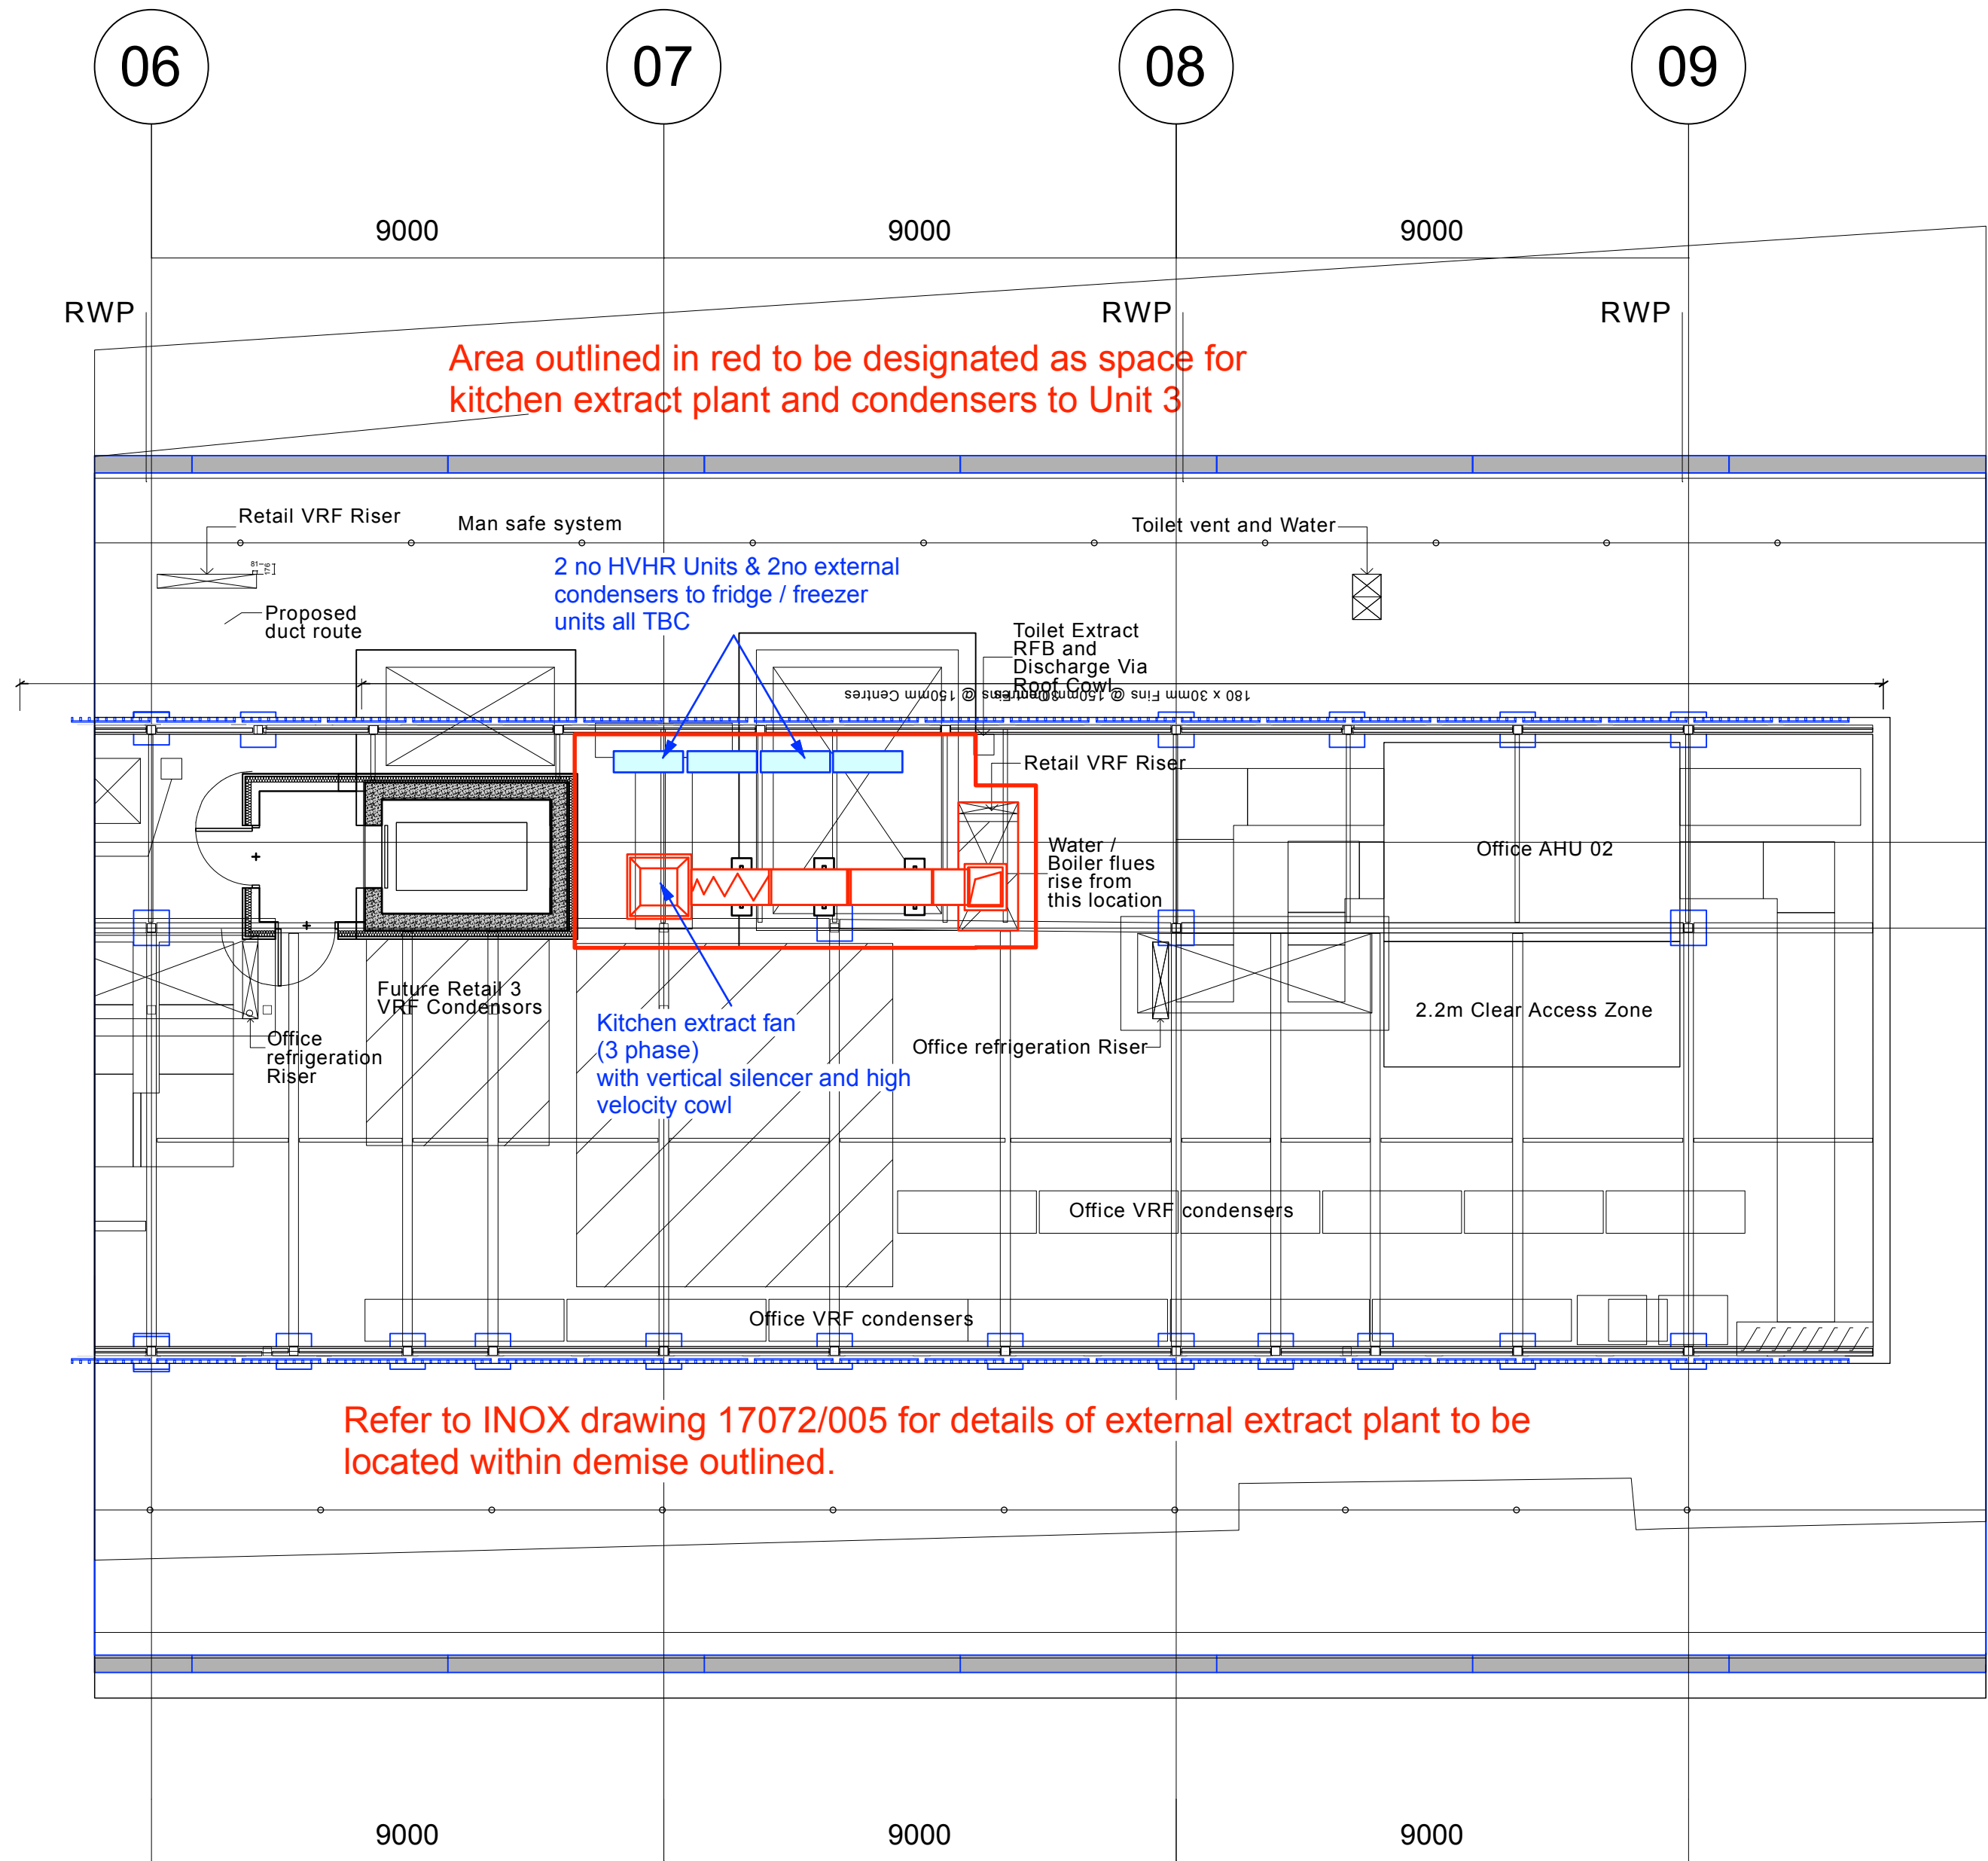

Note:
All ductwork sizes and kitchen extract specification details together with fresh air supply ductwork and fans tas detailed on INOX drawings referred to.

Kitchen Extract Ductwork.


Fire rated Ductwork:
Custom Model No. FRD
This cost covers the upgrade from standard class A ductwork to type A & B 60 minute fire rated ductwork and includes the additional fixings and access doors to carry up to 3.5m3/sec.

Custom Model No. FRD
60mm ROCKWOOL® Fire Duct Slab with a density of 160kg/m3 (10lb/ft3) providing a insulation performance of 60mins

Custom Model No. EXTRACT DUCTWORK
Extract only ductwork system, 55m of standard class A ductwork with EC Box fan and speed controller

Custom Model No. SILENCERS

In-line melinex lined sound attenuator

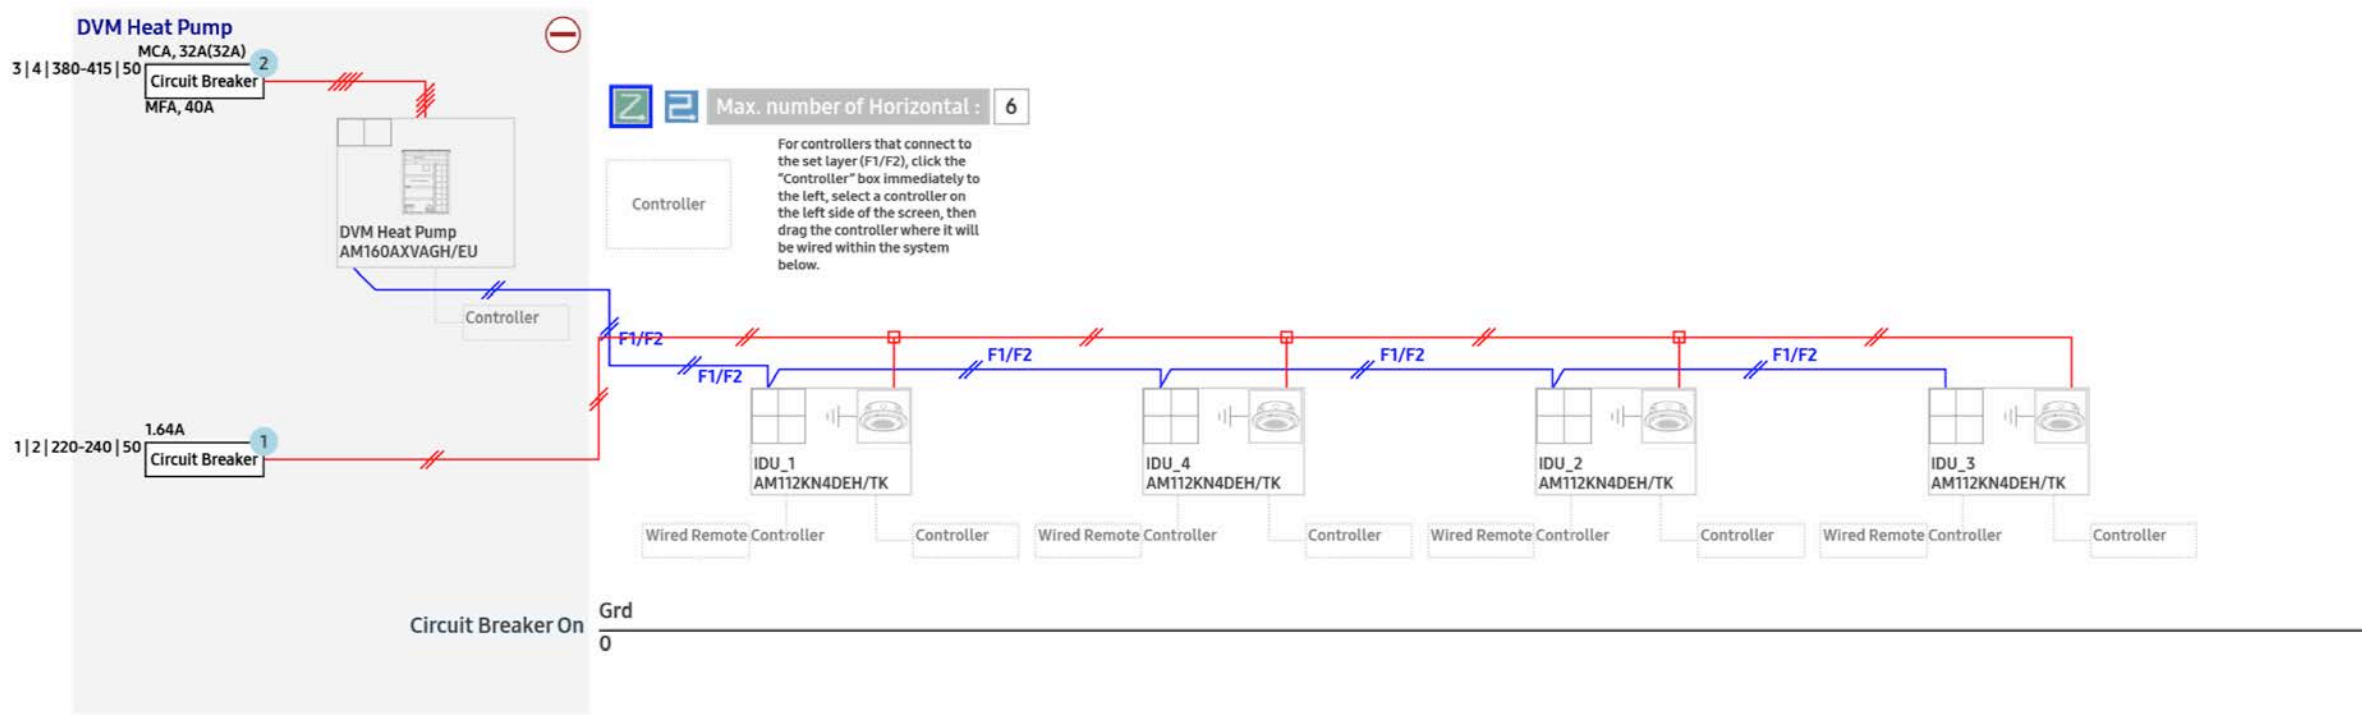

Note: this drawing to be read in conjunction with INOX drawings: 17072/001, 003, 005, 006 and 007.

REVISIONS :
Rev A 15.02.2025 Amended layout following receipt of Acme drawings.

inspire: design consultancy

49 the tannery lawrence street york yo10 3wh
t&f 01904 611 091 e peter@inspiredc.co.uk

CLIENT :
ZaaP Restaurants

SITE : Ground Floor Unit 3, The Lincoln, Brazennose Street, Manchester M2 5BP

DRAWING TITLE:
Roof Plan

DATE :
December 2024

SCALE :
1:100 & 200 @ A1

DRAWING BY :
PS

DRAWING NO:
ZaaP/Manc/105A

CONTRACTORS MUST VERIFY ALL DIMENSIONS ON SITE BEFORE COMMENCING ANY WORK.FIGURED DIMENSIONS TO TAKE PRECEDENCE OVER SCALED DIMENSIONS.THE COPYRIGHT OF THIS DRAWING IS RESERVED.THE DRAWING MUST NOT BE DISCLOSED WITHOUT ANY AUTHORITY. DO NOT SCALE.