


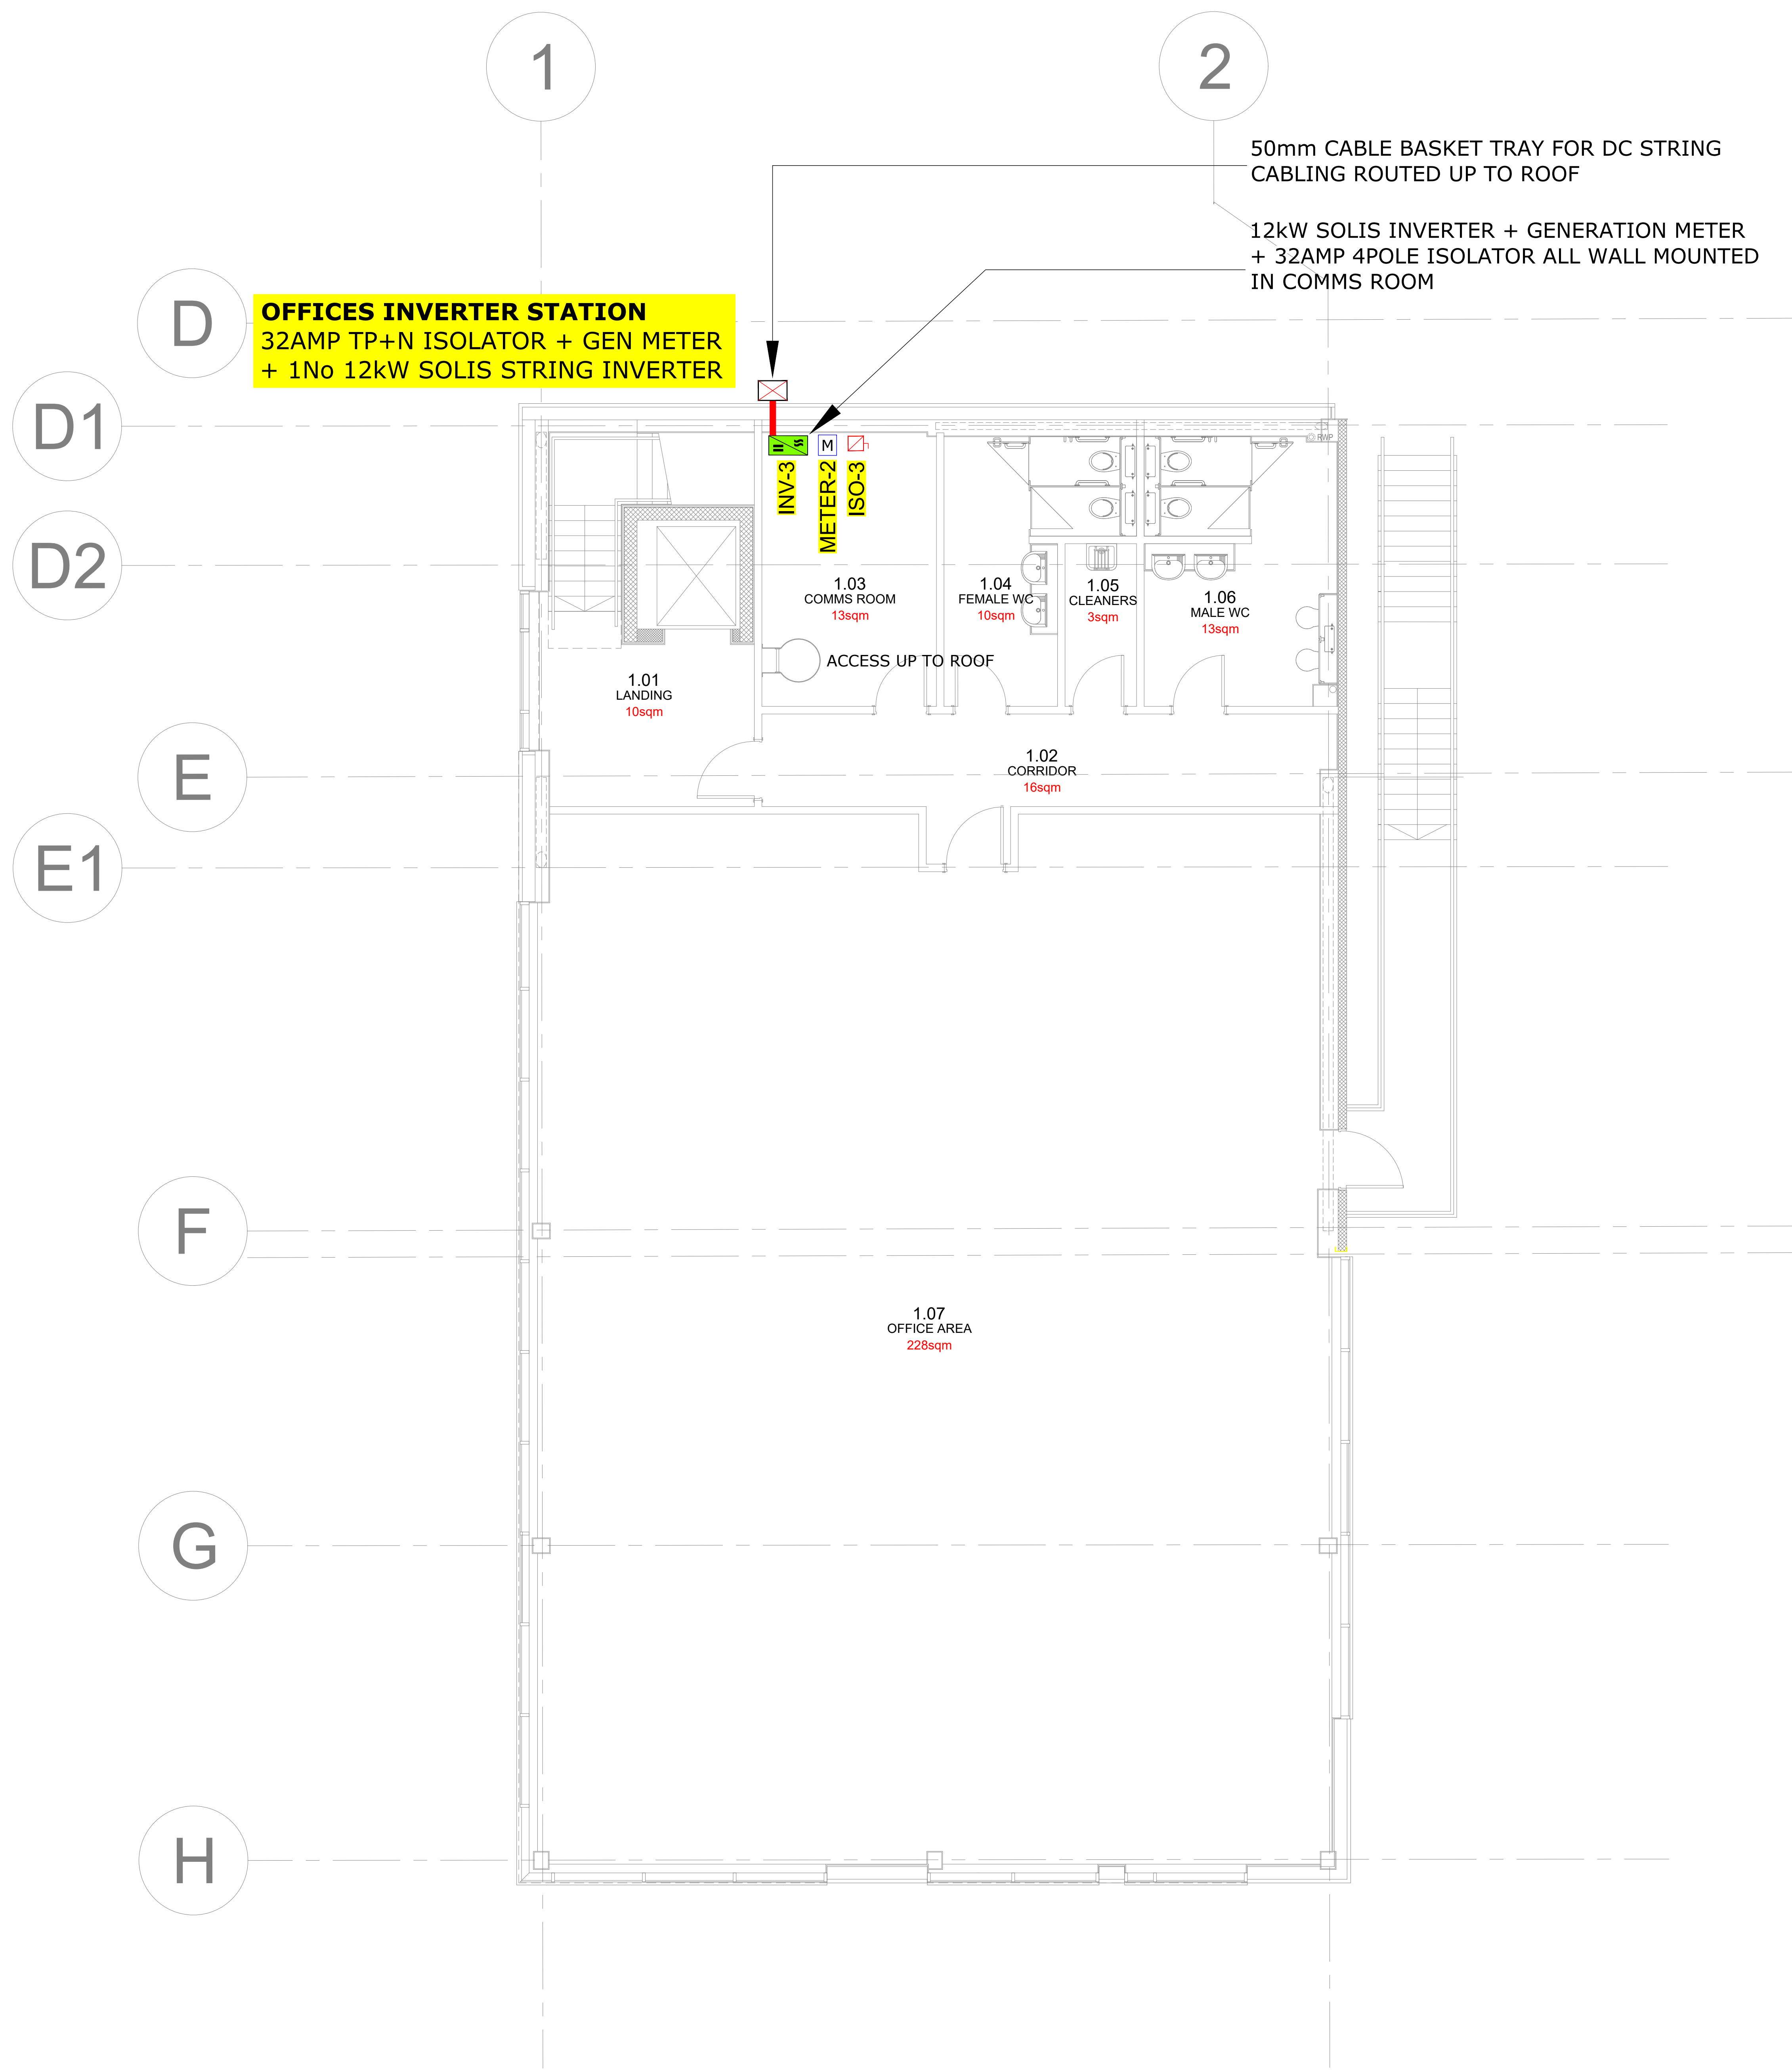


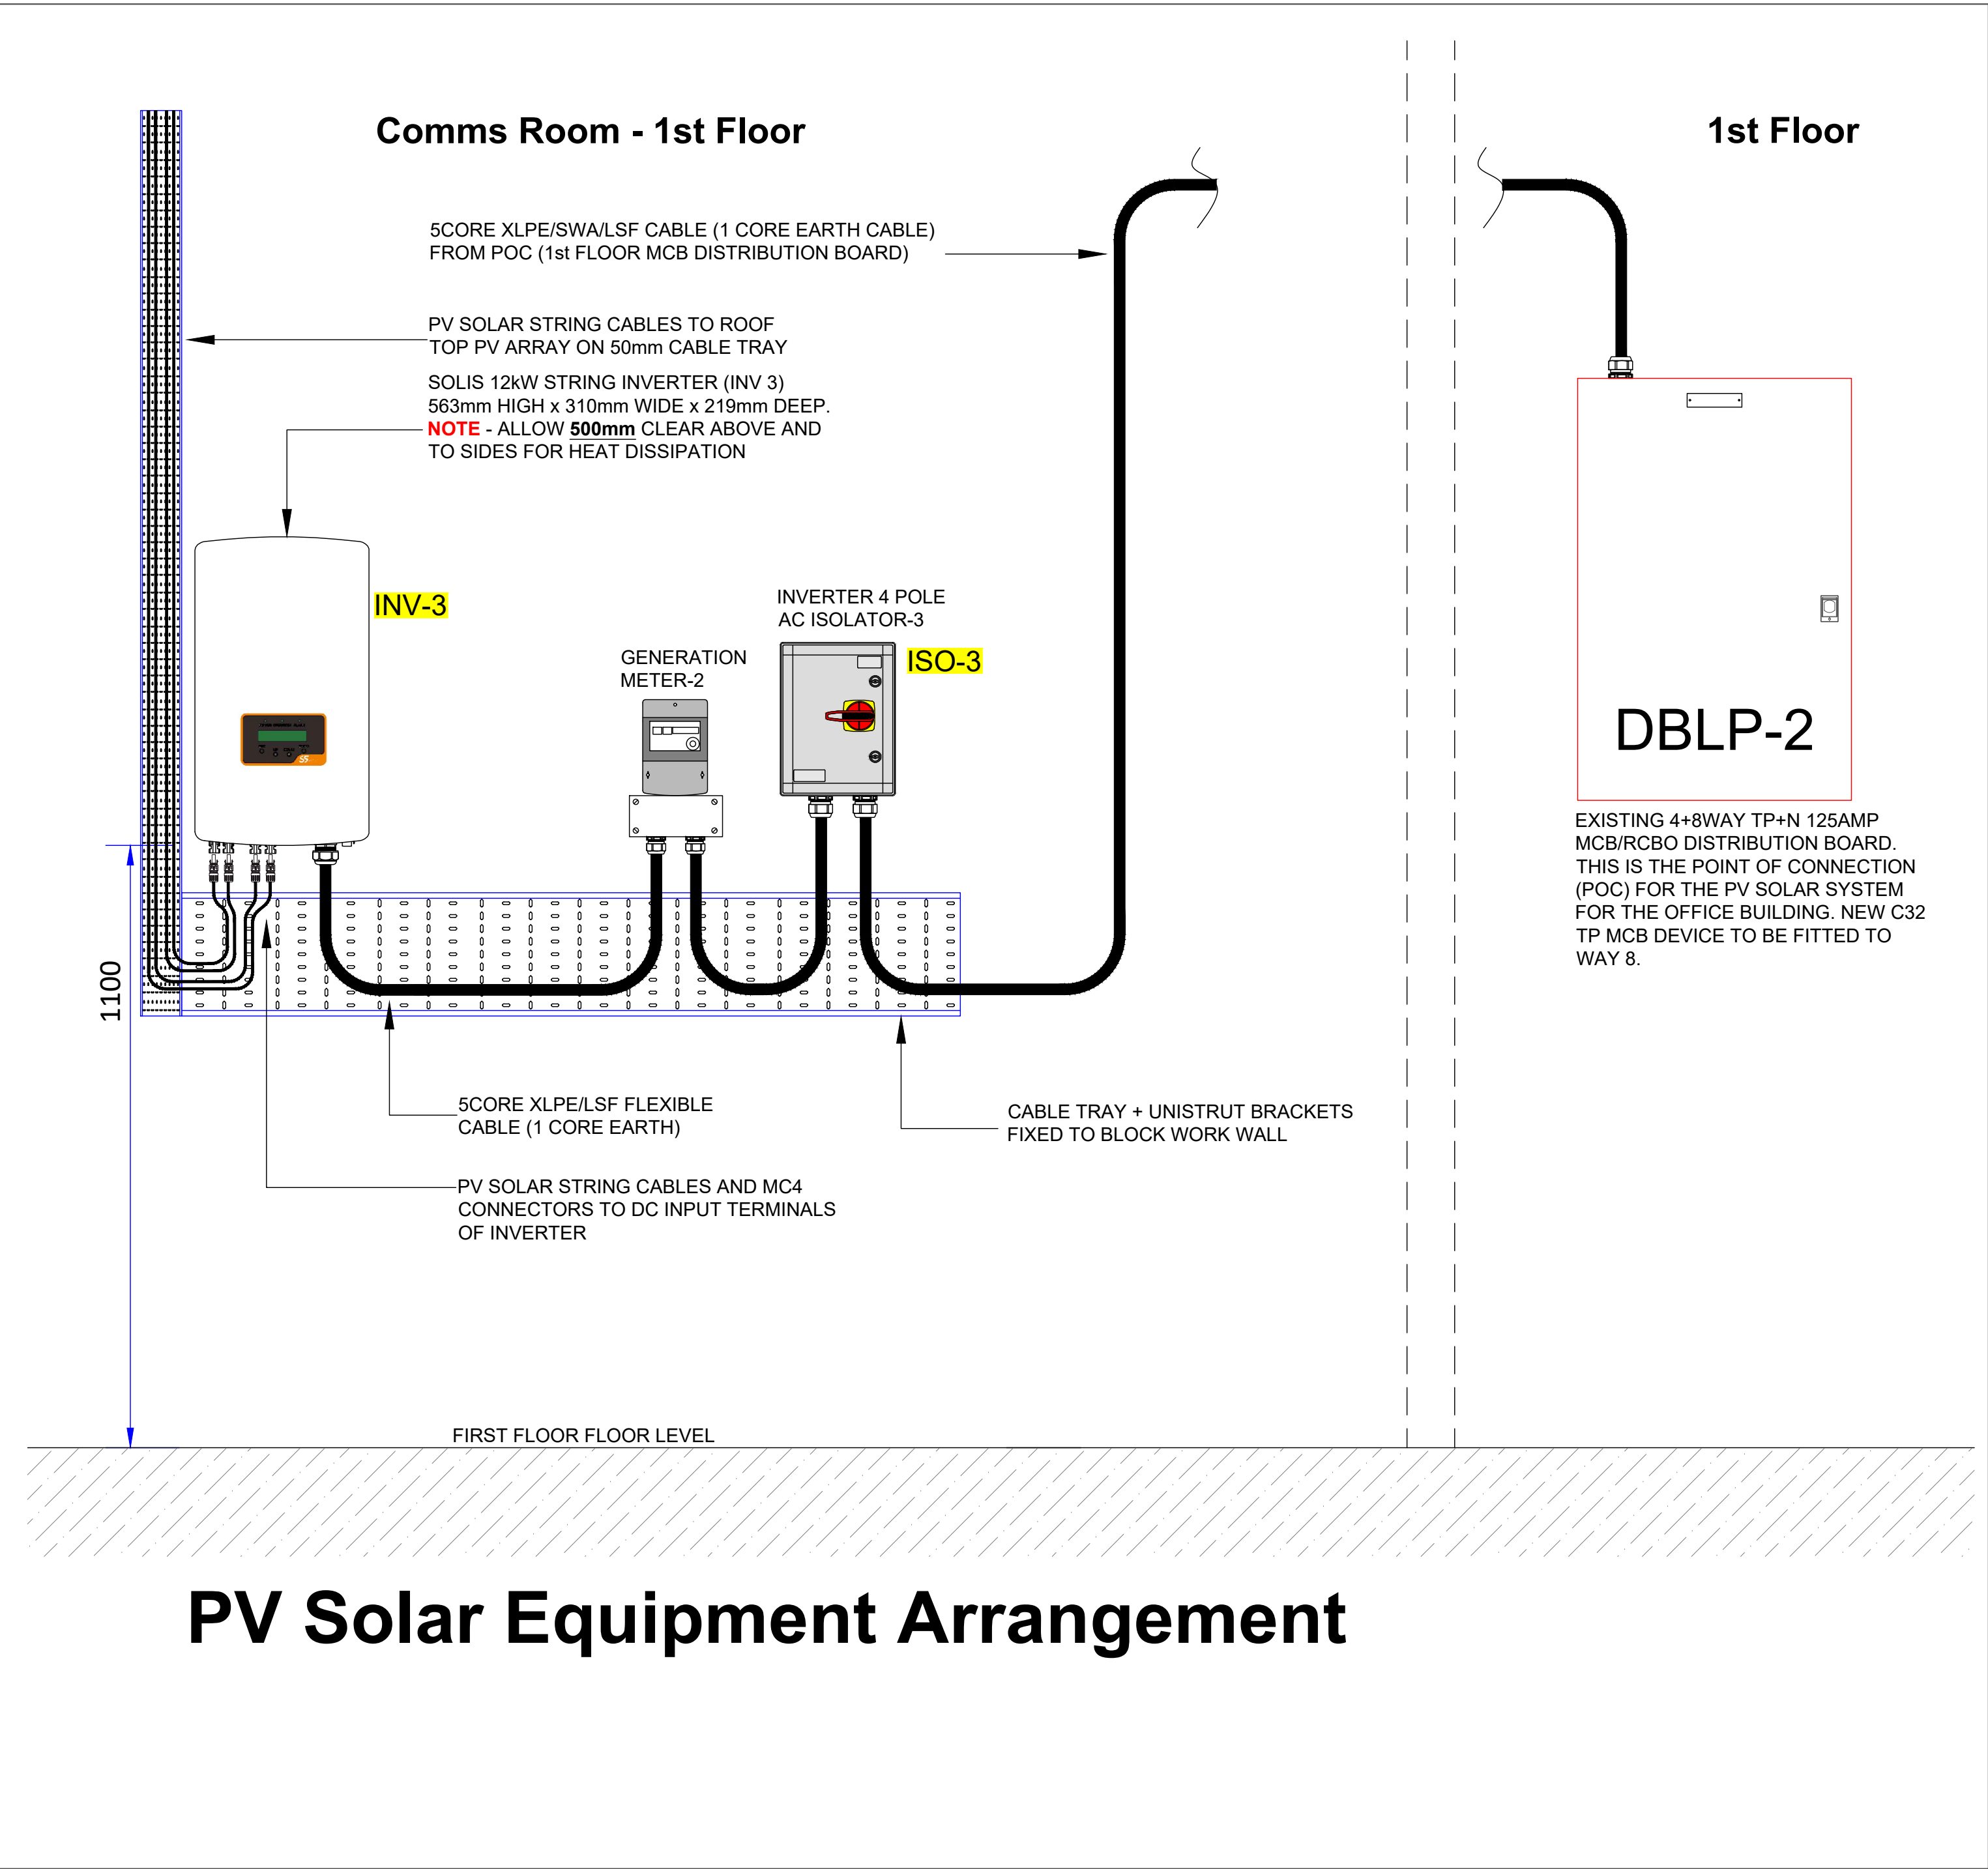

OFFICES 1st FLOOR PLAN - PV SOLAR EQUIPMENT

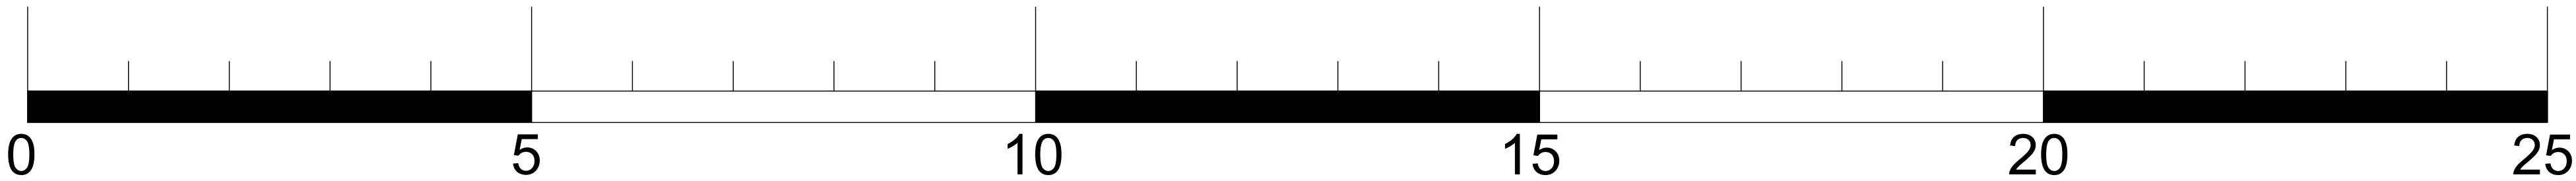

PV Solar Equipment Arrangement

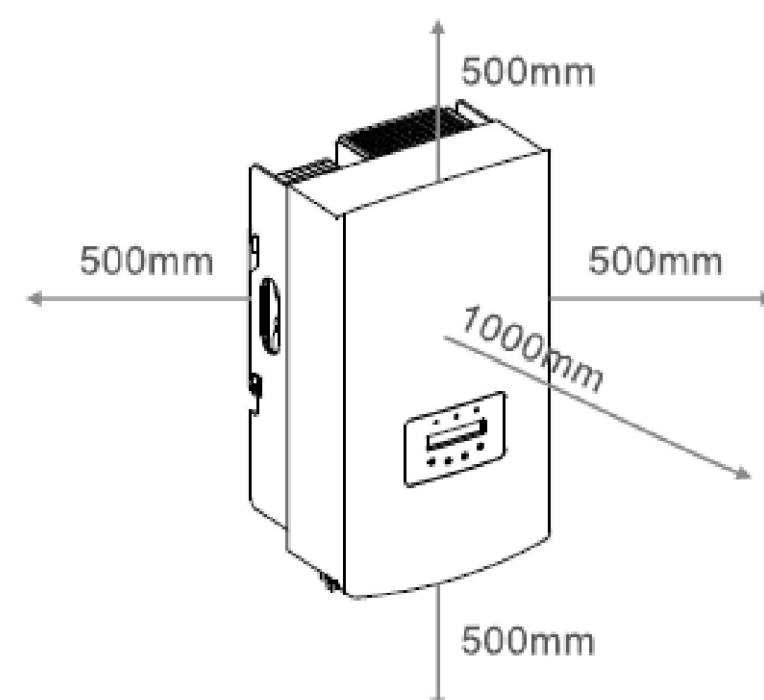

INVERTER CLEARANCES

A	AMc	RM	RS	ISSUED FOR COMMENT	25/08/24
VERSION	DRWN	CHKD	AUTH	REASON FOR ISSUE	DATE
S4				DEVELOPED DESIGN	
SUITABILITY CODE		SUITABILITY DESCRIPTION			



DHL INTERNATIONAL
2 SUNBANK LANE, AIRPORT CITY, WA15 0PT
294.68kWp ROOF PV SOLAR SCHEME
FIRST FLOOR PLAN - PV SOLAR EQUIPMENT

DRAWING NUMBER 2806-E0004					SHEET SIZE A0
					REVISION A