
 


1. DO NOT SCALE FROM THIS DRAWING - USE FIGURED DIMENSIONS ONLY.
2. READ IN CONJUNCTION WITH ALL OTHER CONSULTANTS / SPECIALISTS DRAWINGS, REPORT ANY DISCREPANCIES BEFORE AFFECTED WORK COMMENCES.
3. ALL SETTING OUT DIMENSIONS TO BE CHECKED ON SITE BY CONTRACTOR BEFORE WORK COMMENCES.
4. THIS DRAWING REMAINS COPYRIGHT OF KEPczyk PEARCE SANDERSON LTD. COPY / DISTRIBUTE ONLY WITH CONSENT OF THE AUTHOR.

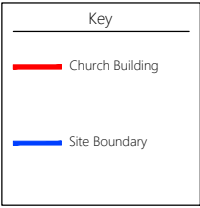

Scale Bar (1:500)



Site Plan as Existing
Scale 1:500

Contract Lighting Renewal Works		Site Plan as Existing			
Client	Society of Jesus (Jesuits)	Contract No.	2013	Drawn	MS
Building / Structure	The Church of the Holy Name of Jesus, Oxford Road, Manchester M13 9PG	Date	Jan 2025	Revision	-
KEPCZYK PEARCE SANDERSON ARCHITECTS, SURVEYORS & HISTORIC BUILDING CONSULTANTS		Address:	75 Wilmslow Road, Handforth, Wilmslow, Cheshire SK9 3EN		
		Tel:	01625 400103		
		Drawing No.	EX 02		
		Scale	1:500 @ A3		