



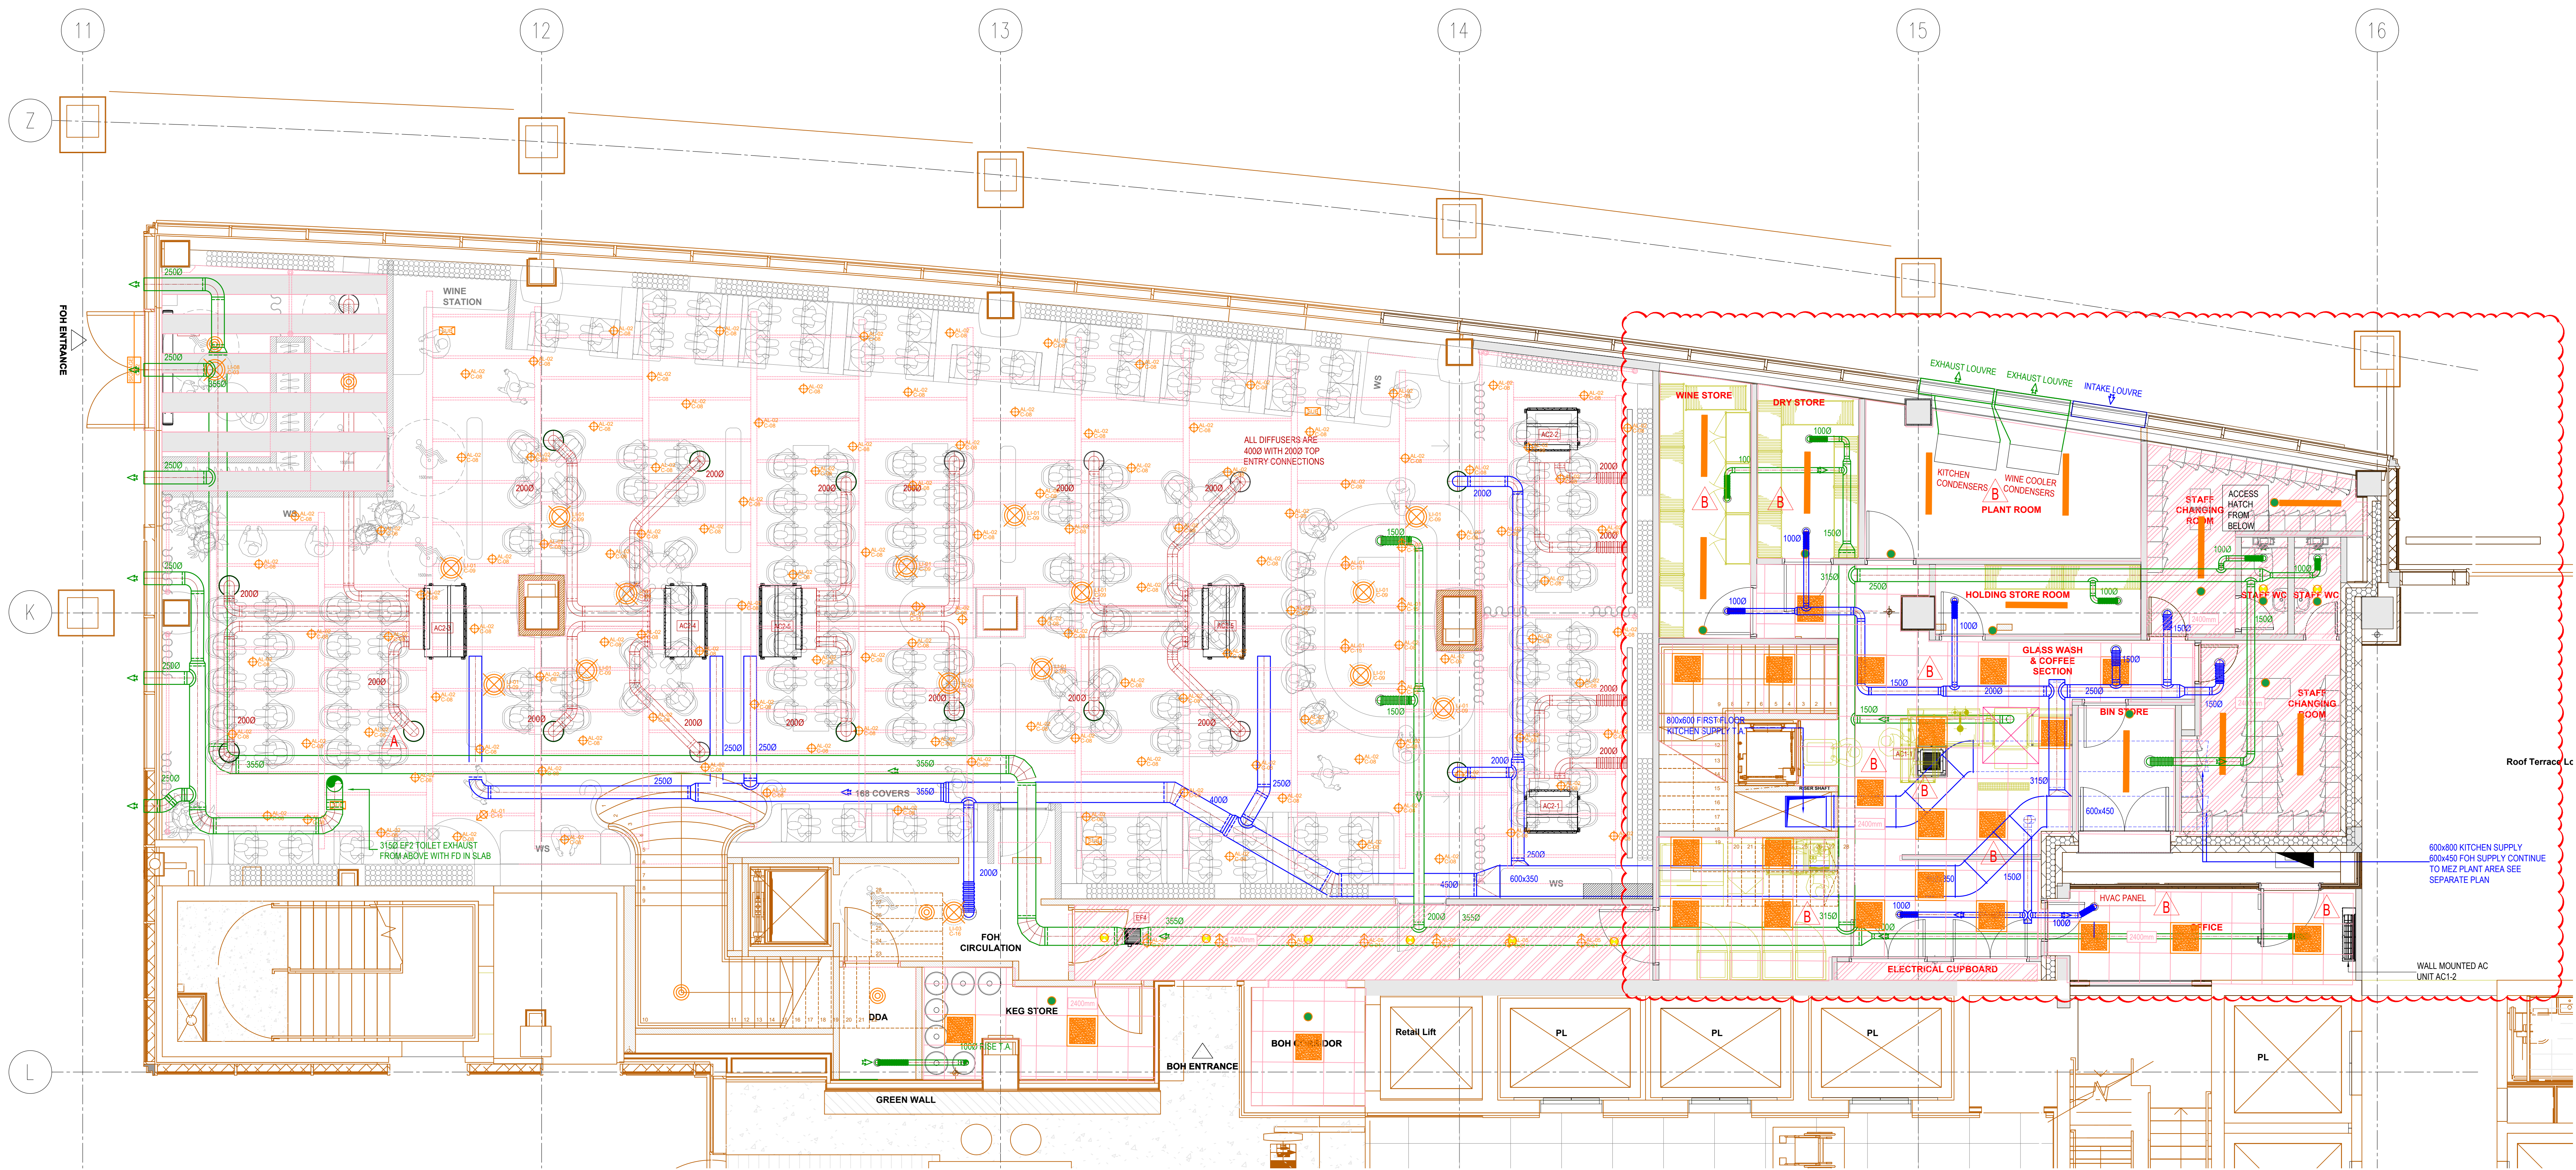

GROUND FLOOR

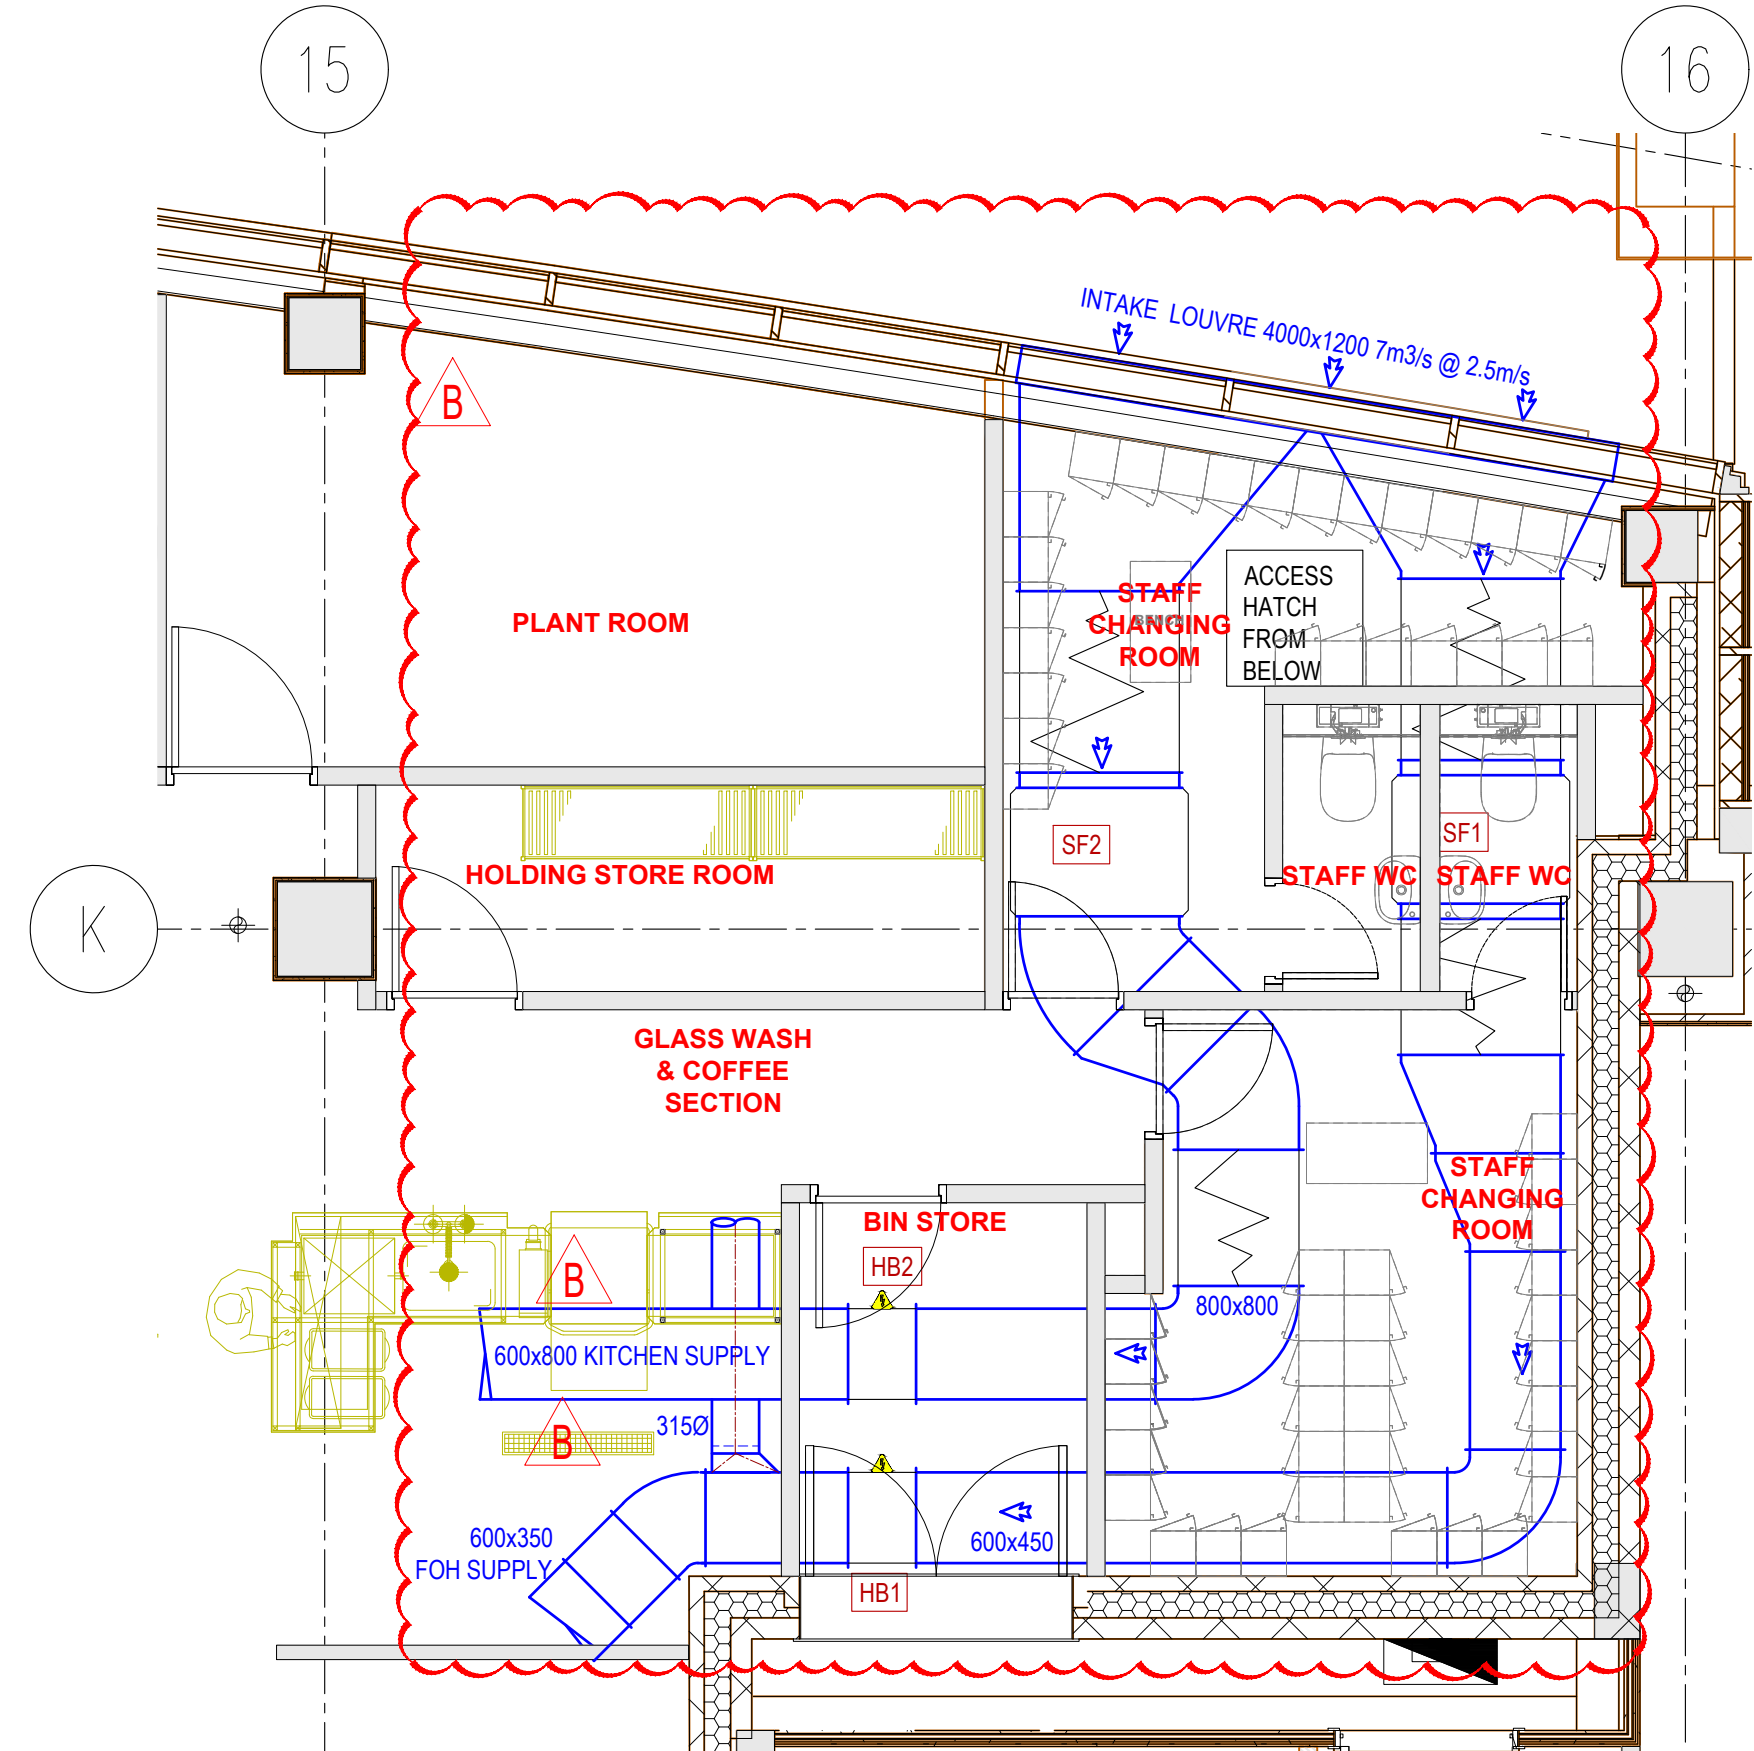

MEZZANINE PLANT AREA

General notes:

- Portions of all equipment, ductwork and fittings are indicative only.
- Contractor shall confirm the sequence of installation works to ensure safe access to plant.
- Services shown to health & safety issues. Liaise with the main contractor to ensure that installation works are programmed to ensure that there are no clashes.
- All dimensions shall comply with the relevant British Standards.
- The drawing was produced using CAD and should not be amended by hand.
- Dimensions given are for reference and should be checked on site prior to commencement of work.

Specific notes:

- This drawing should be read in conjunction with all architectural, structural and services drawings for this project.
- Contractor shall confirm the sequence of installation works to ensure safe access to plant.
- Services shown to health & safety issues. Liaise with the main contractor to ensure that installation works are programmed to ensure that there are no clashes.
- All dimensions shall comply with the relevant British Standards.
- The drawing was produced using CAD and should not be amended by hand.
- Dimensions given are for reference and should be checked on site prior to commencement of work.

METERAGE

SUPPLY DUCTWORK	0.0m
WC EXTRACT DUCTWORK	0.0m
AC PIPEWORK	0.0m

Quantities are for this sheet only

No.	Date	Rev.	Description
B	30-04-24	01	GROUND FLOOR KITCHEN SUPPLY DUCTS RELOCATED. DUCTWORK REVISED.
A	24-04-24	01	CONDENSERS RELOCATED. AC UNITS RELOCATED TO SUIT NEW WALL LAYOUT. MEZ PLANT AREA UPDATED HVAC PANEL. RELOCATED WATER/WATERS DRAUGHT. FOH SUPPLY REVISED. EXHAUST CONNECTIONS TO LOUVER REVISED AND FOH GRILLE LOCATIONS REVISED.

Client: **BIG MAMMA STUDIO**

Project: **2306 - MANCHESTER**

Drawing Title: **GROUND FLOOR AIR CONDITIONING AND VENTILATION LAYOUT**

Drawing No.: **001-1204-01** Rev: **B**

Scale: 1:50 @ A0 1:100 @ A2

Drawn By: KDM Checked By: - Date: 04.04.24

chapman ventilation

15-20 Woodfield Road, Walsley Garden City, Huddersfield AL7 1JQ
Tel: 01471 372858 Fax: 01471 372001
Email: info@chapmanventilation.co.uk Web: www.chapmanventilation.co.uk

Copyright of this drawing resides with Chapman Ventilation Limited ©