



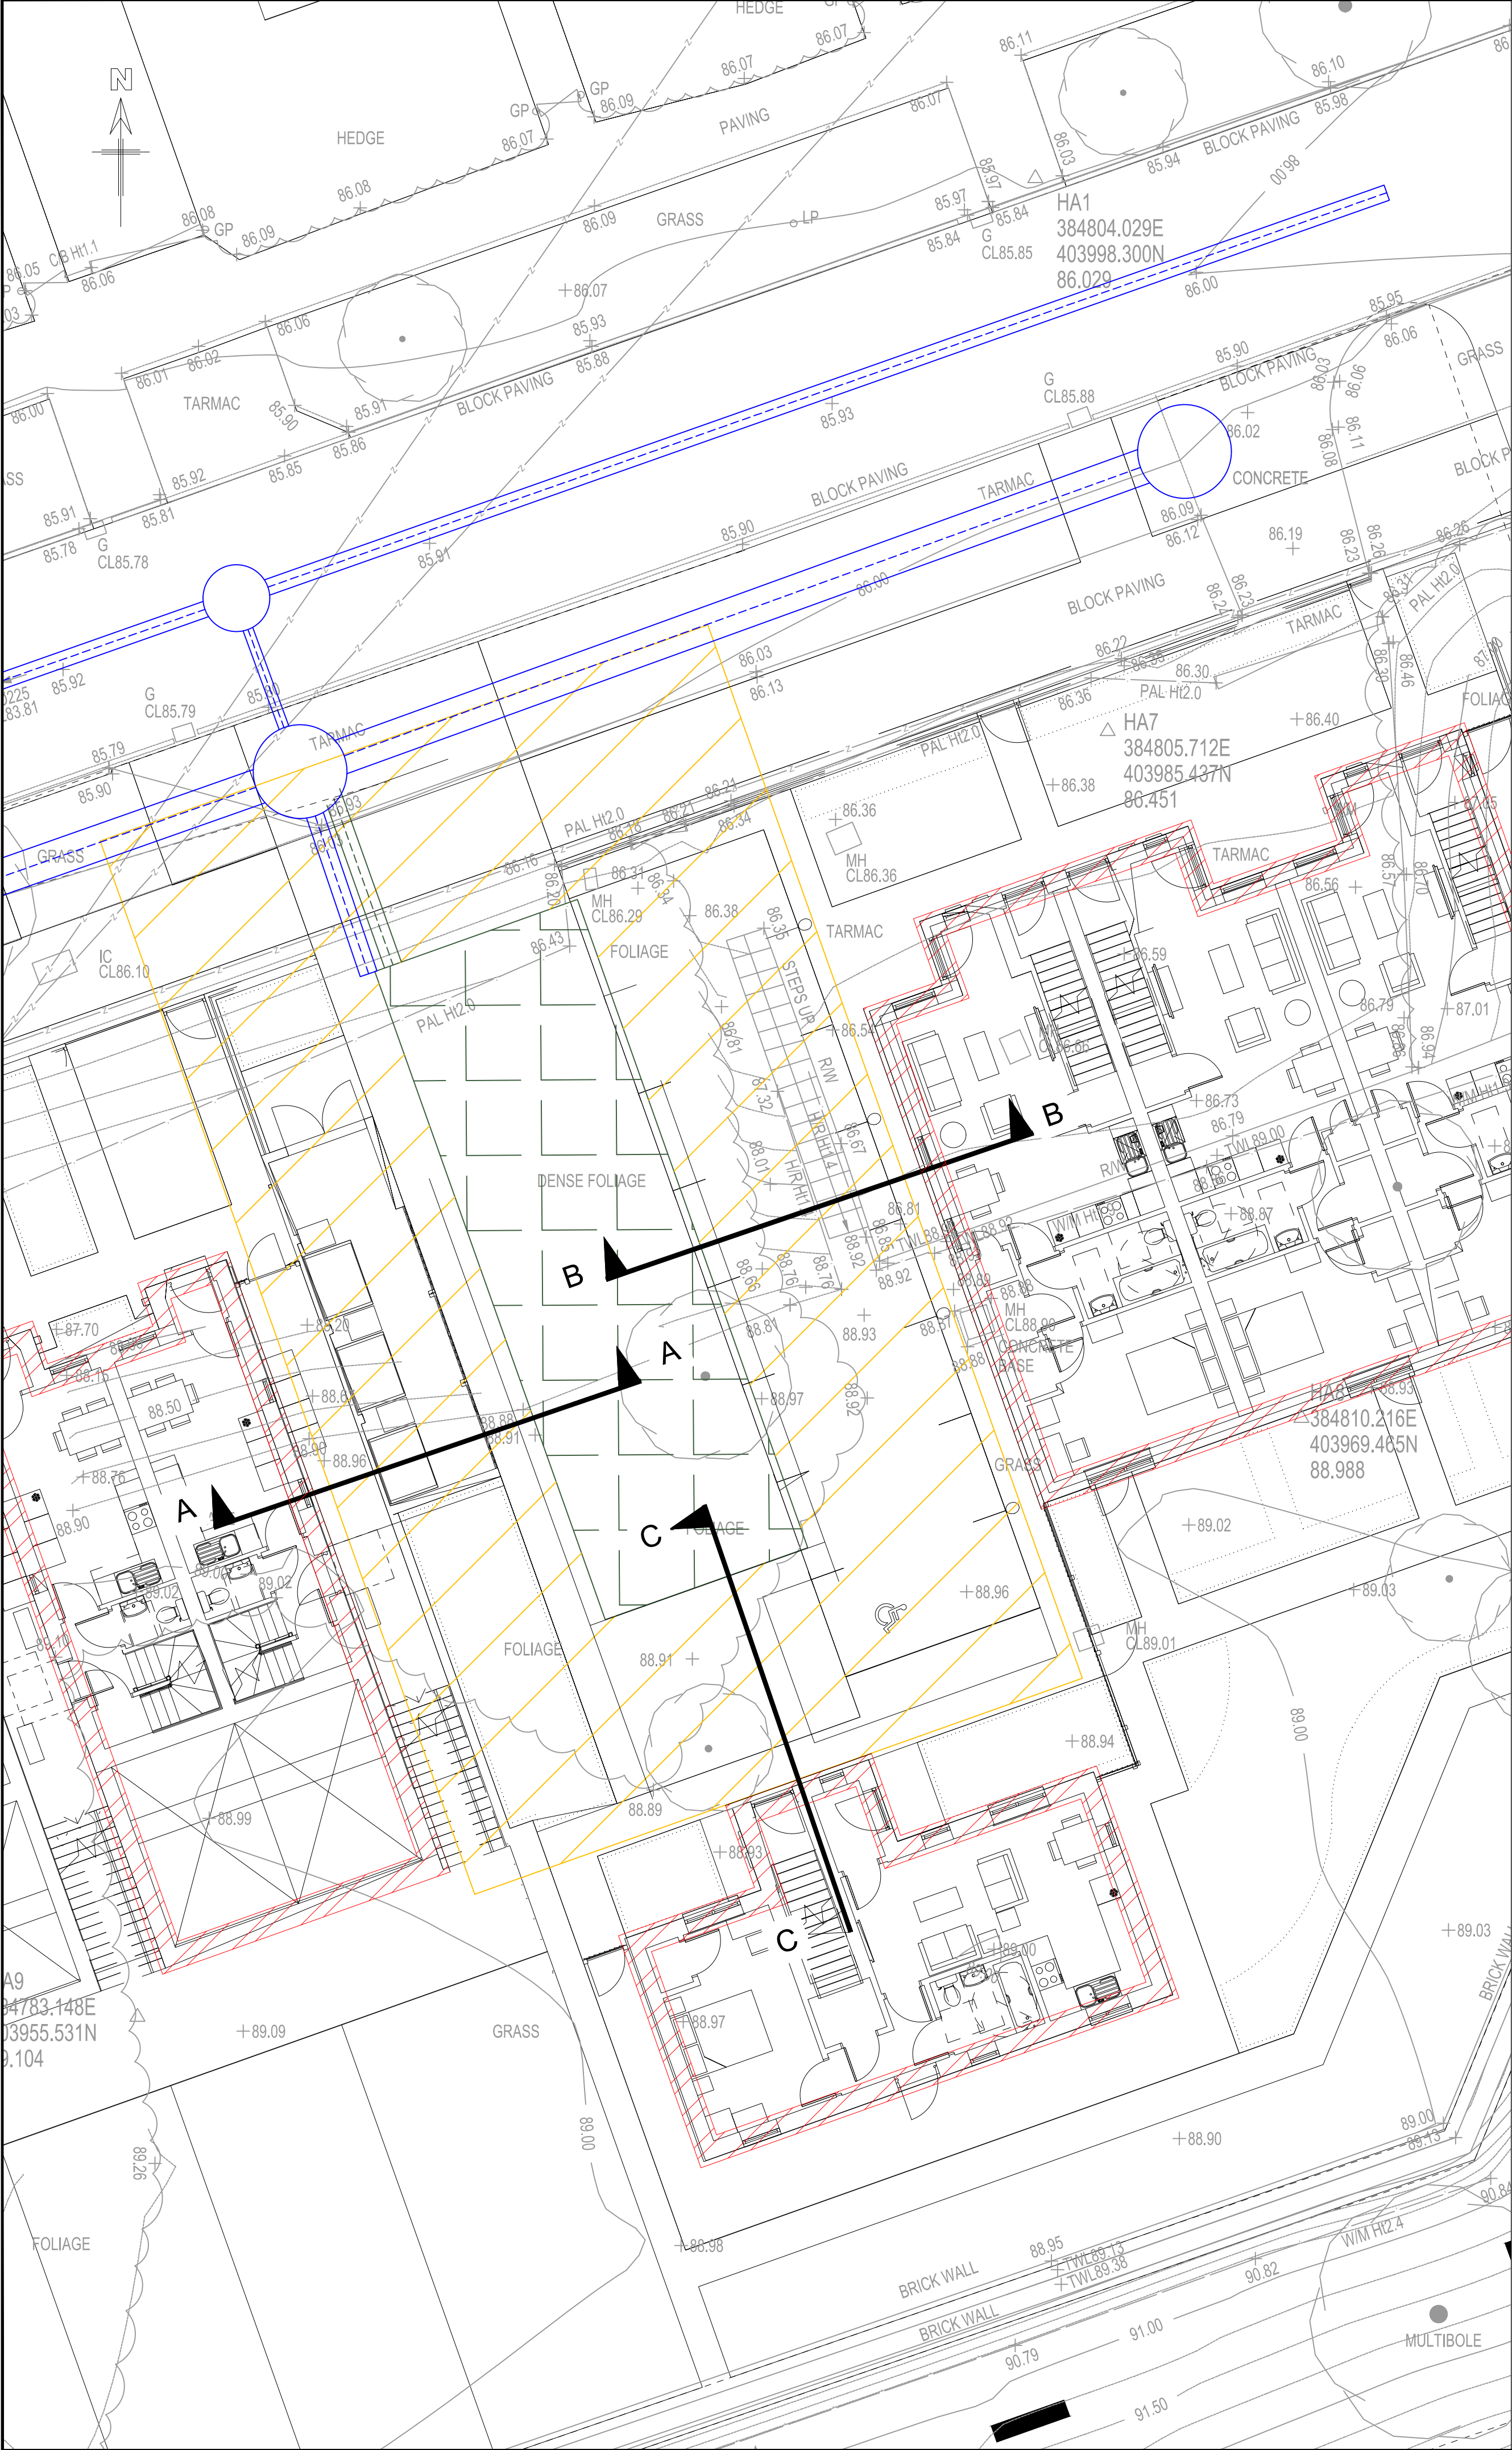


BLOCK 3

FOR FOUNDATION
PLAN SEE
DRAWING
106240-PEF-FD-XX-DR-S-10003

SECTION A-A
1:50 SCALE

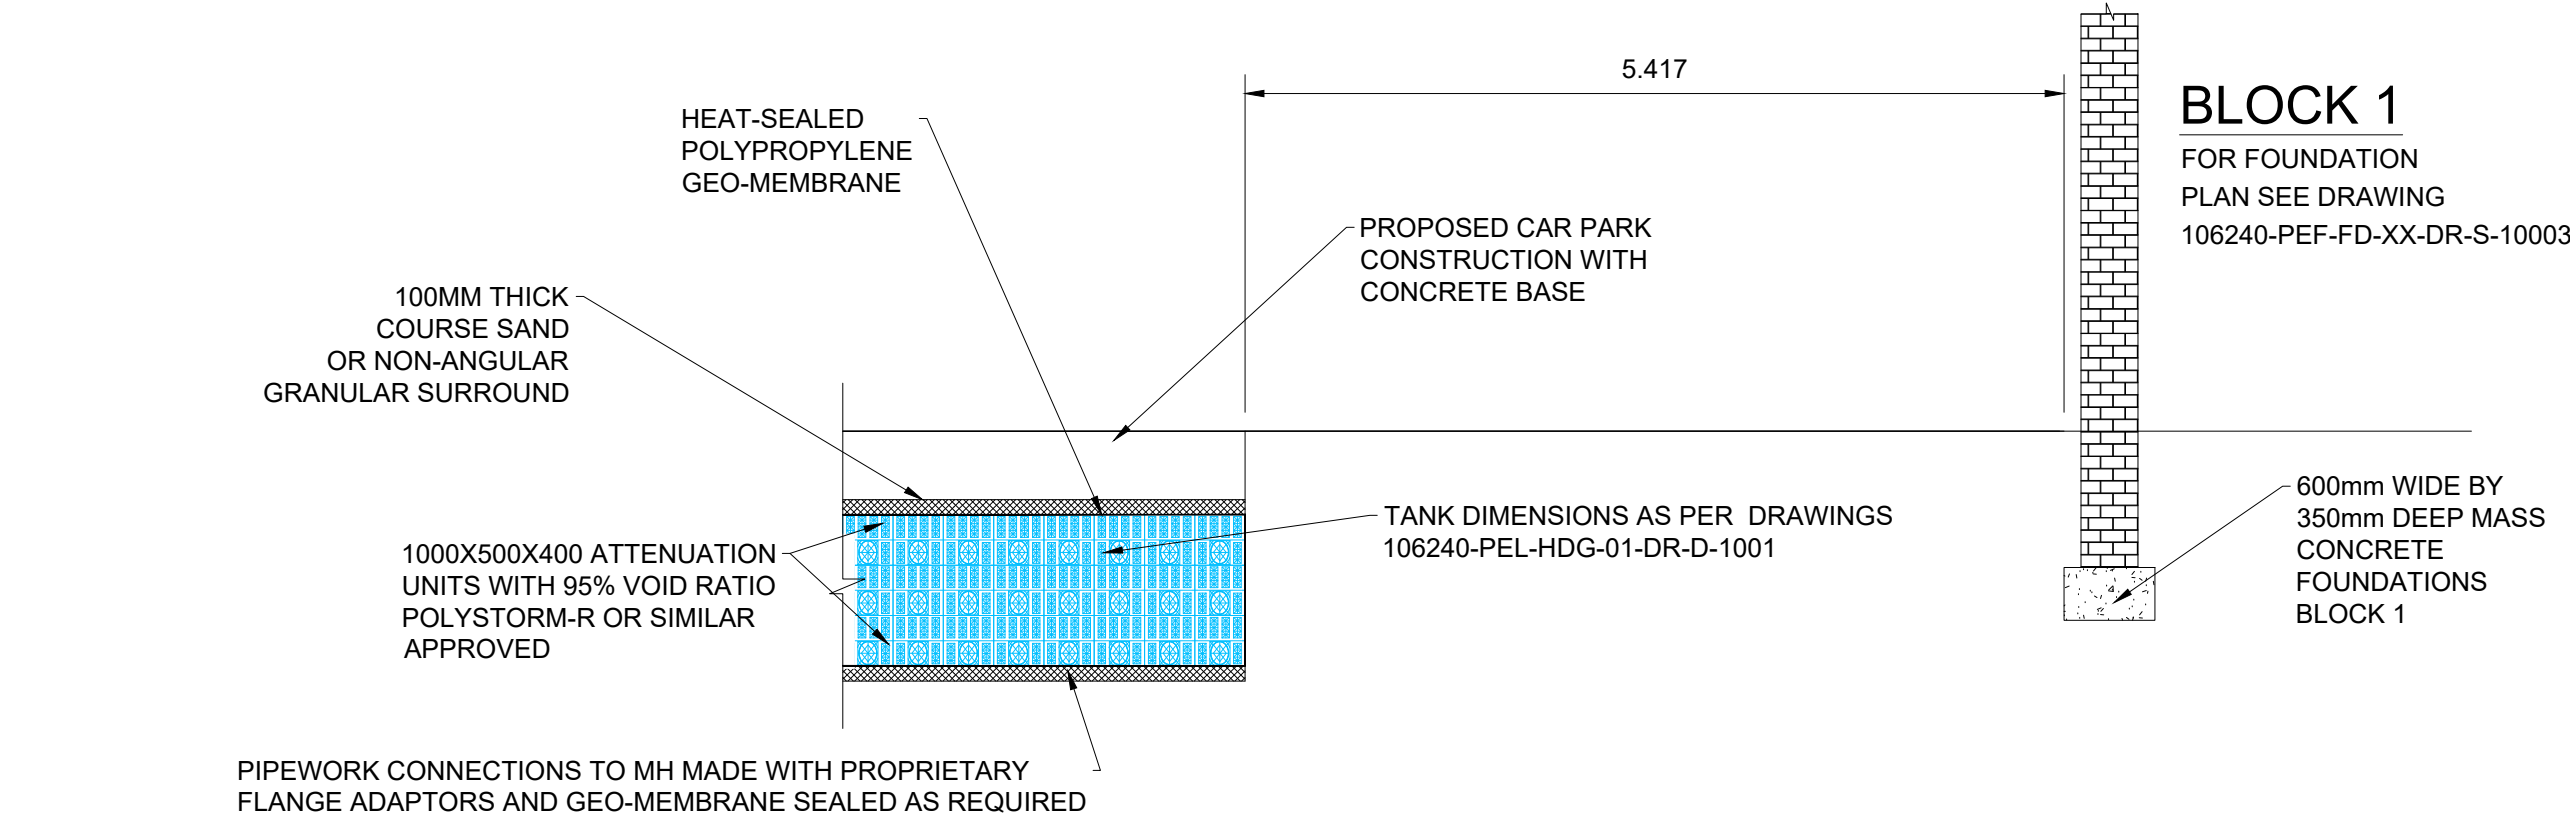

SECTION B-B
1:50 SCALE

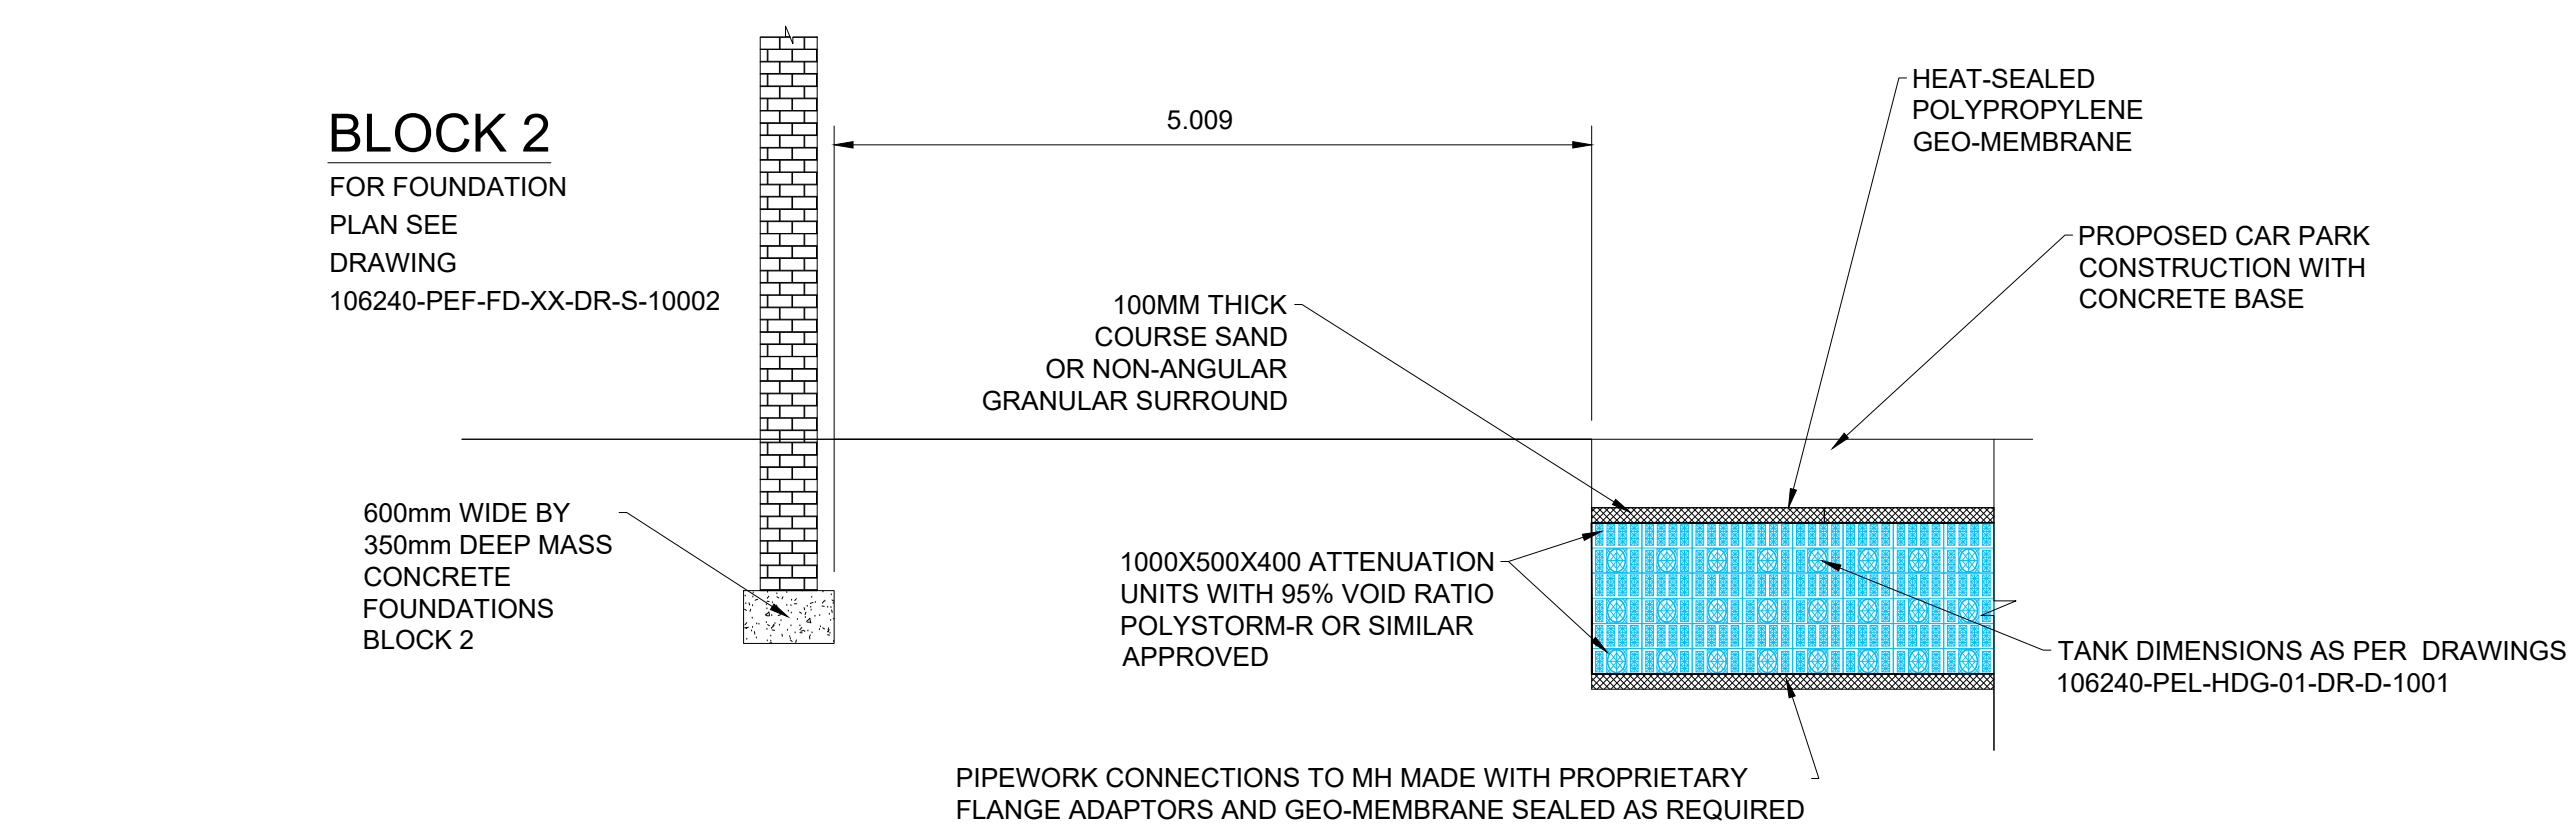

SECTION C-C
1:50 SCALE



- GENERAL NOTES
- G1. DO NOT SCALE THIS DRAWING.
- G2. ANY DIMENSIONAL DISCREPANCIES SHOULD BE NOTIFIED TO THE ENGINEER IMMEDIATELY.
- G3. ALL DIMENSIONS ARE IN MILLIMETRES - (mm)
ALL LEVELS ARE IN METRES - (m) AND ARE ABOVE ORDNANCE DATUM AT NEWLYN, CORNWALL UNLESS NOTED OTHERWISE.
- G4. NORTH SHOWN INDICATIVE ONLY
- G5. THIS DRAWING IS TO BE READ IN CONJUNCTION WITH ALL RELEVANT SPECIFICATIONS, DRAWINGS, DETAILS AND OTHER DESIGN INFORMATION.
- G6. ALL DRAWINGS AND WRITTEN MATERIAL CONTAINED WITHIN, CONSTITUTE ORIGINAL AND UNPUBLISHED WORK OF THE ENGINEER AND MAY NOT BE DUPLICATED, USED, REPRODUCED OR DISCLOSED WITHOUT WRITTEN CONSENT OR EXPRESS PERMISSION FROM THE ENGINEER.
- G7. ALL INFORMATION CONTAINED IN THIS DOCUMENT IS COPYRIGHT ©
- G8. WHERE THE CONTRACTOR UNDERTAKES OR ENGAGES A THIRD PARTY TO UNDERTAKE TEMPORARY WORKS DESIGN, OR VARIES THE PELL FRISCHMANN DESIGN IN ANY WAY, THEN THE CONTRACTOR WILL TAKE FULL RESPONSIBILITY AND LIABILITY FOR ALL DESIGN ASPECTS, INCLUDING A DESIGN RISK ASSESSMENT. THE CONTRACTOR SHALL INFORM PELL FRISCHMANN OF ANY PROPOSED VARIANCES TO THE DESIGN.

- STORAGE 1 IN 100 YEAR NOT TO BE ADOPTED
- 5m EASEMENT
- MASS CONCRETE FOUNDATION

P02	ADDITIONAL INFORMATION ADDED	PC	AH	AH	11.12.24
P01	FIRST ISSUE	PC	AH	AH	24.05.24
REV	DESCRIPTION	DRN	CHK	APP	DATE

Pell Frischmann
4th FLOOR, ONE ST JAMES SQUARE, MANCHESTER, M2 6DN
Telephone +44 (0)161 826 9400
Email: pfmmanchester@pellfrischmann.com
www.pellfrischmann.com

Architect/Client/Contractor

greatplaces
HOUSING GROUP

Project

LONGHURST ROAD

Drawing Title

**S104
ATTENUATION
FOUNDATION PLAN**

Drawing Status	PRELIMINARY			
Drawn	Name	Date	Status Code	S03
Designed	P. CLARK	24.05.24	Scale	
Eng Chk	P. CLARK	24.05.24	Scale	1:200
Approved	A. HALL	24.05.24	Revision	
Drawing No.	A. HALL	24.05.24	Revision	P02

106240 - PEL - HDG - 01 - DR - D - 1007