



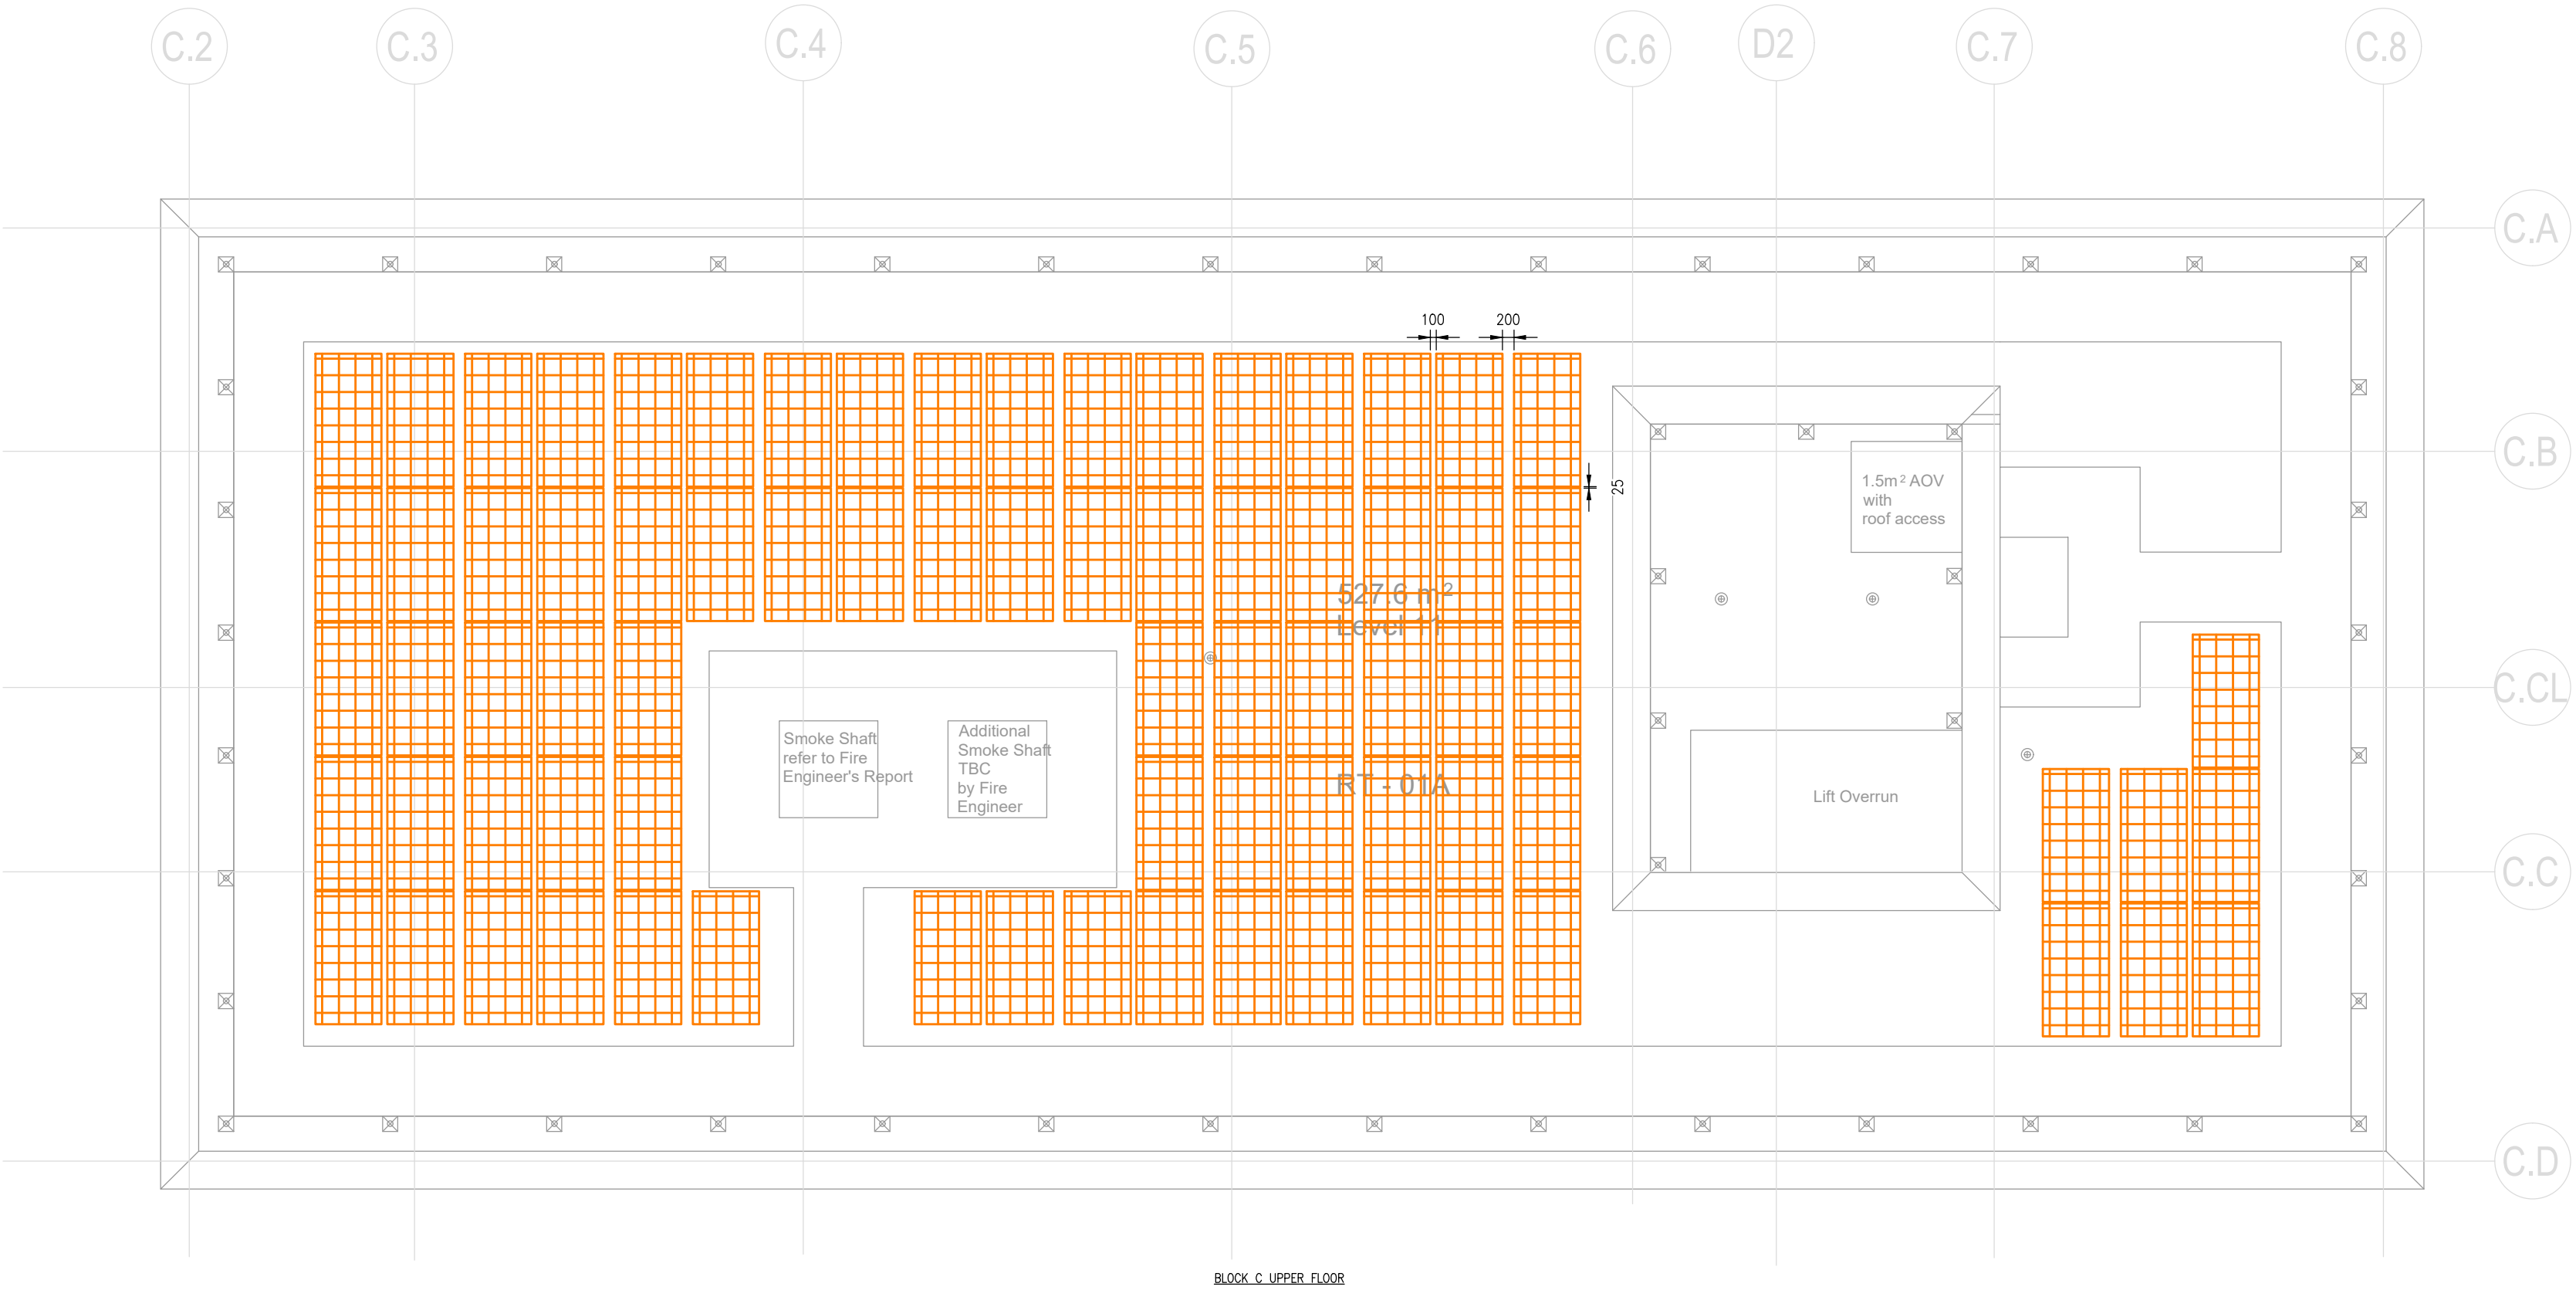

BLOCK C UPPER FLOOR

PHOTOVOLTAIC SYSTEM BASED ON 500W
PANELS TO ACHIEVE 39.48kWp CURRENTLY
SHOWING 78 PANELS IN TOTAL


FINAL DESIGN BY SPECIALIST

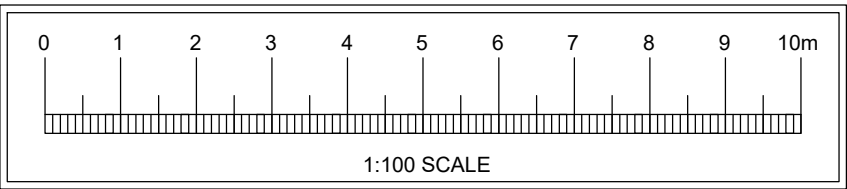

© PROTECTED BY UK COPYRIGHT LAW
DO NOT SCALE OFF THIS DRAWING

DESIGNERS RISK ASSESSMENT
Under section 11, 18 - Construction (Design and Management)
Regulations 2015

SAFETY, HEALTH & ENVIRONMENTAL INFORMATION
There are no significant, unusual or location specific risks which are
not obvious to a competent contractor or likely to be difficult to
manage

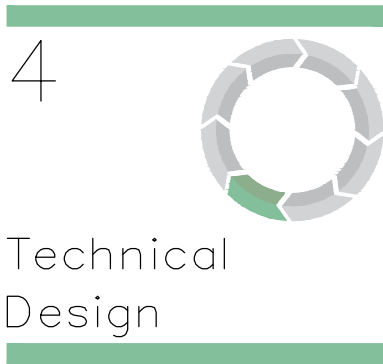

-	P02	PV UPDATED TO SUIT GLAZING SPECIFICATION	CW	BD	07.08.23
-	P01	PRELIMINARY ISSUE	CW	BD	24.07.23
STA	REV	DESCRIPTION	DES	CHD	DATE

PURPOSE OF ISSUE
PRELIMINARY

NOVO
Integration Ltd
7 Feast Field, Horsforth, Leeds,
West Yorkshire, LS18 4TJ
t: +44(0)113 2577300 e: novocad@novo.eu.com

SALBOY

CLIENT

PROJECT
WATERHOUSE GARDENS
MANCHESTER

TITLE
ELECTRICAL SERVICES
BLOCK C
UPPER ROOF PLAN
PV LAYOUT

SCALE 1:100	ORIGINAL SIZE A1	DATE JUL '23
DRAWN EG	DESIGNED CW	CHECKED BD