


PLAN SHOWING EXTRACT ~ 1ST FLOOR & DELIVERY BAY
~NOTE: SCALE 1;50

SECTION SHOWING EXTRACT ~ 1ST FLOOR PLANTROOM

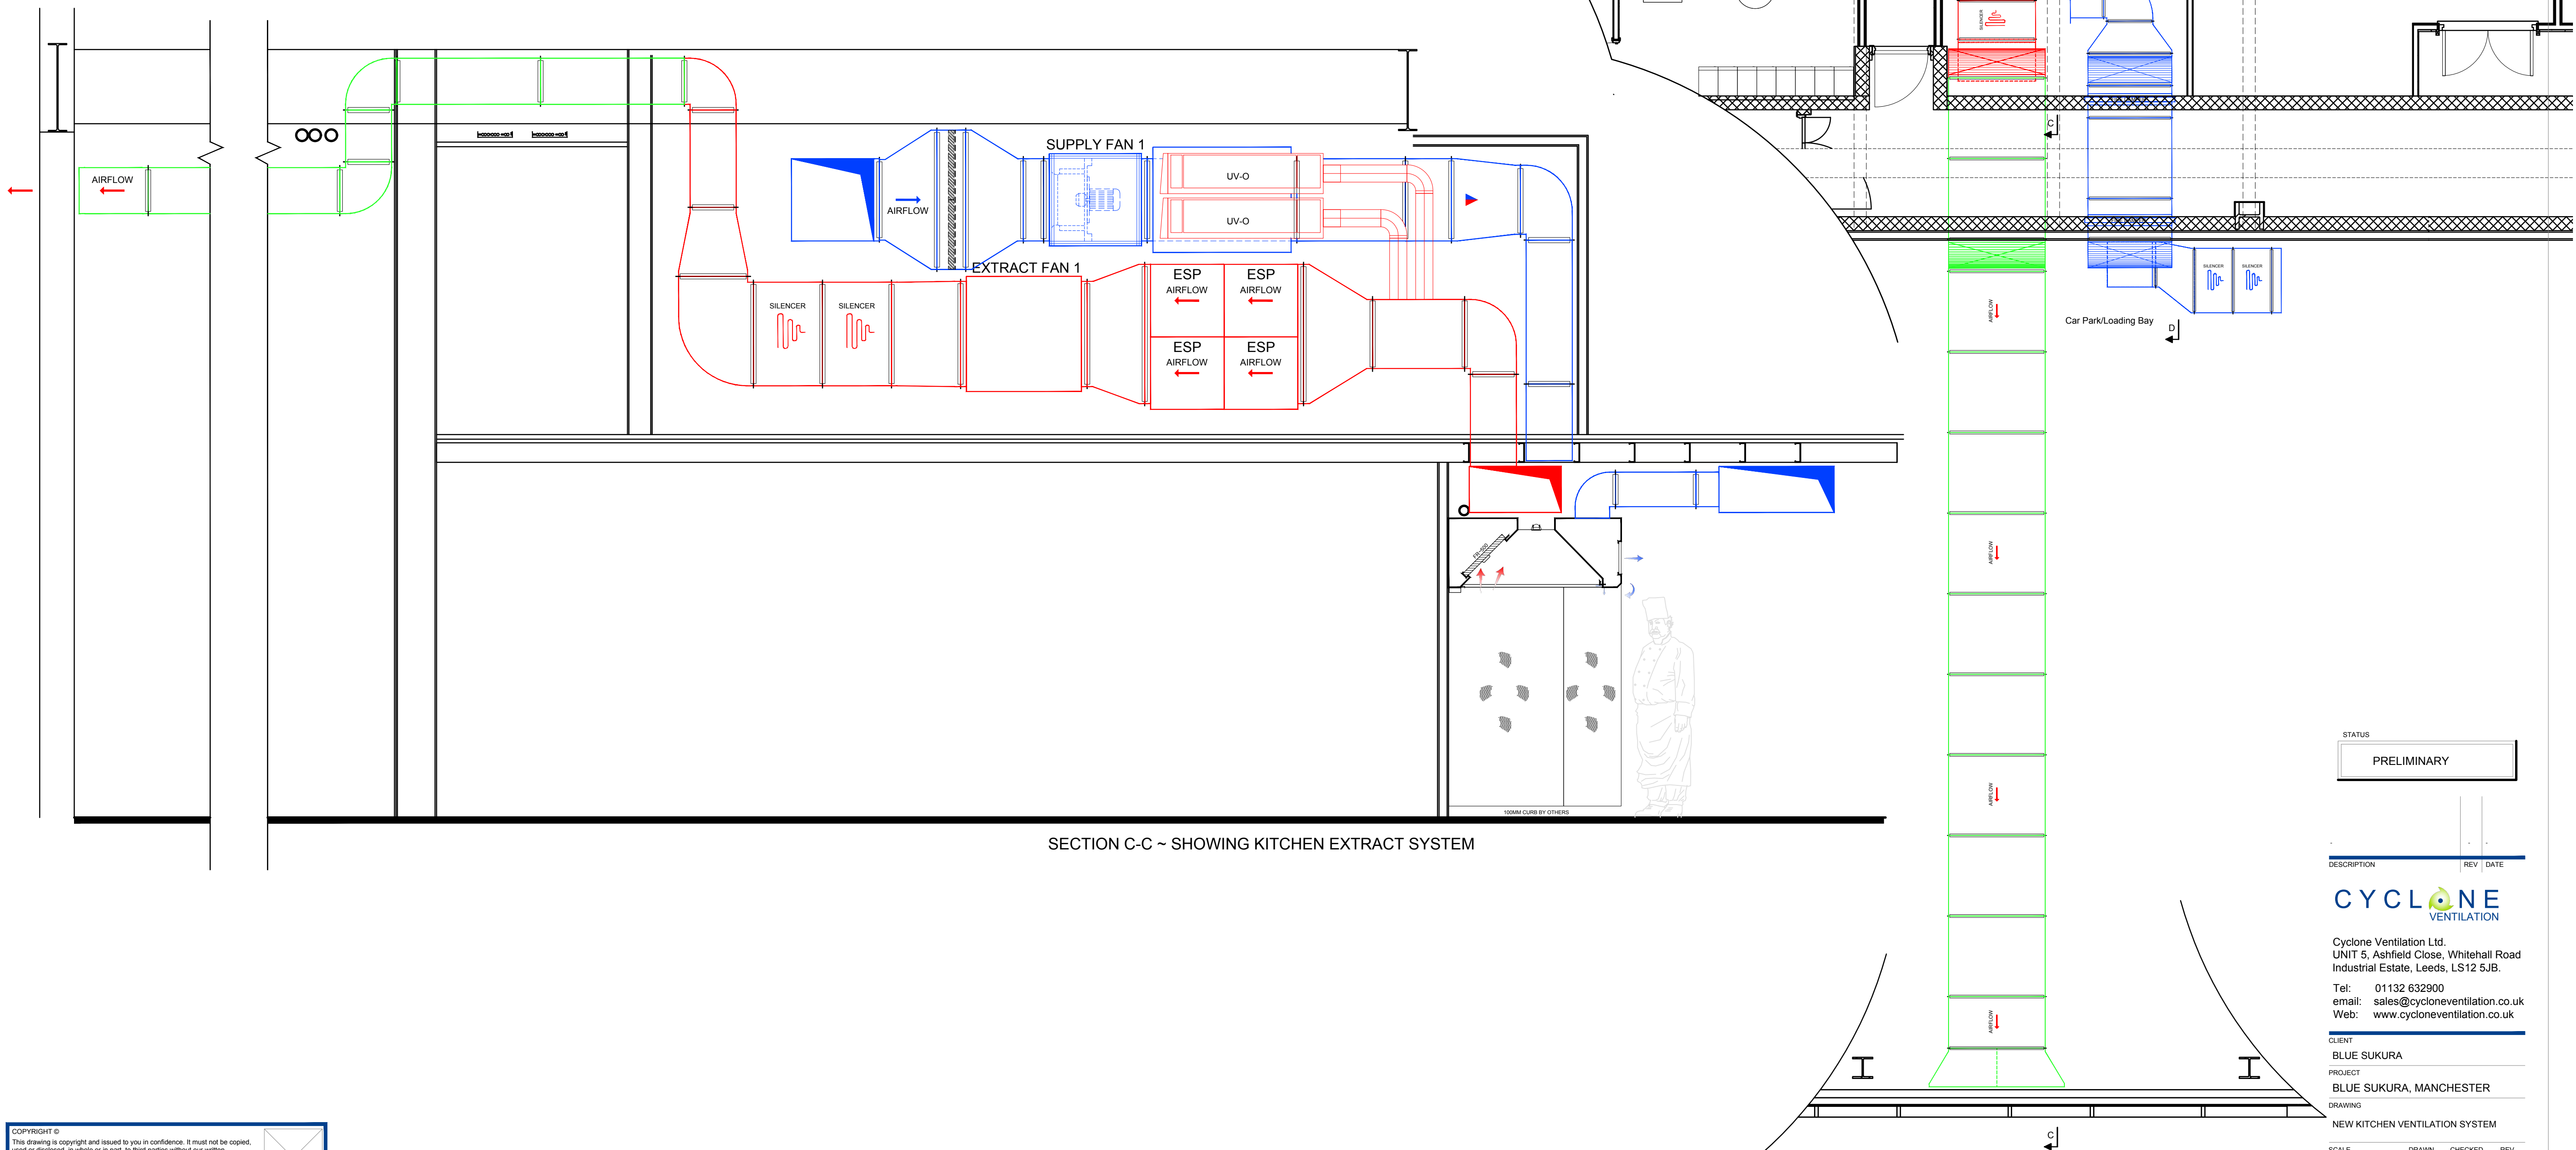

COPYRIGHT ©
This drawing is copyright and issued to you in confidence. It must not be copied, used or disclosed, in whole or in part, to third parties without our written permission. It remains the property of CYCLONE VENTILATION LIMITED and must be returned on request. ©
NOTE: All dimensions are in millimetres unless stated otherwise. If in doubt ask. Do not scale from this drawing.
DRAWING INFORMATION
This CAD drawing is plotted from file: C:\24-1285-001
This CAD drawing contains the following Xrefs: CV24-1285-001

LAYER KEY		
FIRE RATED DUCTWORK	EXTRACT DUCTWORK	SUPPLY DUCTWORK

STATUS	
PRELIMINARY	

DESCRIPTION	REV	DATE
-------------	-----	------

CYCLONE VENTILATION

Cyclone Ventilation Ltd.
UNIT 5, Ashfield Close, Whitehall Road
Industrial Estate, Leeds, LS12 5JB.
Tel: 01132 632900
email: sales@cycloneventilation.co.uk
Web: www.cycloneventilation.co.uk

CLIENT
BLUE SUKURA

PROJECT
BLUE SUKURA, MANCHESTER

DRAWING
NEW KITCHEN VENTILATION SYSTEM

SCALE	DRAWN	CHECKED	REV.
1:28@A1	CJW	RPW	

DATE	JOB NO.	DWG. NO.
OCT 2024	CV24-1285	003

Original sheet size A1