

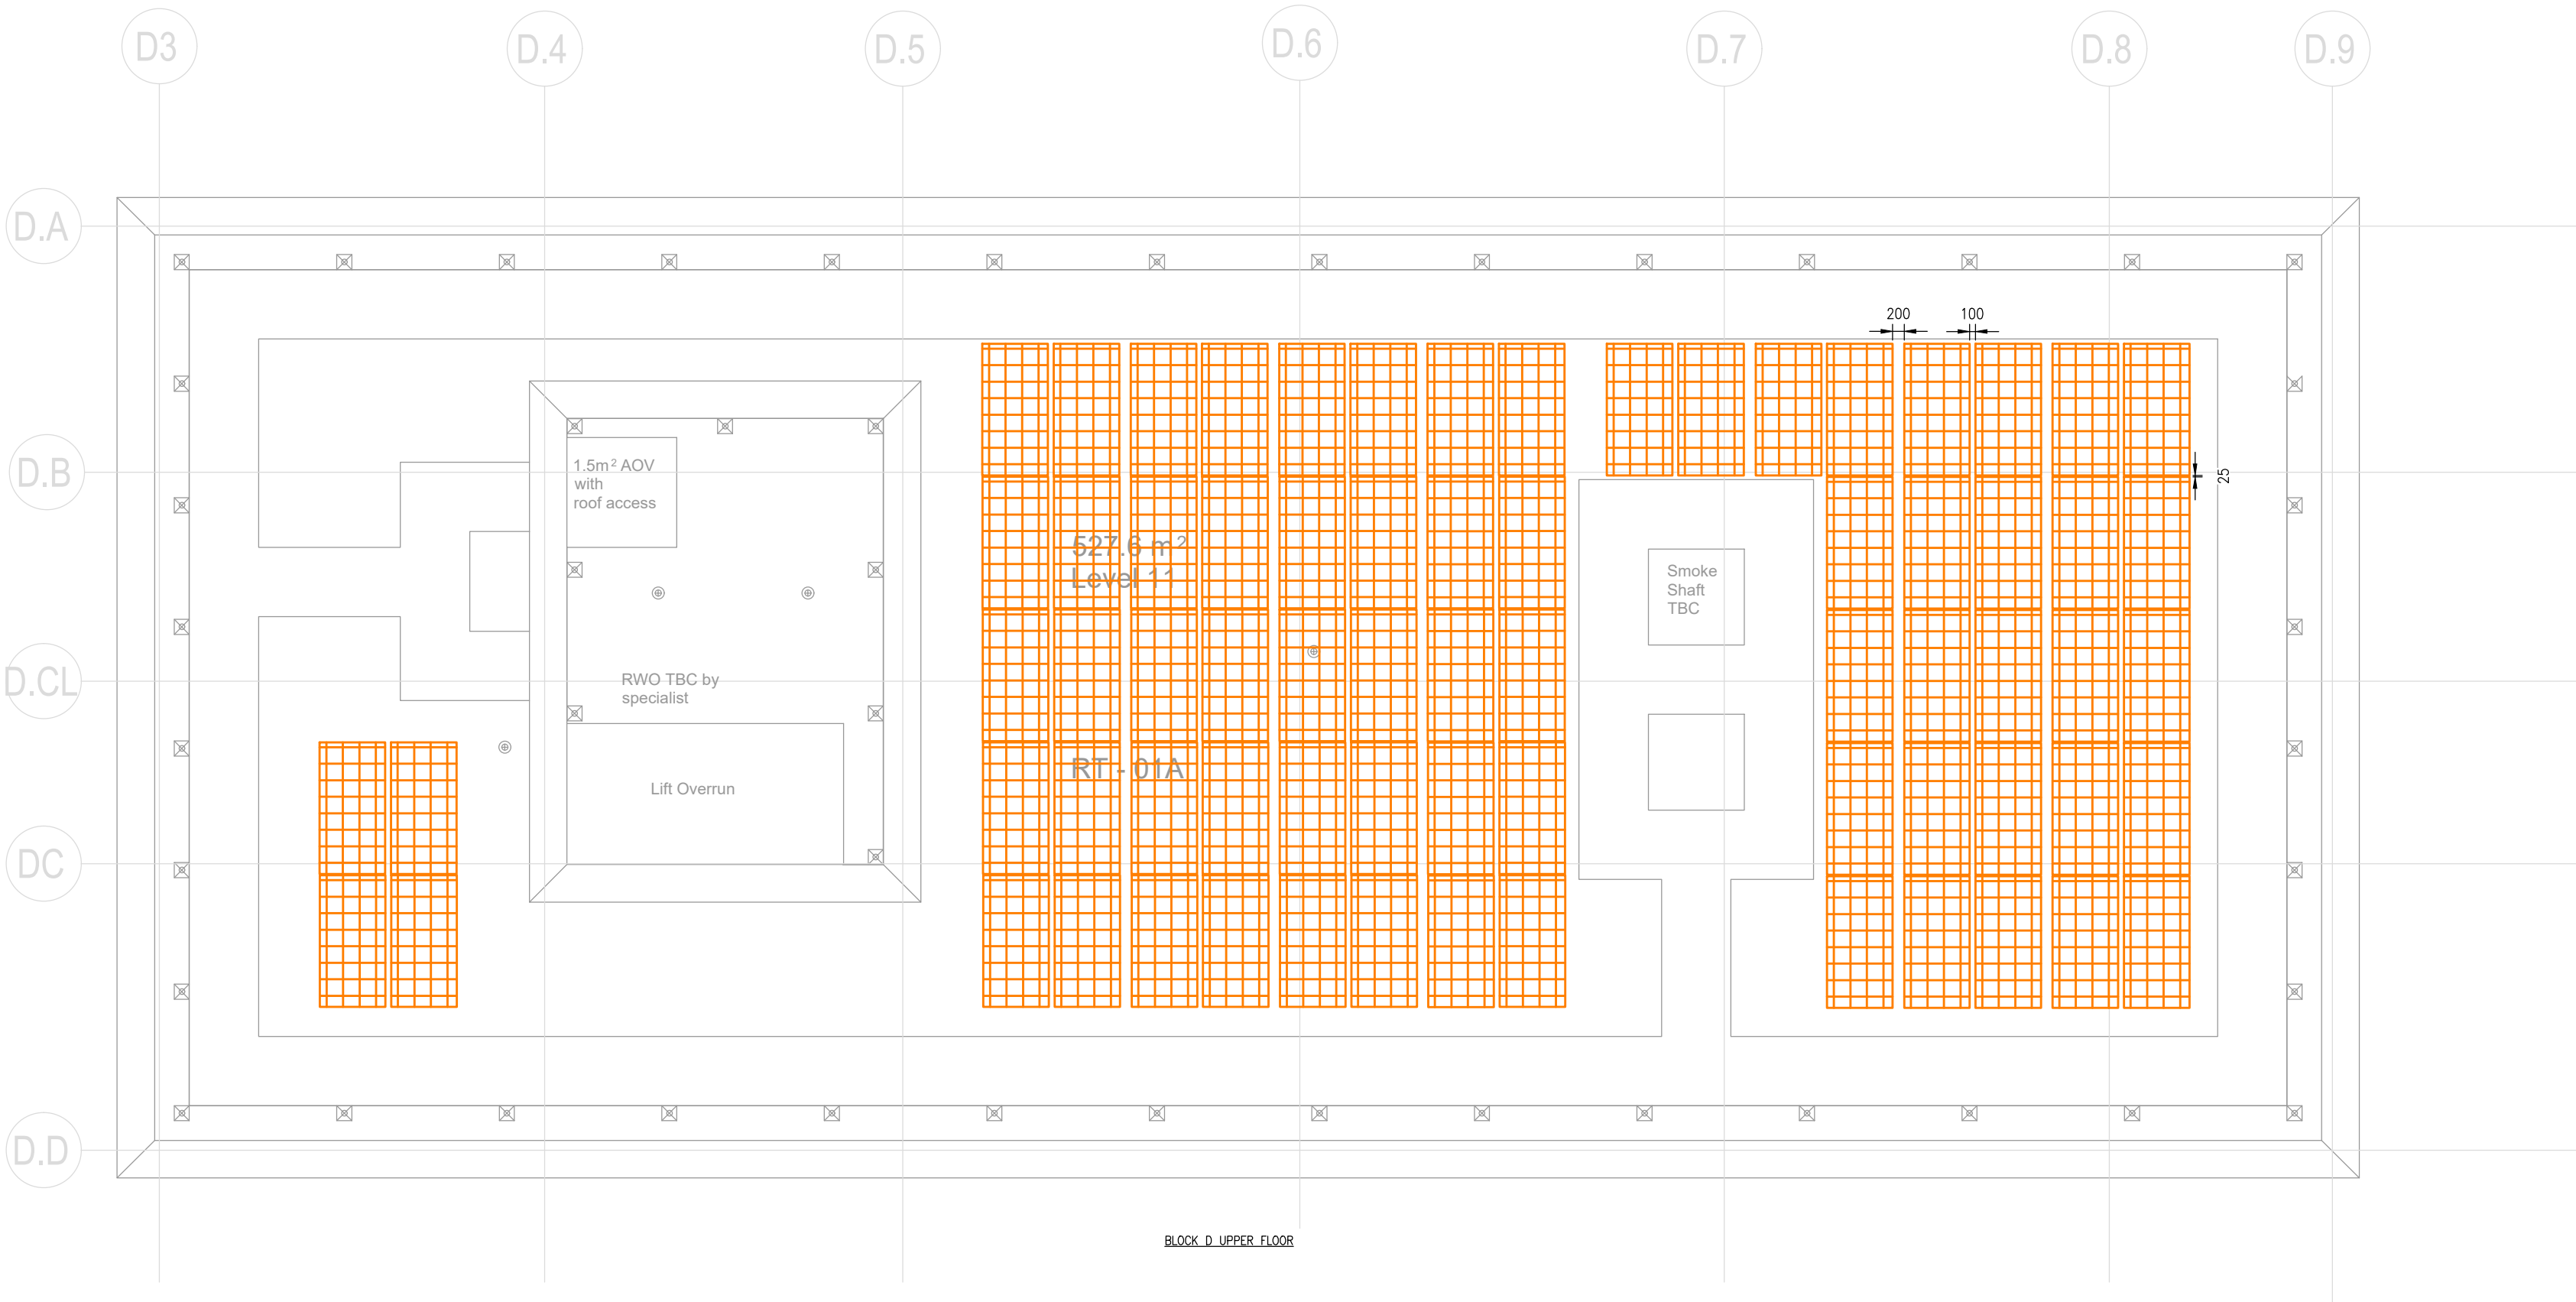


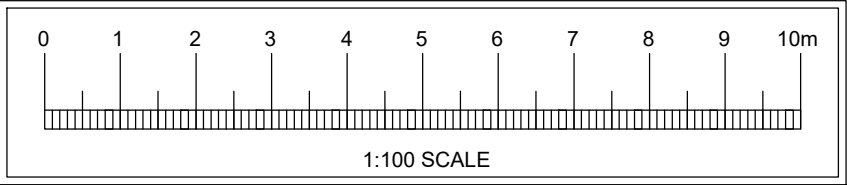

PHOTOVOLTAIC SYSTEM BASED ON 500W
PANELS TO ACHIEVE 38.54kWp CURRENTLY
SHOWING 72 PANELS IN TOTAL

FINAL DESIGN BY SPECIALIST

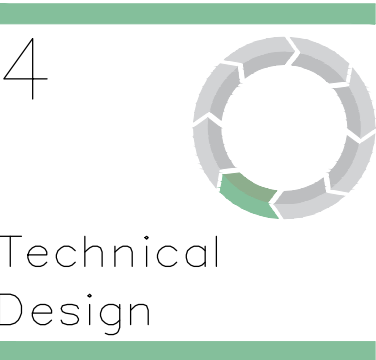

-	P01	PRELIMINARY ISSUE	CW	BD	07.08.23
STA	REV	DESCRIPTION	DES	CHD	DATE

PURPOSE OF ISSUE	PRELIMINARY
------------------	-------------

NOVO
Integration Ltd
7 Feast Field, Horsforth, Leeds,
West Yorkshire, LS18 4TJ
t: +44(0)113 2577300 e: novocad@novo.eu.com

CLIENT	SALBOY
PROJECT	WATERHOUSE GARDENS MANCHESTER
TITLE	ELECTRICAL SERVICES BLOCK D UPPER ROOF PLAN PV LAYOUT

SCALE	ORIGINAL SIZE	DATE
1:100	A1	JUL '23
DRAWN	DESIGNED	CHECKED
EG	CW	BD

REVISION

P01