

Space Number	Space Name	ADBCode	ADBDescription	ADBGroup
G.C02	Circ GF03	DAT902	Double Gang R445 Outlet	1
G.C02	Circ GF03	FAP901	Fire Alarm Interface Unit	1
G.C02	Circ GF03	FAP921	Fire alarm Manual Call Point	1
G.C02	Circ GF03	LGH001	Lighting Fixture	1
G.C02	Circ GF03	MEC001	Mechanical Equipment	1
G.C02	Circ GF03	OUT920	Single Switched Socket Outlet - Plastic	1

Space Number	Space Name	ADBCode	ADBDescription	ADBGroup
G.C03	Circ GF04	DAC000	Access Control Panel	1
G.C03	Circ GF04	DAC001	Green Break Glass Manual Override	1
G.C03	Circ GF04	DAC015	Green Mushroom Push Button Release Switch	1
G.C03	Circ GF04	DAT902	Double Gang R445 Outlet	1
G.C03	Circ GF04	FAP901	Fire Alarm Interface Unit	1
G.C03	Circ GF04	FAP906	Fire Alarm Repeater Panel	1
G.C03	Circ GF04	LGH001	Lighting Fixture	1
G.C03	Circ GF04	OUT915	Key Switched Fused Connection Unit	1
G.C03	Circ GF04	OUT920	Single Switched Socket Outlet - Plastic	1
G.C03	Circ GF04	OUT927	Switched Fused Connection Unit - Plastic	1

Notes:


- This drawing is copyright.
- Do not scale dimensions from this drawing.
- This drawing is to be read in conjunction with all other relevant drawings.
- All discrepancies on this drawing are to be reported to the architect.
- Do not modify any element of this drawing.
- Use drawing only for purpose(s) issued.
- This drawing may contain colour.

Scale Bar


Key Plan

The following external model files are included within this drawing:

1 G.002 & C.003 - Circulation Floor Plan
1 : 50

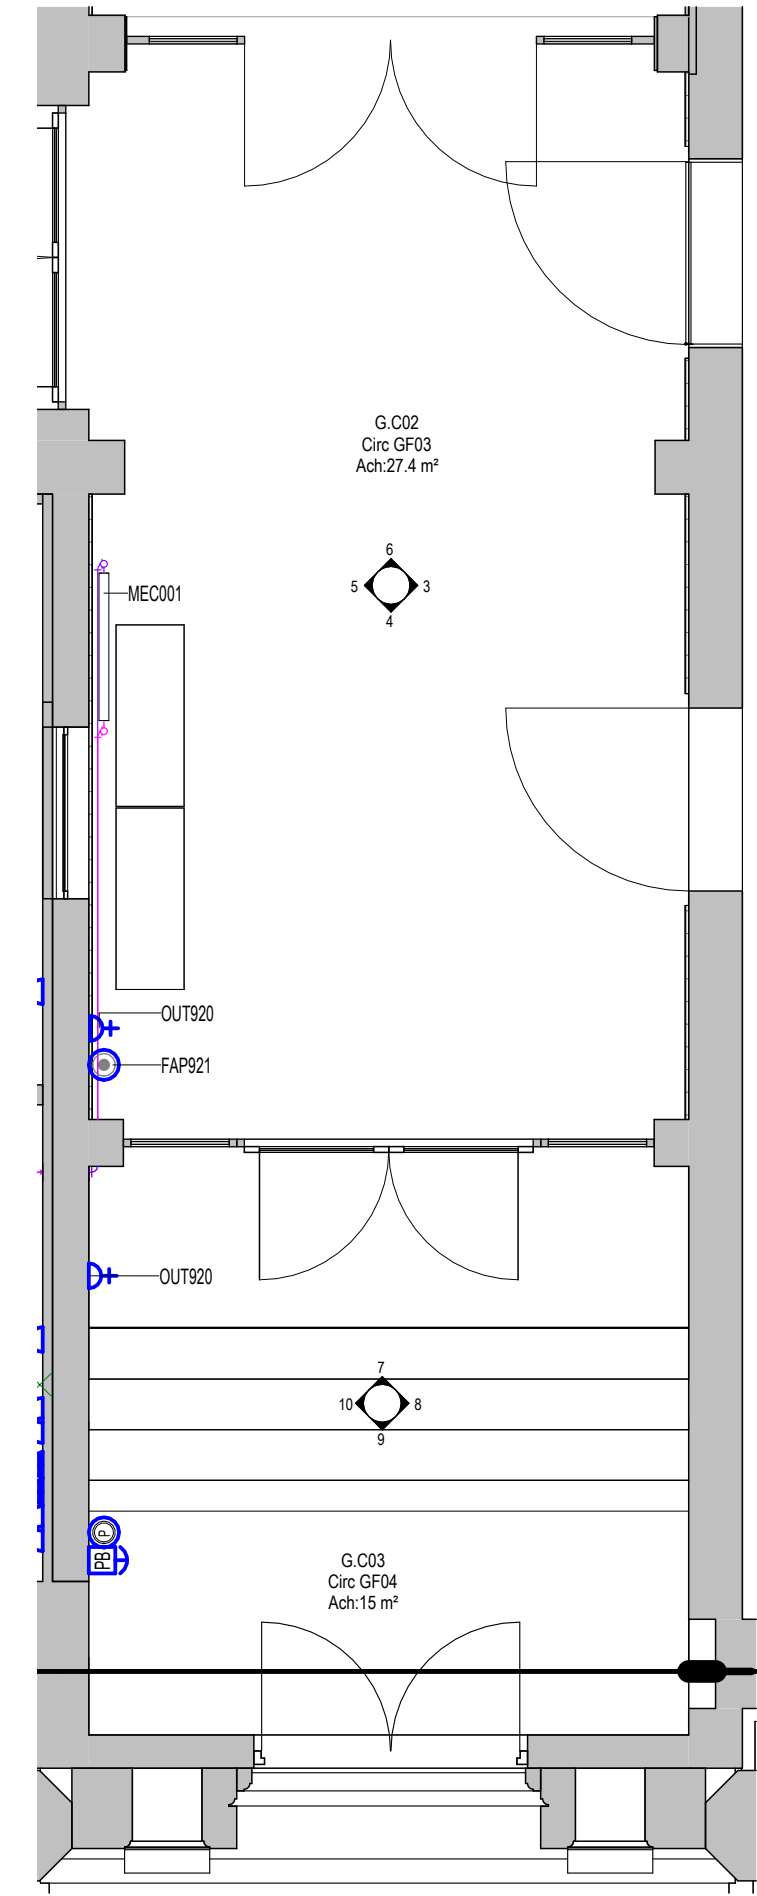


2 G.002 & C.003 - Circulation Isometric View
1 : 50

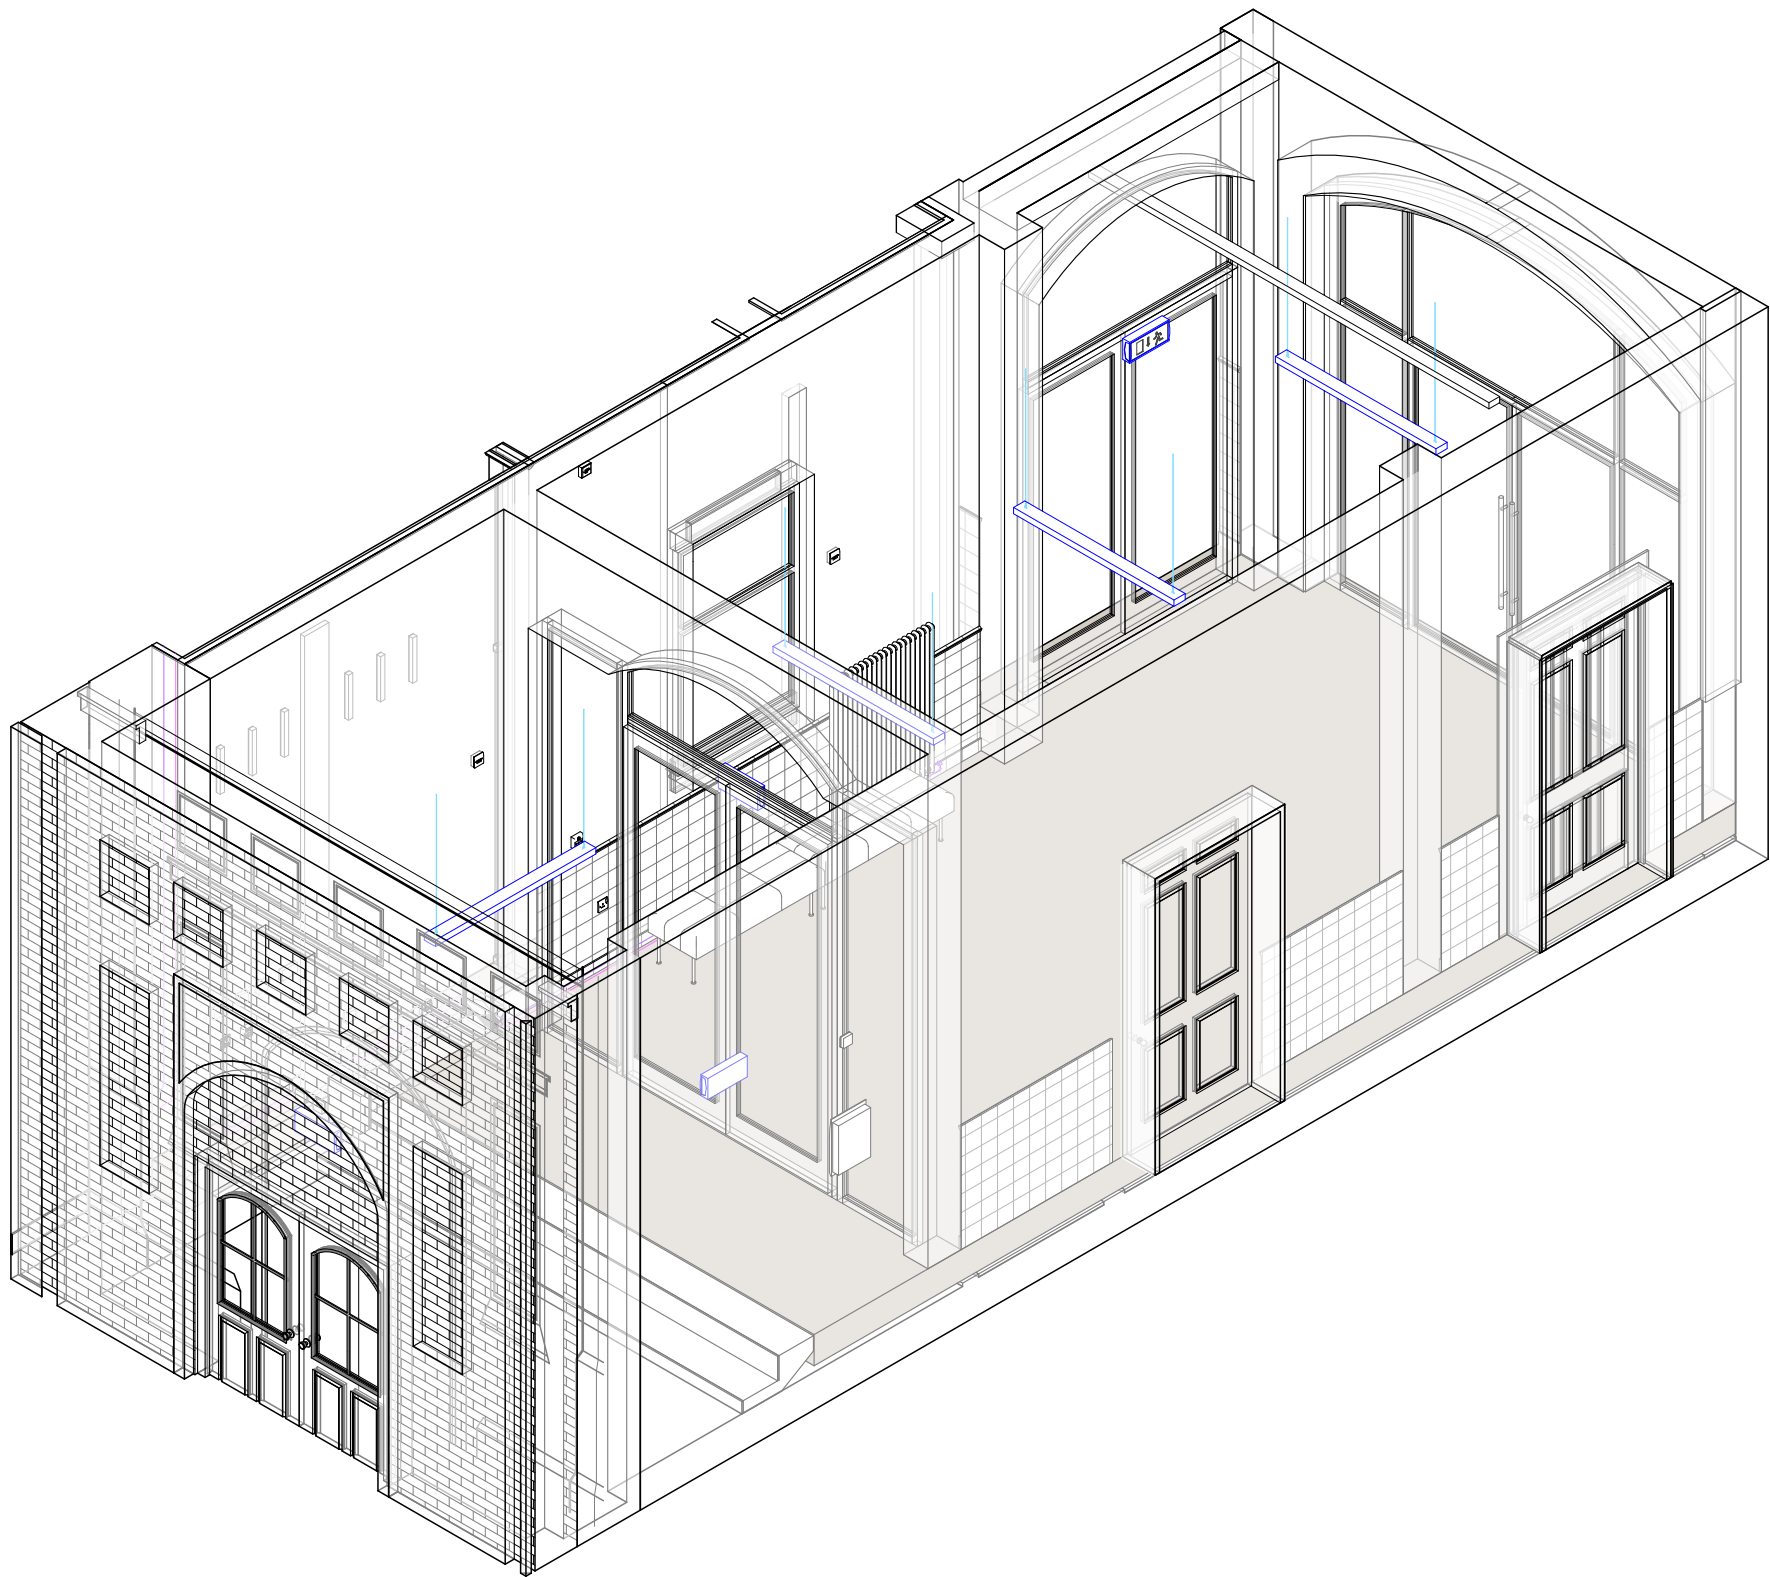


3 ELEVATION 3
1 : 50




4 ELEVATION 4
1 : 50

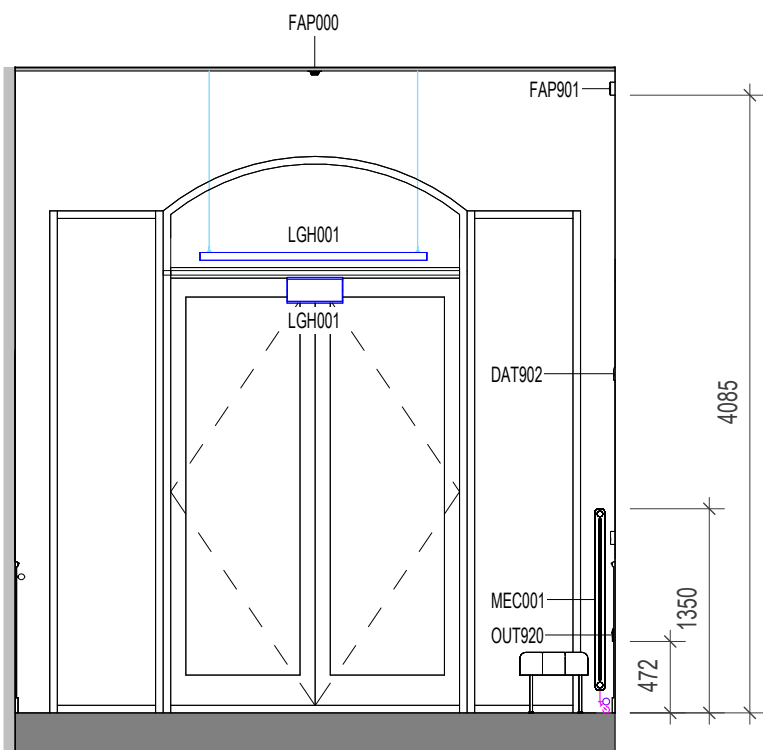


7 ELEVATION 7
1 : 50

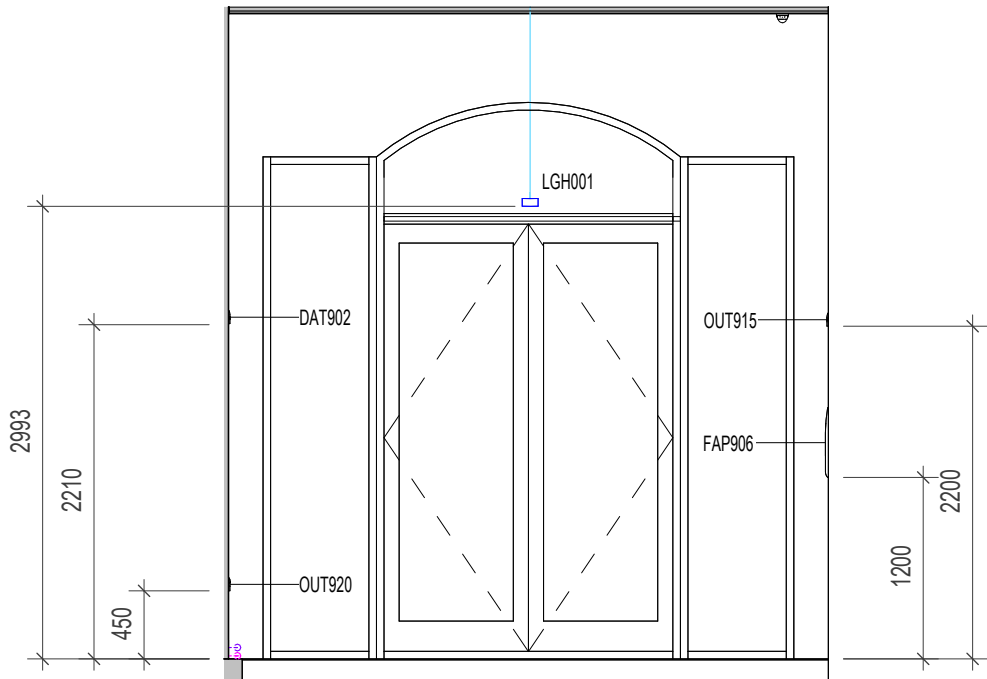


9 ELEVATION 9
1 : 50

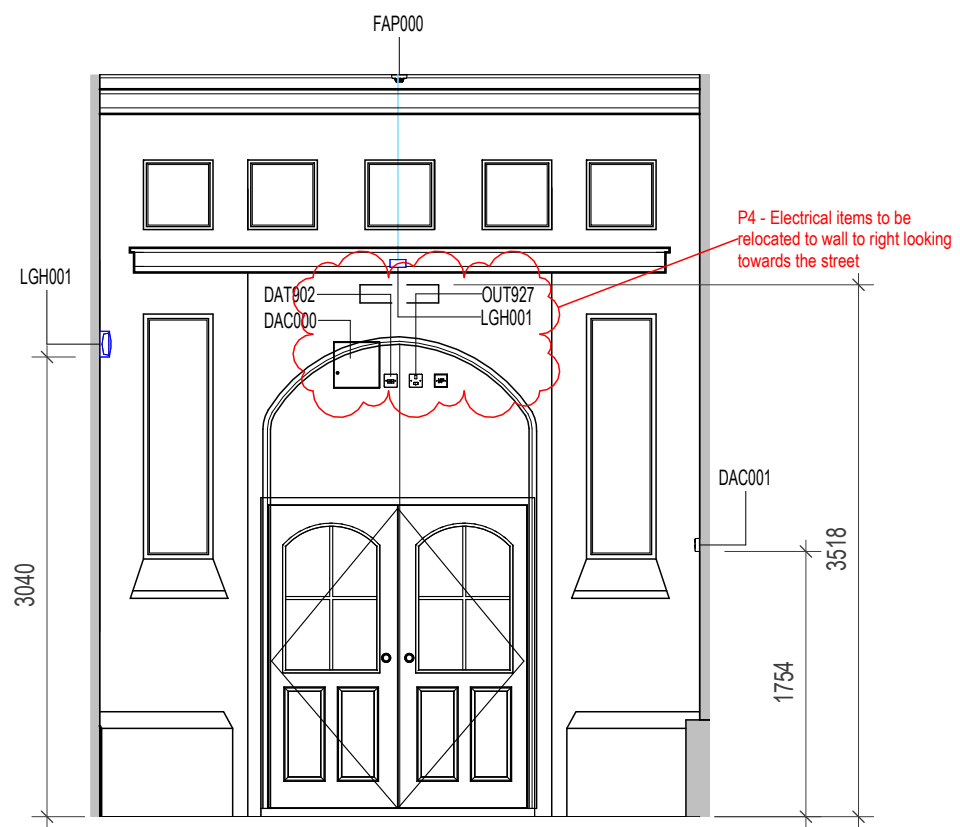


5 ELEVATION 5
1 : 50

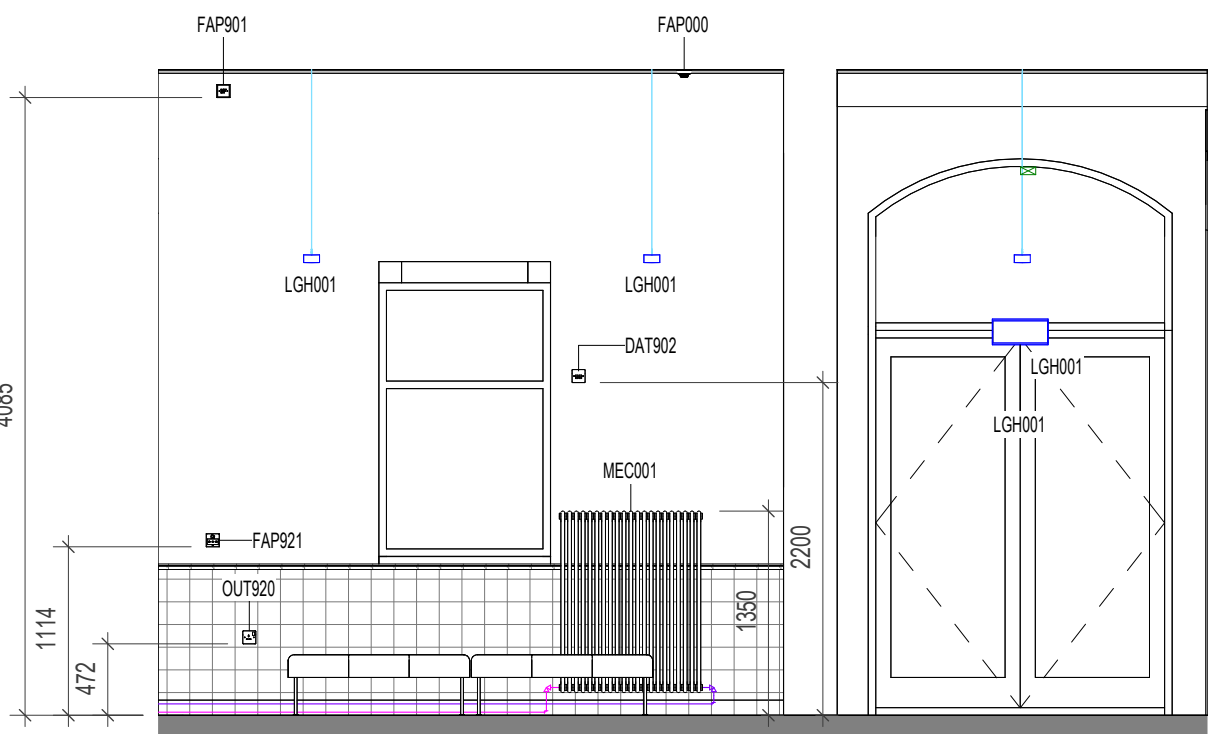


6 ELEVATION 6
1 : 50

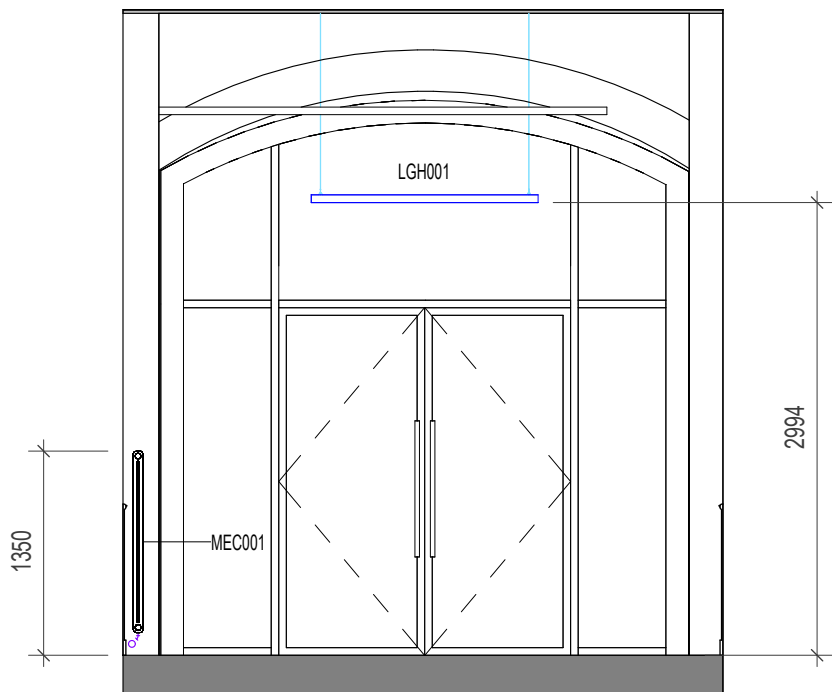

8 ELEVATION 8
1 : 50

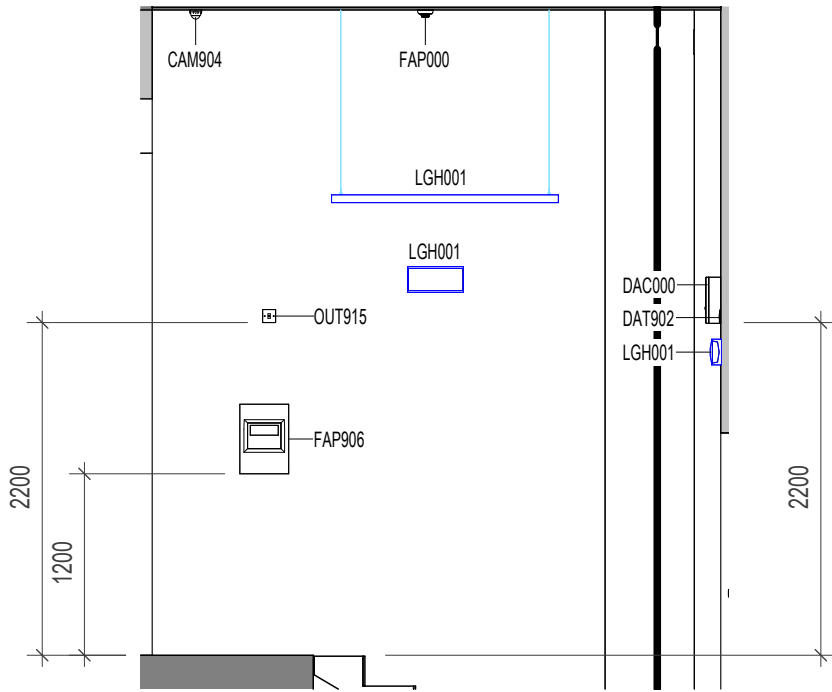

10 ELEVATION 10
1 : 50

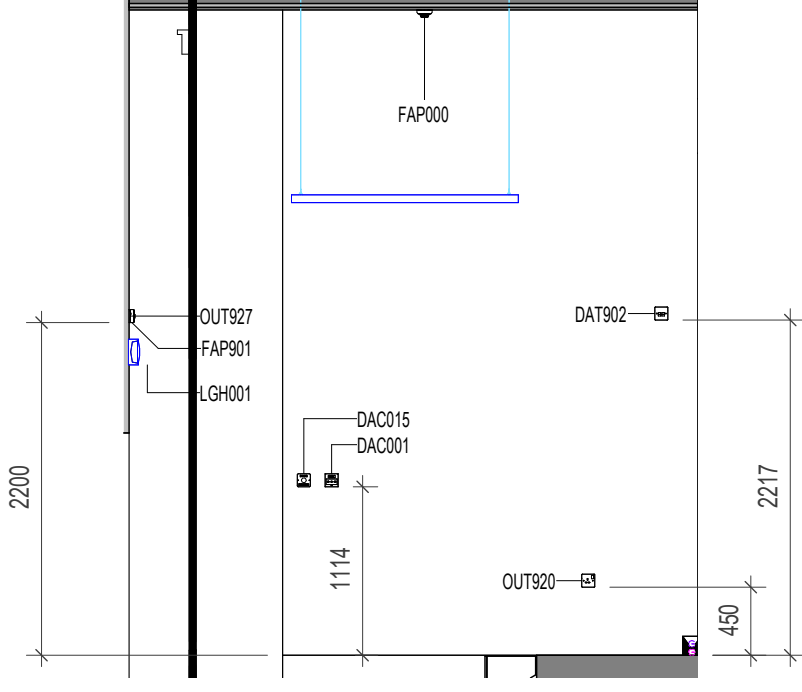

P4	2024/12/17	C-sheets issued to contractor	AB	RM
P3	2024/12/13	C-sheets issued to MCC	AB	RM
P2	2024/07/26	C-sheets issued to MCC	AB	RM
P1	2024/07/12	Co-ordination with MEP	AB	RM
Rev	Date	Revision Notes	Drawn	Review

MANCHESTER
1824
The University of Manchester

ARCADIS

Project
Rutherford Building

Drawing Title
G.002 & C.003 - Circulation

Job Number 141532	Date	Security Classification	Drawn By AJ
Scale@A1 1 : 50	Purpose LISTED BUILDING CONSENT	Reviewed By AB	Revision P4
Drawing Number 4906-RBUM-ARC-XX-ZZ-DR-A-4906			